

PROJECT DESCRIPTION:	
EM SIZE	220.32KW DC STC
MODULE TYPE	(459) JINKO SOLAR JKM480N-60HL4-V 480W

INDEX SHEET	
A.00	SITE PLAN
A.01	LAYOUT PLAN
S.00	FRAMING DETAILS
D.00-D05	SPECIFICATION SHEETS



Alderley
Congleton
Nether Alderley
Macclesfield
SK10 4

PRO.DATE	15/0
DESIGN BY	
CHECKED BY	

PROJECT NAME

MANCHESTER CITY P1B

SHEET NAME


SITE PLAN

SHEET SIZE

ANSI E
279 X 42

SHEET NUMBER

A.00

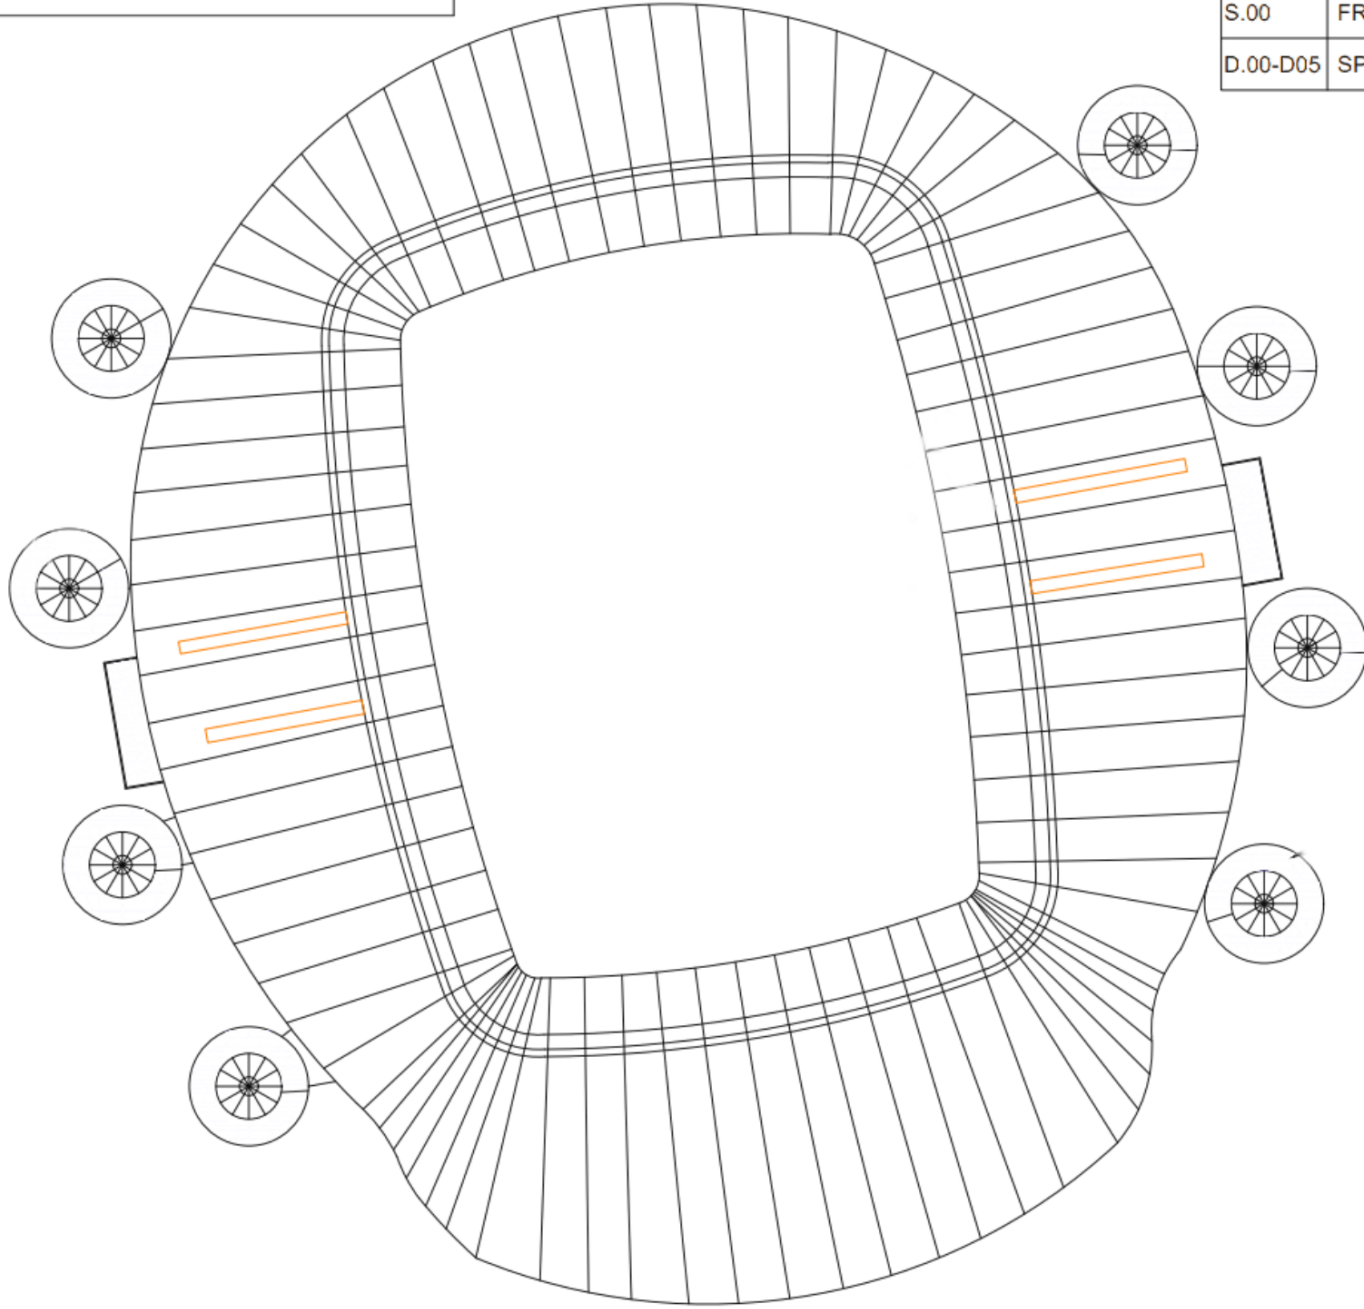

SITE PLAN
SCALE: 1:1000