



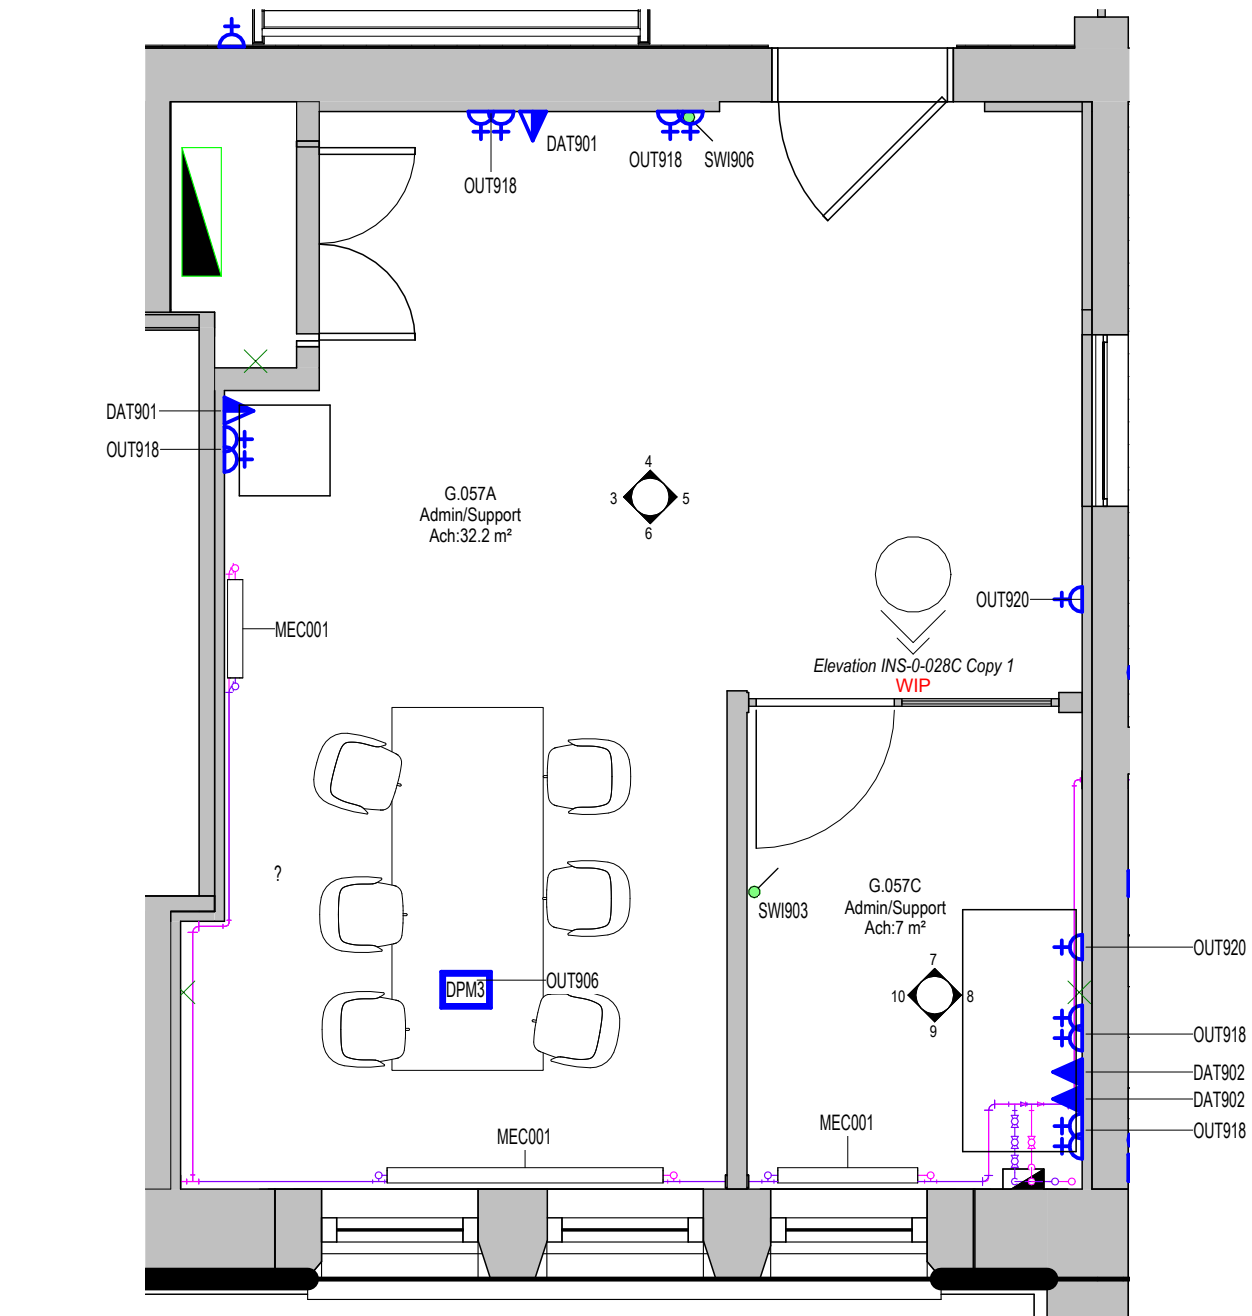

1 Meeting Room G.057 Floor Plan
1 : 50

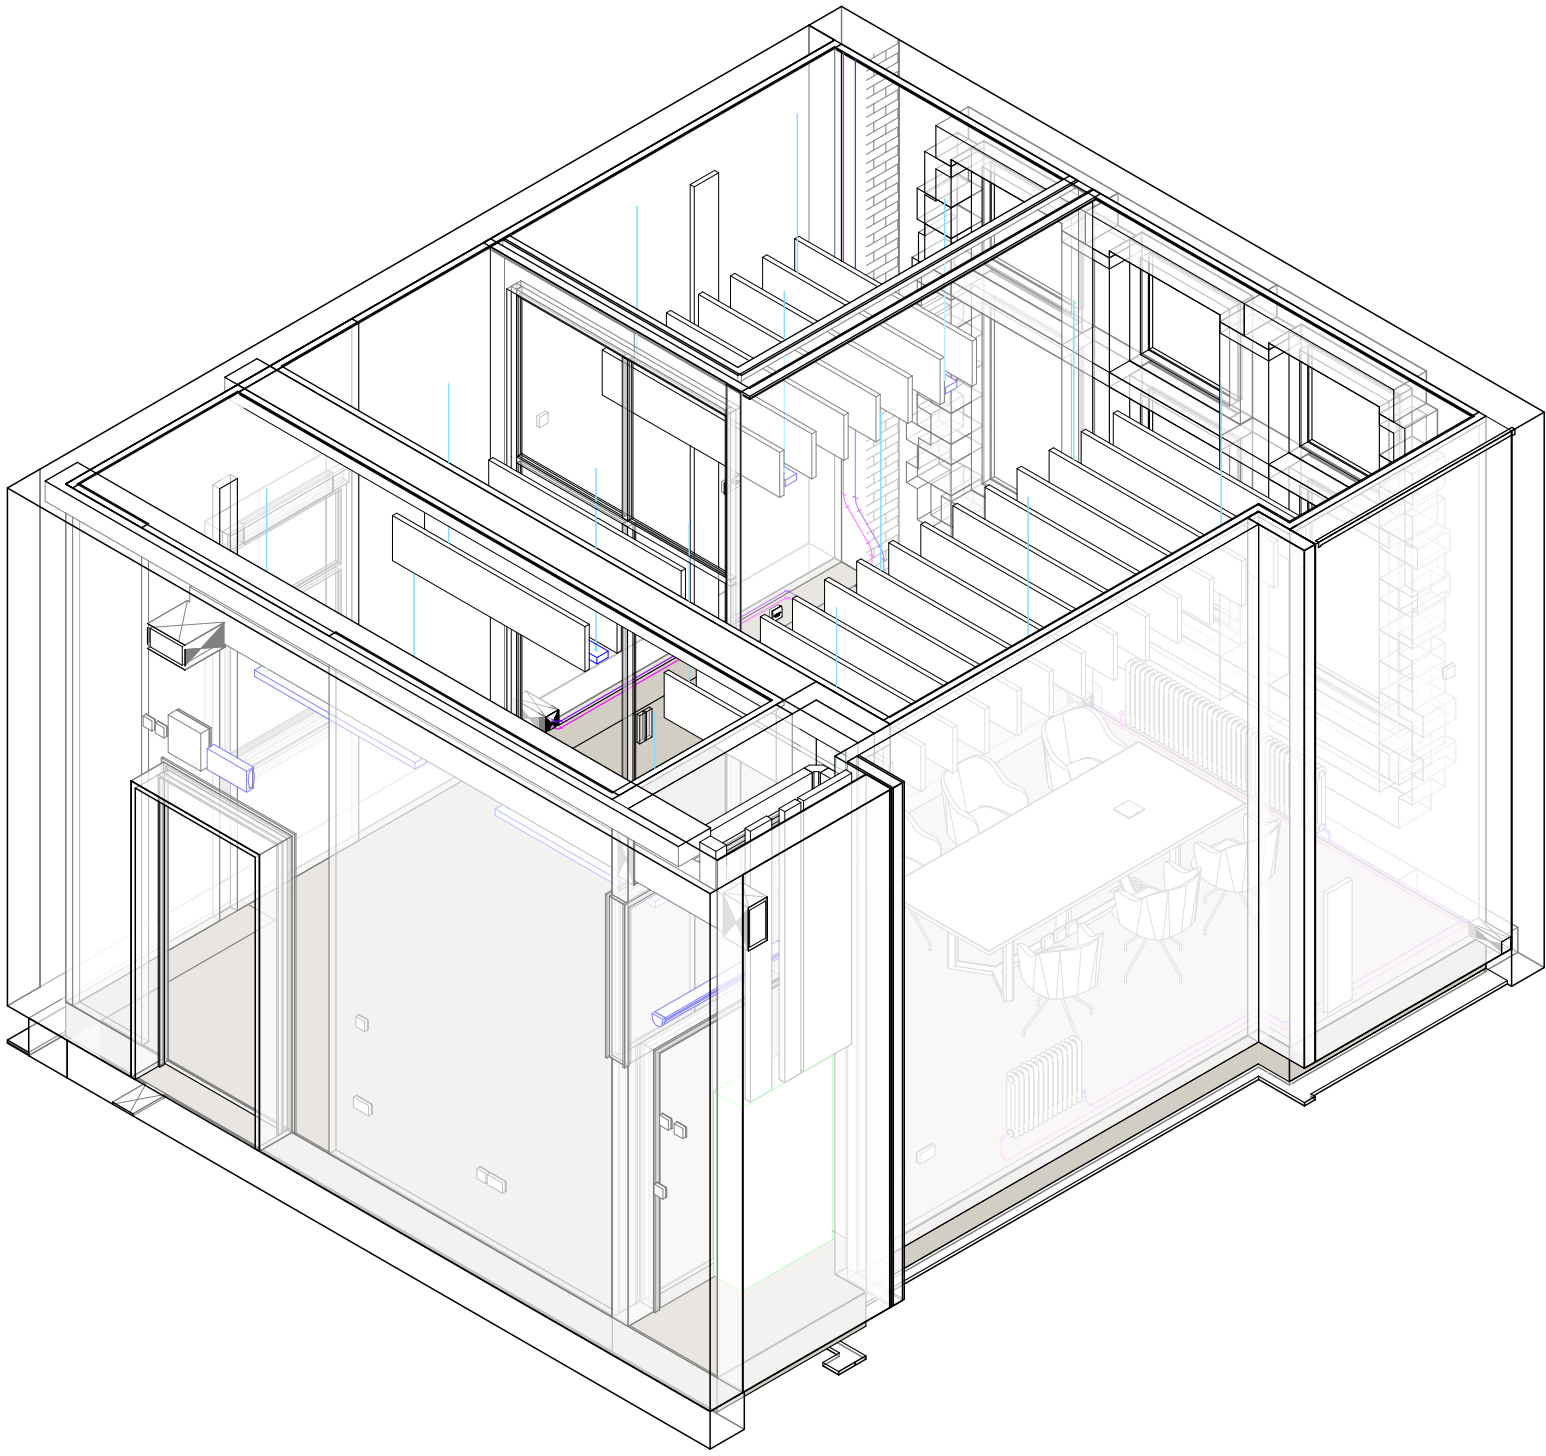

2 Meeting Room G.057 Isometric View

Space Number	Space Name	ADBCode	ADBDescription	ADBGroup
G.057A-1	Admin/Support-1	DAT902	Double Gang RJ45 Outlet	1
G.057A-1	Admin/Support-1	EFX001	Electrical Fixture	1
G.057A-1	Admin/Support-1	LGH001	Lighting Fixture	1
G.057A-1	Admin/Support-1	MEC001	Mechanical Equipment	1
G.057A-1	Admin/Support-1	OUT906	Automatic Changeover Switch	1

Space Number	Space Name	ADBCode	ADBDescription	ADBGroup
G.057C	Admin/Support	DAT902	Double Gang RJ45 Outlet	1
G.057C	Admin/Support	MEC001	Mechanical Equipment	1
G.057C	Admin/Support	OUT918	Double Switched Socket Outlet - Plastic	1
G.057C	Admin/Support	OUT920	Single Switched Socket Outlet - Plastic	1


Notes:

- This drawing is copyright.
- Do not scale dimensions from this drawing.
- This drawing is to be read in conjunction with all other relevant drawings.
- All discrepancies on this drawing are to be reported to the architect.
- Do not modify any element of this drawing.
- Use drawing only for purpose(s) issued.
- This drawing may contain colour.


Scale Bar

Key Plan


The following external model files are included within this drawing:

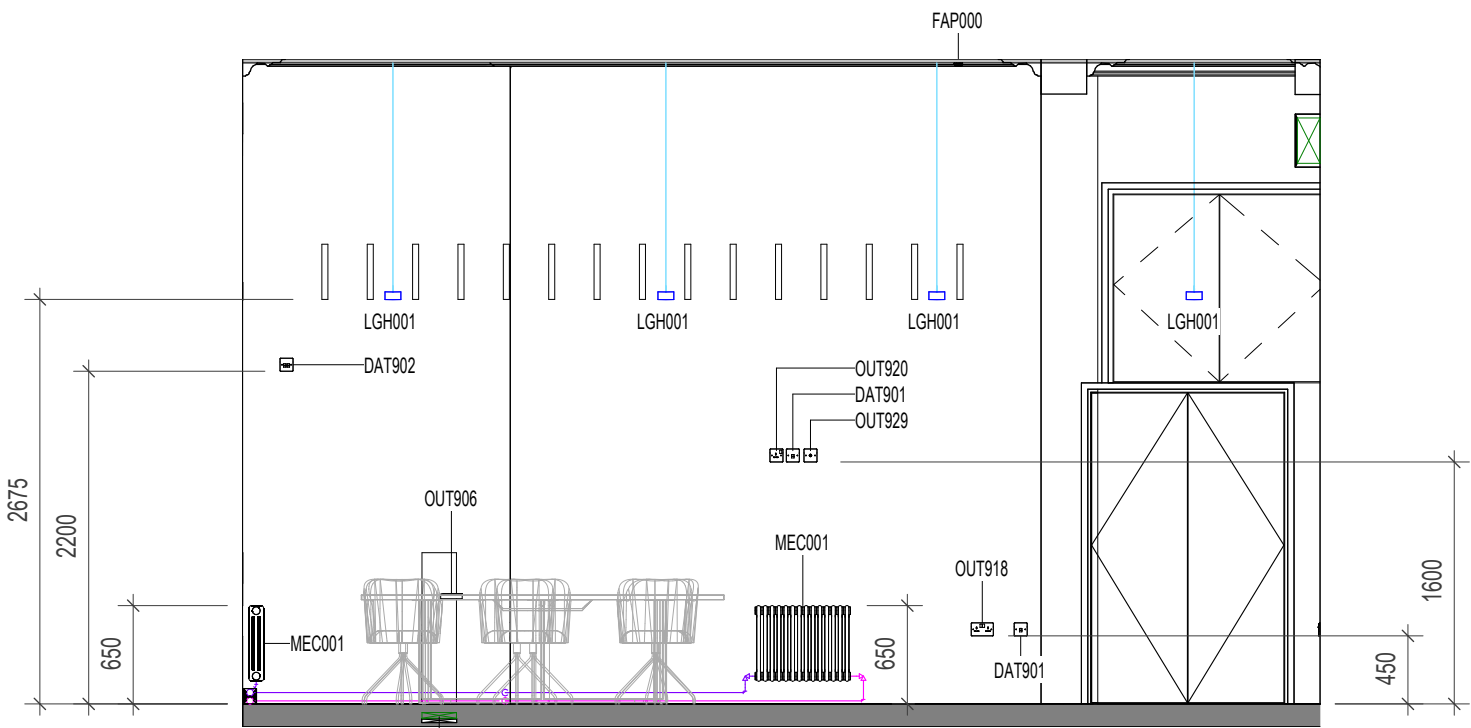


3 ELEVATION 3
1 : 50

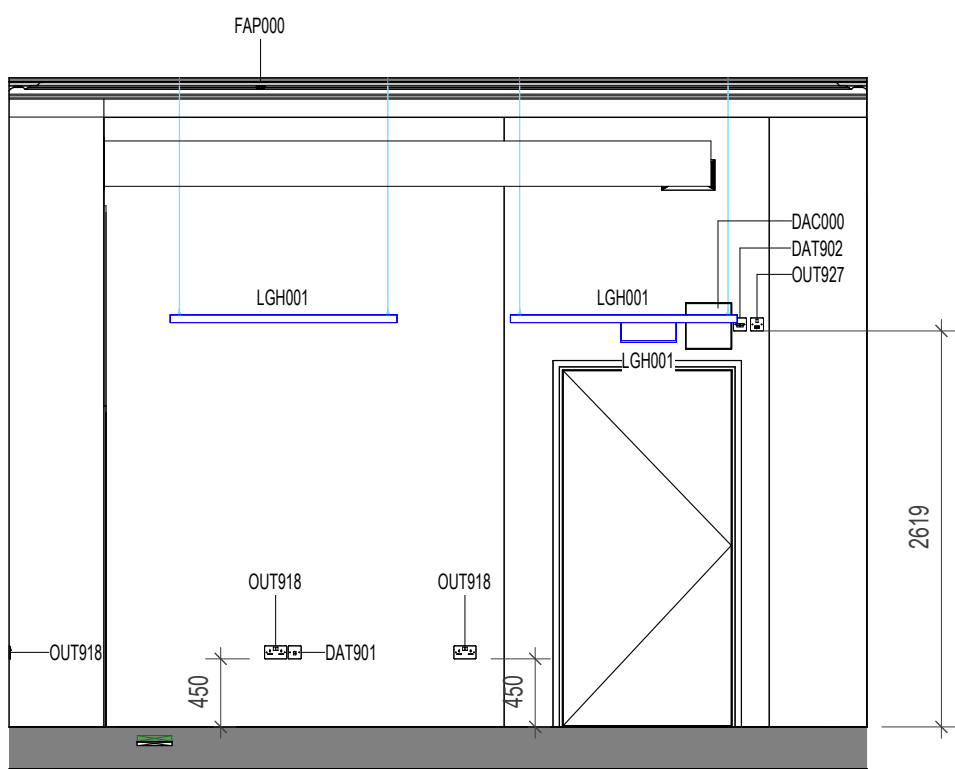


4 ELEVATION 4
1 : 50

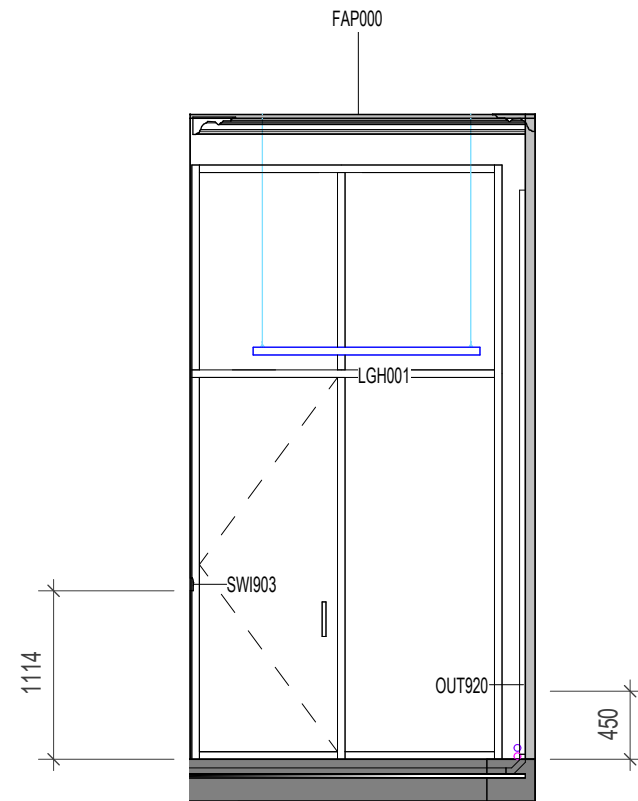


7 ELEVATION 6
1 : 50

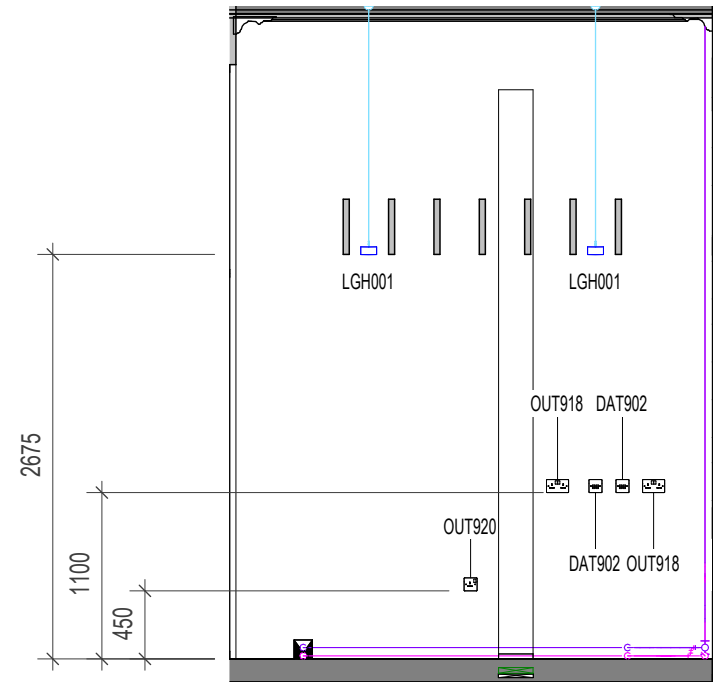


8 ELEVATION 7
1 : 50

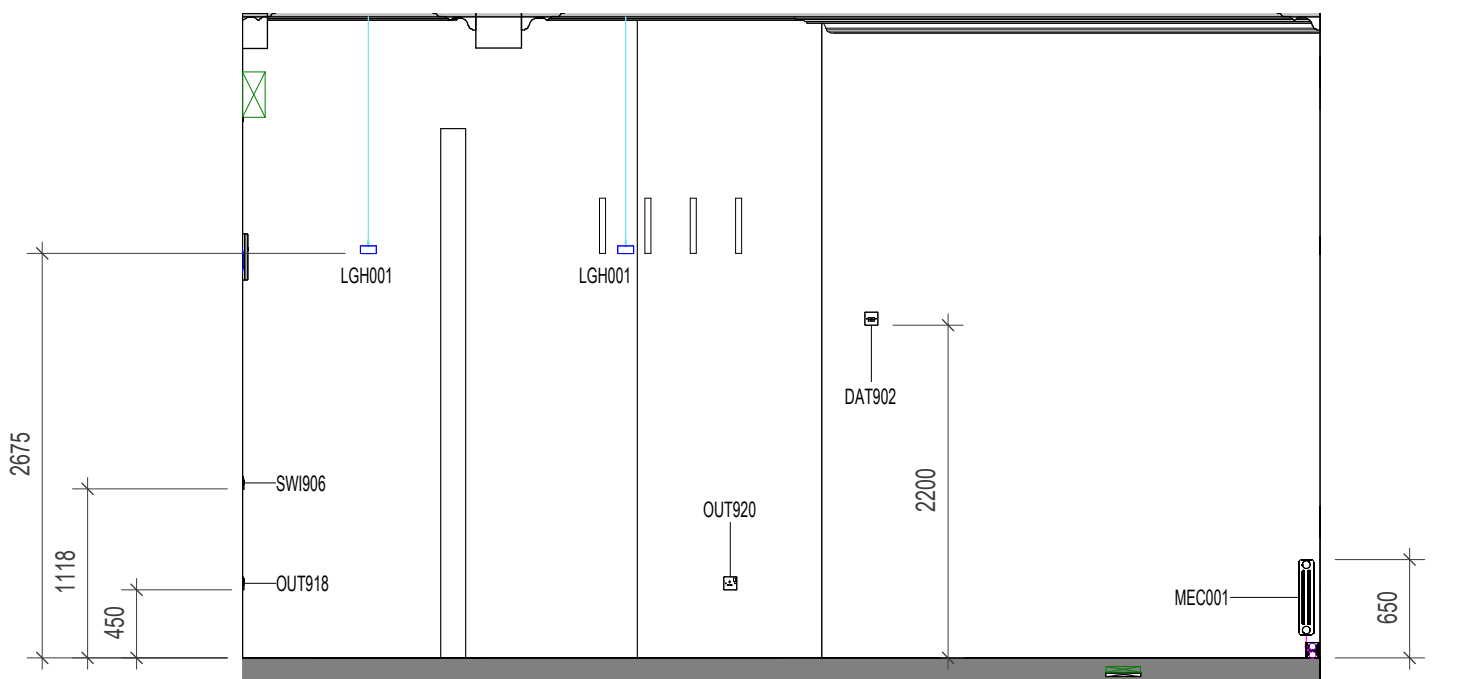


5 ELEVATION 5
1 : 50

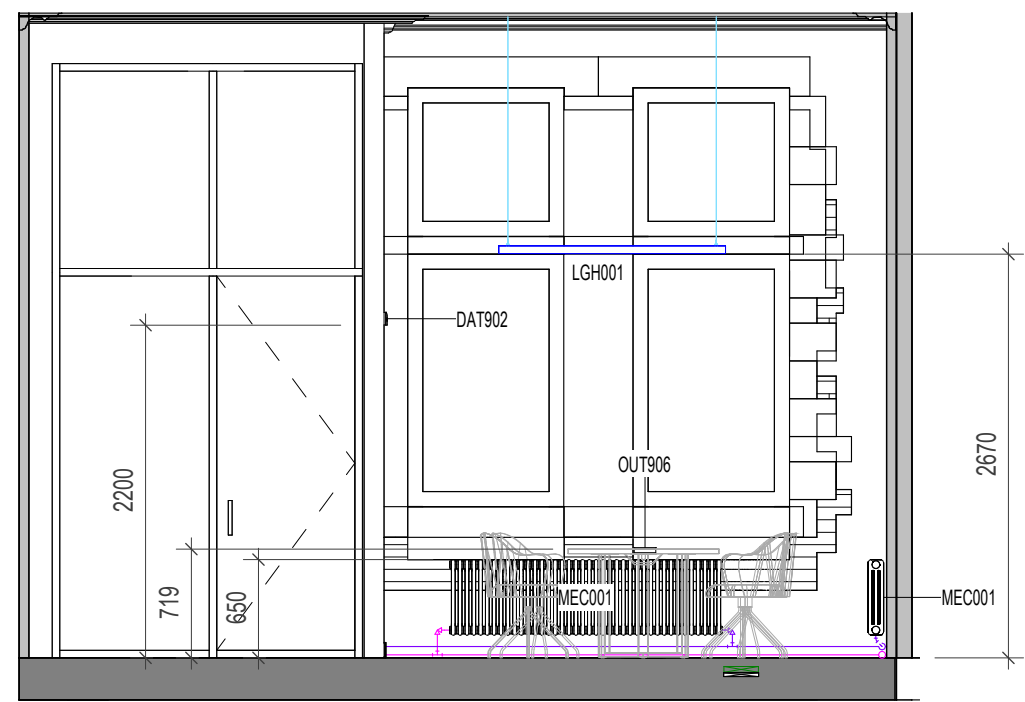

6 ELEVATION 6
1 : 50

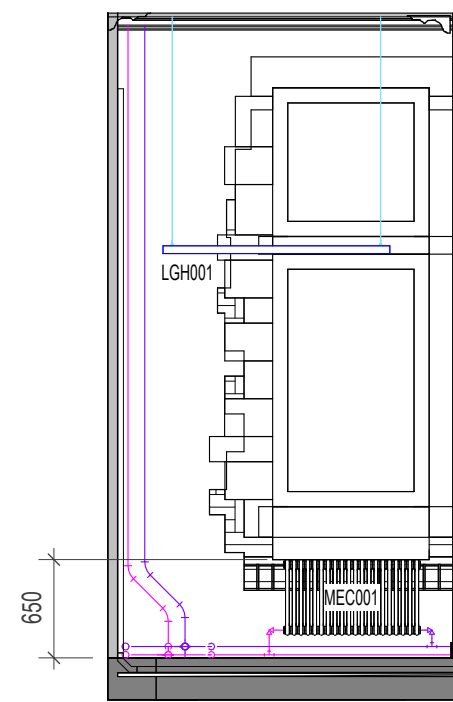

9 ELEVATION 8
1 : 50

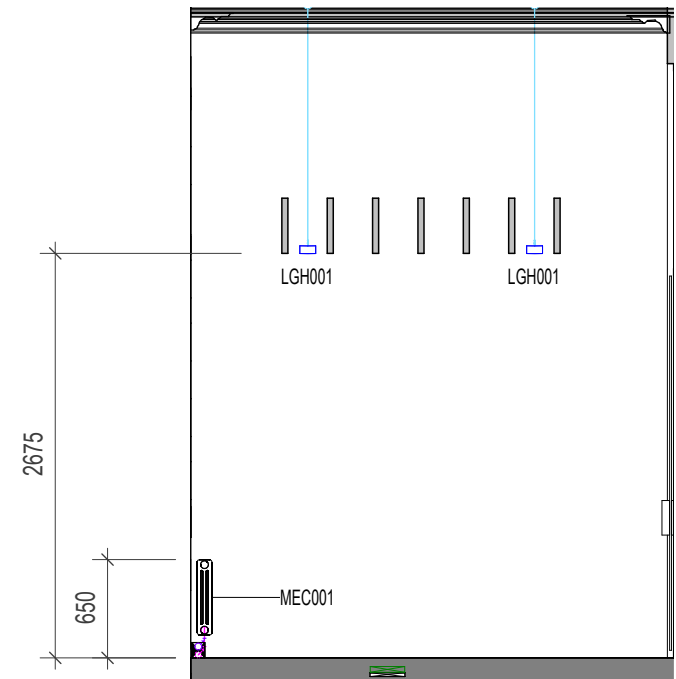

10 ELEVATION 9
1 : 50

P3	2024/12/13	C-sheets issued to MCC	AB	RM
P2	2024/07/26	C-sheets issued to MCC	AB	RM
P1	2024/07/12	Co-ordination with MEP	AB	RM
Rev	Date	Revision Notes	Drawn	Review

MANCHESTER
1824
The University of Manchester

ARCADIS

Project
Rutherford Building

Drawing Title
G.057 - Meeting Room

Job Number 141532	Date	Security Classification	Drawn By AJ
Scale@A1 1 : 50	Purpose LISTED BUILDING CONSENT	Reviewed By AB	Revision P3
Drawing Number 4903-RBUM-ARC-XX-ZZ-DR-A-4903			