

PROJECT DESCRIPTION:	
SYSTEM SIZE	68.16KW DC STC
MODULE TYPE	(142) JINKO SOLAR JKM480N-60HL4-V 480W

INDEX SHEET	
A.00	SITE PLAN
A.01	LAYOUT PLAN
S.00	FRAMING DETAILS
D.00-D.03	SPECIFICATION SHEETS



Alderley Park
Congleton Road
Nether Alderley
Macclesfield
SK10 4TG

PRO DATE	12/9/2024	
DESIGN BY	DR	
CHECKED BY	JD	
DATE	REV	DESCRIPTION
15/11/2024	1	Revised Panels from the Pitched Roof

PROJECT NAME

MANCHESTER CITY 4

SHEET NAME


SITE PLAN

SHEET SIZE

ANSI B
279 X 432

SHEET NUMBER

A.00

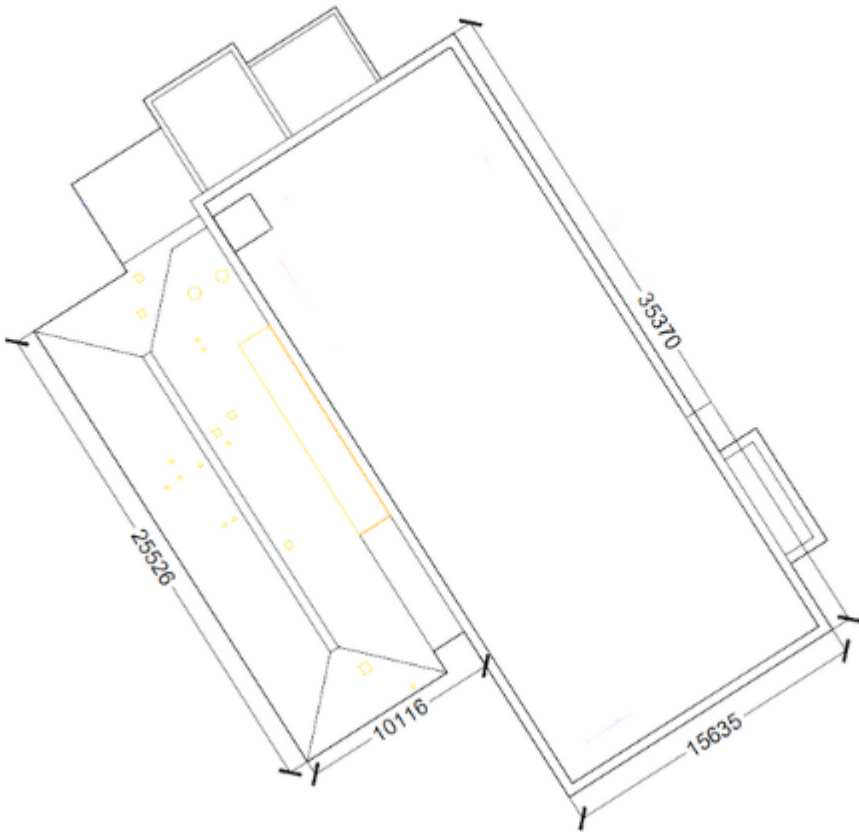



1 SITE PLAN
SCALE: 1:200