




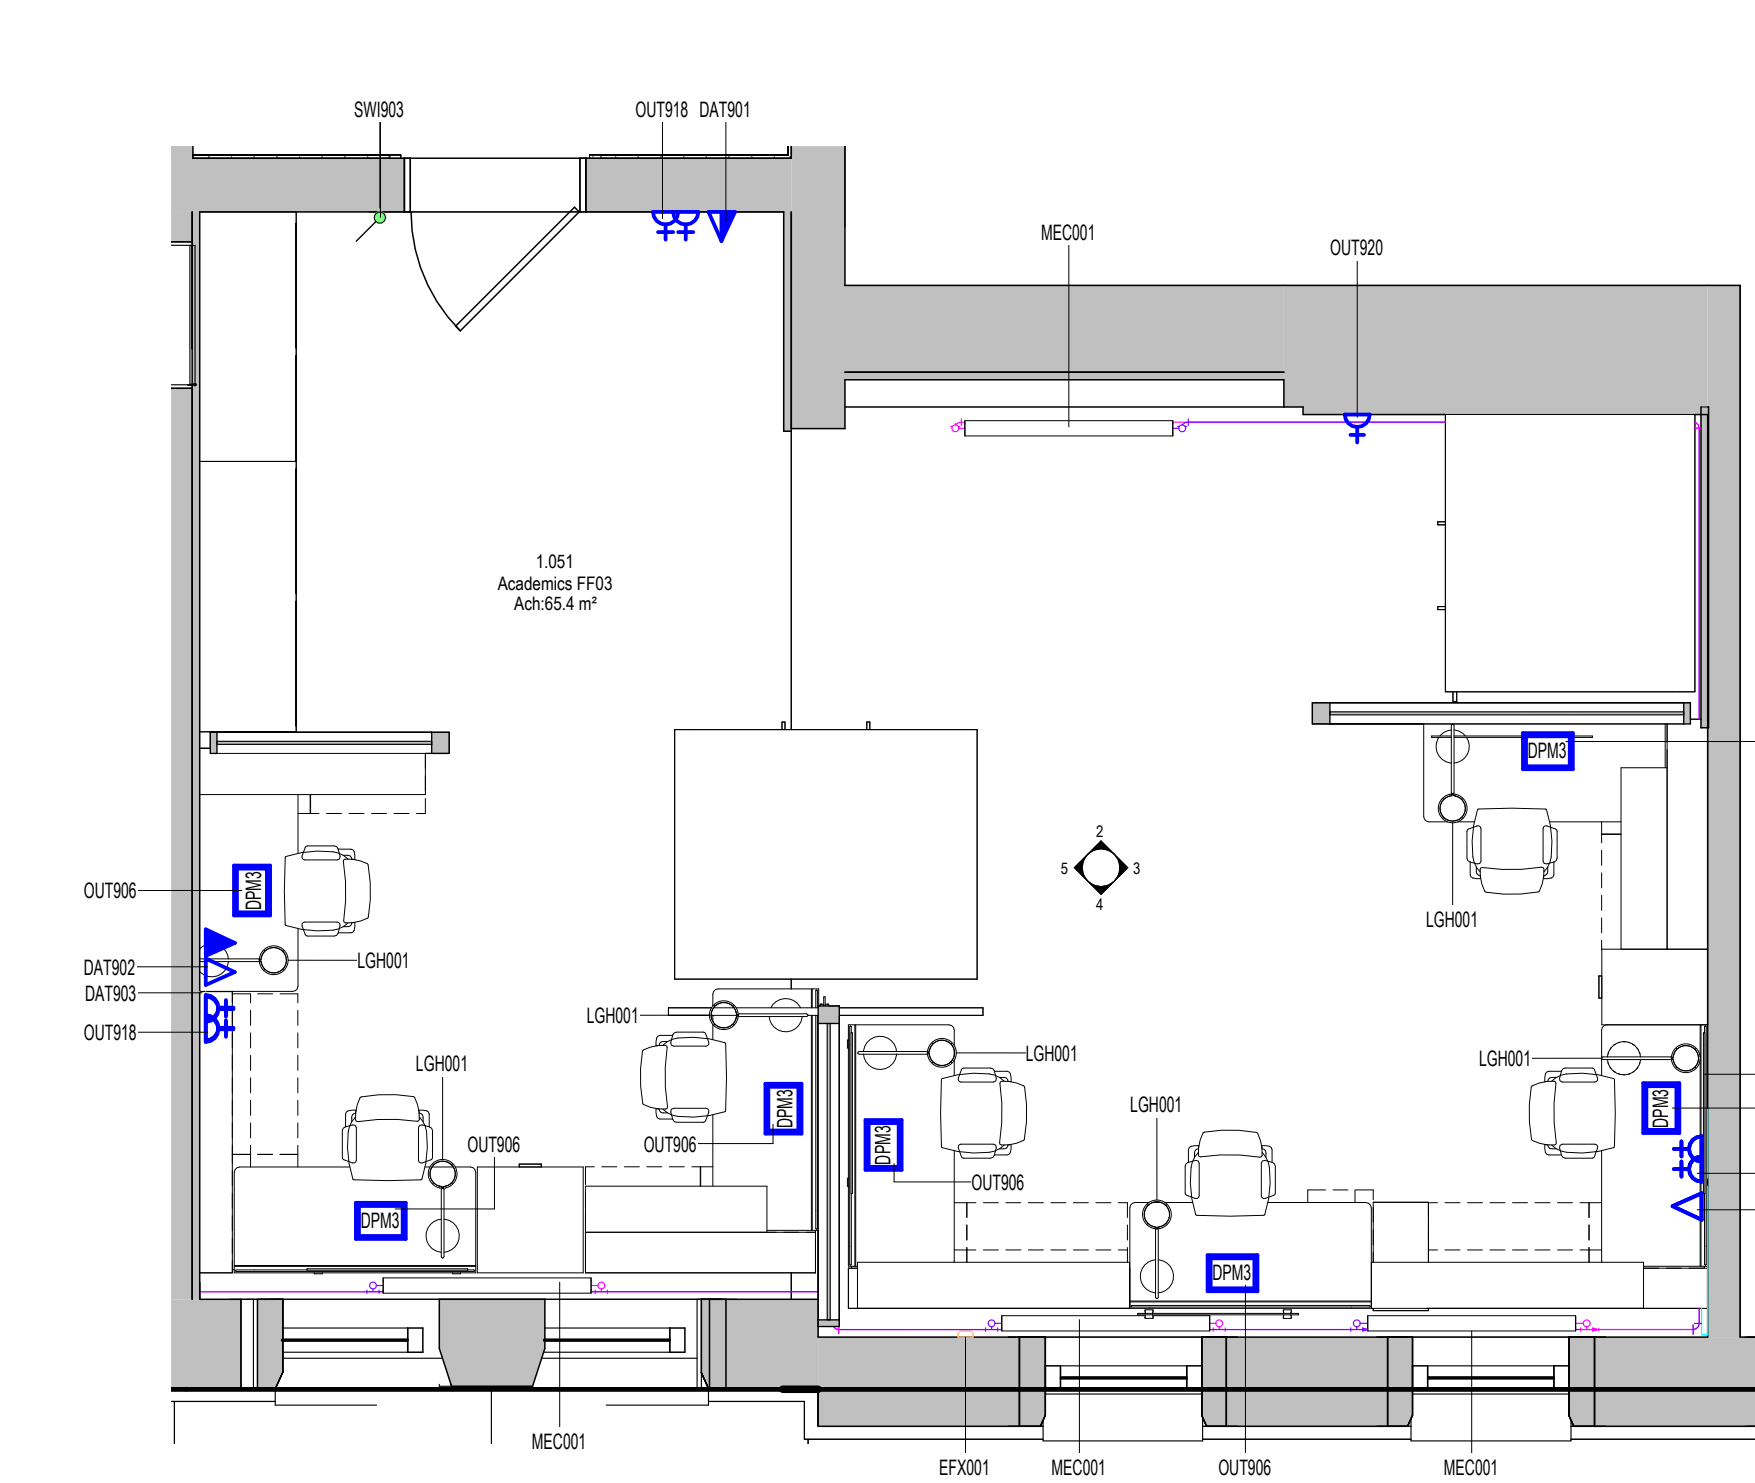


[1] 1.051 Academics FF01 Floor Plan
1 : 50

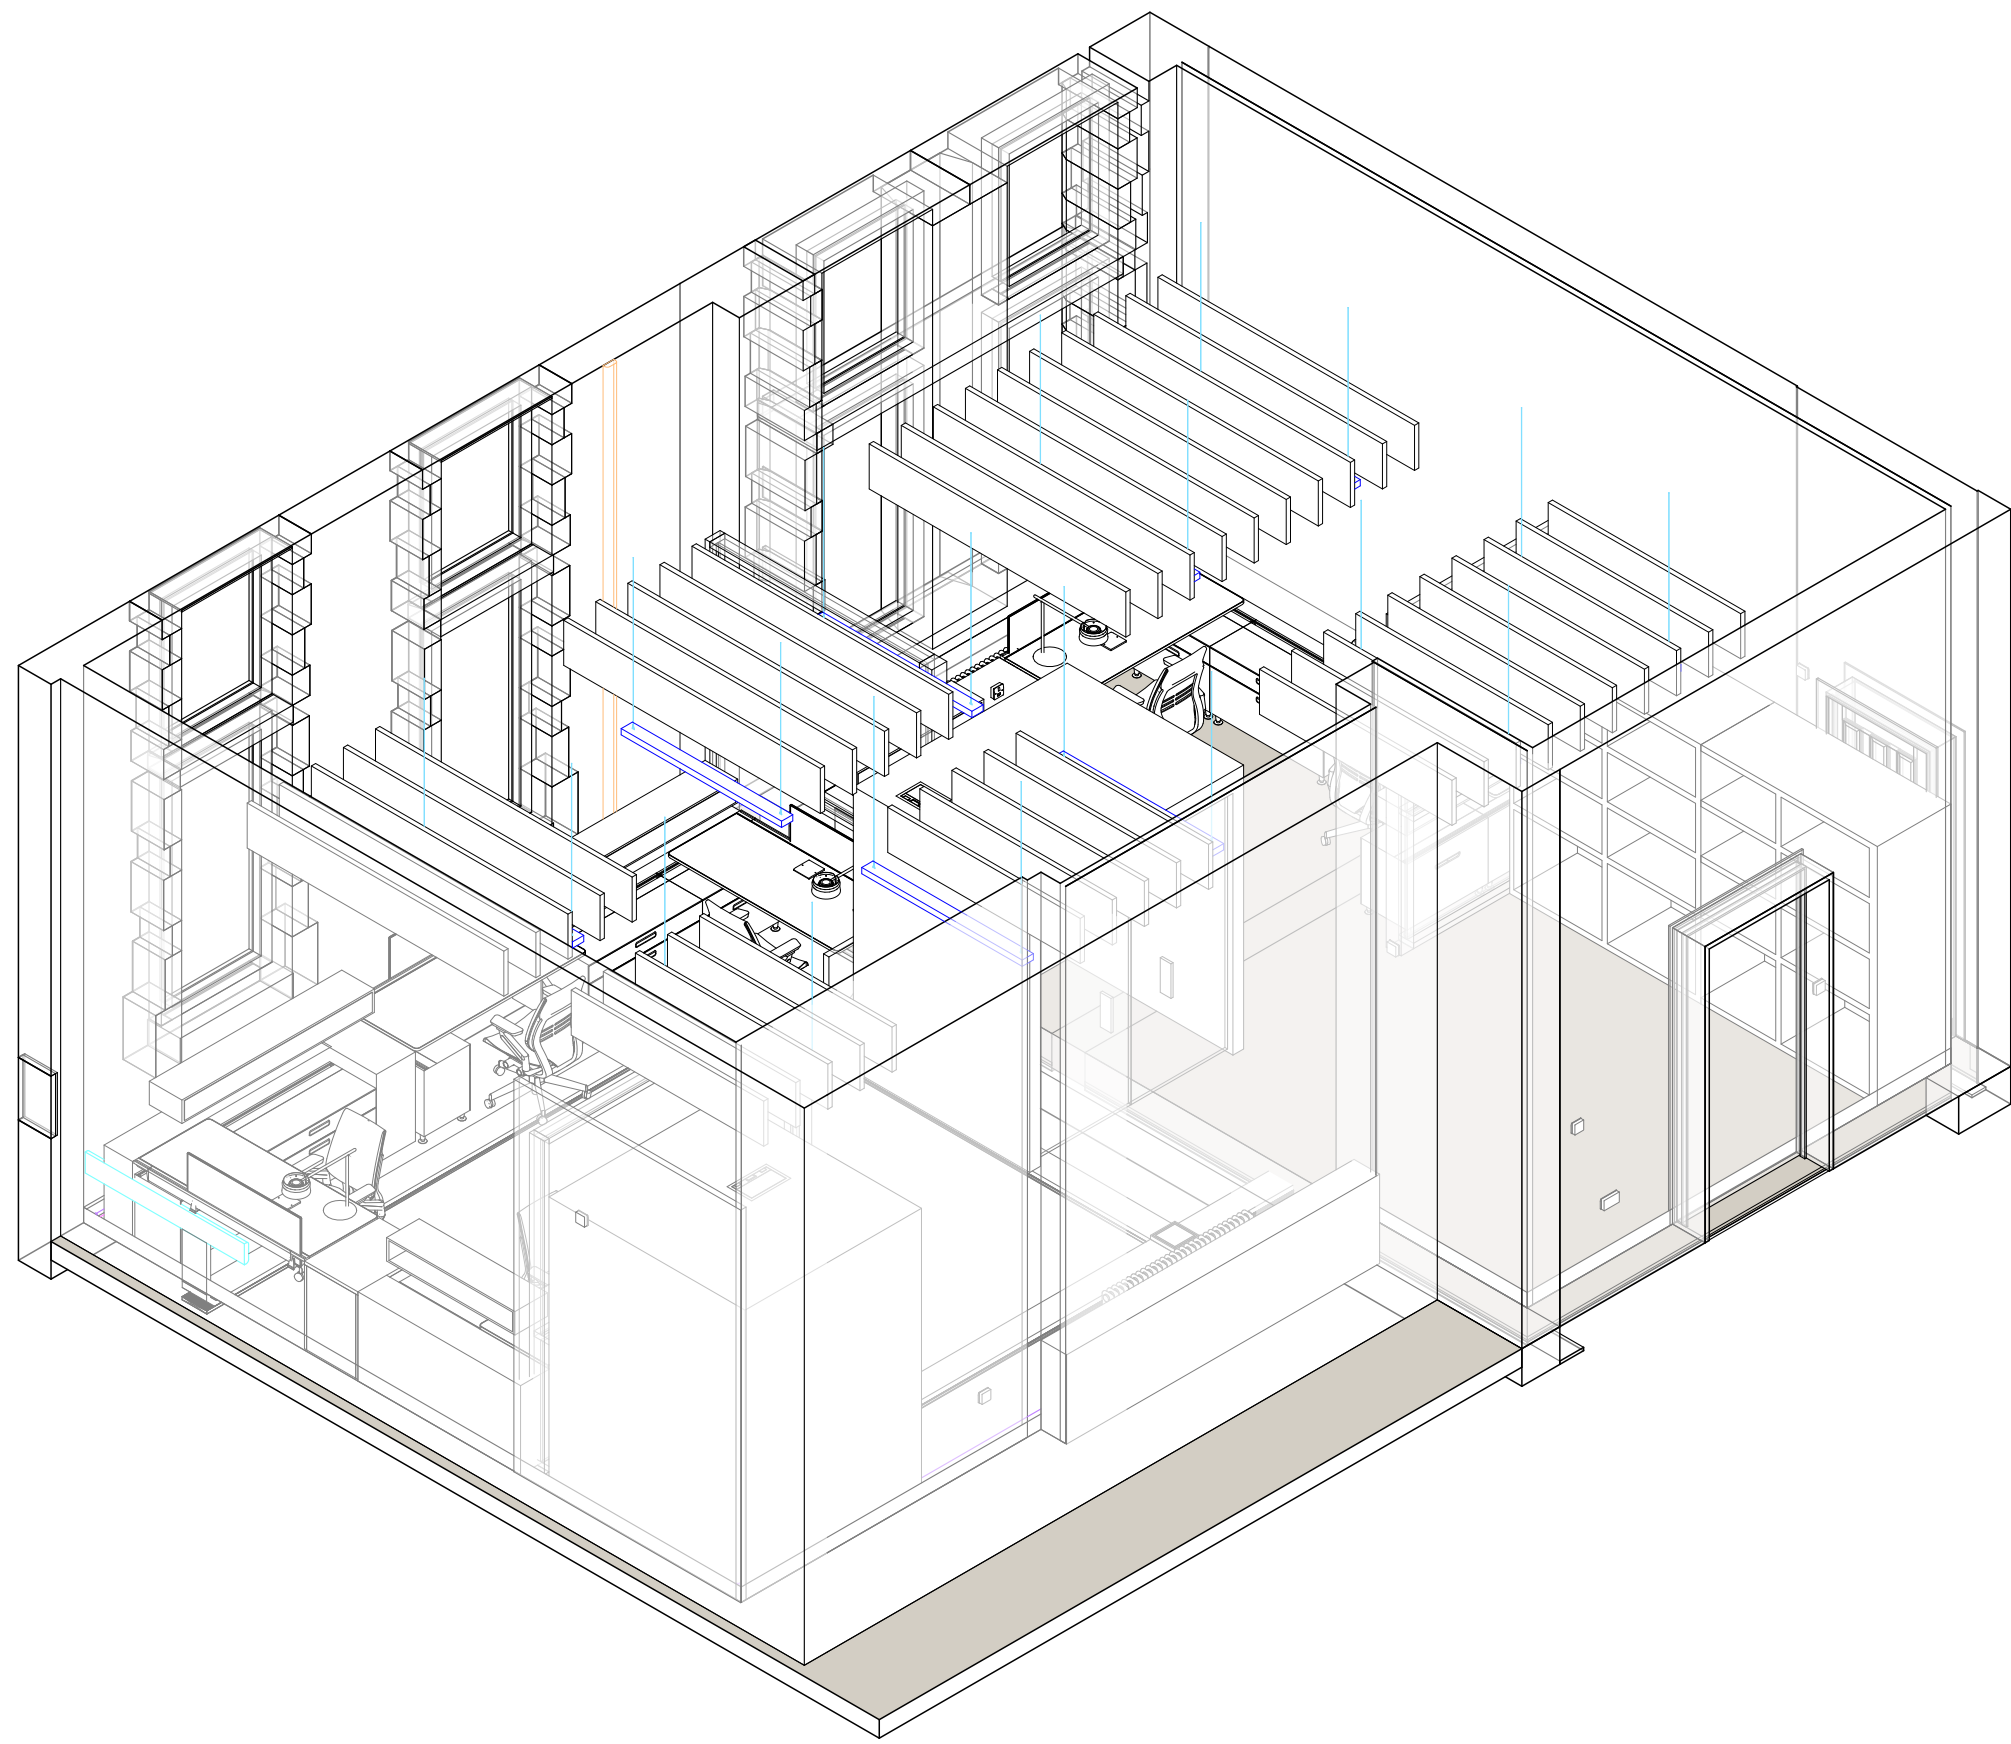


[6] 1.051 Academics FF01 Isometric View

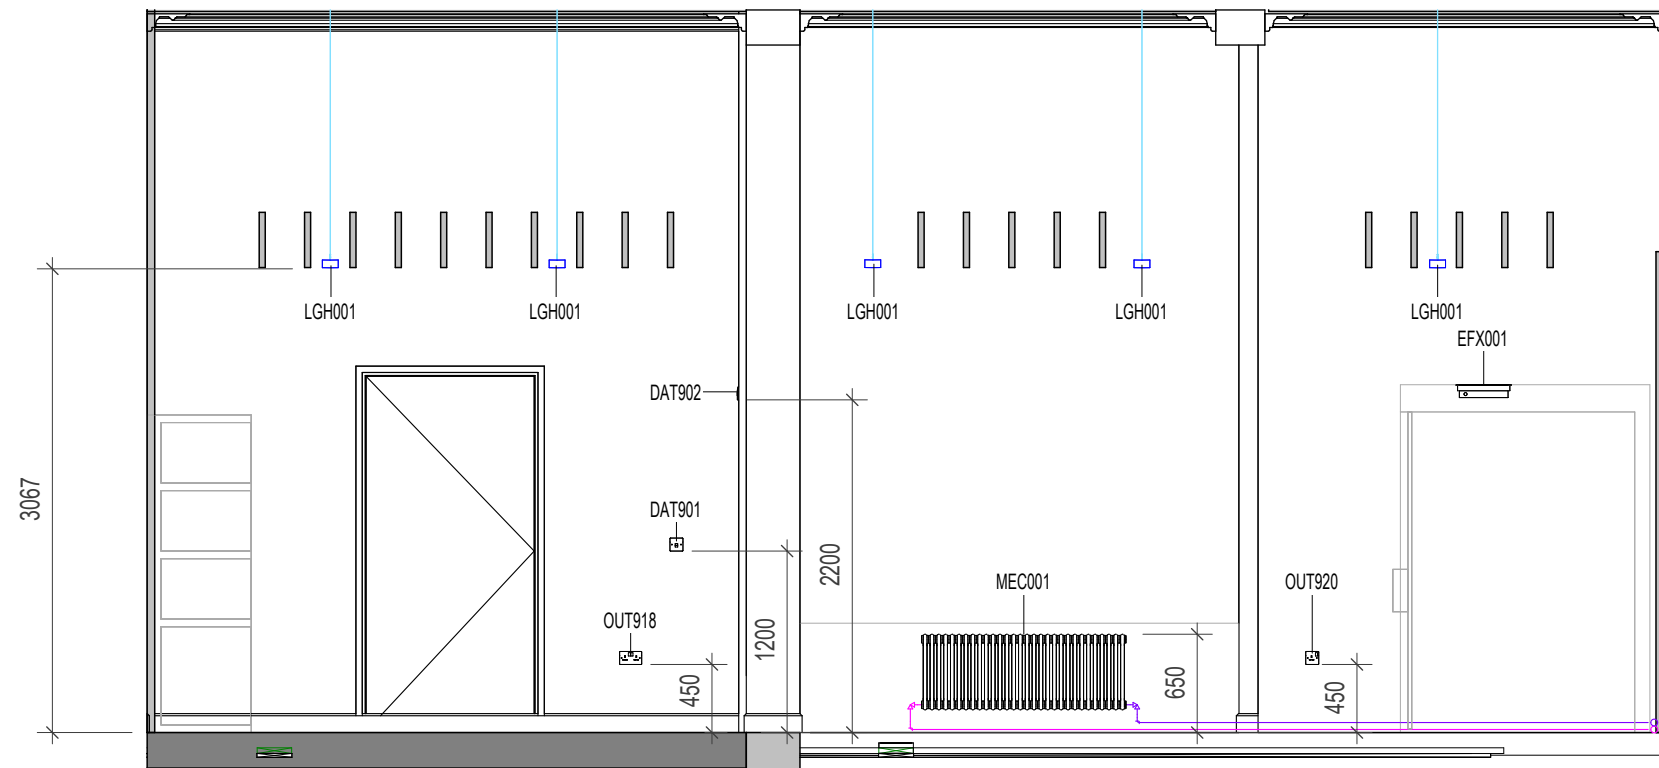


[2] ELEVATION 2
1 : 50

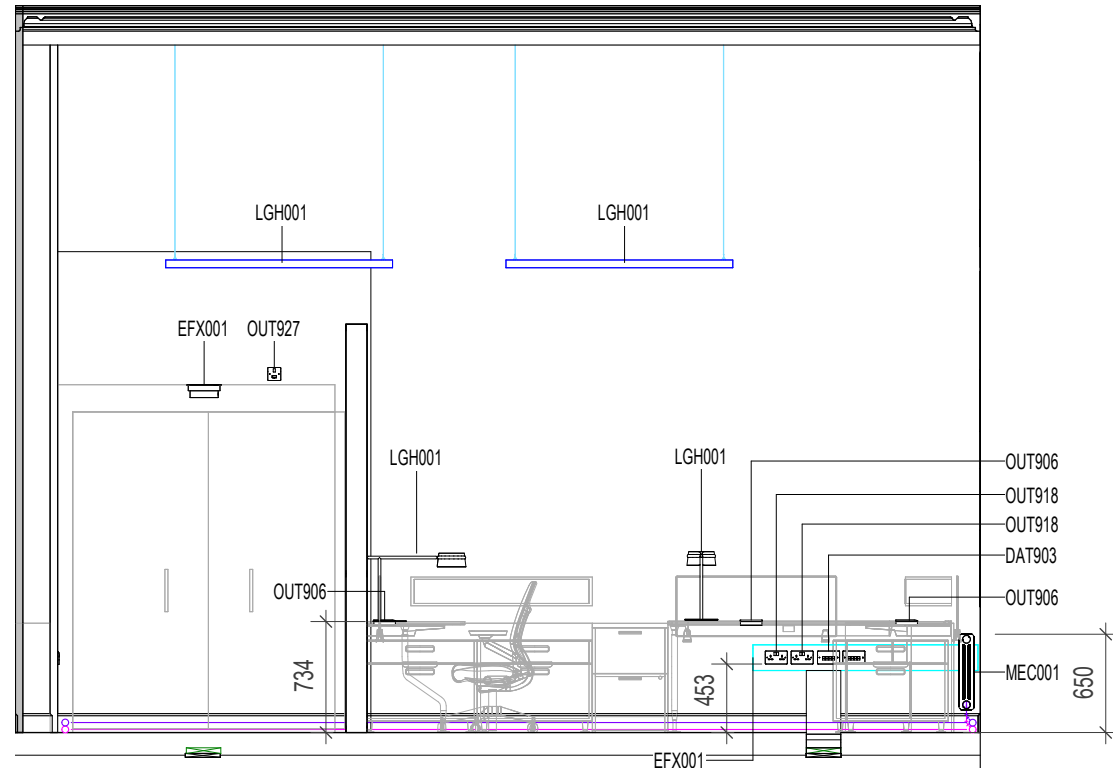

[3] ELEVATION 3
1 : 50

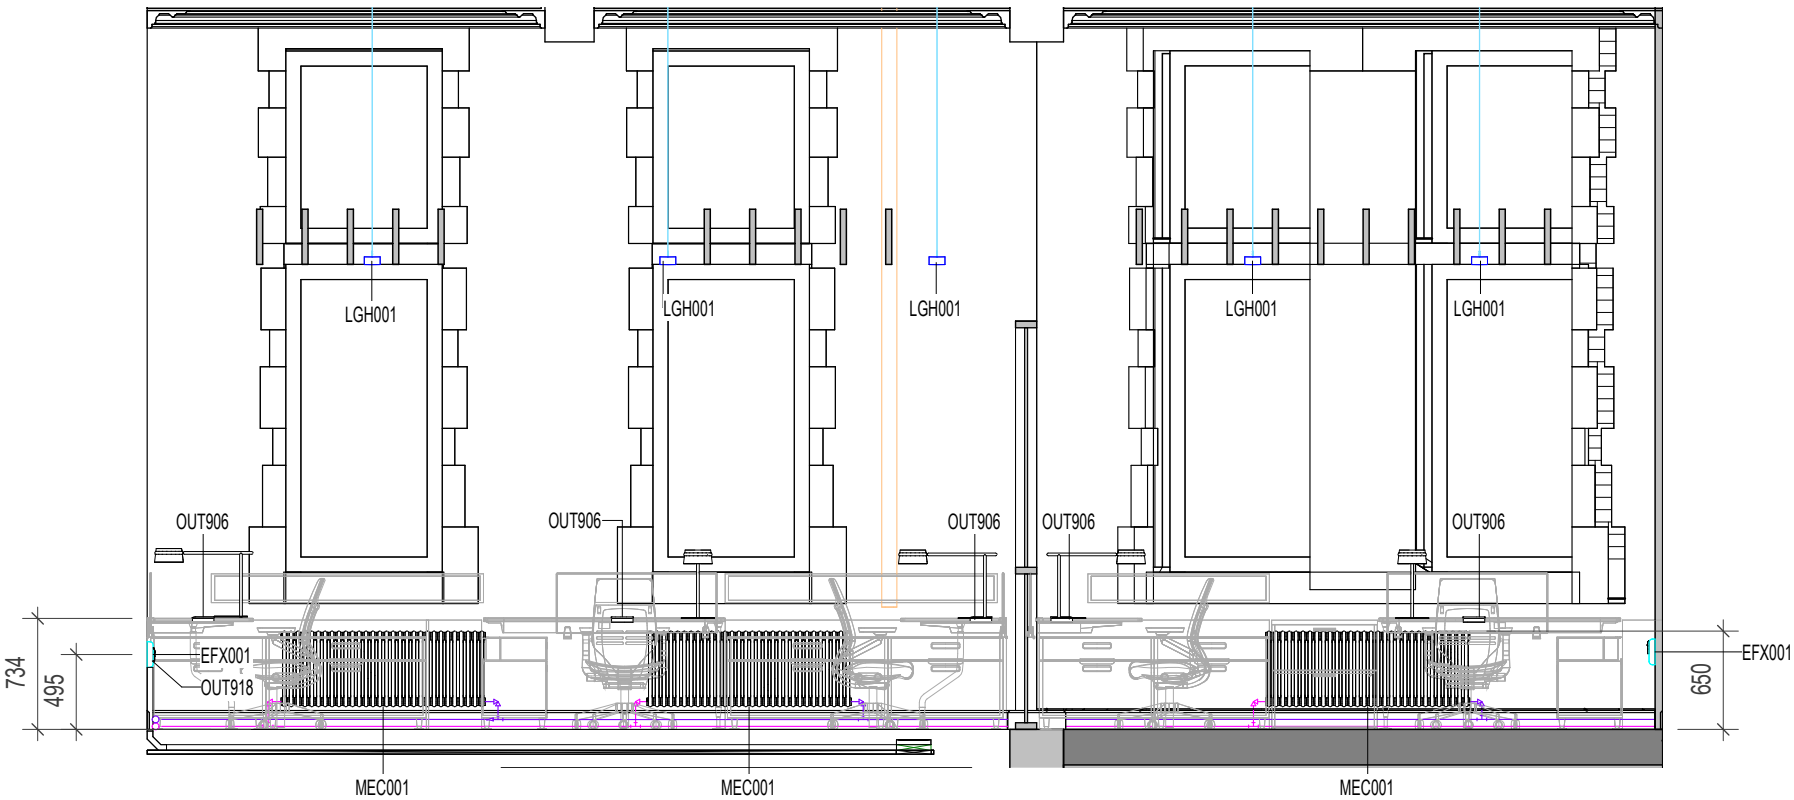

[4] ELEVATION 4
1 : 50

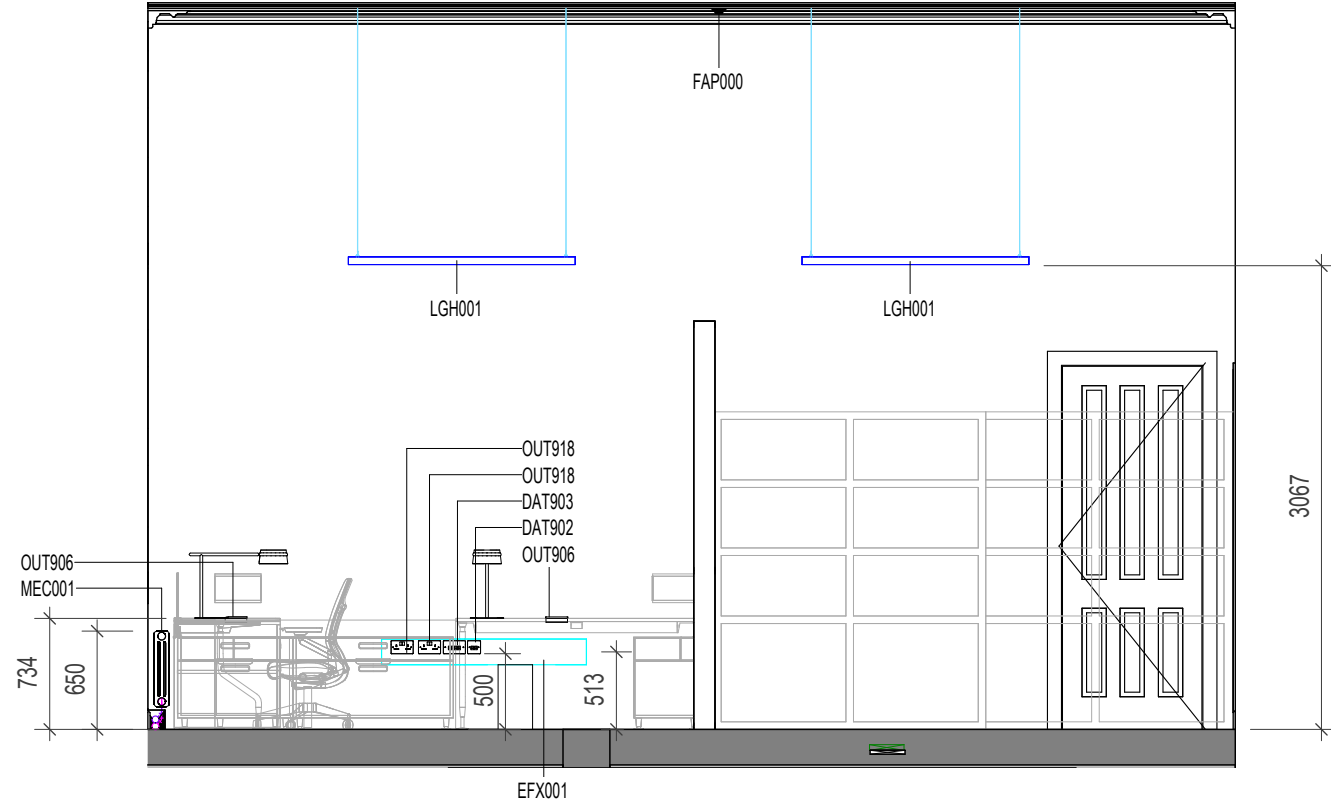

[5] ELEVATION 5
1 : 50

Space Number	Space Name	ADBCode	ADBDescription	ADBGroup
1.051	Academia FF03	DAT902	Double Gang RJ45 Outlet	1
1.051	Academia FF03	DAT903	Four Gang RJ45 Outlet	1
1.051	Academia FF03	EFX001	Electrical Fixture	1
1.051	Academia FF03	LGH001	Lighting Fixture	1
1.051	Academia FF03	MEC001	Mechanical Equipment	1
1.051	Academia FF03	OUT906	Automatic Changeover Switch	1
1.051	Academia FF03	OUT918	Double Switched Socket Outlet - Plastic	1
1.051	Academia FF03	OUT920	Single Switched Socket Outlet - Plastic	1
1.051	Academia FF03	OUT927	Switched Fused Connection Unit - Plastic	1
1.051	Academia FF03	SW903	Plastic Retractive Light Switch	1

Notes:

- This drawing is copyright.
- Do not scale dimensions from this drawing.
- This drawing is to be read in conjunction with all other relevant drawings.
- All discrepancies on this drawing are to be reported to the architect.
- Do not modify any element of this drawing.
- Use drawing only for purpose(s) issued.
- This drawing may contain colour.

Scale Bar

North Point

Key Plan

The following external model files are included within this drawing:

P3	2024/12/13	C-sheets issued to MCC	AB	RM
P2	2024/07/26	C-sheets issued to MCC	AB	RM
P1	2024/07/12	Screen on ground floor should be Fire Rated	AB	RM
Rev	Date	Revision Notes	Drawn	Review

MANCHESTER
1824
The University of Manchester

Project
Rutherford Building

Drawing Title
1.051 - Academics FF01

Job Number 141532	Date	Security Classification	Drawn By AJ
Scale@A1 1 : 50	Purpose LISTED BUILDING CONSENT	Reviewed By AB	Revision
Drawing Number 4909-RBUM-ARC-XX-ZZ-DR-A-4909			P3