




1. DO NOT SCALE FROM THIS DRAWING - USE FIGURED DIMENSIONS ONLY.
2. READ IN CONJUNCTION WITH ALL OTHER CONSULTANTS / SPECIALISTS DRAWINGS, REPORT ANY DISCREPANCIES BEFORE AFFECTED WORK COMMENCES.
3. ALL SETTING OUT DIMENSIONS TO BE CHECKED ON SITE BY CONTRACTOR BEFORE WORK COMMENCES.
4. THIS DRAWING REMAINS COPYRIGHT OF KEPczyk PEARCE SANDERSON LTD. COPY / DISTRIBUTE ONLY WITH CONSENT OF THE AUTHOR.

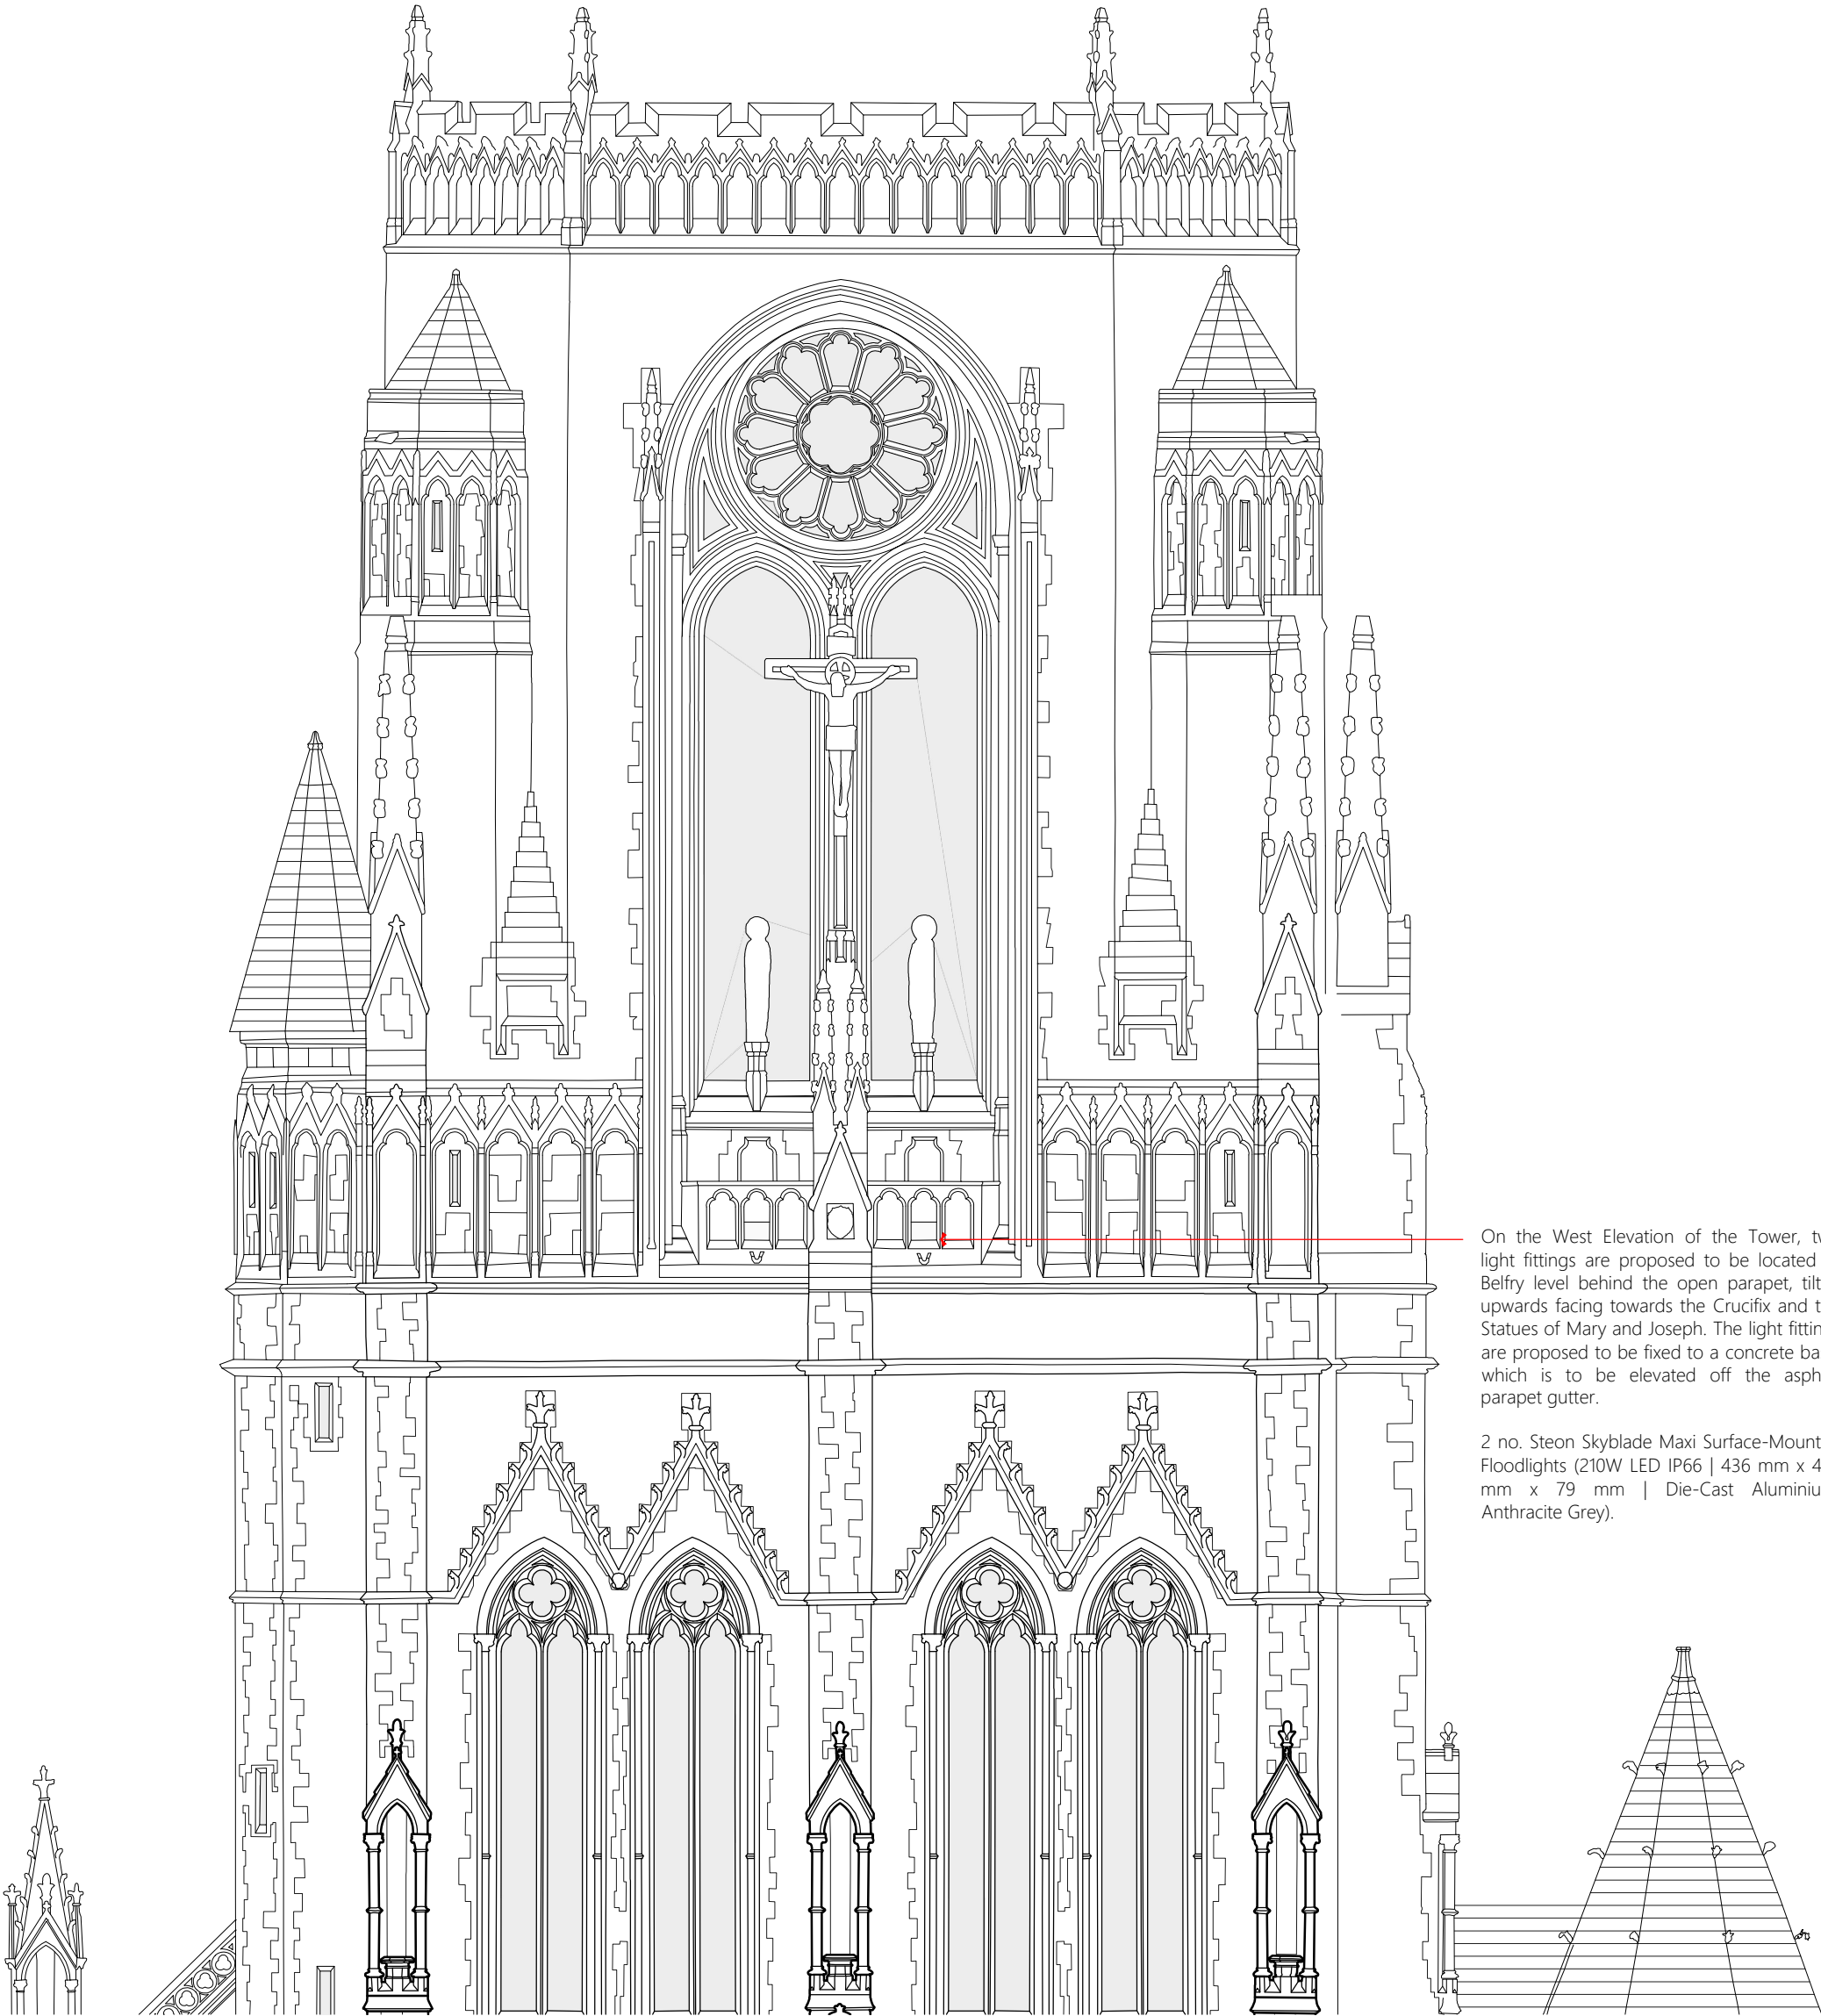

On the West Elevation of the Tower, two light fittings are proposed to be located at Belfry level behind the open parapet, tilted upwards facing towards the Crucifix and the Statues of Mary and Joseph. The light fittings are proposed to be fixed to a concrete base, which is to be elevated off the asphalt parapet gutter.

2 no. Steon Skyblade Maxi Surface-Mounted Floodlights (210W LED IP66 | 436 mm x 472 mm x 79 mm | Die-Cast Aluminium, Anthracite Grey).

 Scale bar (1:100)

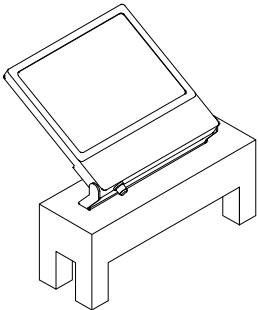

New concrete base to be positioned behind open parapet at Belfry level for light fitting to be fixed to. Base to be elevated off the asphalt parapet gutter.

New Concrete Base for Light Fitting
Scale 1:20

Contract Lighting Renewal Works		Proposed Location of External Light Fittings					
Client Society of Jesus (Jesuits)							
Building / Structure	The Church of the Holy Name of Jesus, Oxford Road, Manchester M13 9PG	Contract No.	2013	Drawn	MS	Drawing No.	P 02
		Date	Jan 2025	Revision	-	Scale	1:100 @ A3
KEPCZYK PEARCE SANDERSON ARCHITECTS, SURVEYORS & HISTORIC BUILDING CONSULTANTS		Address: 75 Wilmslow Road, Handforth, Wilmslow, Cheshire SK9 3EN Tel: 01625 400103					