


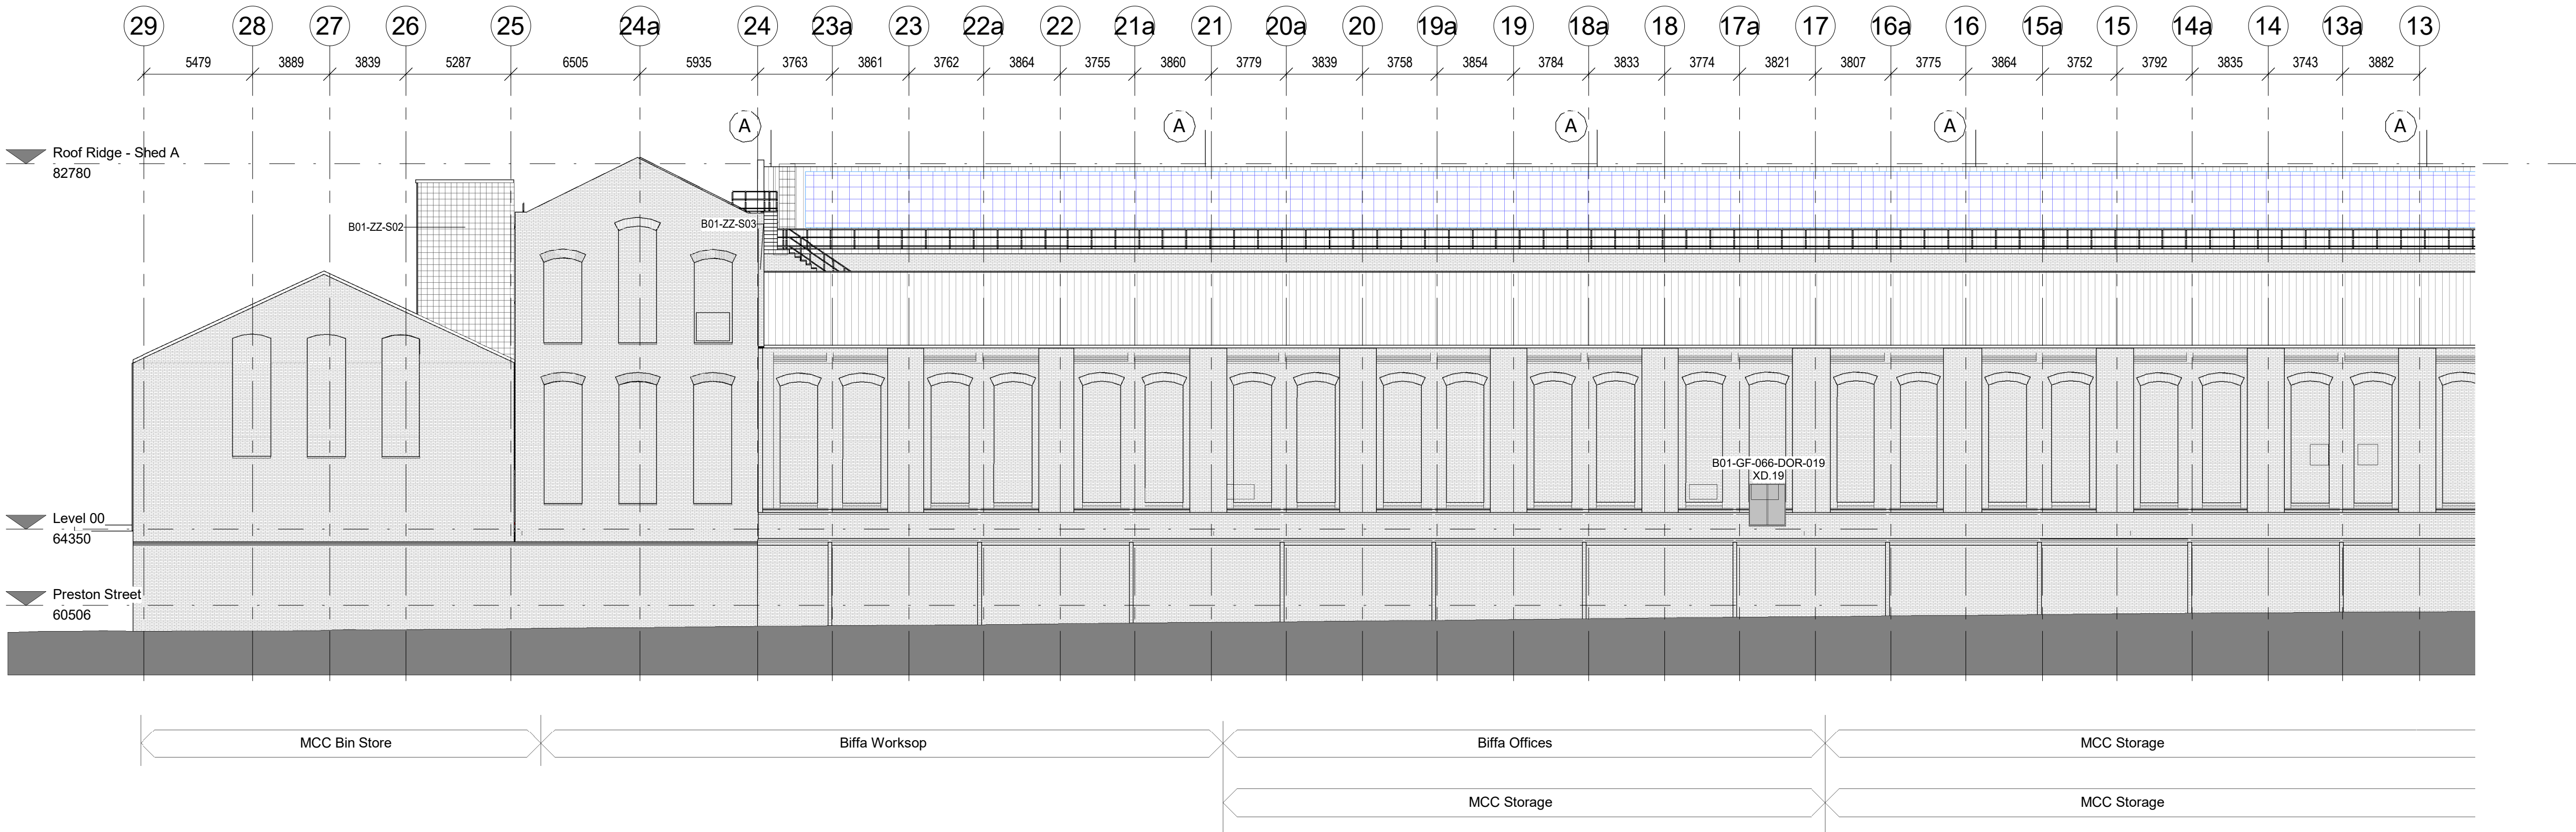


Lightning Protection West Elevation 1

Scale: 1 : 200



Lightning Protection West Elevation 2

 Scale: 1 : 200




General Notes

Do not scale from this drawing. Only work to written dimensions.

All site dimensions shall be verified by the Contractor on site prior to commencing any works.

This drawing is the property of Fletcher-Rae (UK) Limited (t/a Fletcher-Rae) and copyright is reserved by them. The drawing is not to be copied or disclosed by or to any unauthorised persons without the prior written consent of Fletcher-Rae (UK) Limited.

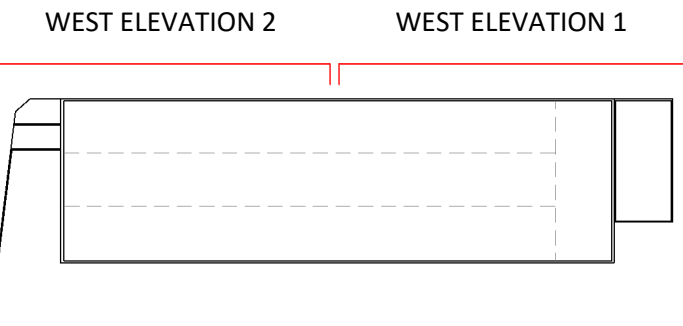

KEY PLAN

- Legend:
- (A) 2m High Stainless Steel Air Termination Rod

C01	First Issue	2024.12.10	AT	AT
Rev.	Description	Date	ISS	APP
Scale	As indicated @ A1			
Status	PD - Published Document (Construction)			
Drawn By	AT			
Checked By	TA			
Date	10.12.2024			
Client:				

Morgan Sindall

Project:
**18021 Hammerstone Road
Manchester**

Sheet Name:
**West Elevation - Lightning
Protection**

Project No.	Orig.	Zone	Level	Type	Role	Cls	Dwg No.	Rev
HRD-FRA-01-EL-DR-A-20-1218								C01
fletcher rae								
Architects Master Planners Designers								
Level 12, Tower 12, 18-22 Bridge Street, Manchester, M3 3BZ								

t +44 (0) 161 242 1140
f +44 (0) 161 242 1141
w www.fletcher-rae.com
e info@fletcher-rae.com