


LIGHTING LEGEND		
REF	SYMBOL	DESCRIPTION
DL1		Adjustable LED Downlight (High Output)
DL2		Adjustable LED Downlight (Low Output)
DL3		Miniature LED Downlight
DL4		Adjustable LED Downlight (Artwork)
L1		LED Light Strip (within a profile)
L2		Flexible LED Strip
L3		High Output LED Strip (Window Ledges)
L4		LED tape
L5		Flexible LED grazer
L6		High Output LED Strip (Ceiling Coffin)
LS1		LED Light Sheet
SP1		Recessed Mounted Spotlight
SP2		Miniature Recessed Mounted Spotlight
SP3		Spike Light (Planters)
SP3A		Surface Spotlight (Trees)
SP4		Surface Spotlight within Mesh
U1		Recessed Inground Uplight (RGBW)
U2		Recessed Inground Uplight
PL1		Bespoke Decorative Pendant
FL1		Decorative Floor Lamp
TL1		Decorative Table Lamp
WL1		Decorative Wall Light
WL2		Picture Light
WL3		Bespoke Wall Light

High Level Lighting
Low Level Lighting

LED STRIP - MAX RUN IS 10M, WE WILL NEED A POWER SUPPLY AFTER EVERY 10M.

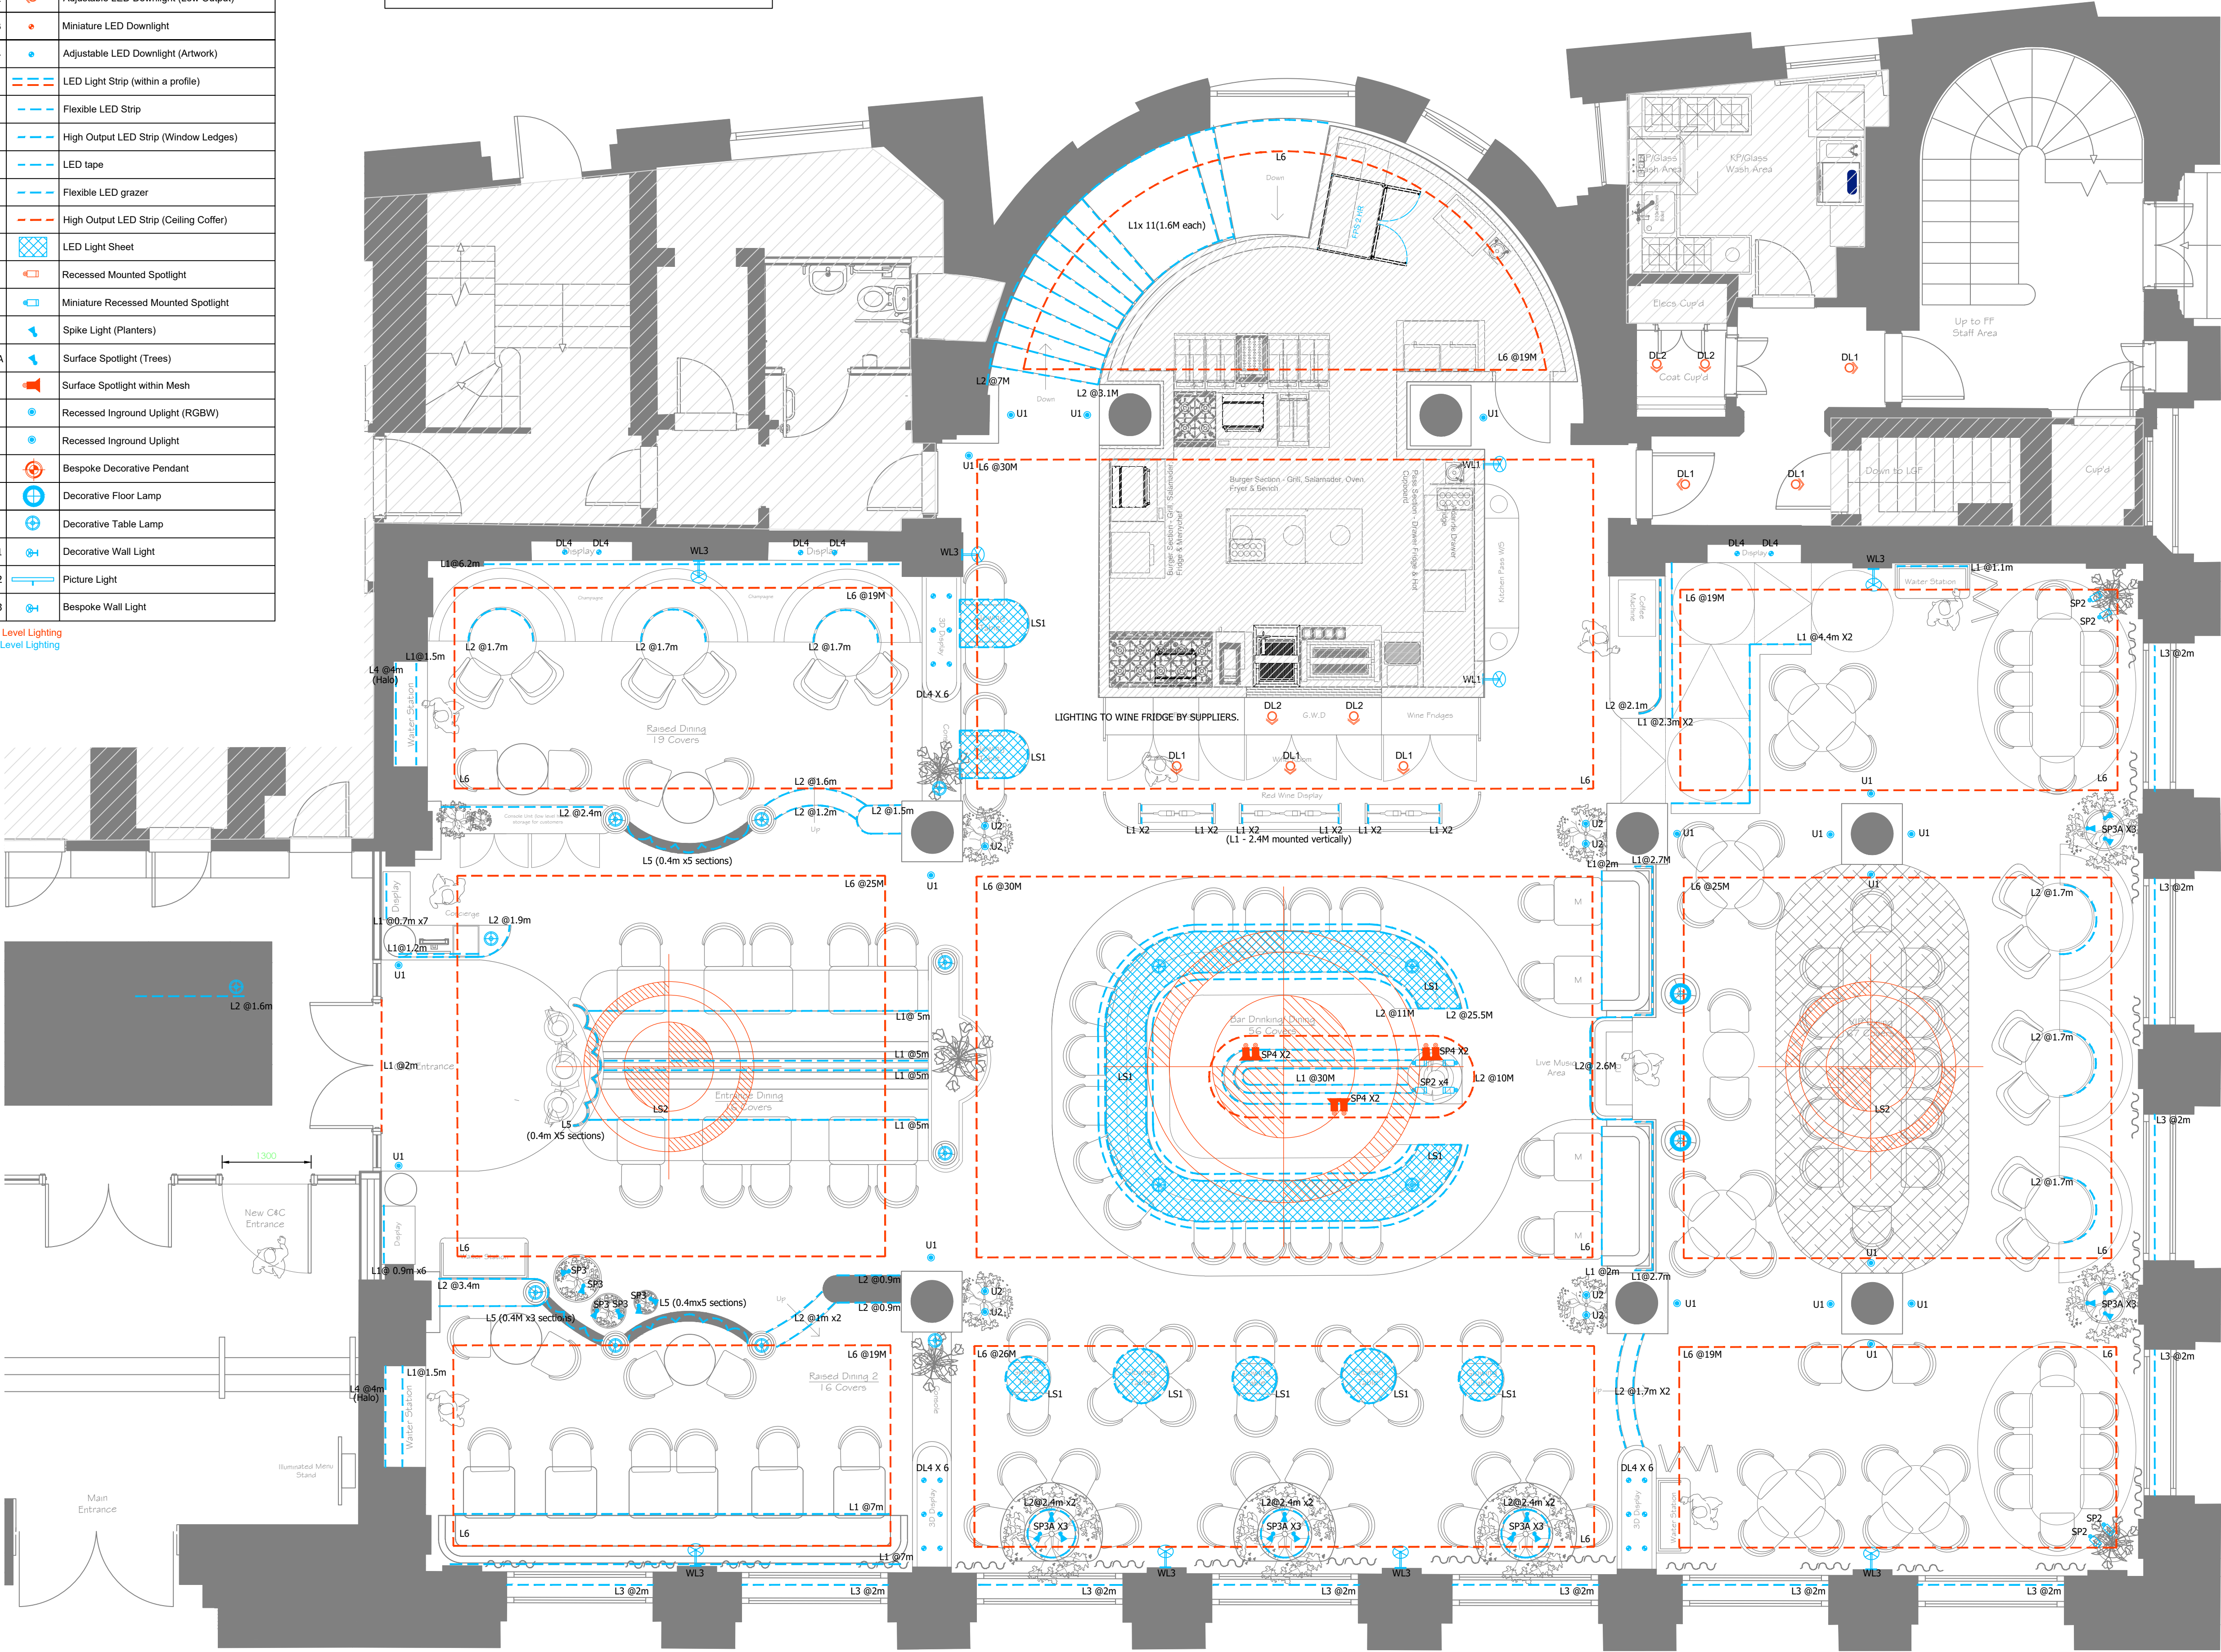

© Mistry Lighting LTD
All Rights Reserved. Mistry Lighting (unless otherwise agreed in writing) their rights under s.77 to 89 of the Copyright, Designs and Patents Act 1988.

DO NOT SCALE THIS DRAWING.

- Notes
- DRAWING TO BE PRINTED IN COLOUR**
- THIS DRAWING MUST BE READ IN CONJUNCTION WITH ALL OTHER RELEVANT PROJECT DRAWINGS AND SPECIFICATIONS
 - DO NOT SCALE FROM THIS DRAWING. IF IN DOUBT PLEASE REQUEST FURTHER INFORMATION.
 - ALL DIMENSIONS ARE SHOWN IN MILLIMETERS UNLESS NOTES STATE OTHERWISE.
 - SYMBOLS INDICATE PROPOSED LOCATIONS OF LIGHTING EQUIPMENT. FOR FURTHER INFORMATION PLEASE REFER TO THE LUMINAIRE SCHEDULES AND DETAILS SHOWN.
 - THE LIGHTING INSTALLATION REQUIRES A VARIETY OF LUMINAIRE TYPES TO ACHIEVE THE DESIRED AFFECTS. INFORMATION HAS BEEN PROVIDED ON THIS DRAWING AS GENERAL GUIDANCE AND OUTLINE OF GOOD PRACTICE. FOR MORE SPECIFIC RECOMMENDATIONS PLEASE REFER TO MANUFACTURERS DETAILS FOR APPLICATION, OPERATION, HANDLING, CLEANING AND DISPOSAL INSTRUCTIONS.
 - INSTALLATION AND MAINTENANCE OF LIGHTING EQUIPMENT INSTALLED AT ANY HEIGHT ABOVE GROUND REQUIRES PRECAUTIONS TO BE TAKEN. ACCESS ARRANGEMENT SHOULD BE IN STRICT ACCORDANCE WITH THE PROJECTS ACCESS REPORT, METHOD STATEMENT AND HEALTH AND SAFETY GUIDELINES.

04	UPDATED LAYOUT	07/01/25	KM
03	UPDATED LAYOUT	11/12/24	NLM
02	CIRCUITING ADDED	28/06/24	NLM
01	DRAFT LAYOUT - FOR COMMENT	17/06/24	NLM
00	DRAFT LAYOUT - FOR COMMENT	10/04/24	NLM
Rev	Description	Date	Dm

SCHEME DESIGN

Status of drawing

MISTRY LIGHTING

0774715 3333
WWW.MISTRYLIGHTING.COM
KRISHNA@MISTRYLIGHTING.COM

Project

CUT & CRAFT, MANCHESTER

Drawing Title

LIGHTING LAYOUT - GF

Drawn By

Date

Scale

Drawing No.

KM

07/01/2025

1:50 @A1

ML_CCM_S_01

Drawing Order:

Revision

Client

Stage

01 of 02

REV 04

CUT&CRAFT

SCHEME DESIGN