

DO NOT SCALE FROM THIS DRAWING.
ALL DIMENSIONS TO BE CHECKED ON SITE.
(DRAWINGS MAYBE SCALED FOR LOCAL AUTHORITY & PLANNING PURPOSE ONLY)
COPYRIGHT PROTECTED.



FOR PLANNING
DO NOT USE FOR CONSTRUCTION

CONSULTANT REFERENCES IN DRAWING:

STRUCTURAL - REF/REVISION

KEY

NEW CONDENSERS

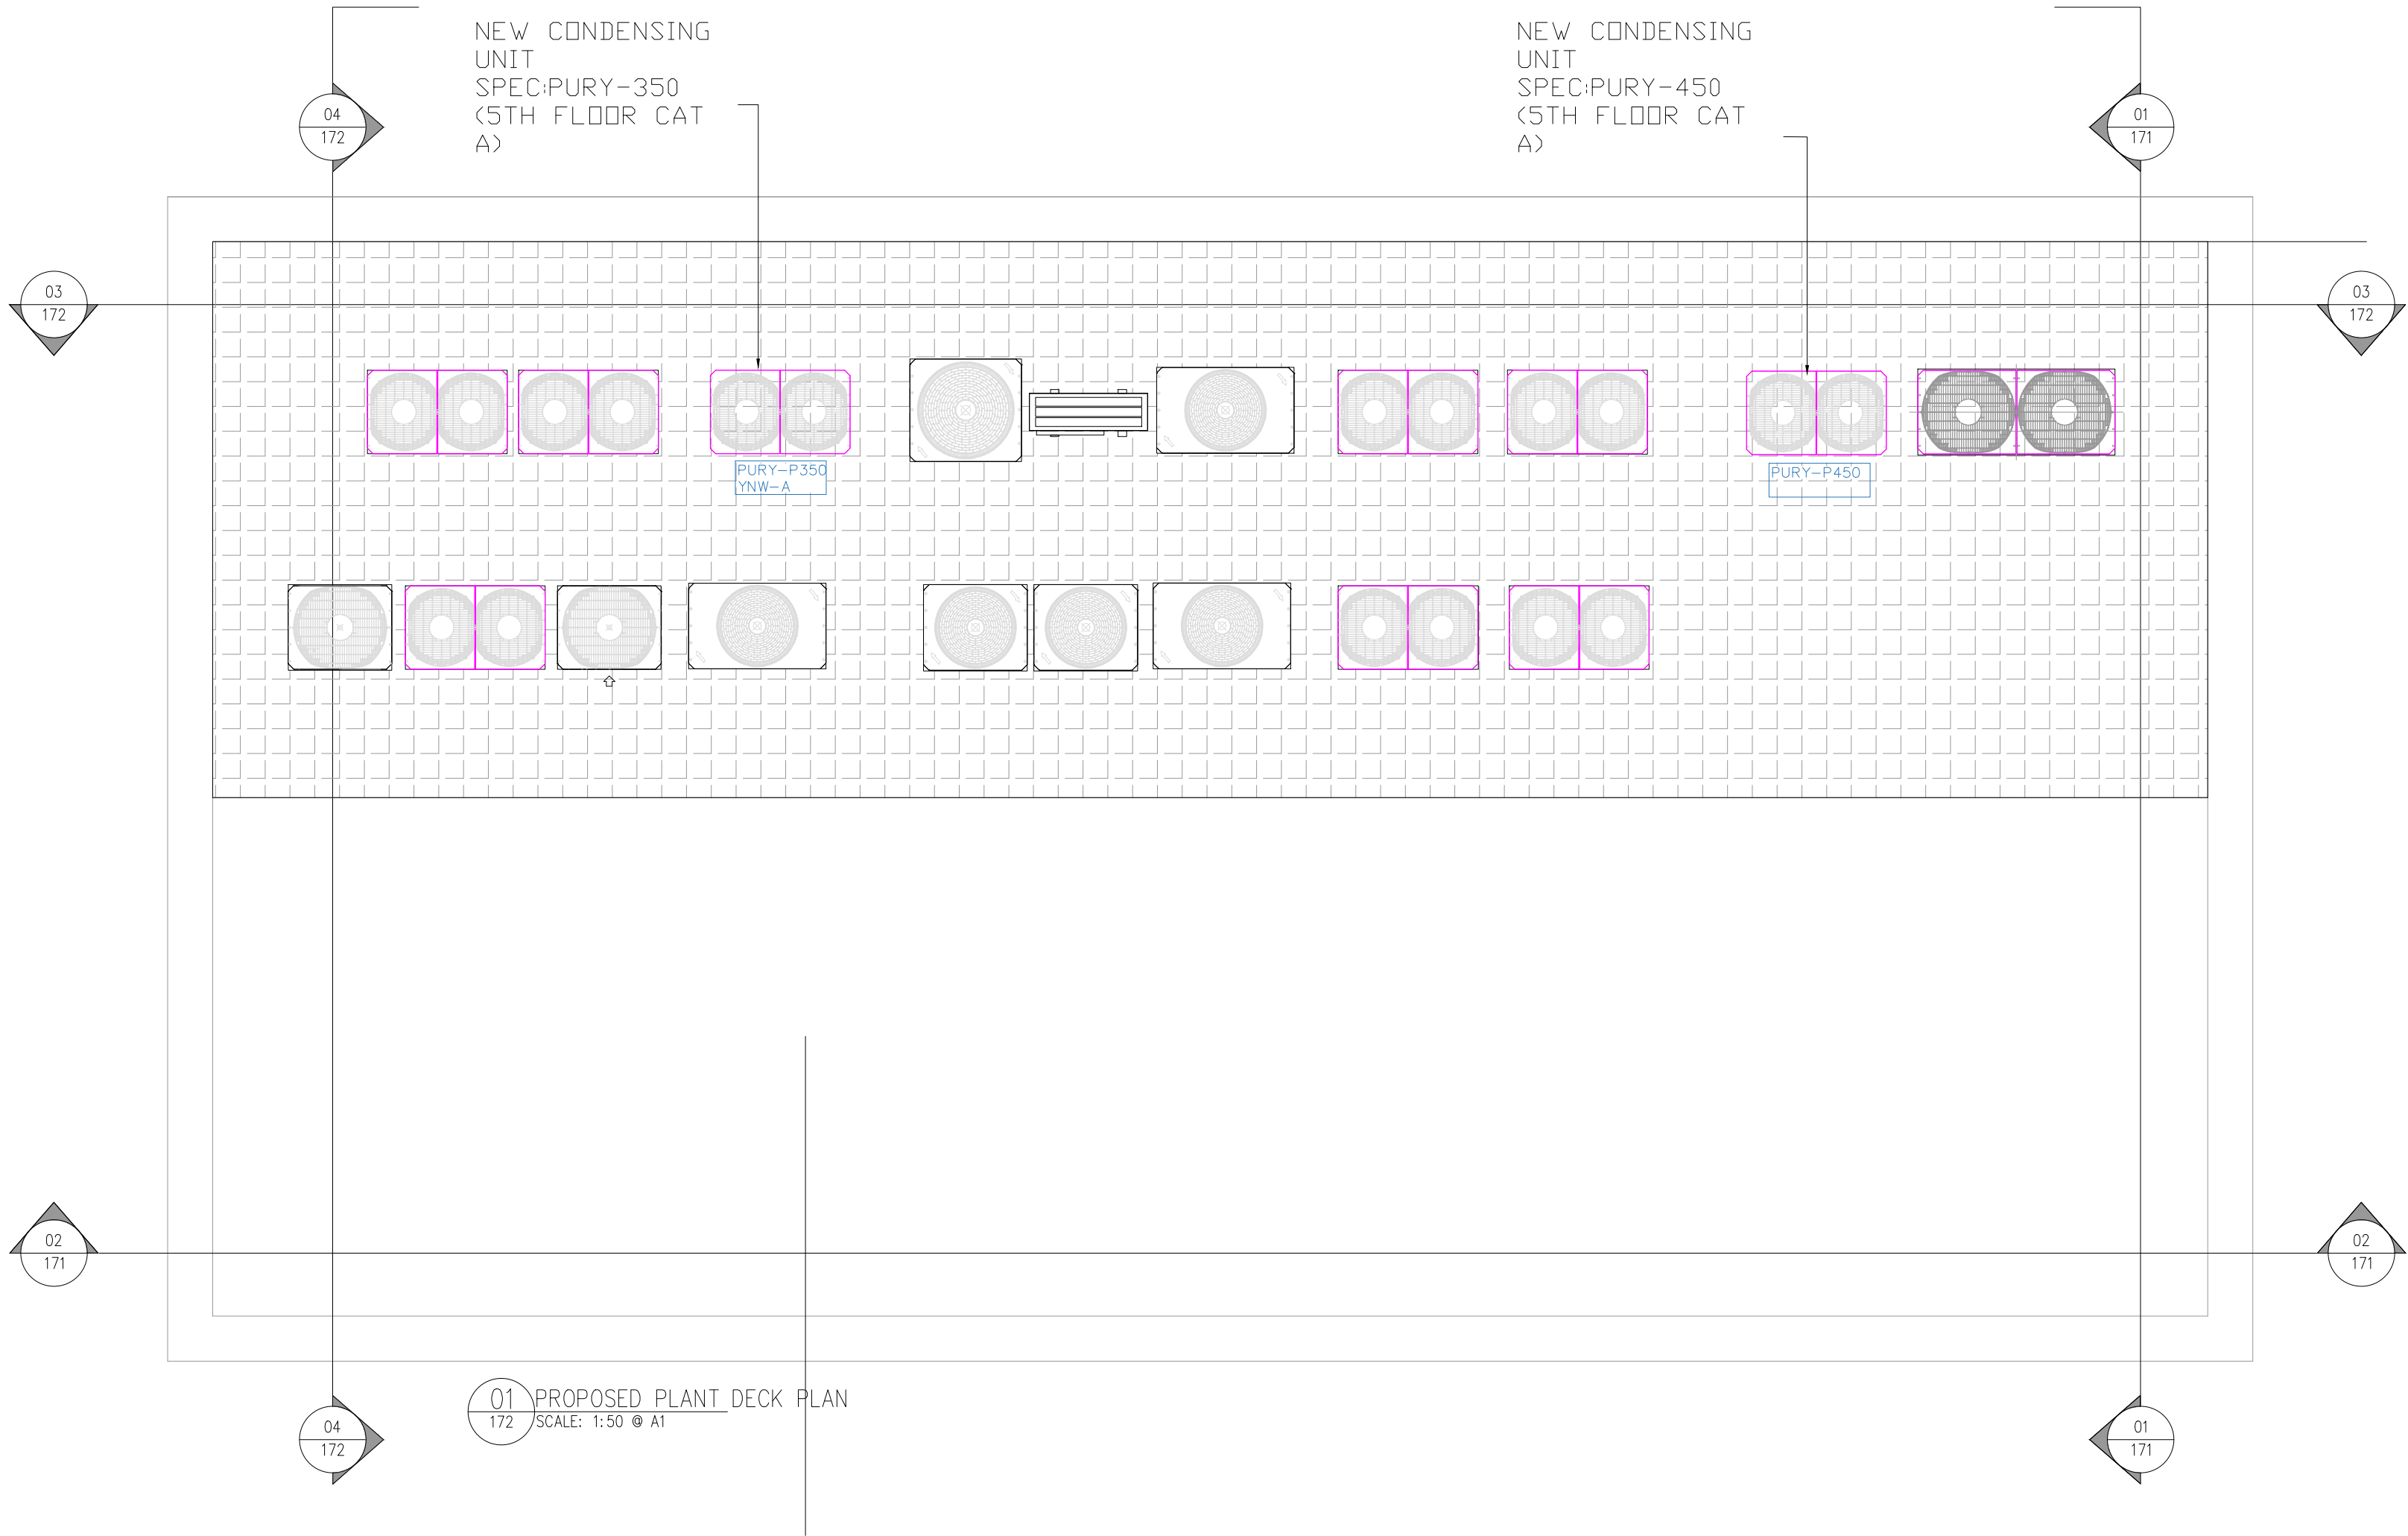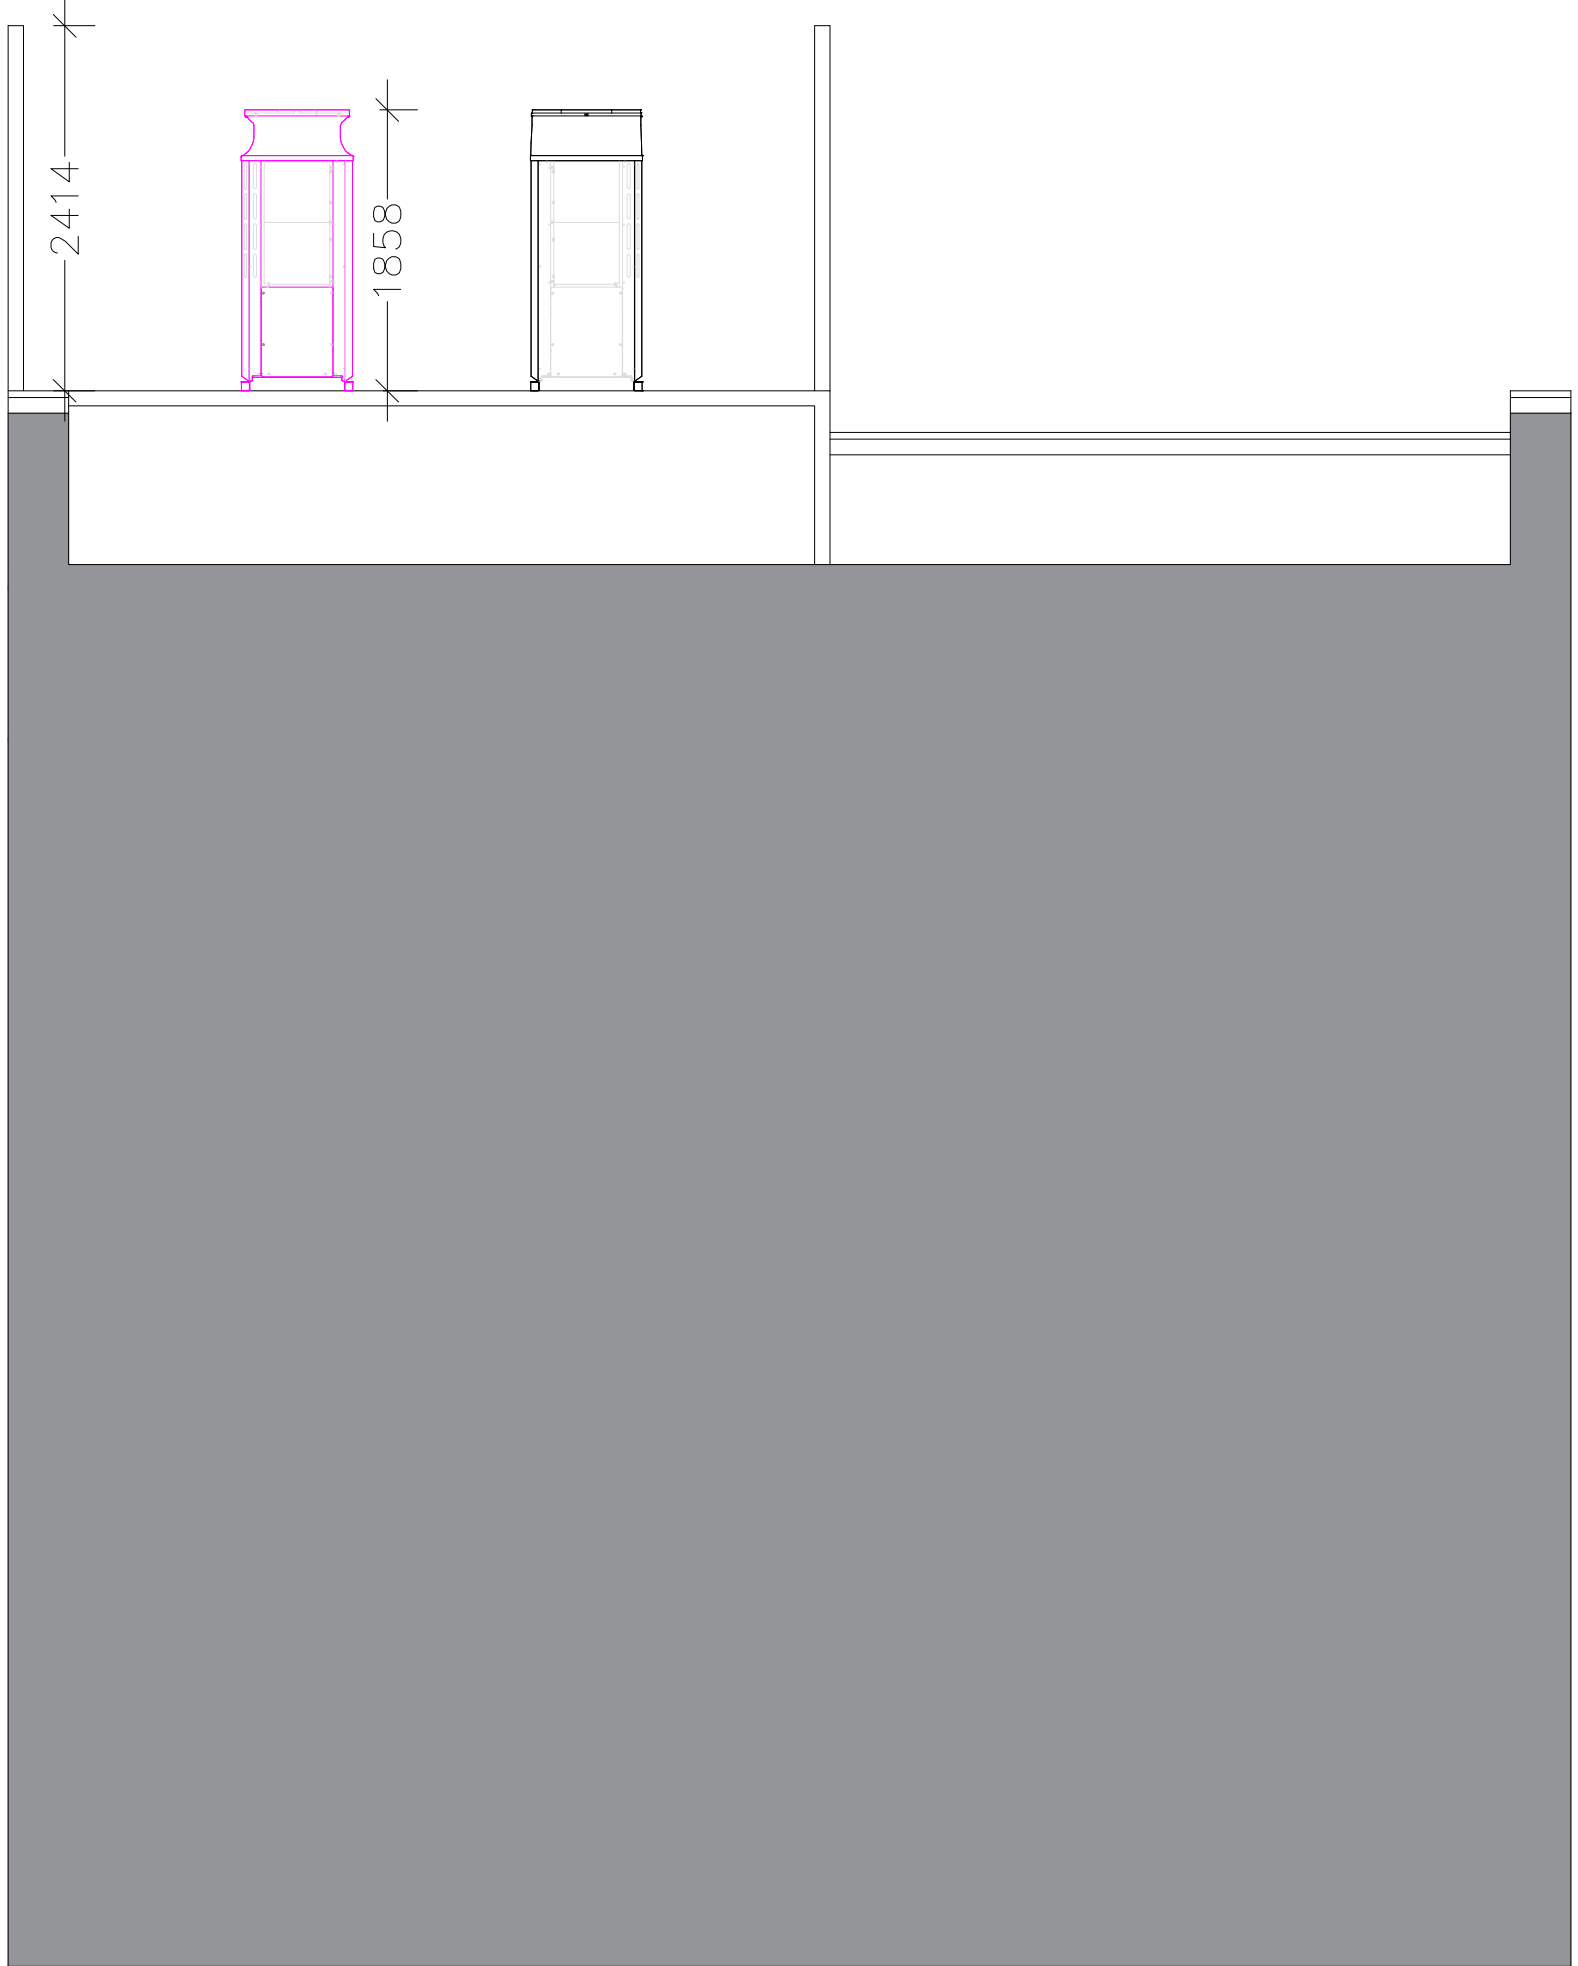

3.00	28/01/24	ISSUED FOR PLANNING Issued for planning.	JW	ARB
REV	DATE	DESCRIPTION	DRAWN	CHECKED
<div><div><div>B</div><div>BLOK PROJECTS</div></div></div>				
PROJECT LINLEY HOUSE MANCHESTER				
DRAWING REFERENCE PROPOSED MECHANICAL PLANT SECTION SHEET TWO				
DRAWN	CHECKED	DRAWING No		
ARB	JG	BP - PL 172		
STAGE	REV	JOB REFERENCE	DRAWING SCALE	DATE
3	00	24-235	1:200@A1	28.01.24
WEBSITE	:	www.blokprojects.com		
TELEPHONE	:	+44 (0)161 452 2668		
EMAIL	:	info@blokprojects.com		