



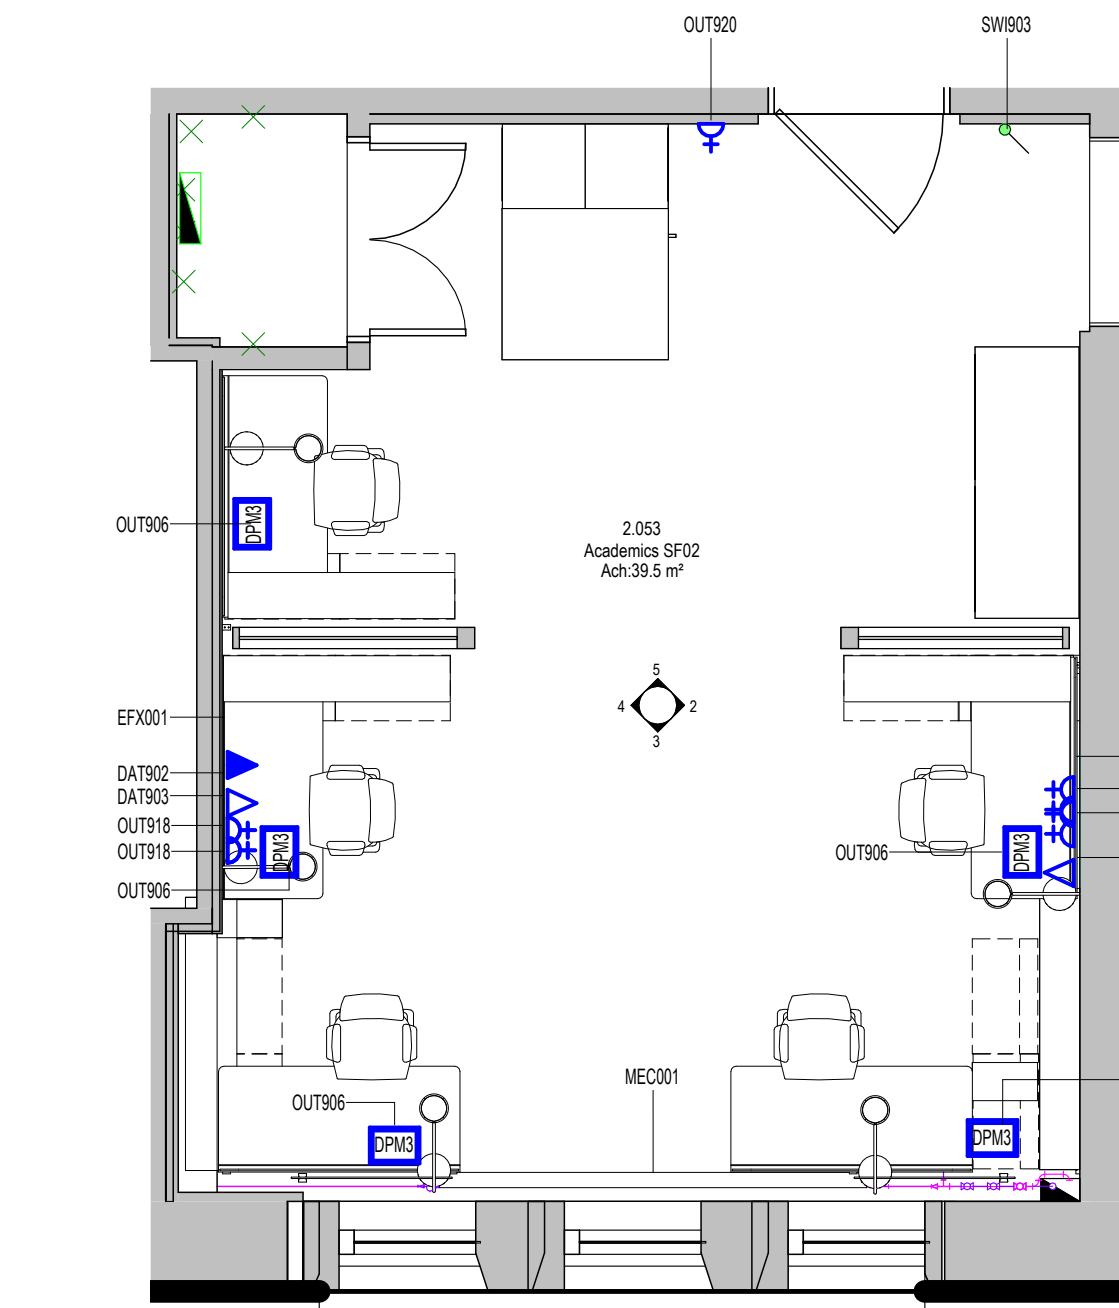

1 2.053 - Academics SF02 Floor Plan
1 : 50

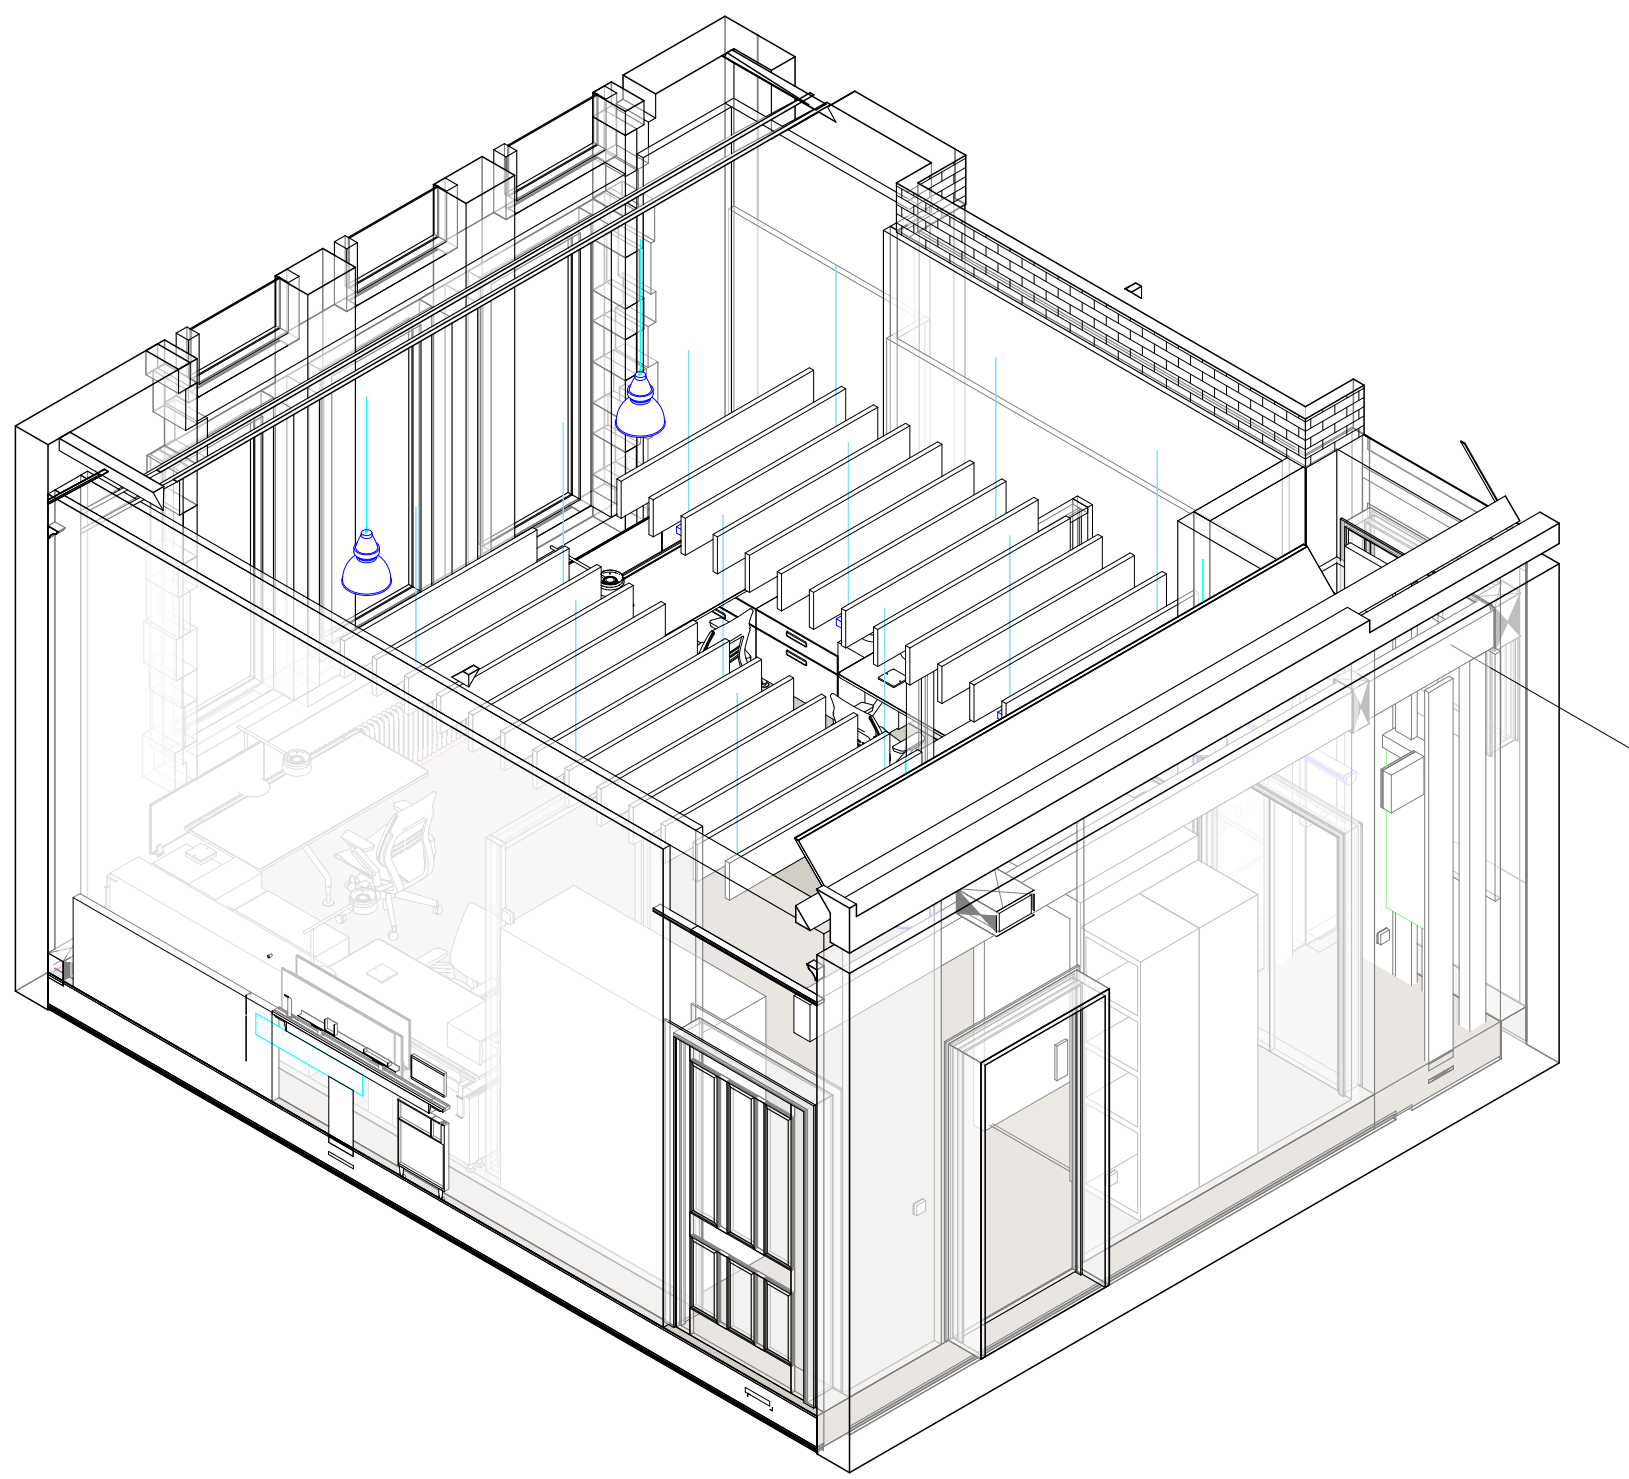

6 2.053 - Academics SF02 Isometric View


Space Number	Space Name	ADBCode	ADBDescription	ADBGroup
2.053-1	Academics SF02-1	DAT902	Double Gang RJ45 Outlet	1
2.053-1	Academics SF02-1	DAT903	Four Gang RJ45 Outlet	1
2.053-1	Academics SF02-1	EFX001	Electrical Fixture	1
2.053-1	Academics SF02-1	LGH001	Lighting Fixture	1
2.053-1	Academics SF02-1	MEC001	Mechanical Equipment	1
2.053-1	Academics SF02-1	OUT906	Automatic Changeover Switch	1
2.053-1	Academics SF02-1	OUT918	Double Switched Socket Outlet - Plastic	1
2.053-1	Academics SF02-1	OUT920	Single Switched Socket Outlet - Plastic	1
2.053-1	Academics SF02-1	SW903	Plastic Restorative Light Switch	1

Notes:
• This drawing is copyright.
• Do not scale dimensions from this drawing.
• This drawing is to be read in conjunction with all other relevant drawings.
• All discrepancies on this drawing are to be reported to the architect.
• Do not modify any element of this drawing.
• Use drawing only for purpose(s) issued.
• This drawing may contain colour.


Scale Bar

Key Plan


The following external model files are included within this drawing:

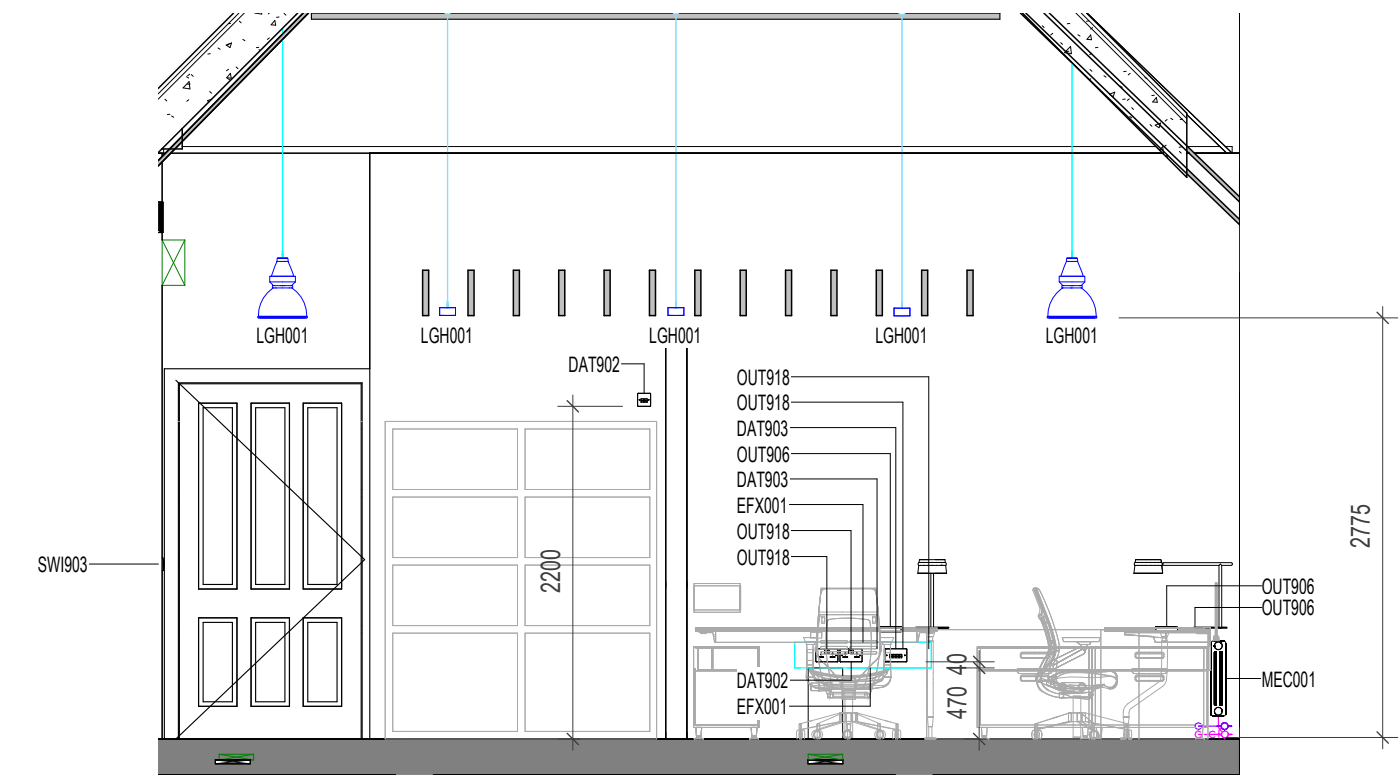


2 ELEVATION 2
1 : 50

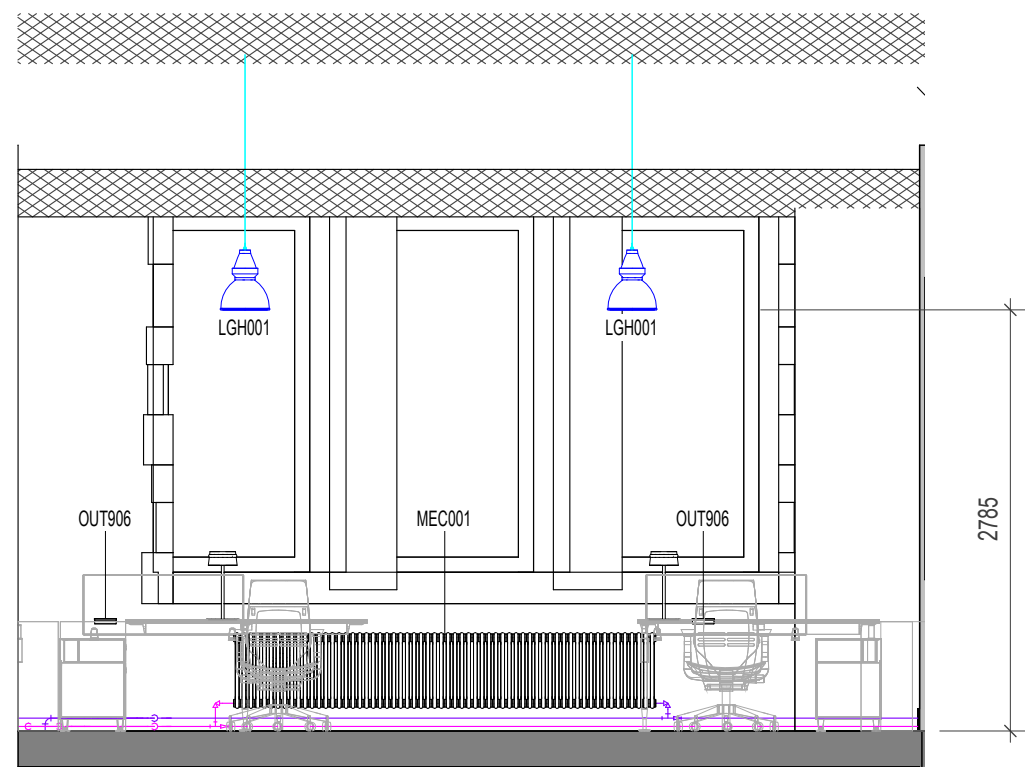

3 ELEVATION 3
1 : 50

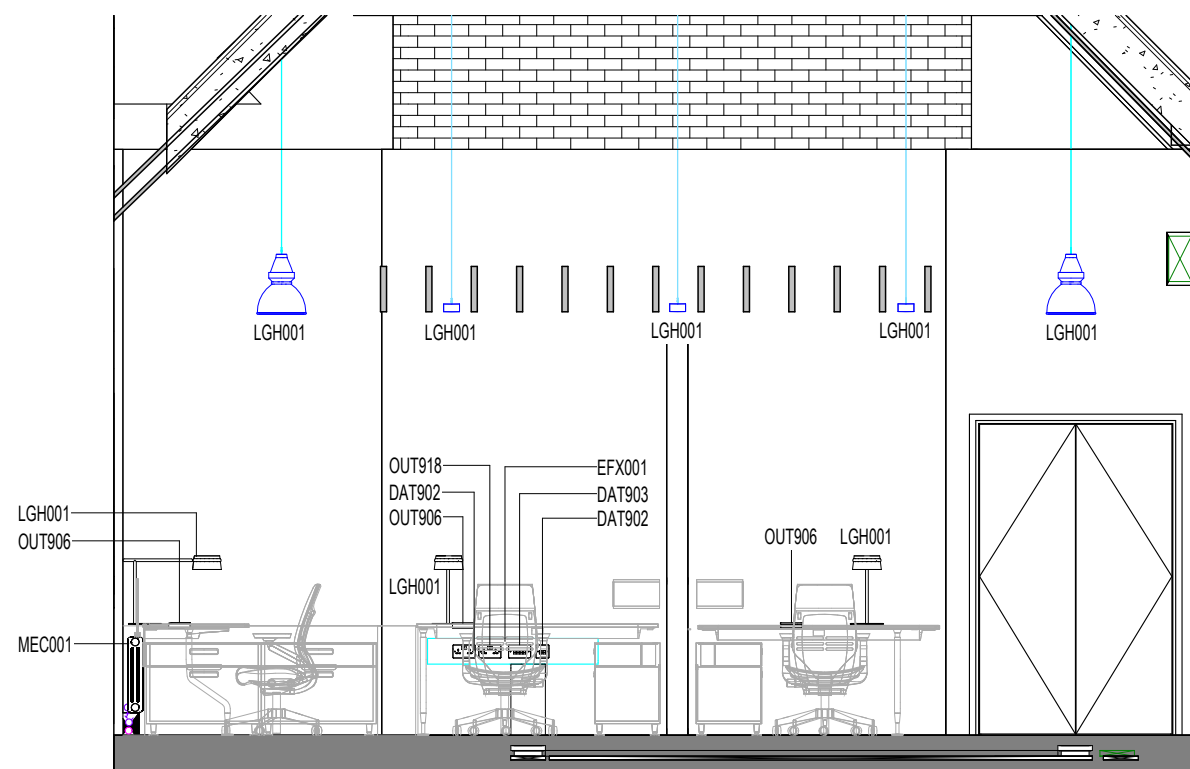

4 ELEVATION 4
1 : 50

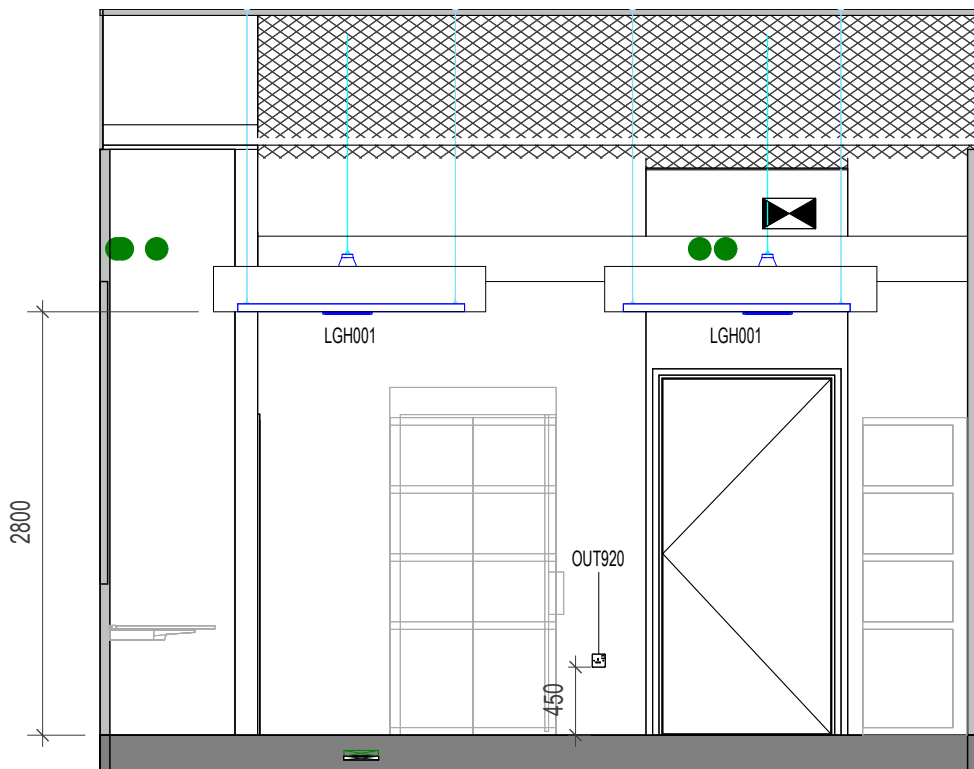

5 ELEVATION 5
1 : 50

P3	2024/12/13	C-sheets issued to MCC	AB	RM
P2	2024/07/26	C-sheets issued to MCC	AB	RM
P1	2024/07/12	Screen on ground floor should be Fire Rated	AB	RM
Rev	Date	Revision Notes	Drawn	Review

MANCHESTER
1824
The University of Manchester

ARCADIS

Project
Rutherford Building

Drawing Title
2.053 - Academics SF02

Job Number 141532	Date	Security Classification	Drawn By AJ
Scale@A1 1 : 50	Purpose LISTED BUILDING CONSENT	Reviewed By AB	Revision P3
Drawing Number 4915-RBUM-ARC-XX-ZZ-DR-A-4915			