




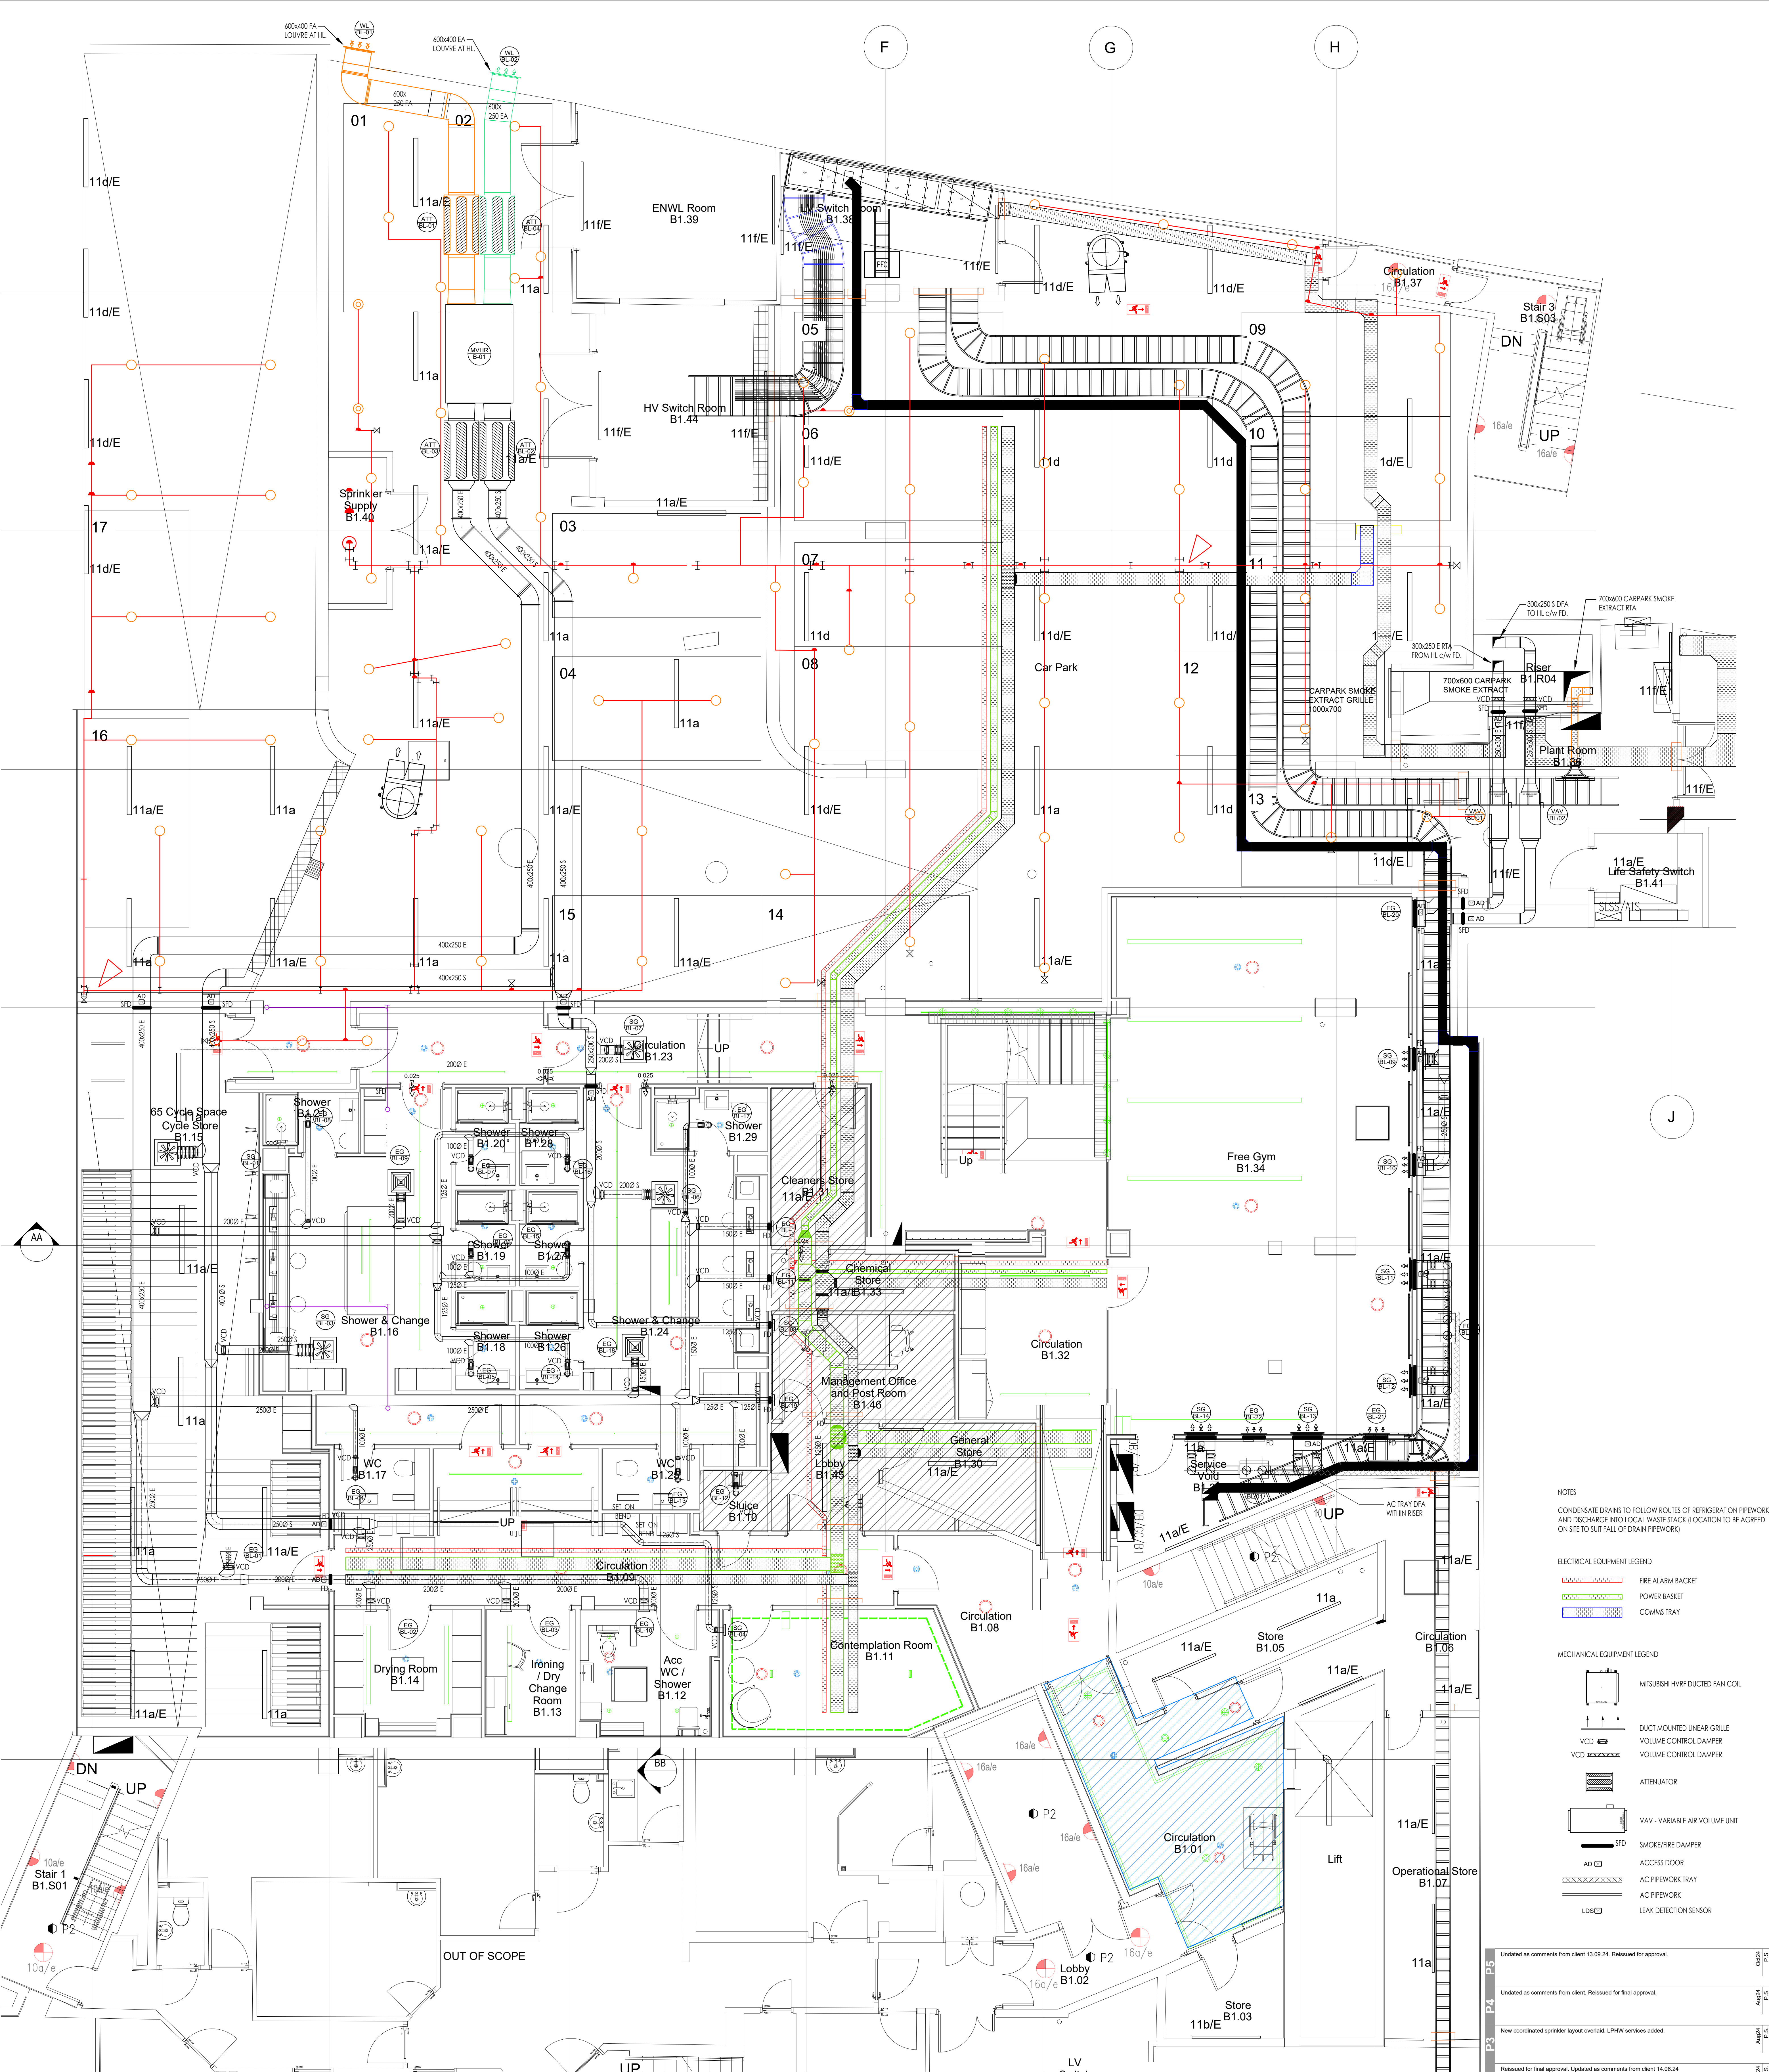

PLAN AT BASEMENT FLOOR LEVEL Scale 1:50

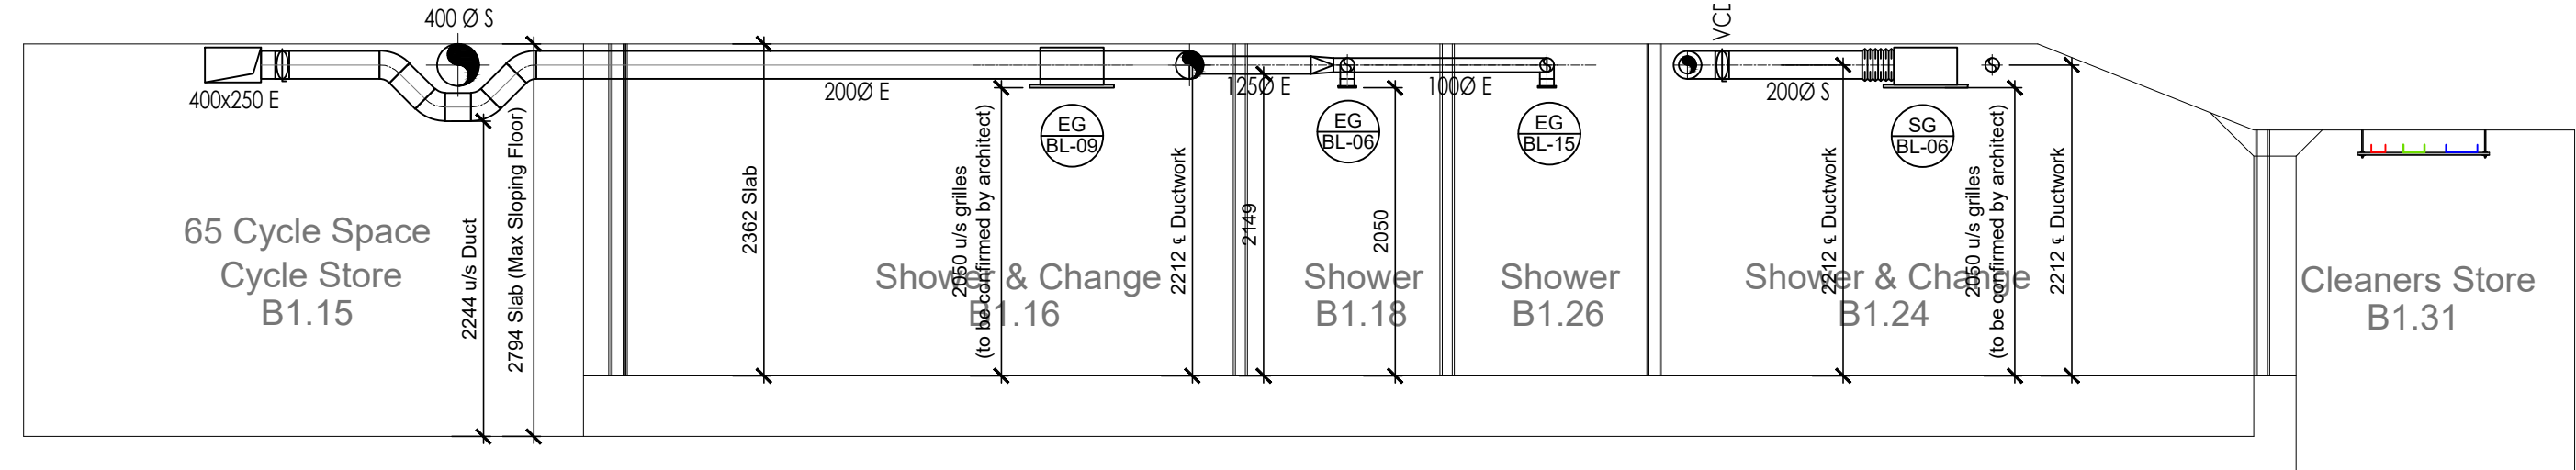

SECTION 'A' - 'A' Scale 1:50

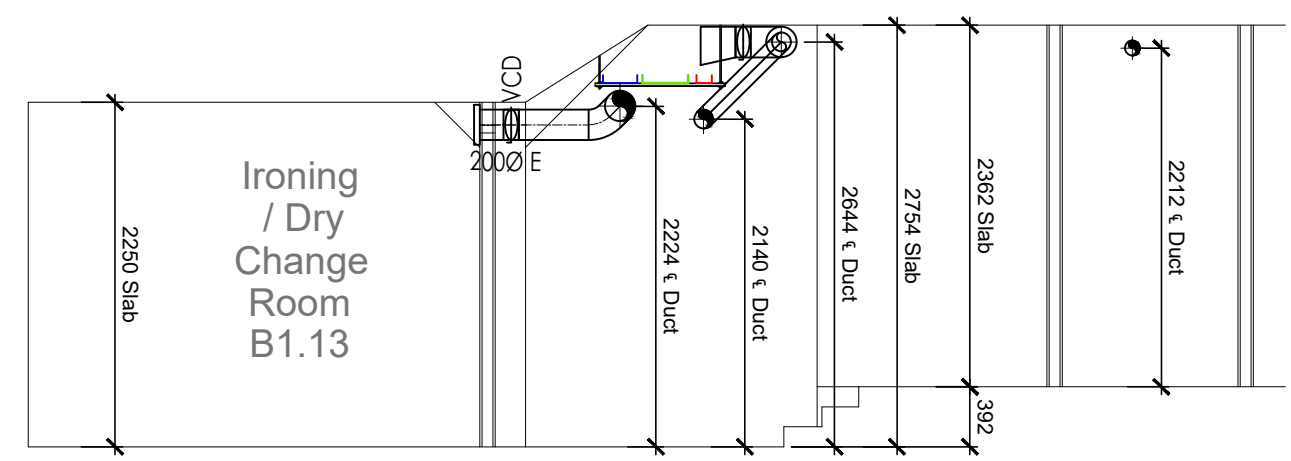

SECTION 'B' - 'B' Scale 1:50

NOTES
CONDENSATE DRAINS TO FOLLOW ROUTES OF REFRIGERATION PIPEWORK
AND DISCHARGE INTO LOCAL WASTE STACK (LOCATION TO BE AGREED
ON SITE TO SUIT FALL OF DRAIN PIPEWORK)

ELECTRICAL EQUIPMENT LEGEND
FIRE ALARM BACKET
POWER BACKET
COMMS TRAY

MECHANICAL EQUIPMENT LEGEND
MITSUBISHI HVRF DUCTED FAN COIL
DUCT MOUNTED LINEAR GRILLE
VOLUME CONTROL DAMPER
VOLUME CONTROL DAMPER
ATTENUATOR
VAV - VARIABLE AIR VOLUME UNIT
SMOKE/FIRE DAMPER
ACCESS DOOR
AC PIPEWORK TRAY
AC PIPEWORK
LEAK DETECTION SENSOR

Revision	Description	Date	By	Check	Appr
P5	Updated as comments from client 13.09.24. Reissued for approval.	13/09/24	P.S.	D.I.	S.K.
P4	Updated as comments from client. Reissued for final approval.	14/09/24	P.S.	D.I.	S.K.
P3	New coordinated sprinkler layout overlaid. LPHW services added.	14/09/24	P.S.	D.I.	S.K.
P2	Reissued for final approval. Updated as comments from client 14.06.24	14/06/24	P.S.	D.I.	S.K.
P1	For Approval	14/06/24	P.S.	D.I.	S.K.
Client					
Project	Bruntswood				
	Pall Mall Manchester				
Title	Coordinated M+E Services Layout Basement Floor Level				
Drawn by	P.S.				
Checked by	D.I.				
Approved by	S.K.				
Scale	1:50				
Sheet Size	A0				
Issue Date	March 24				
Contract No.	CW11193				
Drawing No.	ME-59-B-01				
Revision	P5				

The contractor is to check all dimensions and conditions on site before commencing. DO NOT SCALE - USE DIMENSIONS
DIMENSIONS ONLY. This drawing is confidential & is the property of CubicWorks Ltd. It must not be copied, loaned or
disclosed to any third party without prior written consent.