
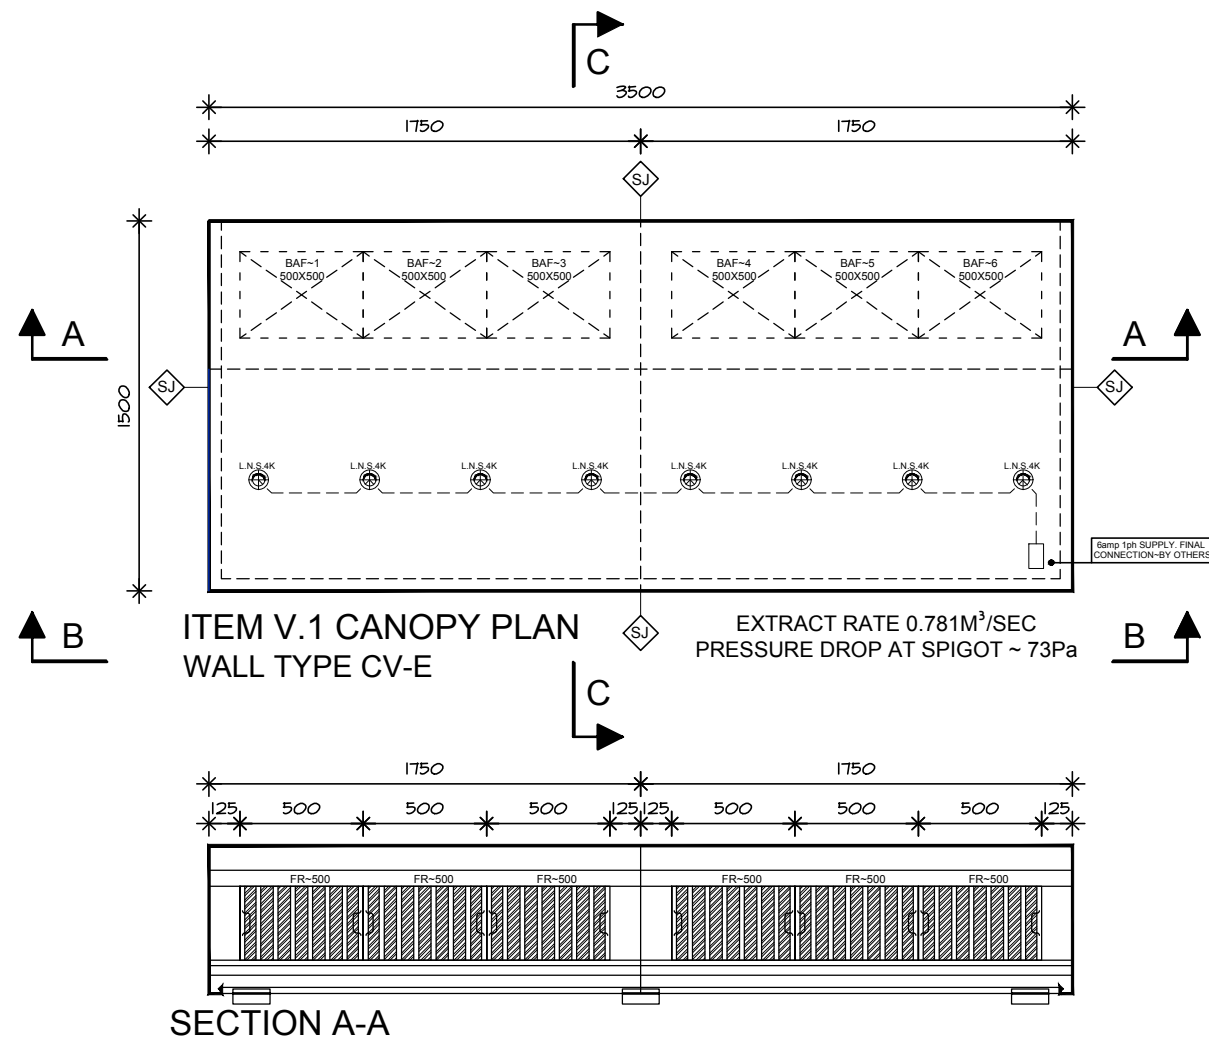
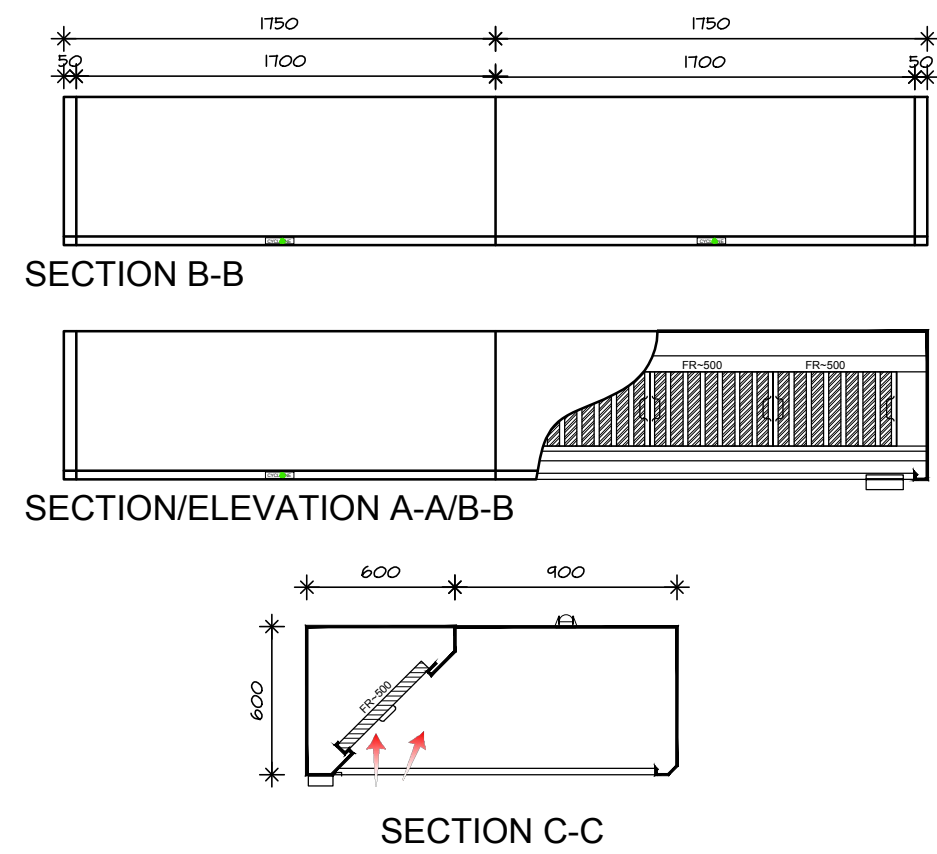
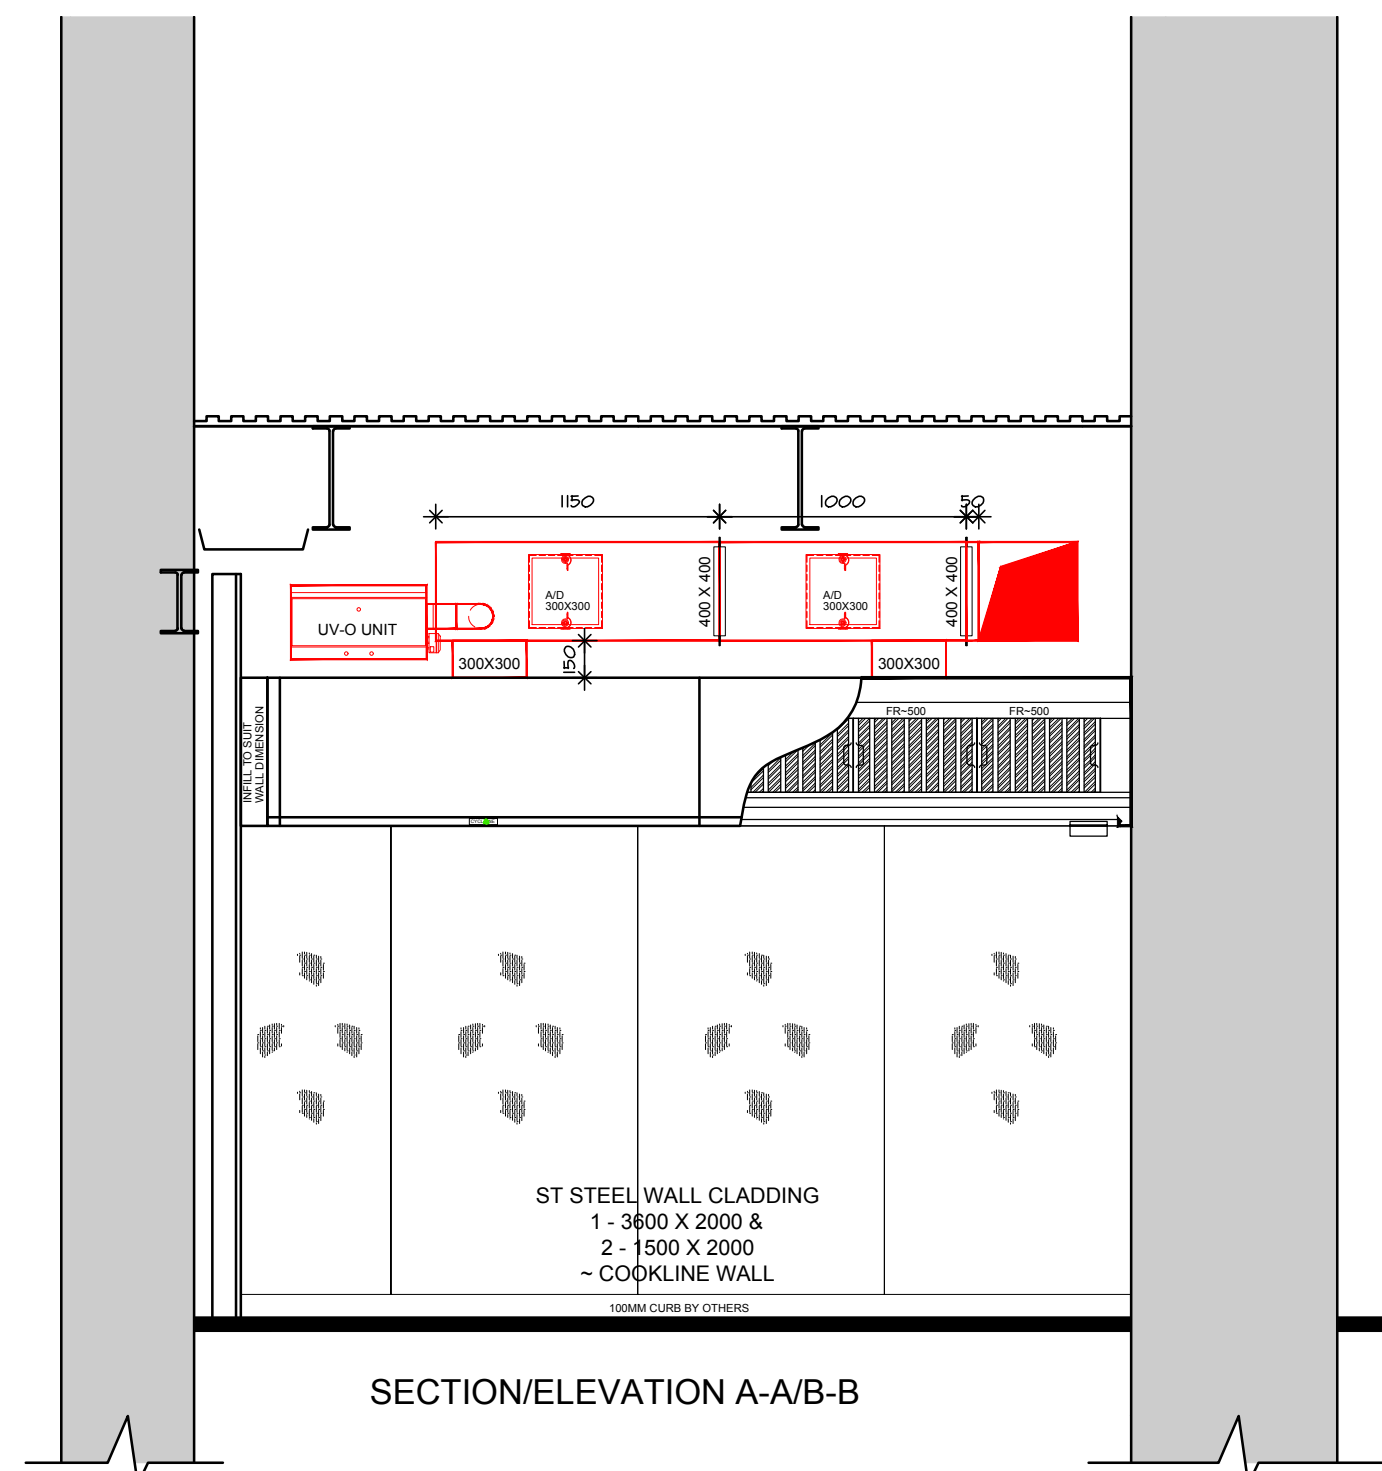


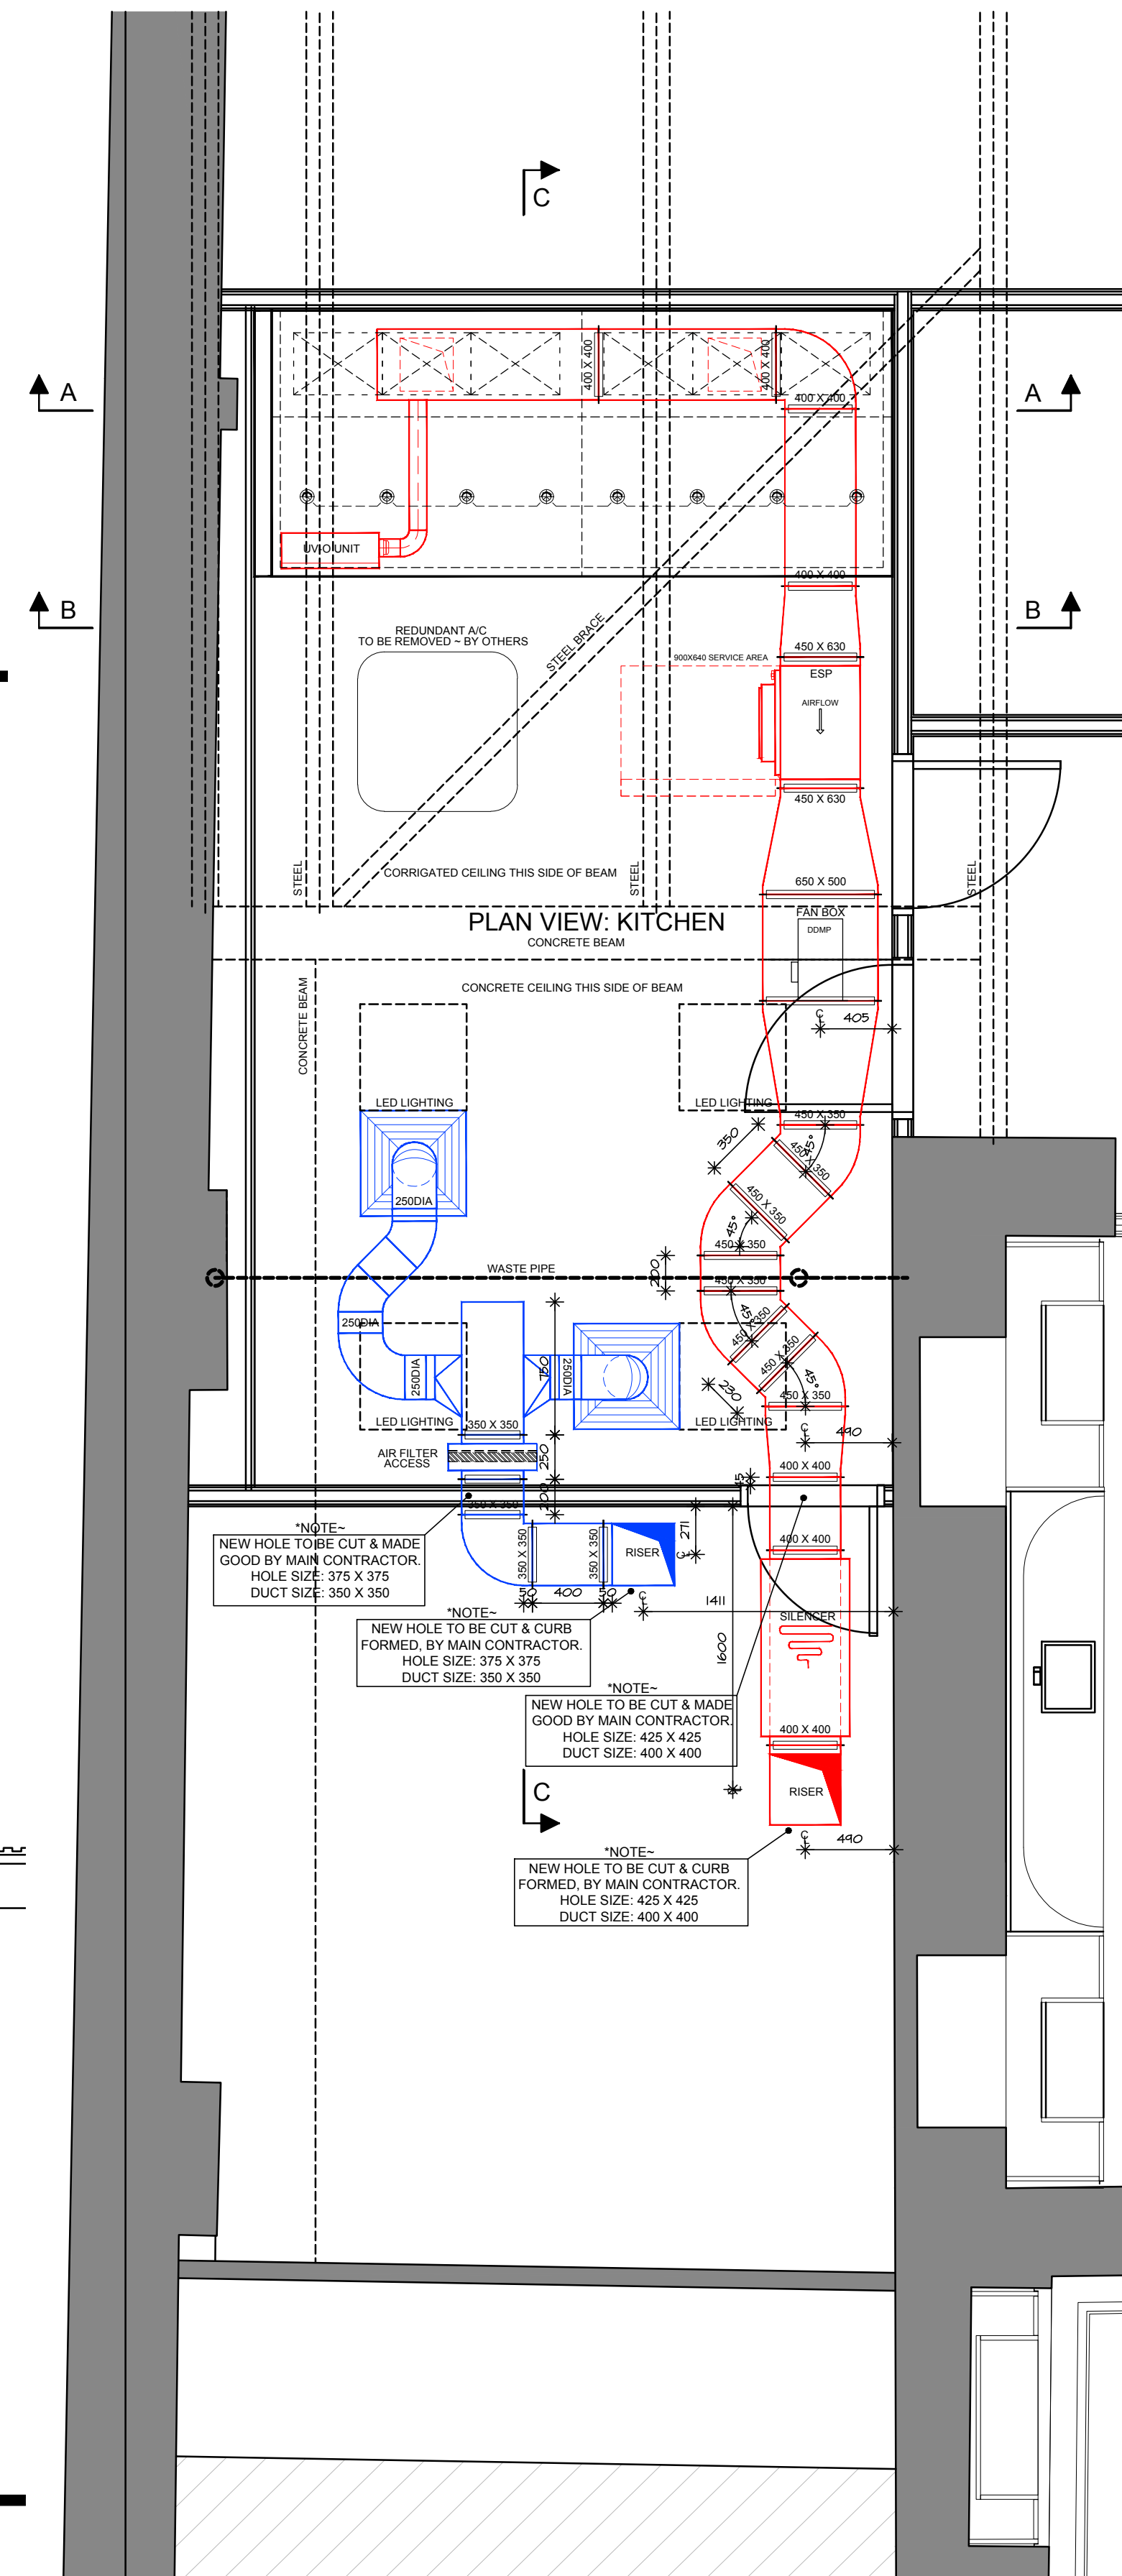


FAN & ELECTRICAL DATA

KITCHEN EXTRACT FAN:
MANUFACTURER & MODEL: NICOTRA DMP
POWER SUPPLY: 230V-1PH
ELECTRICAL LOADINGS: T.B.C
CONTROLLER TYPE: POTENTIOMETER

KITCHEN SUPPLY FAN:
MANUFACTURER & MODEL: N/A
POWER SUPPLY: N/A
ELECTRICAL LOADINGS: N/A
CONTROLLER TYPE: N/A

PLAN VIEW: ROOF PLANT AREA

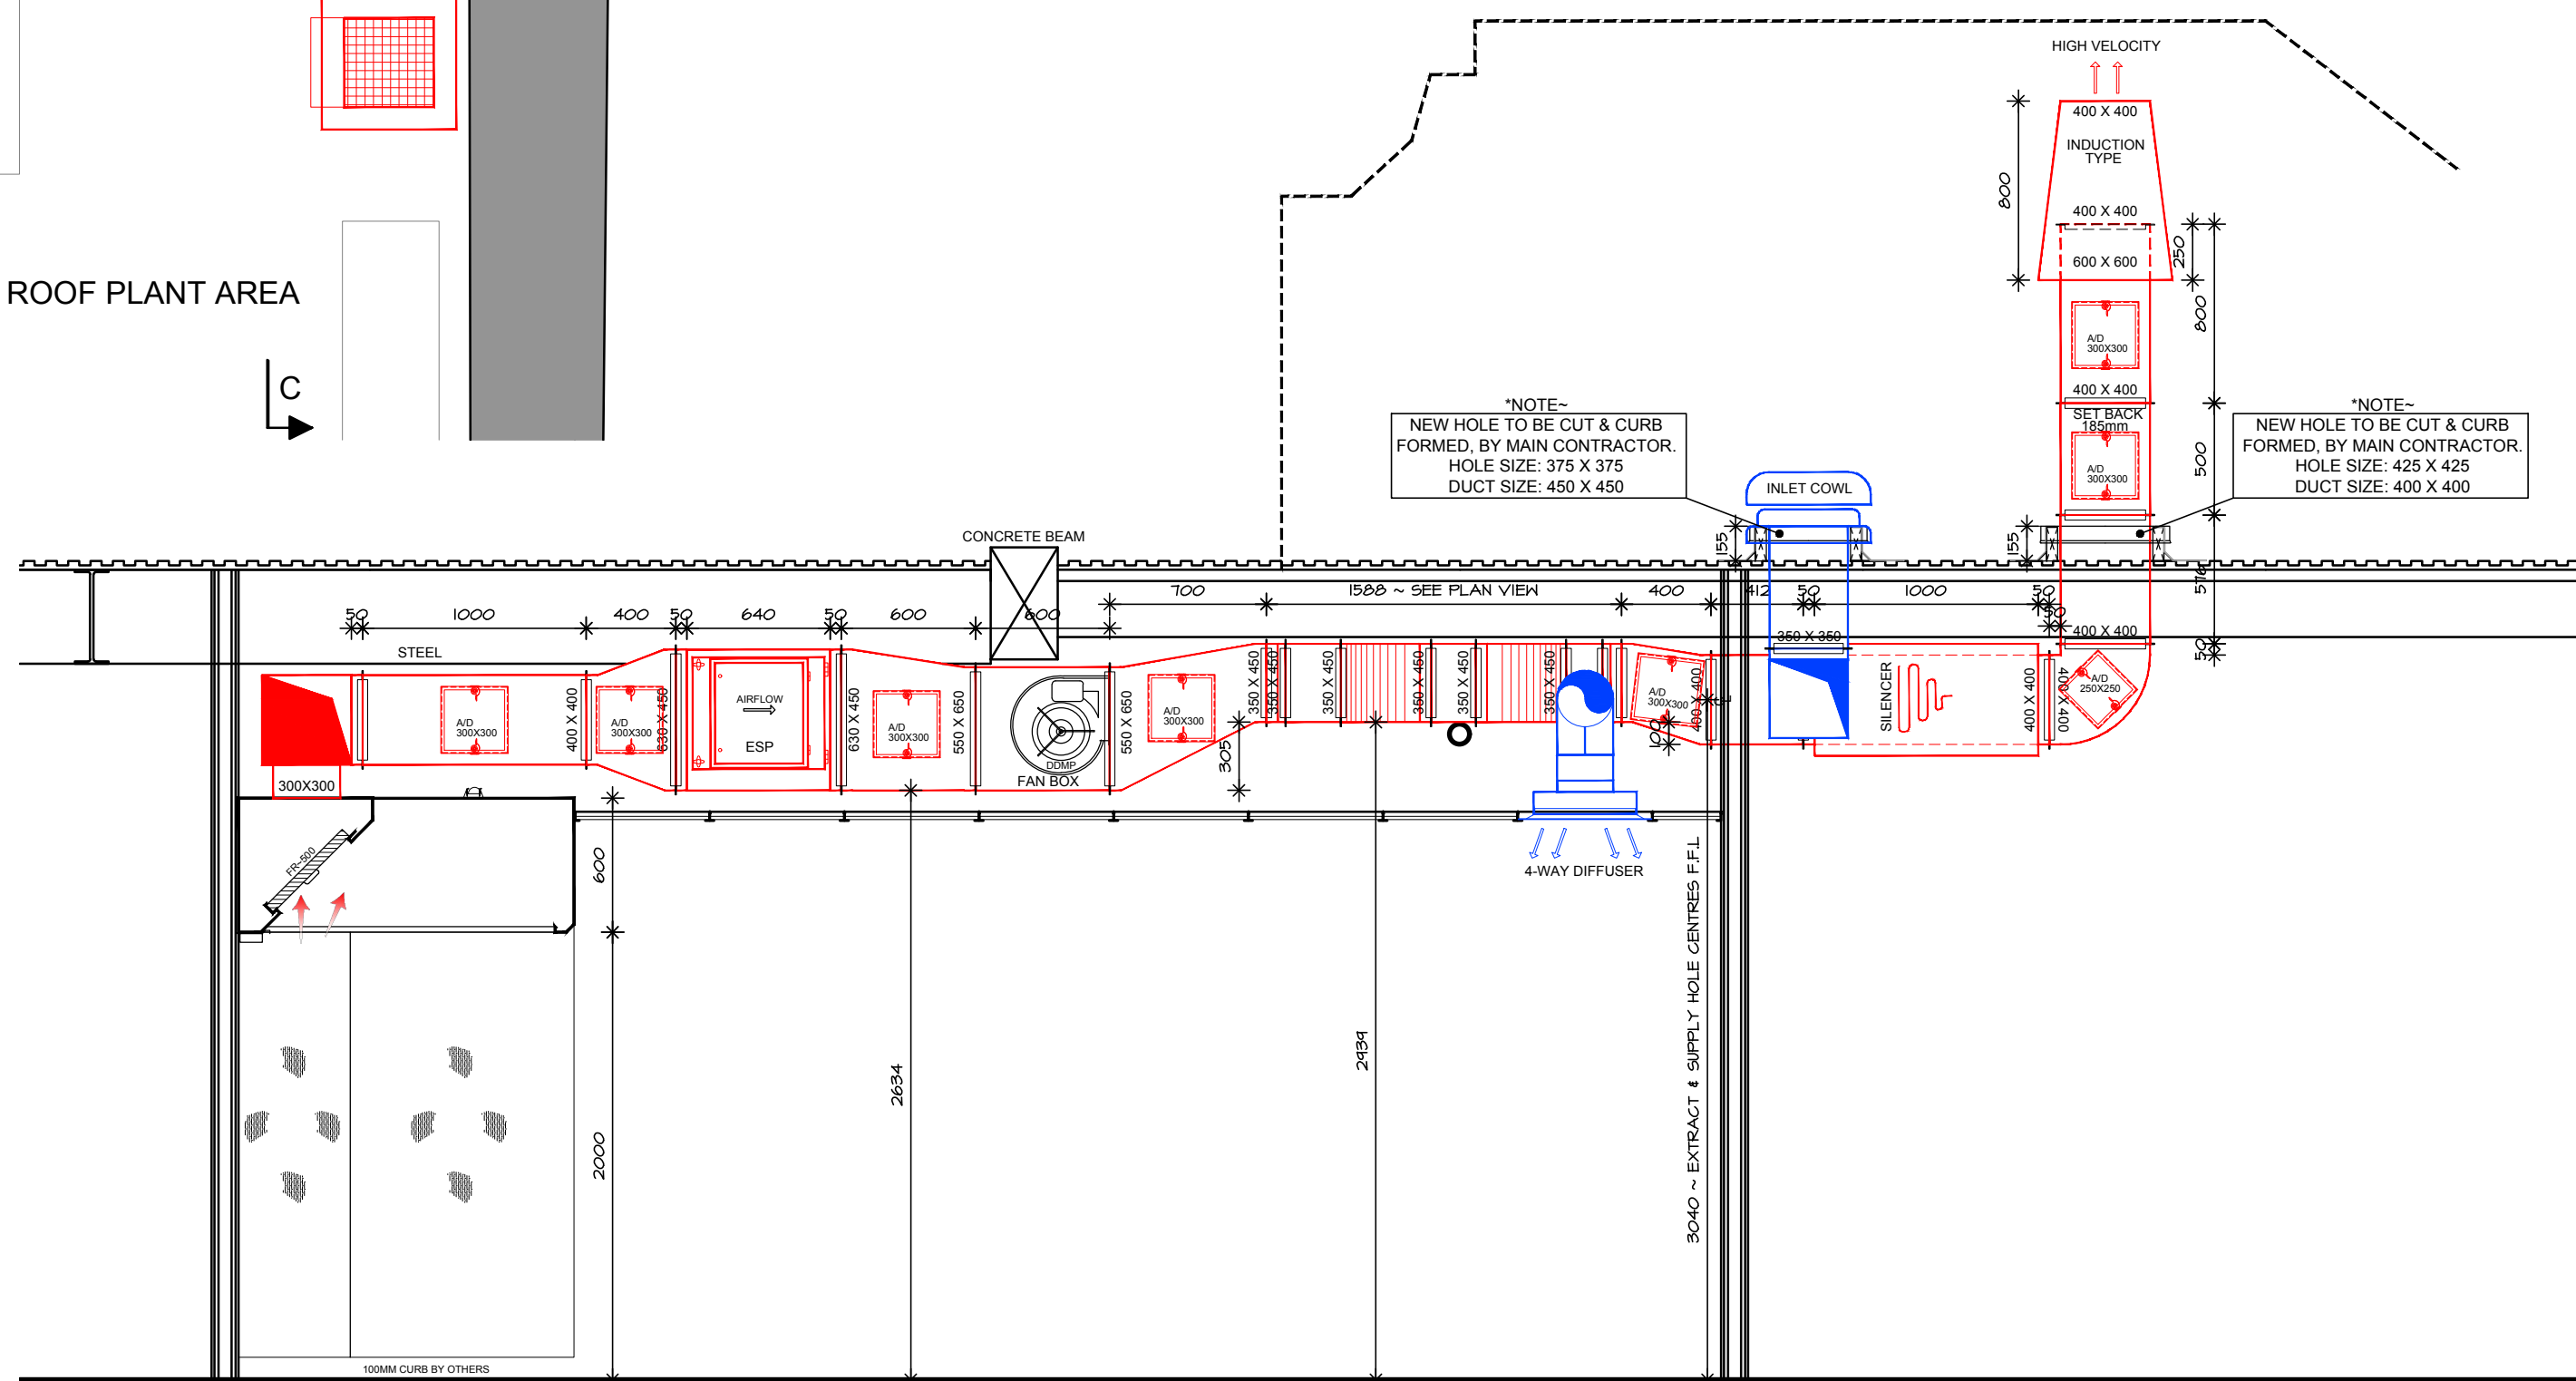

STATUS

APPROVAL

SUPPLY AIR SYSTEM ADDED
DUCTWORK ALTERATIONS

REV. DATE

B A 05.12.24
14.11.24

DESCRIPTION

CYCLONE VENTILATION

Cyclone Ventilation Ltd.
UNIT 5, Ashfield Close, Whitehall Road
Industrial Estate, Leeds, LS12 5JB.
Tel: 01132 632900
email: sales@cycloneventilation.co.uk
Web: www.cycloneventilation.co.uk

CLIENT

SALIX COMMERCIAL KITCHENS

PROJECT

AP HOUSE, MANCHESTER

DRAWING

NEW KITCHEN VENTILATION SYSTEM

SCALE

1:30@A1

DRAWN

CJW

CHECKED

RPW

REV.

B

DATE

JUNE 2024

JOB NO.

CV24-1250

DWG. NO.

001

Original sheet size A1

COPYRIGHT ©
This drawing is copyright and issued to you in confidence. It must not be copied, used or disclosed, in whole or in part, to third parties without our written permission. It remains the property of CYCLONE VENTILATION LIMITED and must be returned on request. ©
NOTE: All dimensions are in millimetres unless stated otherwise. If in doubt ask. Do not scale from this drawing.
DRAWING INFORMATION
This CAD drawing is plotted from file: CV24-1250-001
This CAD drawing contains the following Xrefs: -

LAYER KEY

FIRE RATED DUCTWORK

EXTRACT DUCTWORK

SUPPLY DUCTWORK