


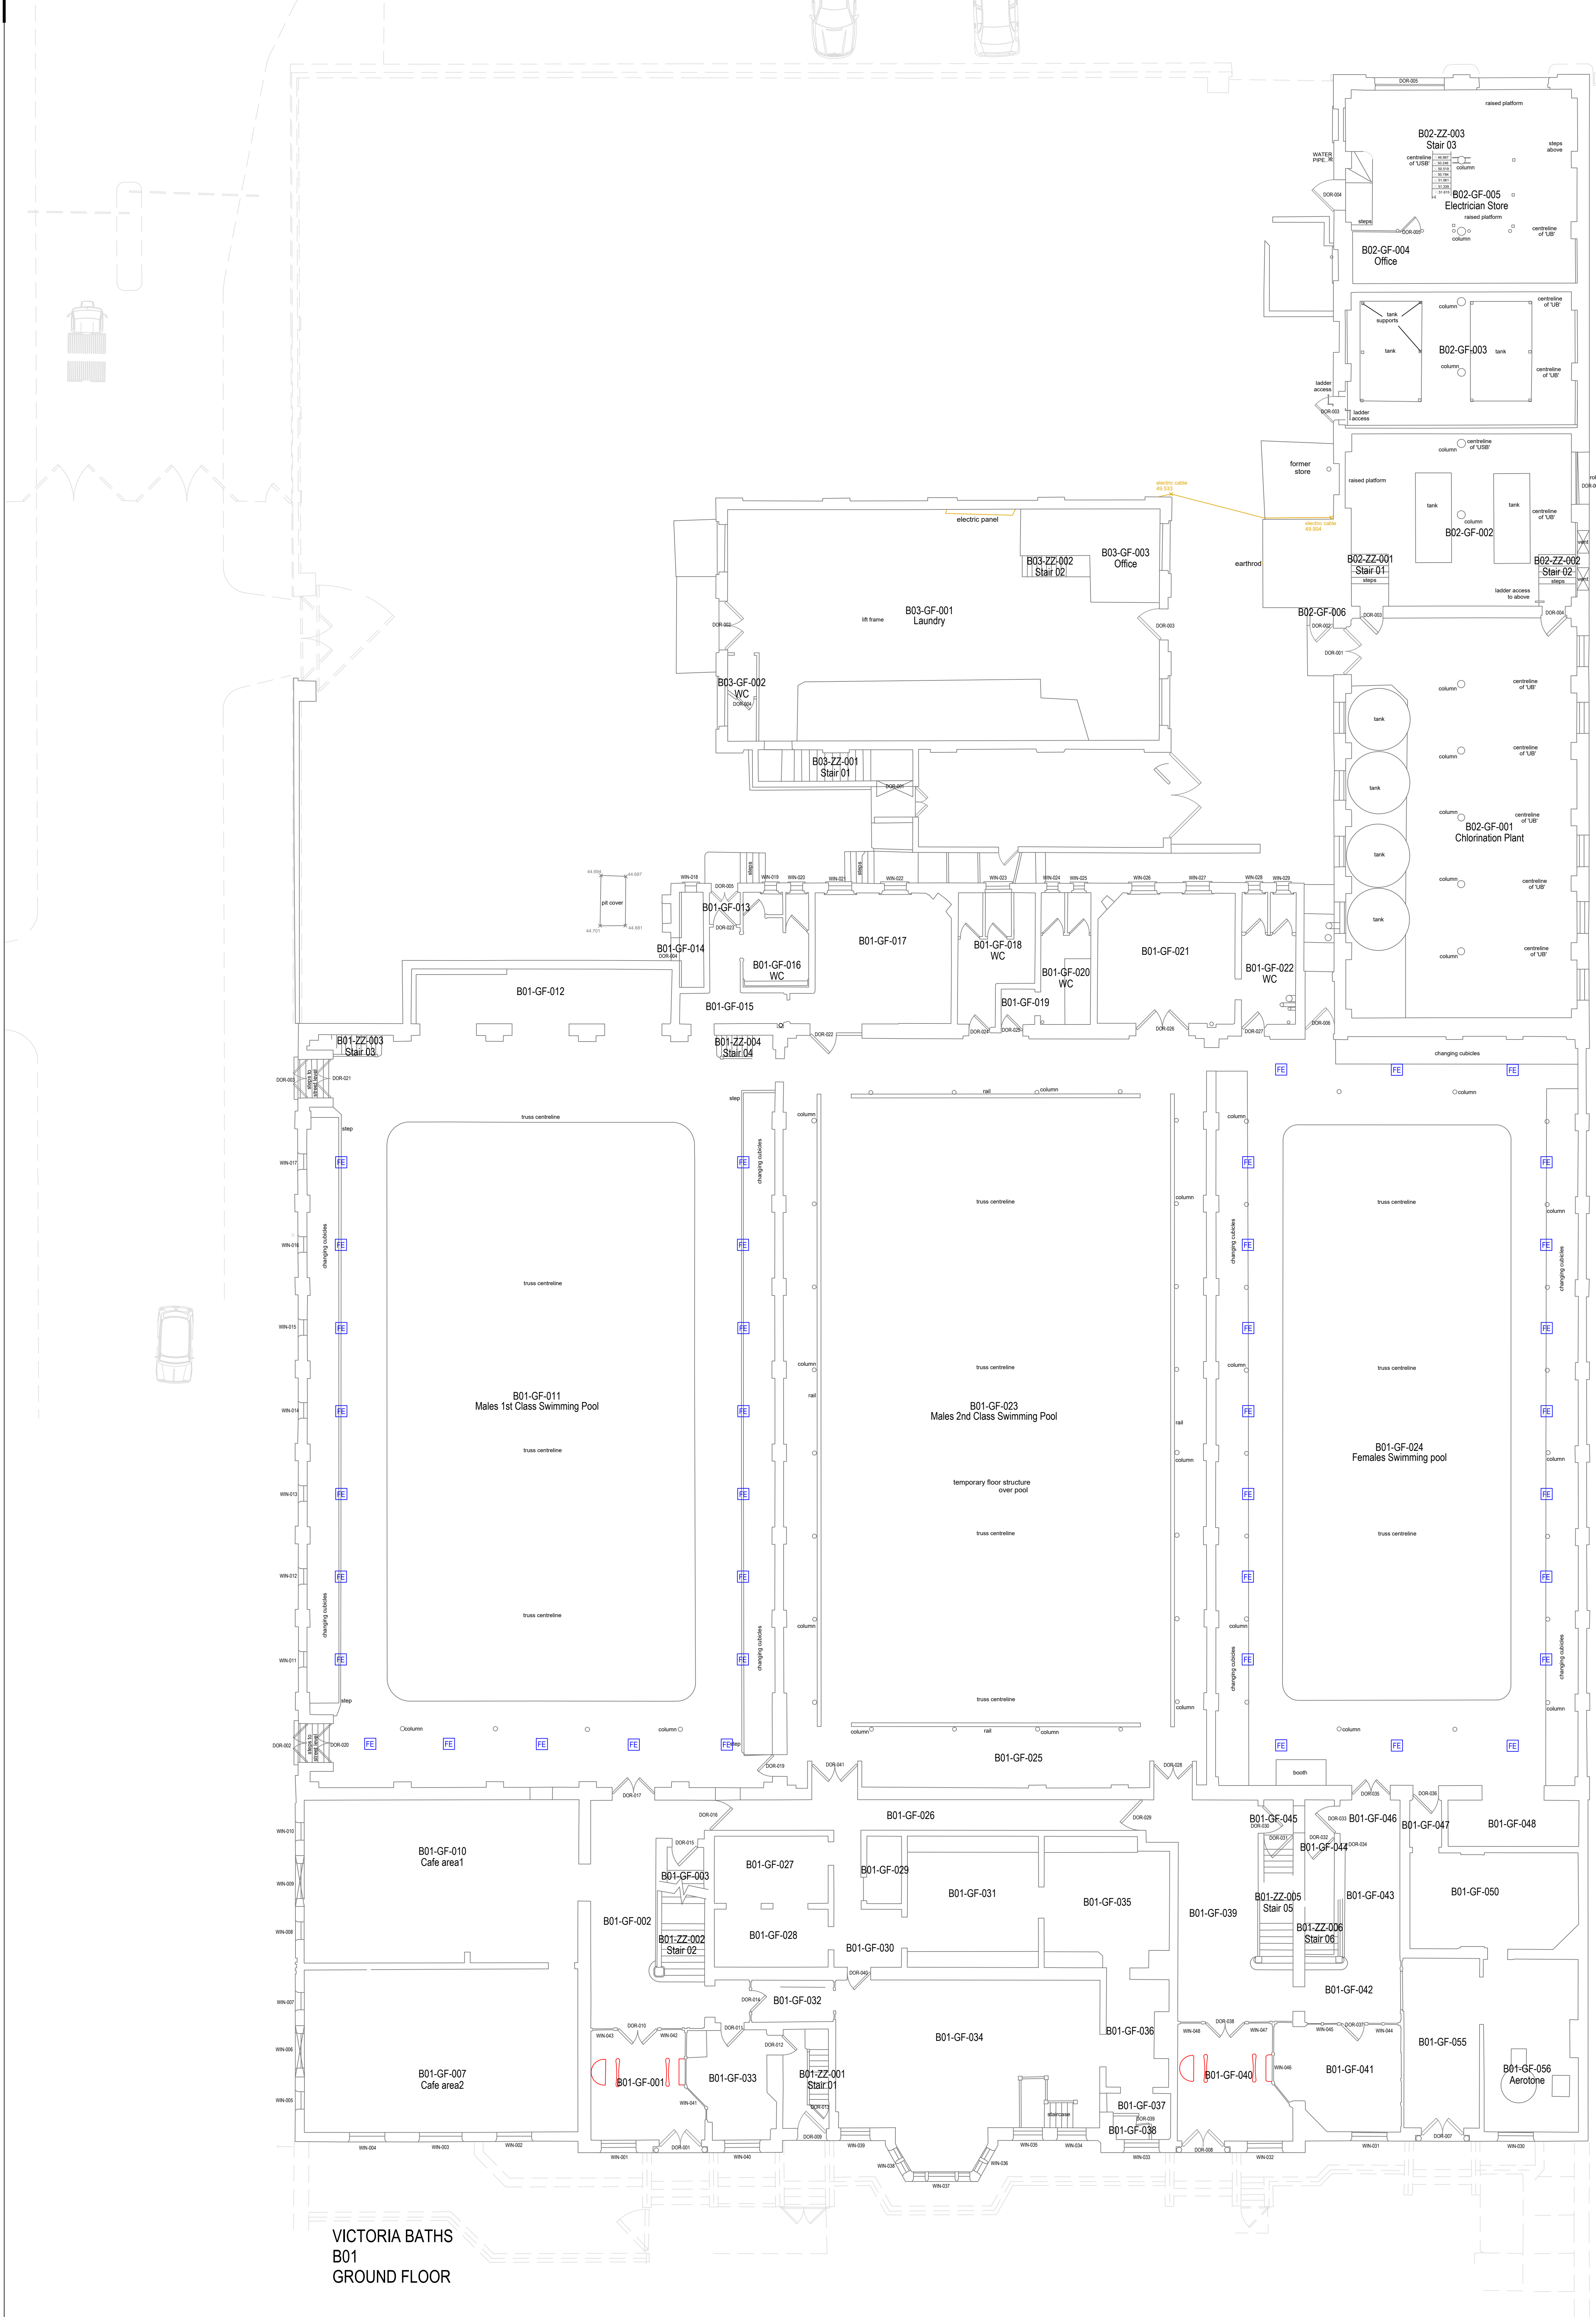

Proposed General Fittings				
Ref.	Description	Manufacturer	Fitting Ref.	Type
A	LED LINEAR SURFACE IP65 FITTING	DEXTRA	TYPHON SENSOR 26W - 3870 LUMENS - 148lm/W REF - TYP L45 PC SS AE - 3HR EMERGENCY VERSION	
B	LED LINEAR SURFACE FITTING	DEXTRA	ECO PACK SENSOR 26W - 3924 LUMENS - 150lm/W REF - EPK L45 BE - 3HR EMERGENCY VERSION	
C	LED 600x600 SURFACE FITTING	DEXTRA	MODLED SURFACE UGR 26.5W - 2939 LUMENS - 110lm/W REF - MODSU L45 CE - 3HR EMERGENCY VERSION	
D	LED LINEAR SURFACE FITTING	DEXTRA	ECO PACK SENSOR AMENITY PLUS ROUND 20W - 2487 LUMENS - 124lm/W REF - ANC L30 WCO DE - 3HR EMERGENCY VERSION	
F	LED SQUARE SURFACE FITTING	DEXTRA	AMENITY PLUS LED 9.5W - 1148 LUMENS - 120lm/W REF - AMS L15 B0 FE - 3HR EMERGENCY VERSION	

NOTES

- All dimensions are in millimetres unless otherwise stated
- This drawing is to be read with all other relevant documentation
- Do not scale from this drawing, all measurement data should be taken directly from the model

Key to Drawing

- Linear LED Luminaire, Emergency adjacent indicates complete with emergency conversion
- Modular LED Luminaire
- LED Wall Pack/Amenity luminaire
- Wall Mounted Floodlight
- Lighting Control Switch 1 way
- Lighting Control Switch 2 way
- Lighting control switch switchdim
- Lighting Control Demand Switch
- Lighting control Demand/Manual dimming switch
- Lighting Control Scene setting plate
- Key Switch for emergency exit signs
- Number adjacent to switch indicates number of gangs
- Lighting Control combined movement sensor and photo-cell (non Dimmable)
- Lighting Control combined movement sensor and photo-cell (Dimmable)
- Lighting Control photo-cell
- Lighting Control Corner mounted movement sensor
- Lighting Control marshalling box

Notes

All new basement fittings to have presence sensor operation.

Ground floor fittings to be switched maintained.

MANCHESTER CITY COUNCIL

Capital Programmes Division

Manchester City Council
PO Box 532, Town Hall
Manchester M60 2LA

DRAWING STATUS

Information

PROPERTY TITLE
Victoria Baths
Hathersage Road
Manchester M13 0FE

UPRN 010090237549 OFE NO 0000

PROJECT TITLE
Replacement Issues (Lighting and Building) from FRA

DRAWING TITLE
Ground floor plan - Electrical Works

JOB NO. CL45356 DATE 29.08.24 REV
SCALE 1:100@A0 AUTHOR TB CHECKED BY APPROVED BY
DRAWING NO. VBC-MCC-B01-GF-DR-E-0011