




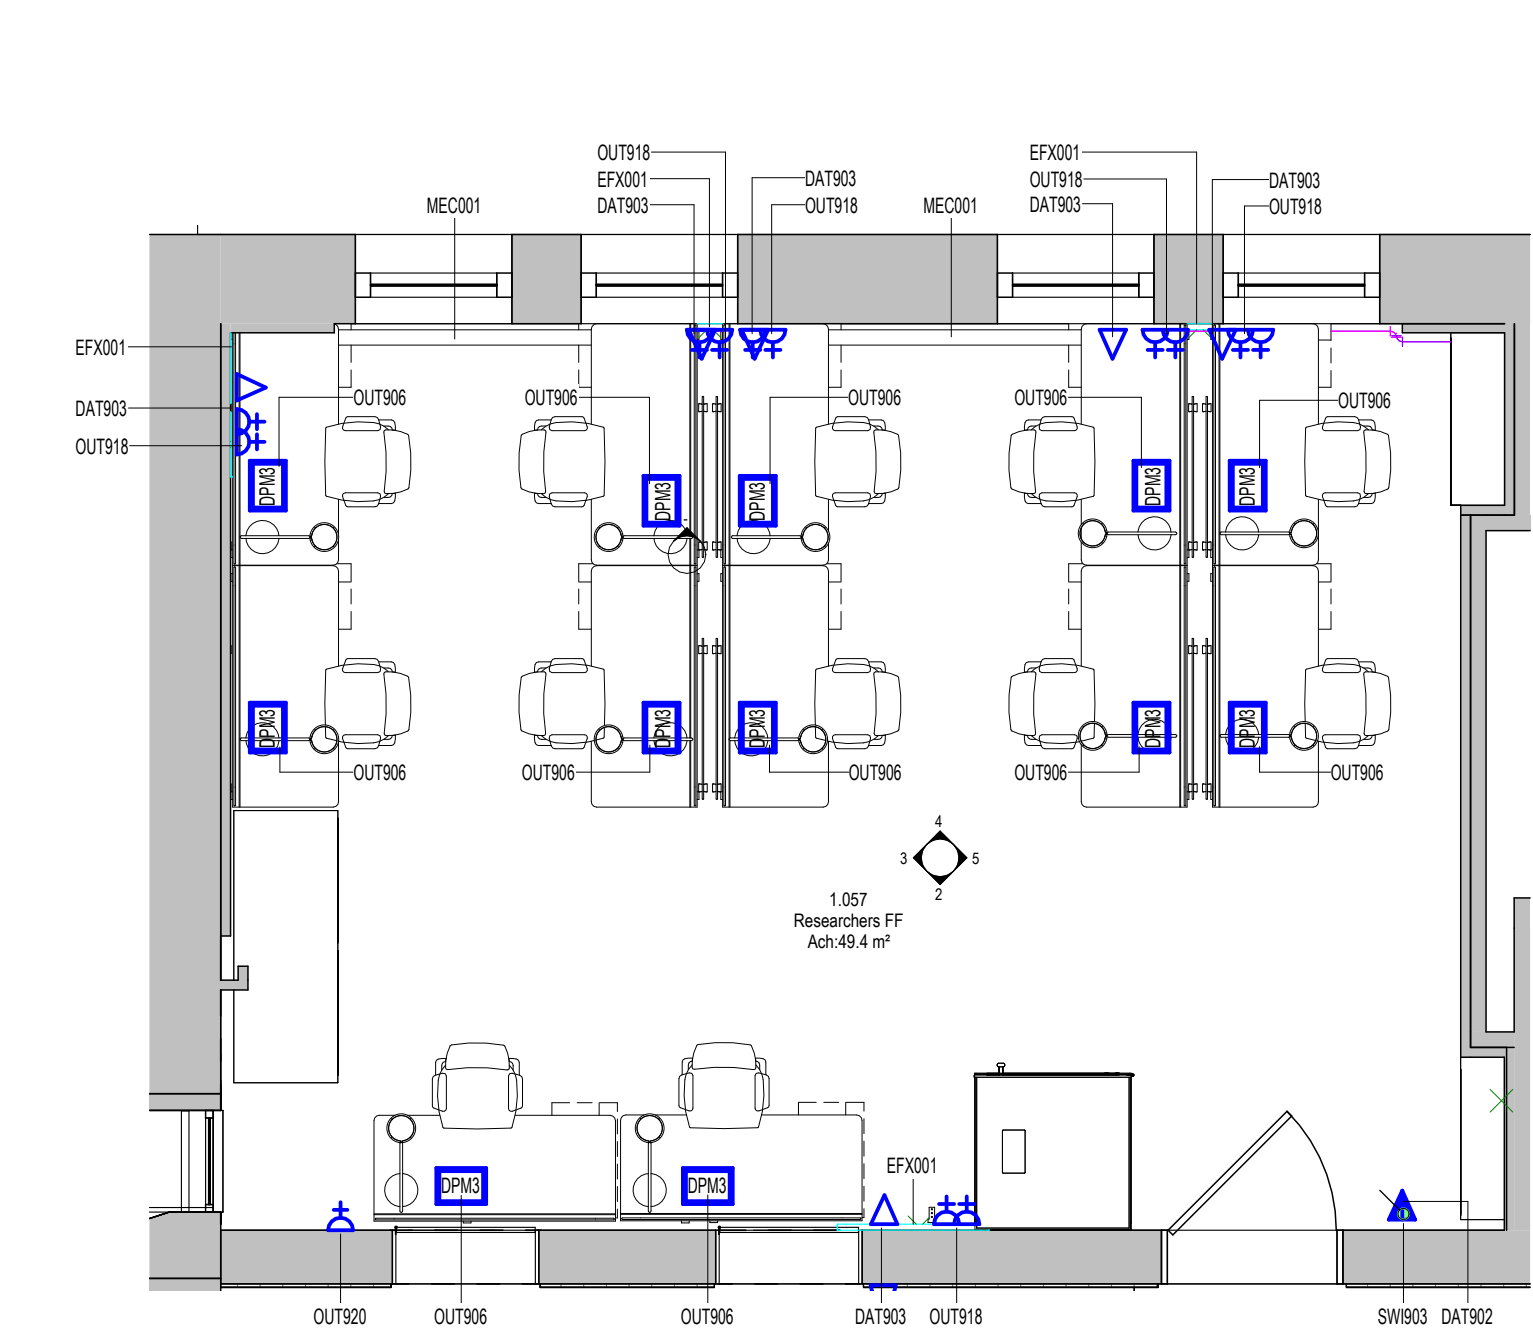


1 1.057 Researchers FF Floor Plan
1 : 50

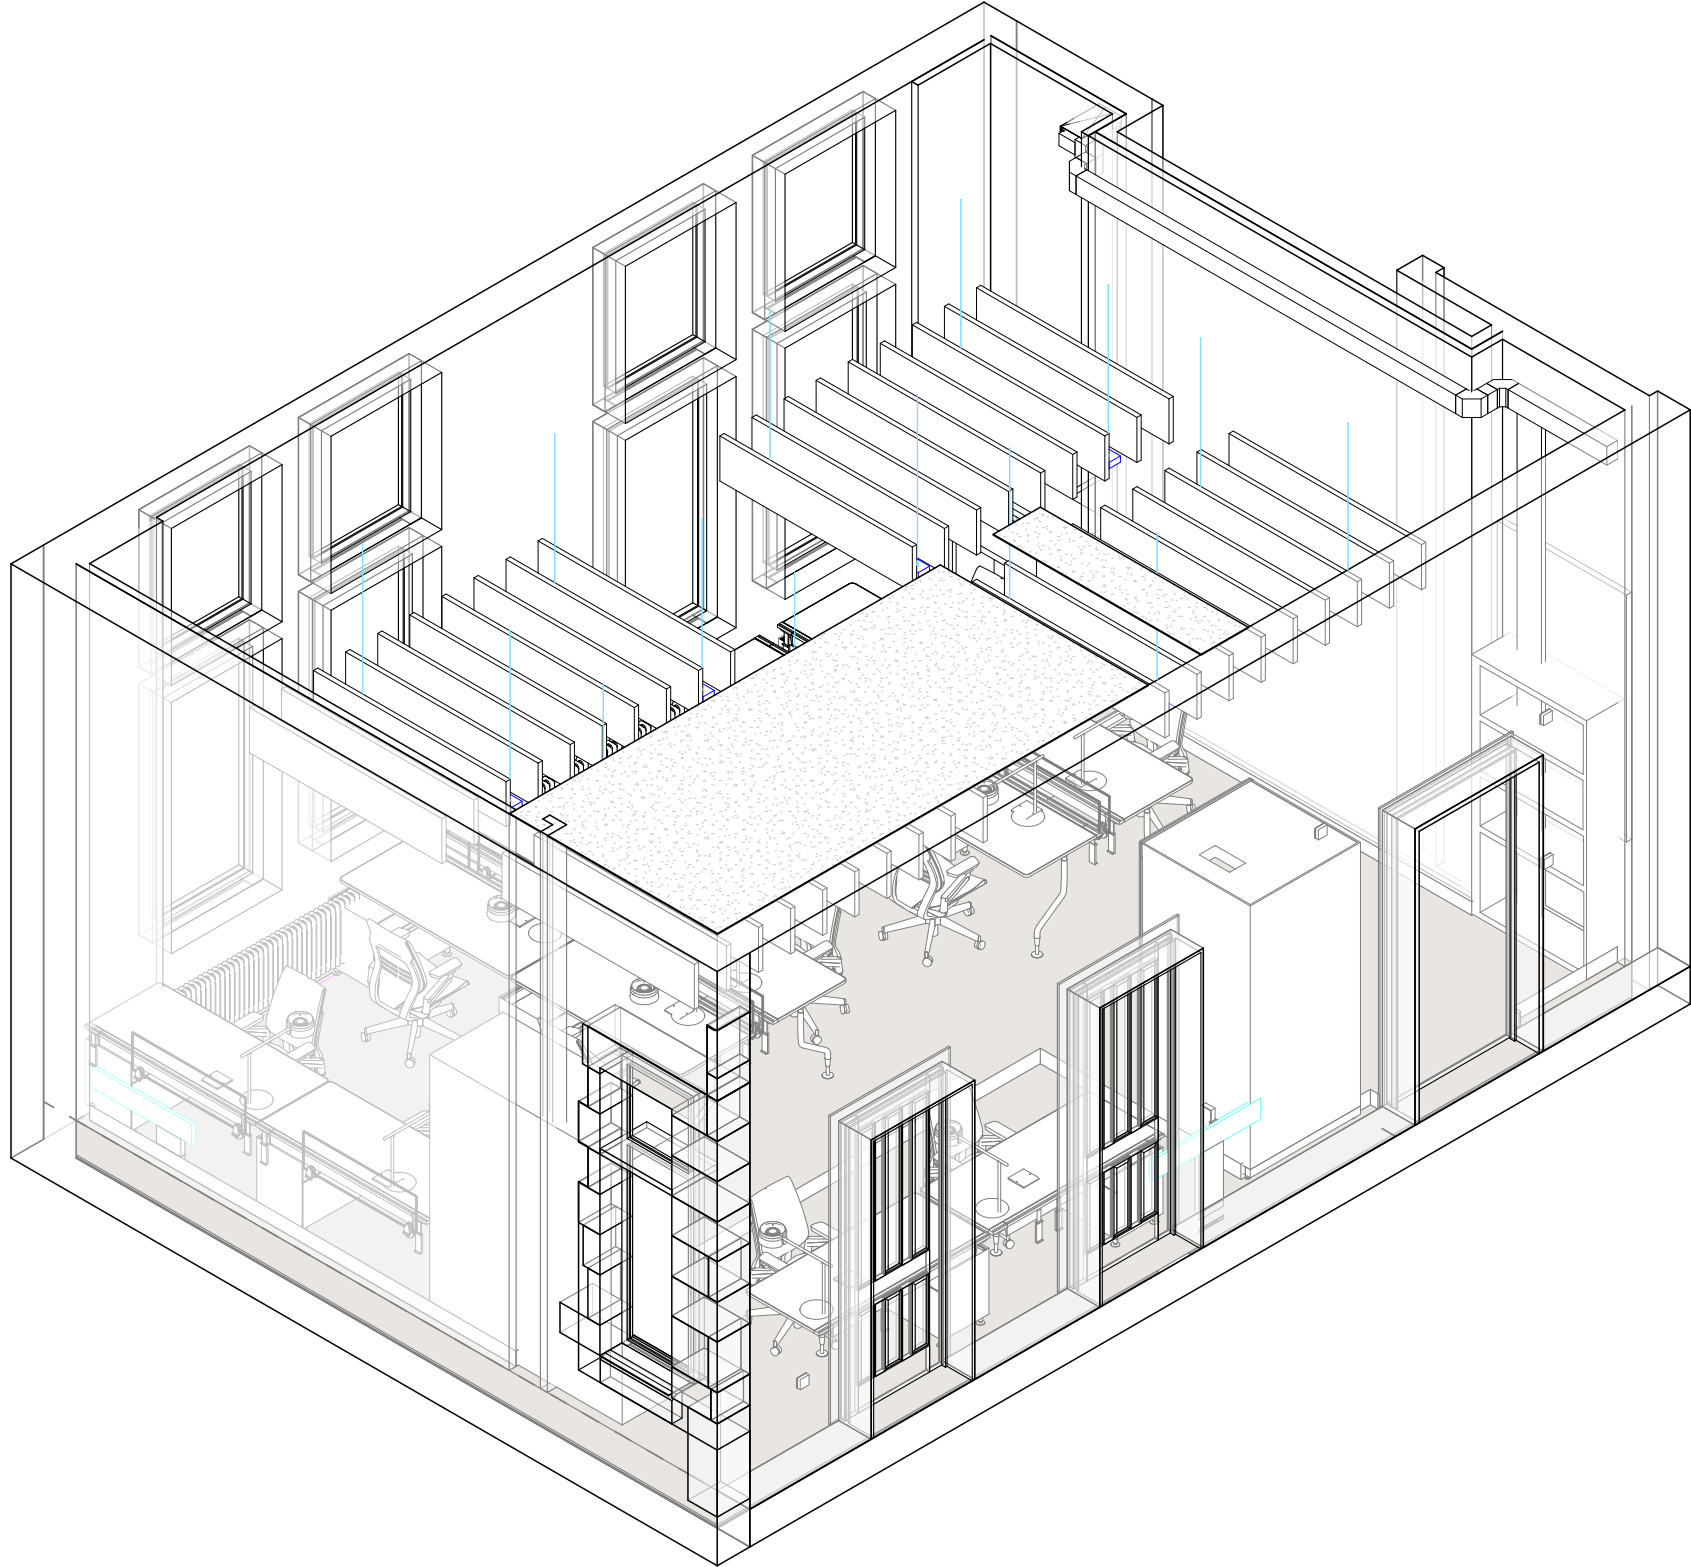


6 1.057 Researchers FF Isometric View

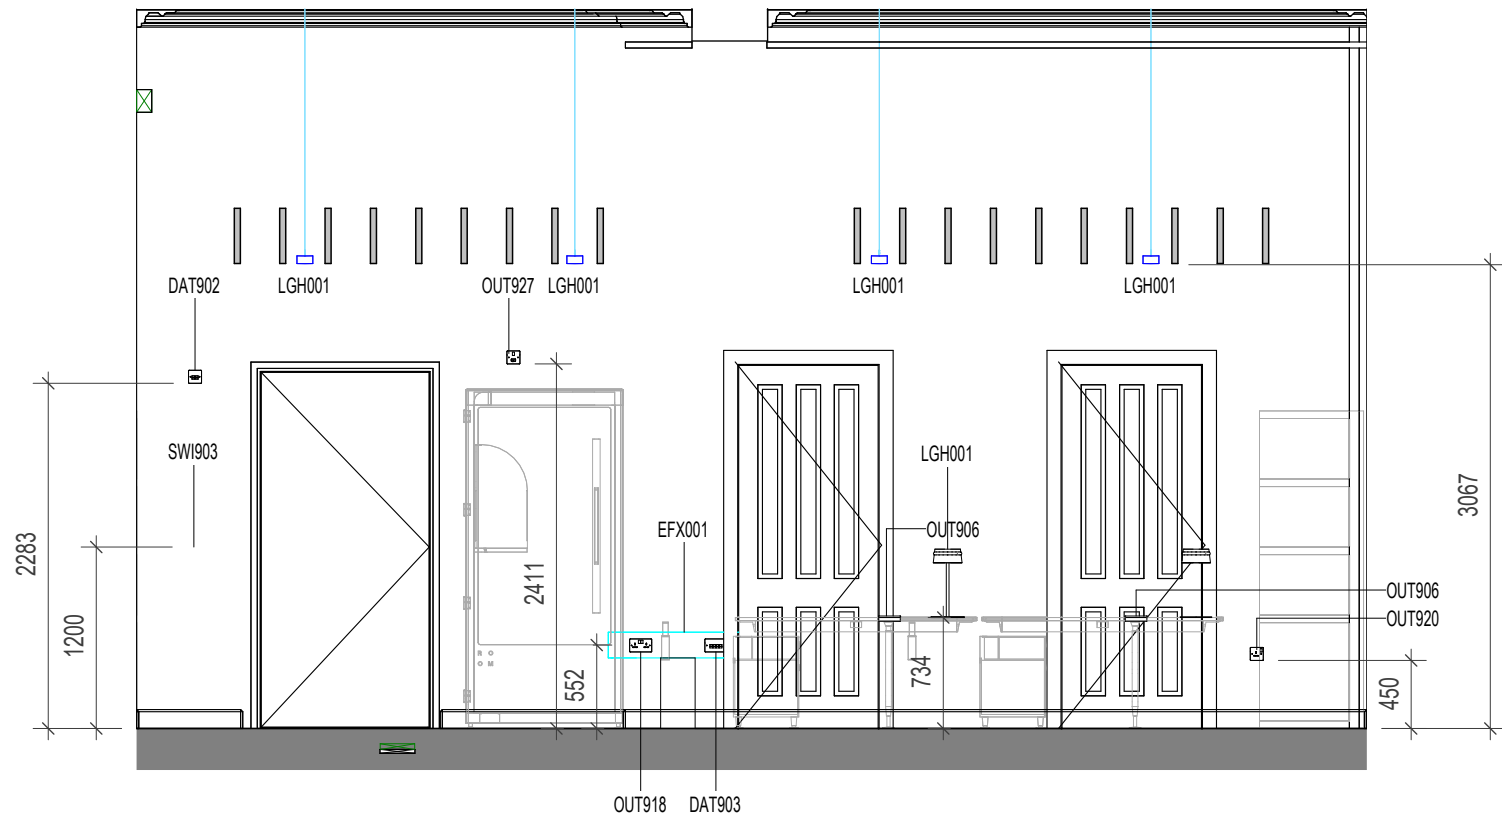


2 ELEVATION 2
1 : 50

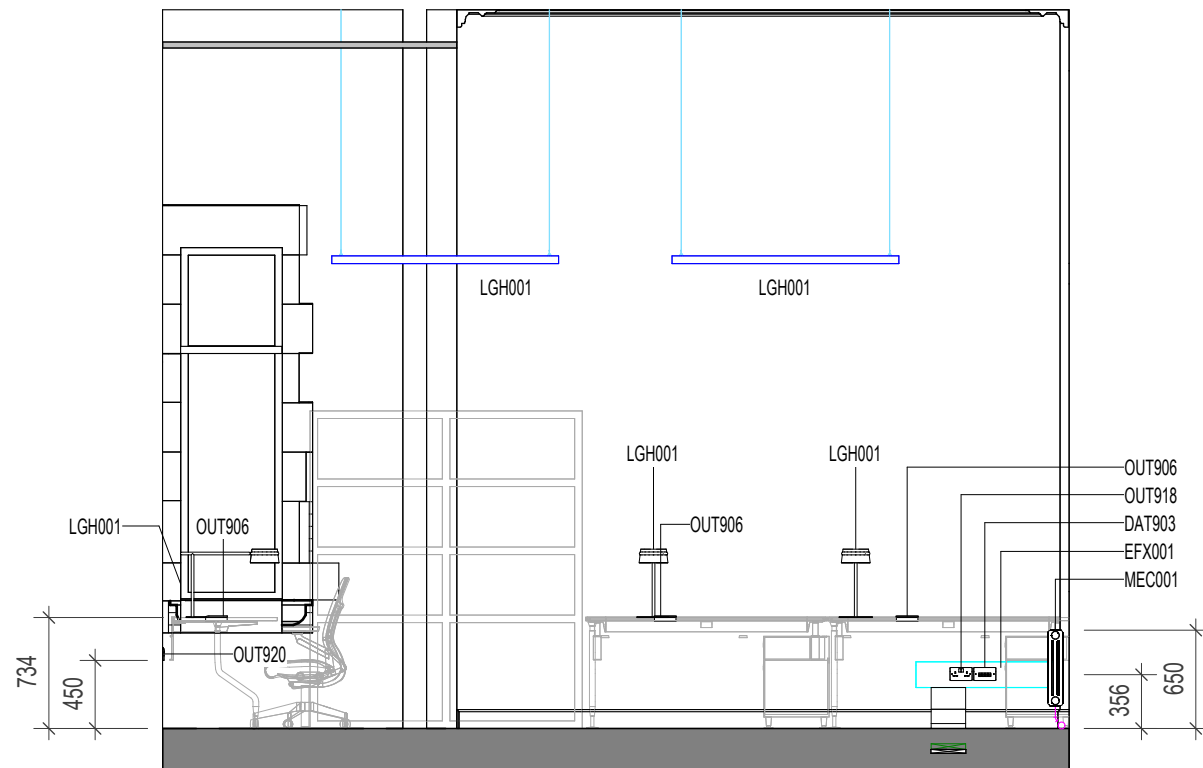

3 ELEVATION 3
1 : 50

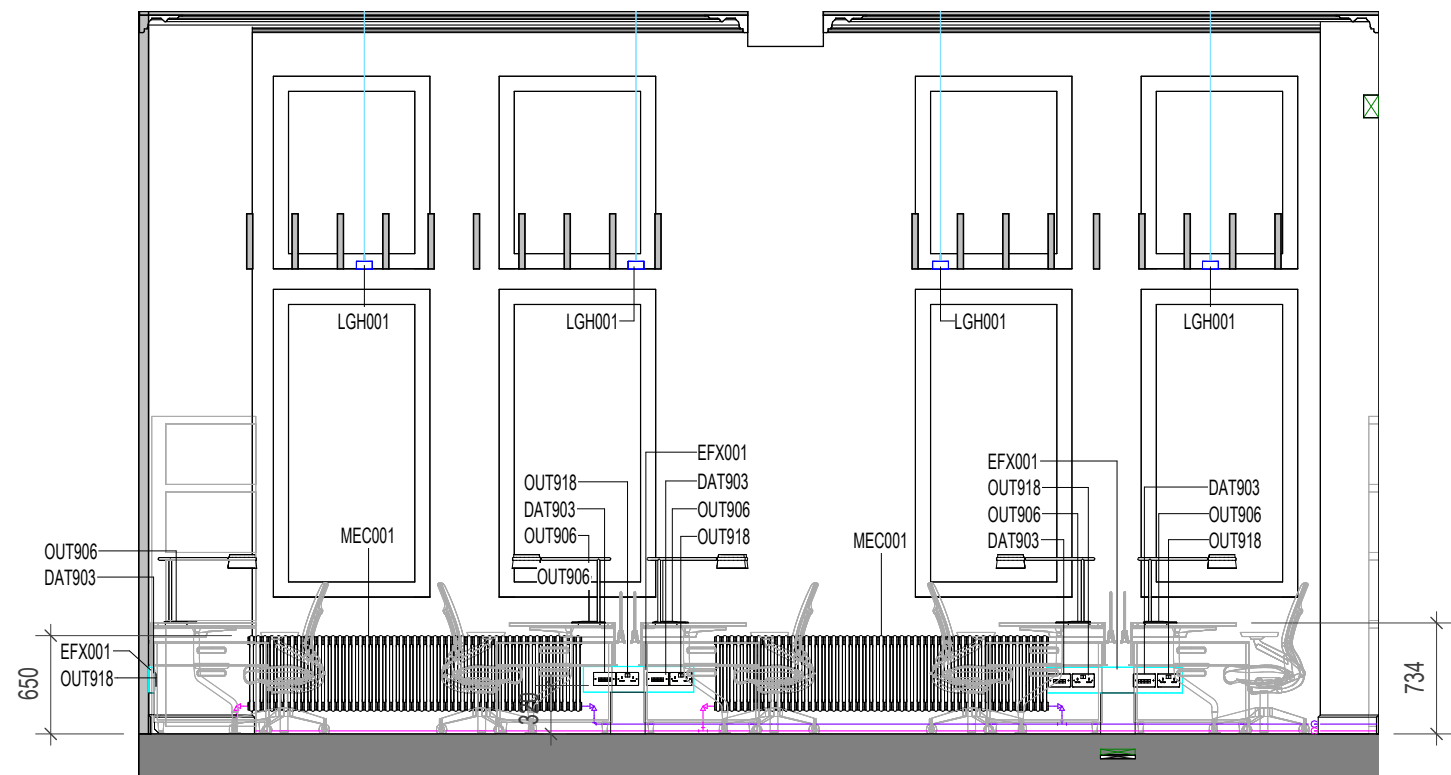

4 ELEVATION 4
1 : 50

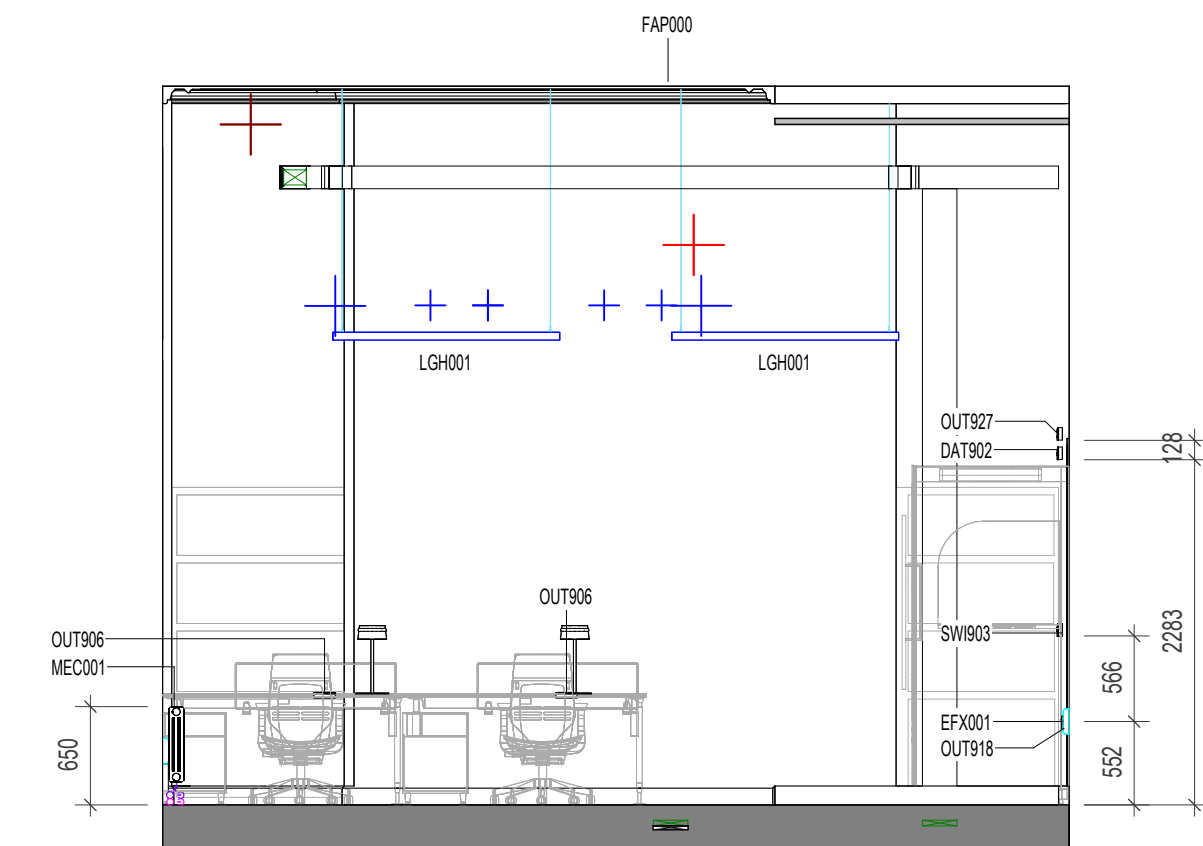

5 ELEVATION 5
1 : 50

Space Number	Space Name	ADBCode	ADBDescription	ADBGroup
1.057	Researchers FF	DAT902	Double Gang RJ45 Outlet	1
1.057	Researchers FF	DAT903	Four Gang RJ45 Outlet	1
1.057	Researchers FF	EFX001	Electrical Fixture	1
1.057	Researchers FF	LGH001	Lighting Fixture	1
1.057	Researchers FF	MEC001	Mechanical Equipment	1
1.057	Researchers FF	OUT906	Automatic Changeover Switch	1
1.057	Researchers FF	OUT918	Double Switched Socket Outlet - Plastic	1
1.057	Researchers FF	OUT920	Single Switched Socket Outlet - Plastic	1
1.057	Researchers FF	OUT927	Switched Fused Connection Unit - Plastic	1
1.057	Researchers FF	SW903	Plastic Retractive Light Switch	1

Notes:

- This drawing is copyright.
- Do not scale dimensions from this drawing.
- This drawing is to be read in conjunction with all other relevant drawings.
- All discrepancies on this drawing are to be reported to the architect.
- Do not modify any element of this drawing.
- Use drawing only for purpose(s) issued.
- This drawing may contain colour.

North Point

Key Plan

The following external model files are included within this drawing:

P3	2024/12/13	C-sheets issued to MCC	AB	RM
P2	2024/07/26	C-sheets issued to MCC	AB	RM
P1	2024/07/12	Screen on ground floor should be Fire Rated	AB	RM
Rev	Date	Revision Notes	Drawn	Review

MANCHESTER
1824
The University of Manchester

ARCADIS

Project
Rutherford Building

Drawing Title
1.057 - Researchers FF

Job Number 141532	Date	Security Classification	Drawn By AJ
Scale@A1 1 : 50	Purpose LISTED BUILDING CONSENT	Reviewed By AB	
Drawing Number 4910-RBUM-ARC-XX-ZZ-DR-A-4910			Revision P3