




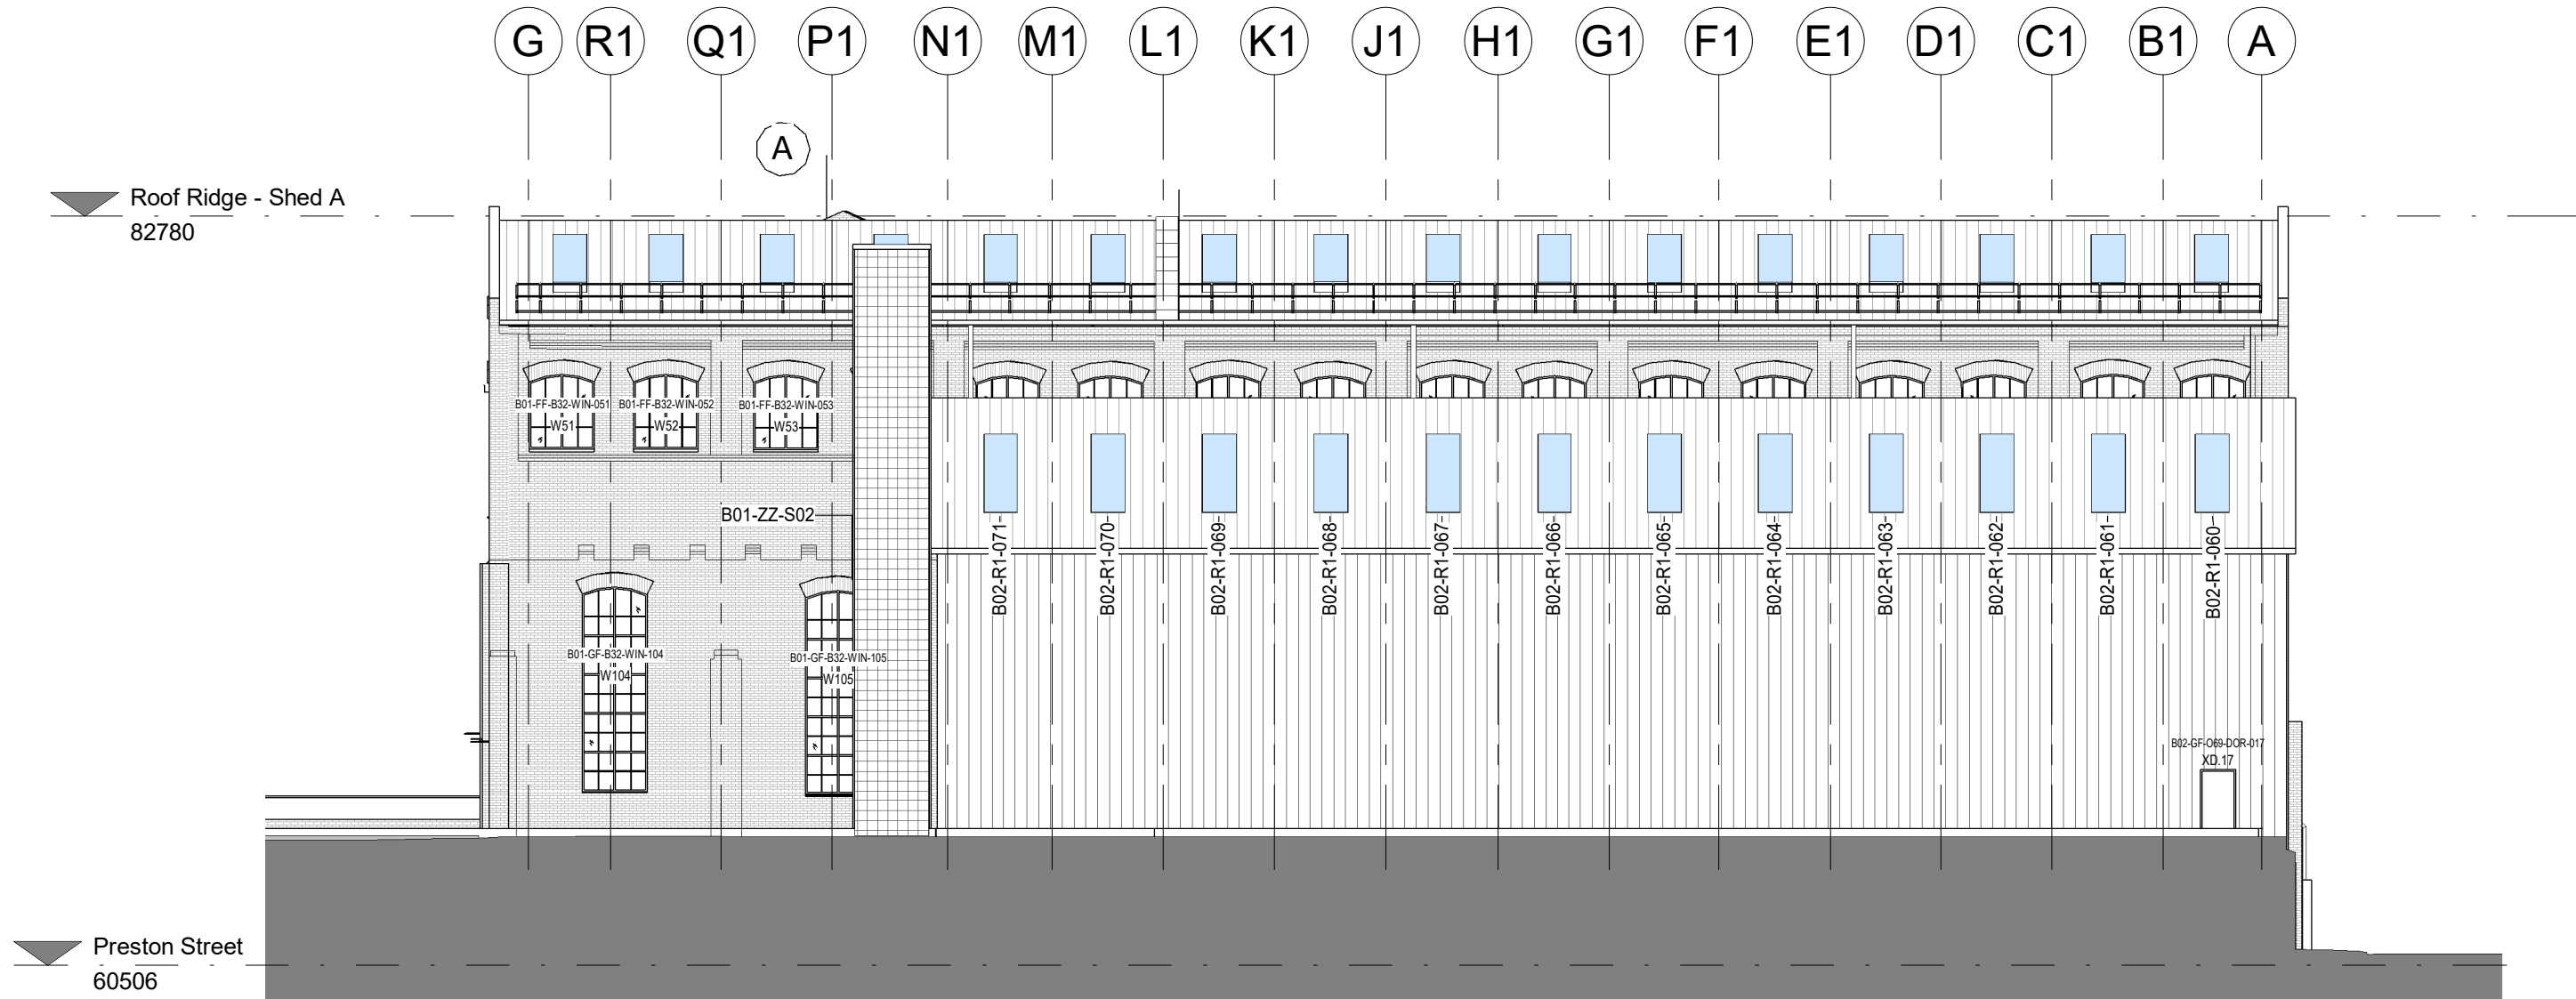


Lightning Protection North Elevation 1
Scale: 1:200

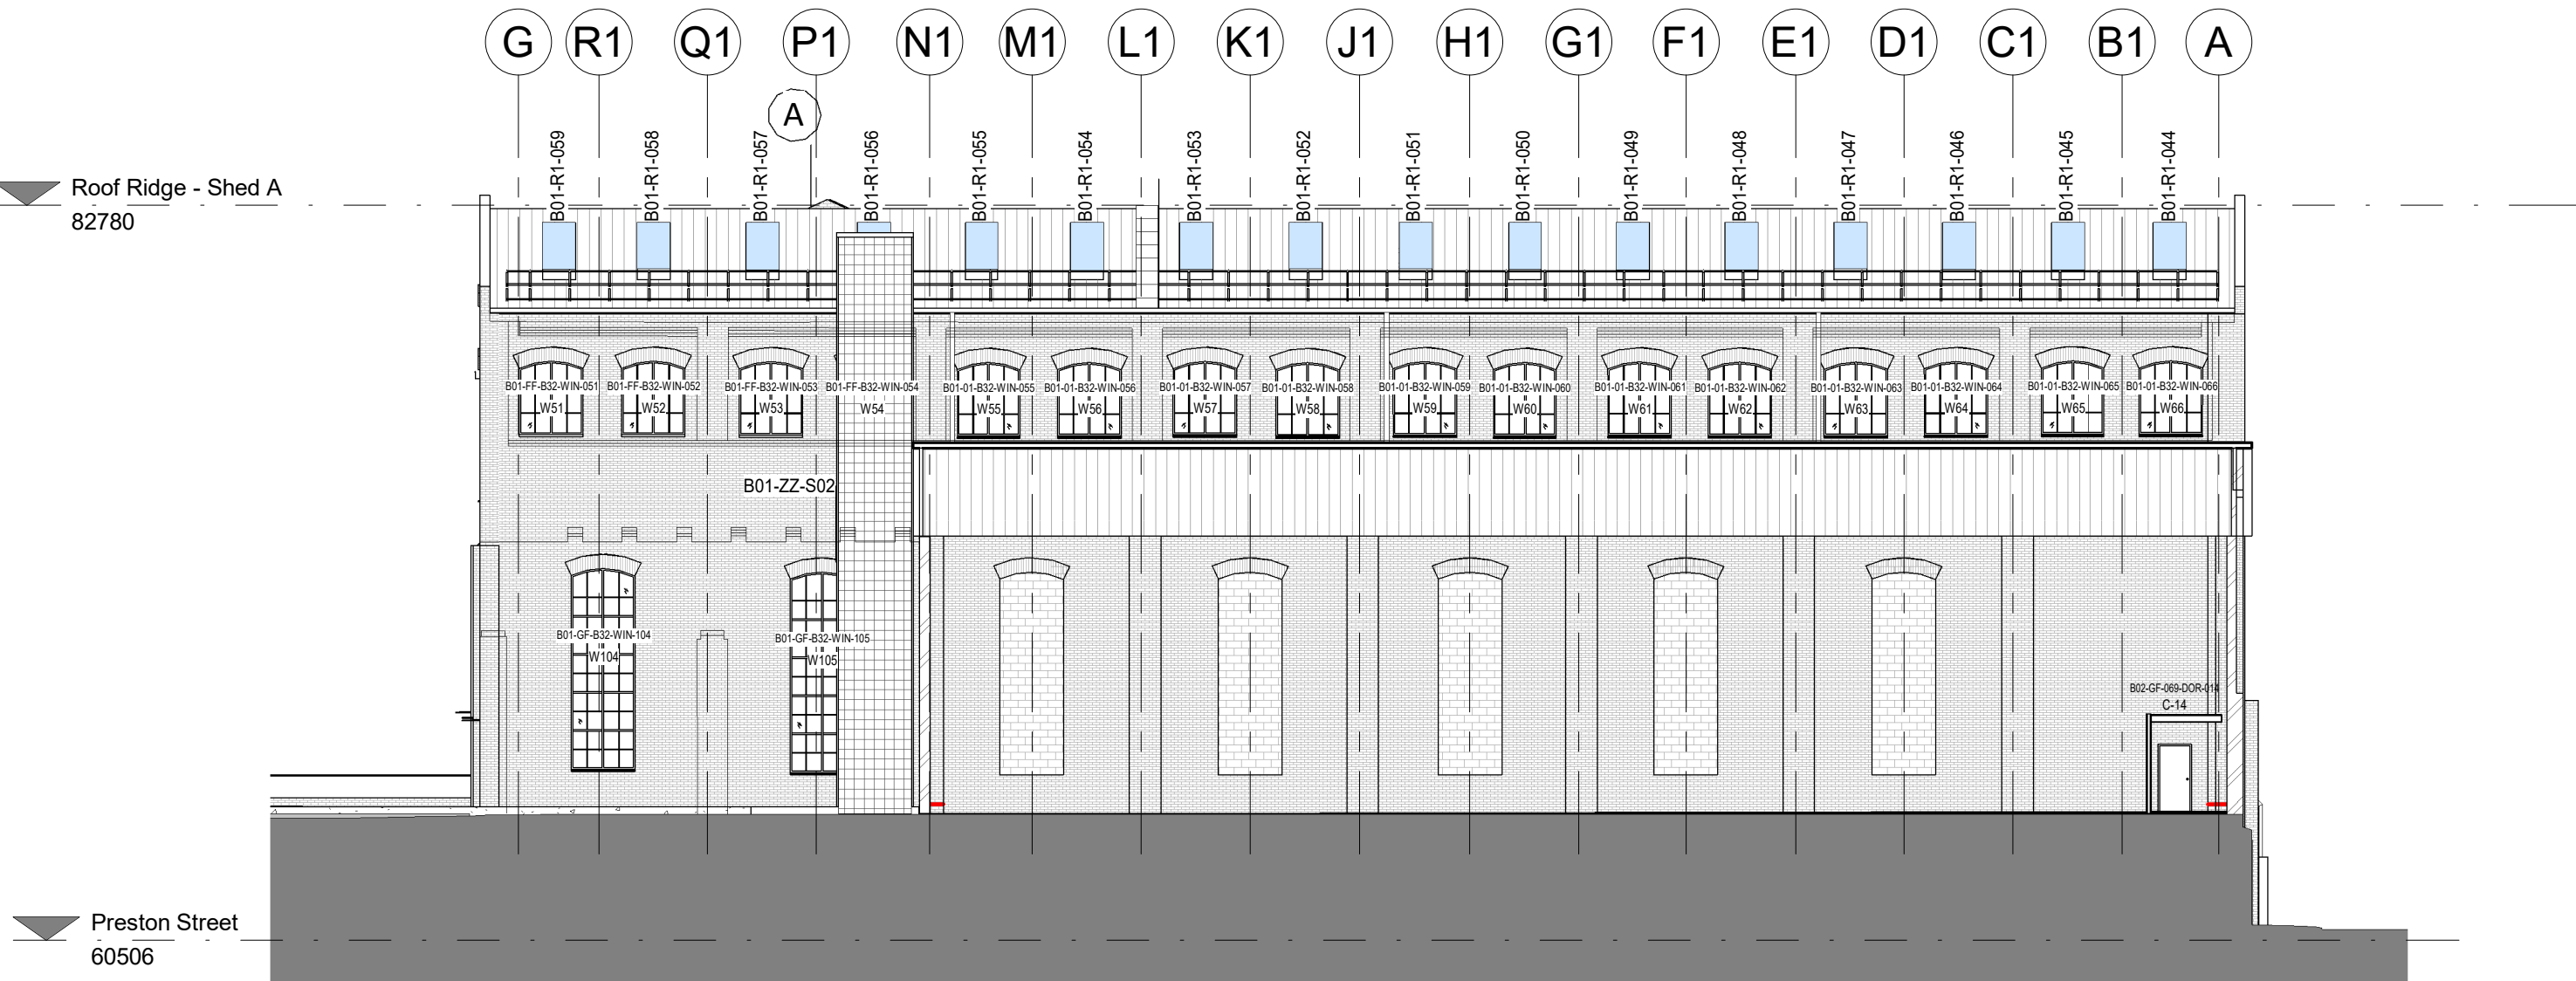

Lightning Protection North Elevation 2
Scale: 1:200

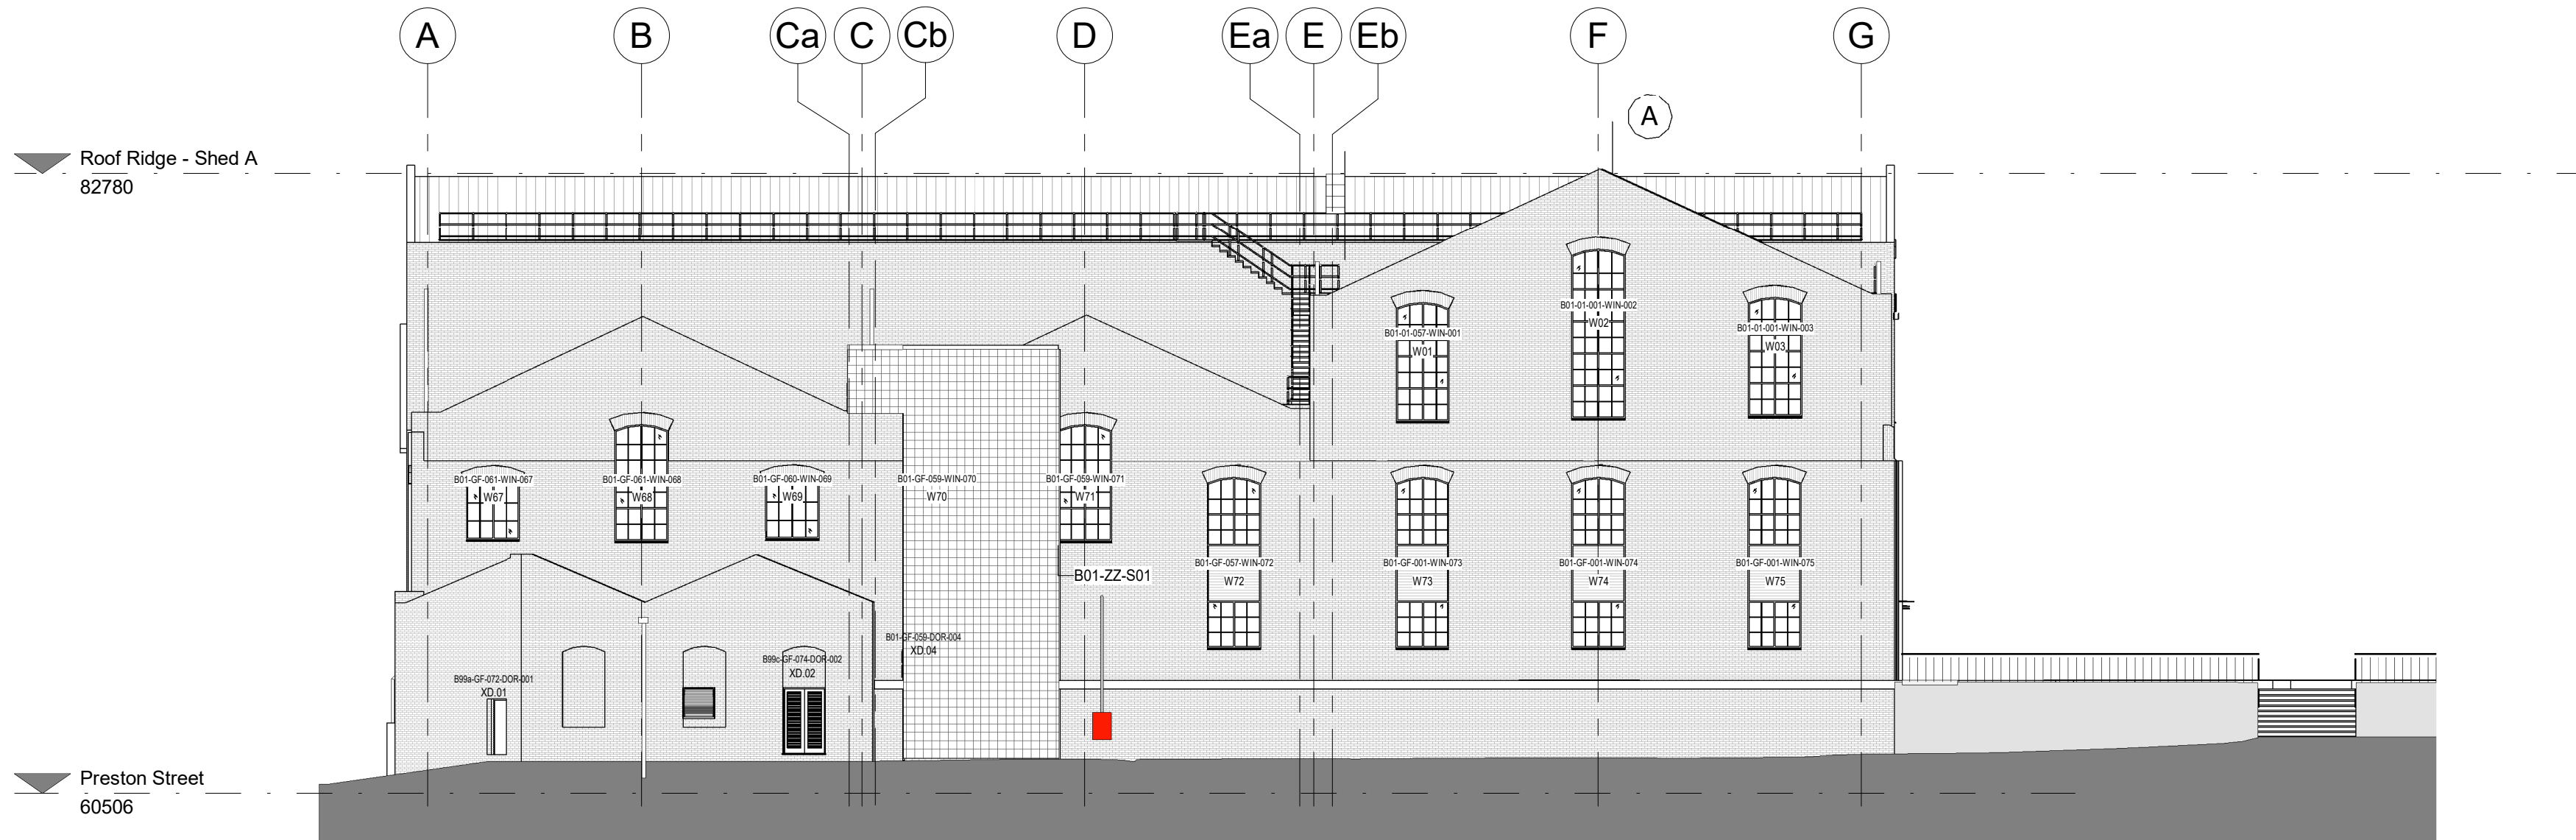

 Lightning Protection South Elevation
Scale: 1:200




General Notes

Do not scale from this drawing. Only work to written dimensions.

All site dimensions shall be verified by the Contractor on site prior to commencing any works.

This drawing is the property of Fletcher-Rae (UK) Limited (t/a Fletcher-Rae) and copyright is reserved by them. The drawing is not to be copied or disclosed by or to any unauthorised persons without the prior written consent of Fletcher-Rae (UK) Limited.

**MORGAN
SINDALL**

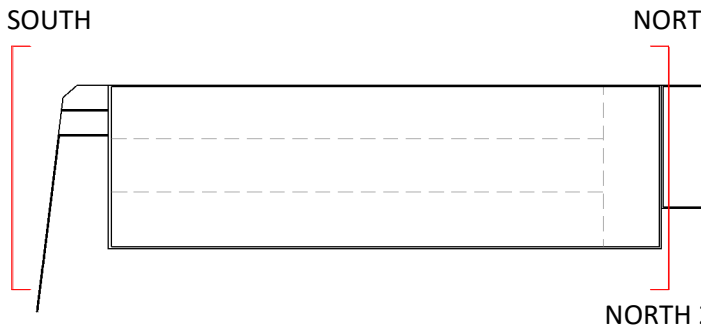

KEY PLAN

Legend:

(A) 2m High Stainless Steel Air Termination Rod

Rev.	First Issue	Description	Date	AT	ISS	APP
------	-------------	-------------	------	----	-----	-----

Scale: As indicated @ A1
Status: PD - Published Document (Construction)
Drawn By: AT
Checked By: TA
Date: 10.12.2024

Client: Morgan Sindall

Project: 18021 Hammerstone Road
Manchester

Sheet Name: North & South Elevations - Lightning Protection

Project No. Orig. Zone Level Type Role CIs Dwg No. Rev
HRD-FRA-01-EL-DR-A-20-1217 C01

fletcher|rae
Architects | Master Planners | Designers
Level 12, Tower 12, 18-22 Bridge Street, Manchester, M3 3BZ

t +44 (0) 161 242 1140
f +44 (0) 161 242 1141
w www.fletcher-rae.com
e info@fletcher-rae.com