


LEGEND:	
	BASKET
	LADDER
	TRAY
	TRUNKING
	DATA/COMMS
	ELV/FA
	SUBMAIN
	LIGHTING & POWER
	3 COMPARTMENT FOR DATA/ELV / L&P & FA
	FA
	3-COMPARTMENT 228 x 38mm FITTED FLOOR TRUNKING (FF)
	UNDERFLOOR TRUNKING JUNCTION BOX DIMENSION - 310mmL x 310mmW x 65mmD
	FLOOR BOX DIMENSIONS - 333mmL x 310mmW x 65mmD

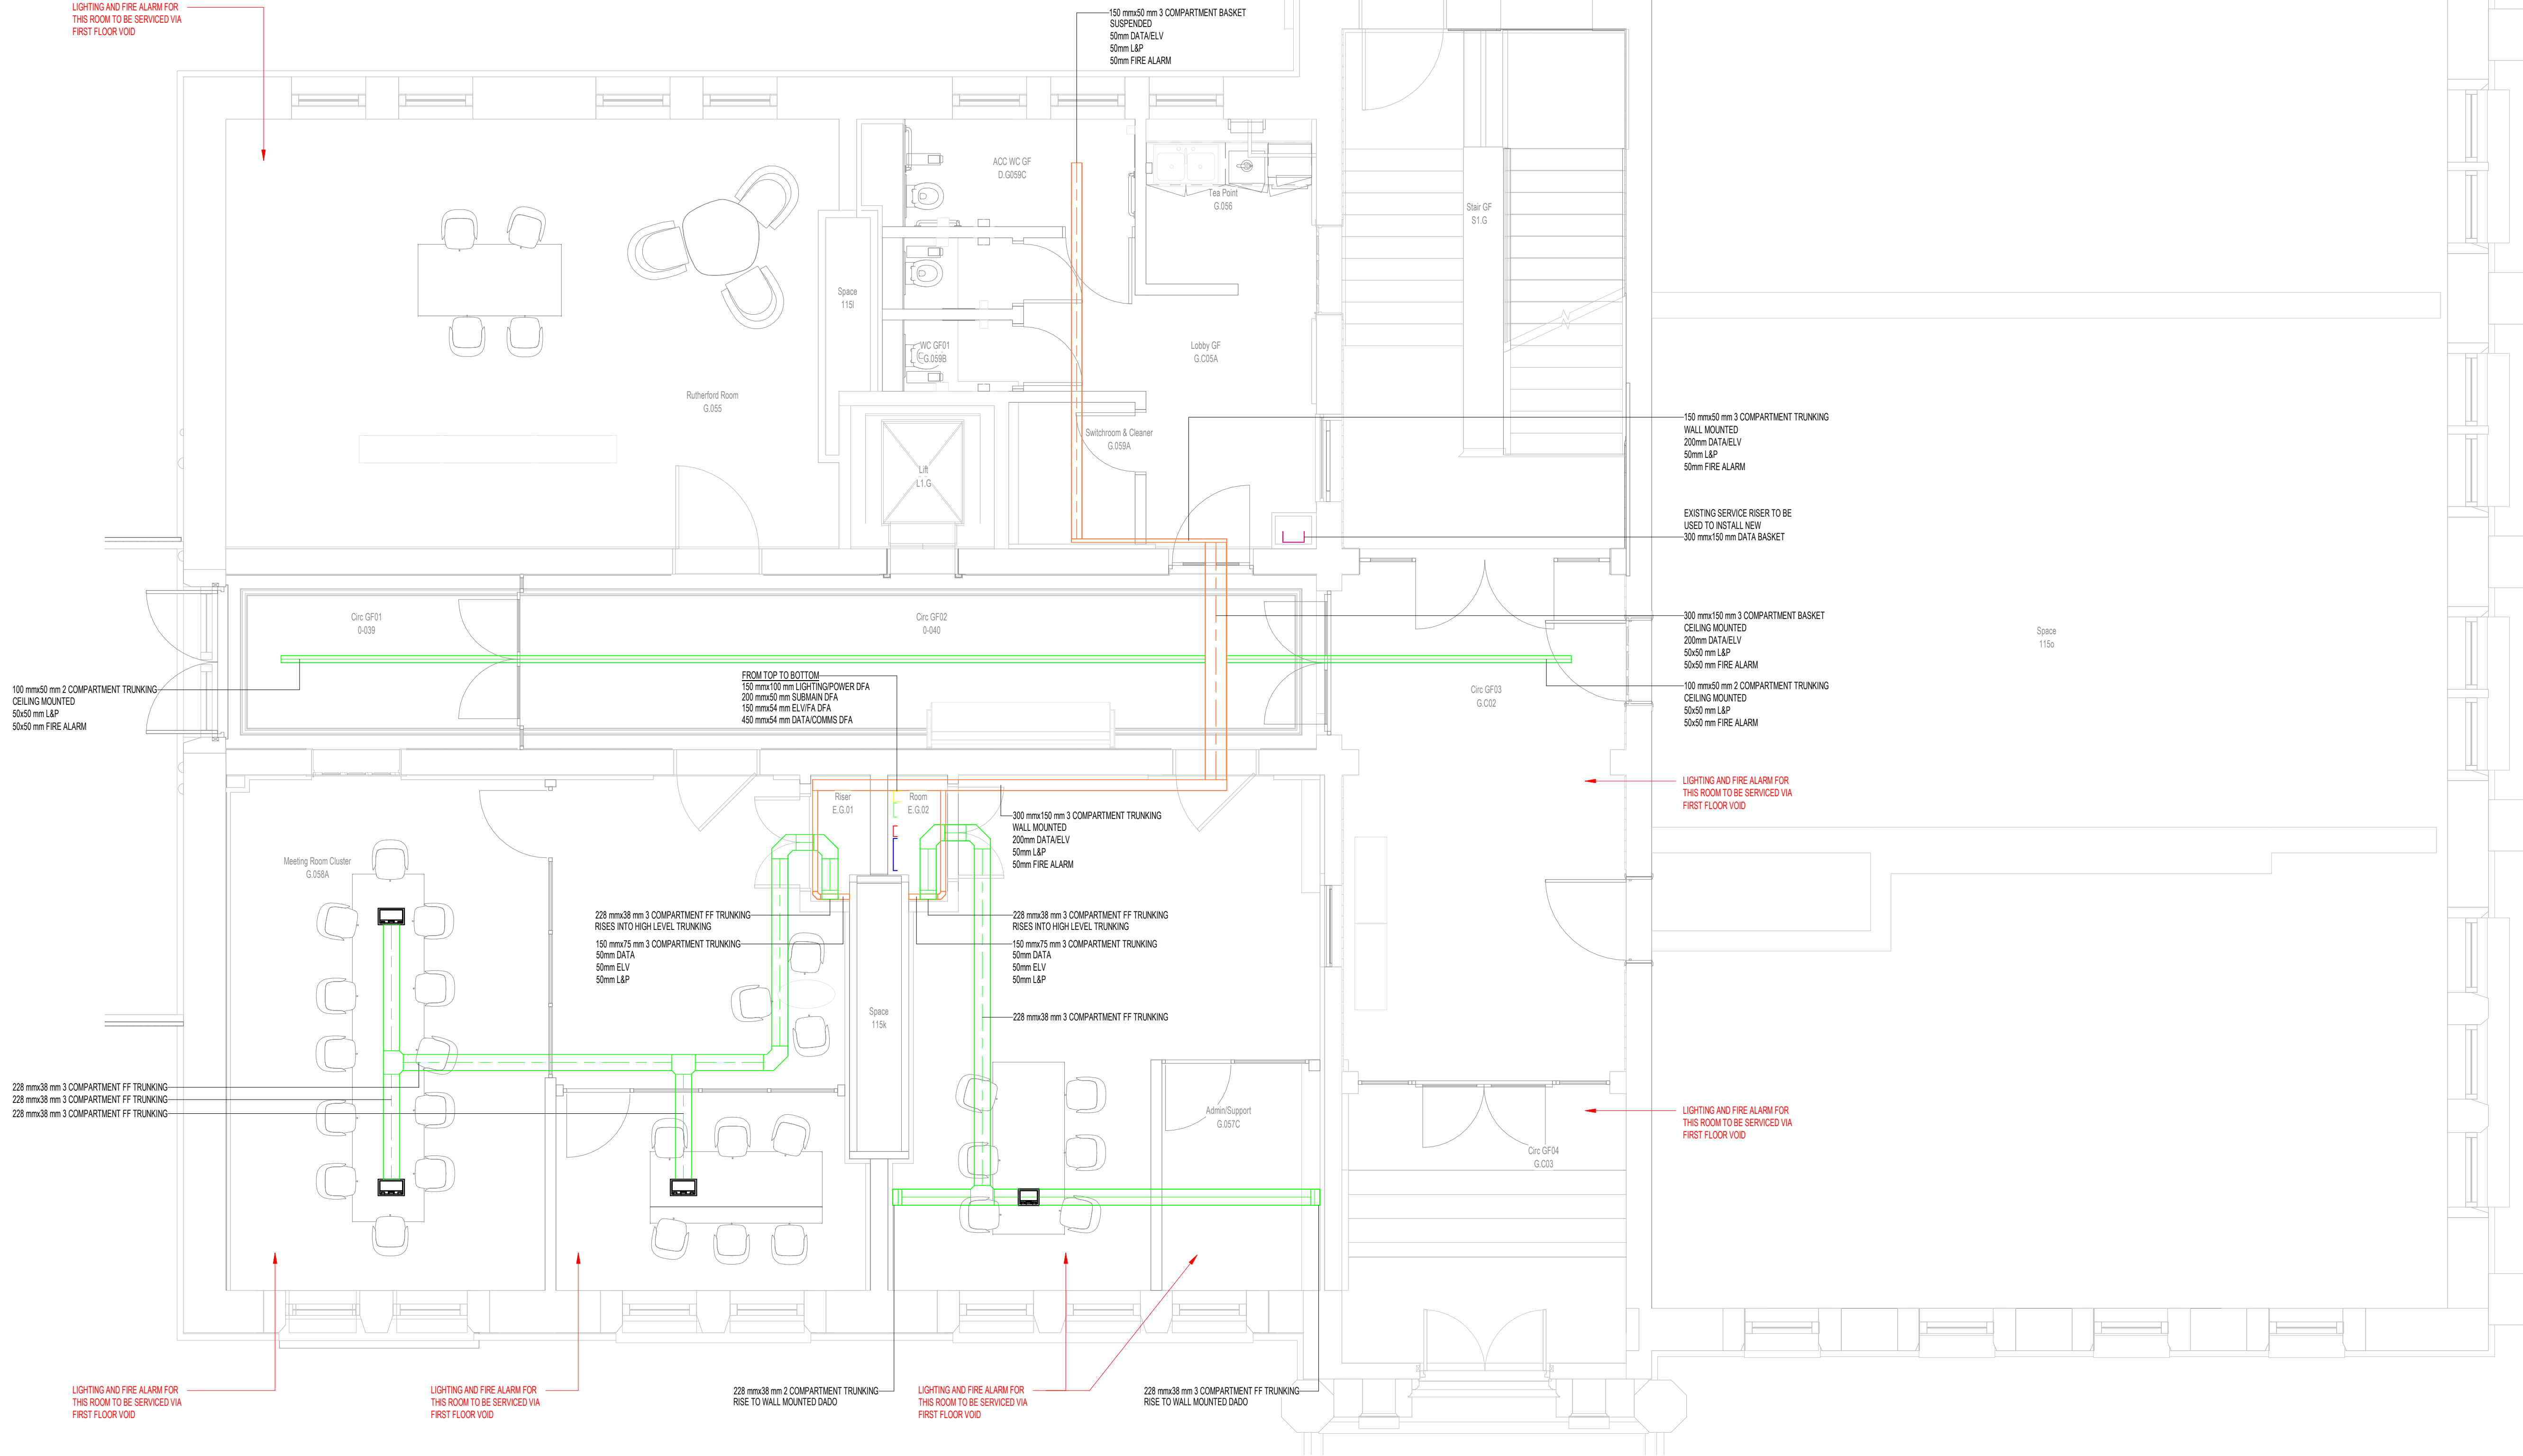

1

00 - Containment Design
1 : 50

NOTES:
THIS IS A DESIGN DRAWING NOT AN INSTALLATION DRAWING.
DIMENSIONS SHOULD NOT BE SCALED.
SITE DIMENSIONS TO BE CHECKED BEFORE PRODUCTION OF CRITICAL MANUFACTURING DRAWINGS.
THE DRAWING IS COPYRIGHT AND NO PART MAY BE REPRODUCED WITHOUT WRITTEN CONSENT.

CONTAINMENT

1.

THIS DRAWING SHALL BE READ IN CONJUNCTION WITH THE RELEVANT MECHANICAL AND ELECTRICAL SERVICES PERFORMANCE SPECIFICATION, DISTRIBUTION BOARD SCHEDULES AND ASSOCIATED LAYOUT DRAWINGS.

2.

A COMPLETE AND COMPREHENSIVE CABLE CONTAINMENT SYSTEM SHALL BE PROVIDED TO ACCOMMODATE AND SUPPORT ALL SUB MAIN CABLING THROUGHOUT THEIR LENGTH FROM THE MAIN SECTION BOARD WITHIN THE PLANT ROOM

3.

SUITABLE FIRE BARRIERS TO ALL PENETRATIONS THROUGH THE FIRE COMPARTMENTS AND BARRIERS. REFERENCE SHOULD BE MADE TO THE FIRE STRATEGY DRAWING TO ASCERTAIN BARRIER/COMPARTMENT CONSTRUCTION AND RATING

4.

CONTAINMENT SHALL CARRY CABLES OF ONLY ONE VOLTAGE BAND WHERE ALL SUCH CABLES MUST BE INSULATED TO LV GRADES. ELV BASKET MAY CONVEY SECURITY FIRE ALARM AND EMERGENCY LIGHTING WHERE THE WIRING SYSTEMS ARE ALL ELV WITH VGRADE INSULATION AND THEY ARE CORRECTLY SCREENED/SEGREGATED. THE CONTRACTOR SHALL CONFIRM THAT ALL CABLES LISTED AND PROVIDED WITH LV GRADE INSULATION

5.

UNDER NO CIRCUMSTANCES MAY FIRE ALARM/EMERGENCY LIGHTING CABLES BE ROUTED ON LV CONVEYANCE SYSTEMS.

6.

THE CONTRACTOR MUST OBSERVE THE MINIMUM SEPARATION BETWEEN DISSIMILAR VOLTAGE BAND CONVEYANCE SYSTEMS.

7.

ALL ELV CABLES MUST BE TERMINATED IN ACCORDANCE WITH THEIR INTENDED TERMINATING IMPEDANCE. ALL CABLES SHALL BE TERMINATED CORRECTLY BY TESTING AND CERTIFICATION.

8.

THE CONTRACTOR SHALL PROVIDE SMALL TRUNKING LID SECTIONS FOR PENETRATIONS THROUGH FIRE BARRIERS SUCH THAT REMOVAL OF LID DOES NOT AFFECT FIRE SEAL AROUND TRUNKING. THE CONTRACTOR SHALL PROVIDE A DURABLE LABEL TO TRUNKING LID WHERE FIRE BARRIERS ARE WITHIN TRUNKING.

9.

MULTI-COMPARTMENT CABLE TRUNKING SYSTEMS TO BE ROUTED AT HIGH LEVEL AS EXISTING WITHIN CORRIDORS

10.

ALL SERVICES IN CORRIDORS TO BE BACK ENTRY FED VIA SURFACE INSTALLED CONDUITS

11.

FINAL DATA CONTAINMENT SIZING AND ROUTING TO BE CONFIRMED WHEN DATA OUTLET STRATEGY HAS BEEN FINALISED

Rev
C02

STAGE 4 ISSUE - MCC COMMENTS INCORPORATED

By: JD Chkd: DH Date: 06.12.24 App: AD

Rev
C01

STAGE 4 CONTRACT ISSUE

By: JN Chkd: DH Date: 16.08.24 App: AD

Status
A4

Description
STAGE 4A COMPLETED

Stage
4

Client

Project

UNIVERSITY OF MANCHESTER RUTHERFORD BUILDING

Drawing

ELECTRICAL SERVICES
CONTAINMENT
GROUND FLOOR
GENERAL ARRANGEMENT LAYOUT

NEWCASTLE ■ TEESSIDE ■ YORKSHIRE ■ NORTH WEST

Drawing Number
UOMRB-CAD-XX-00-DR-E-67000

Revision
C02

Scale
As indicated

Size
A1

Drawing Origins :
RBUM-IBI-XX-XX-M3-A-000002 Rev 241108