
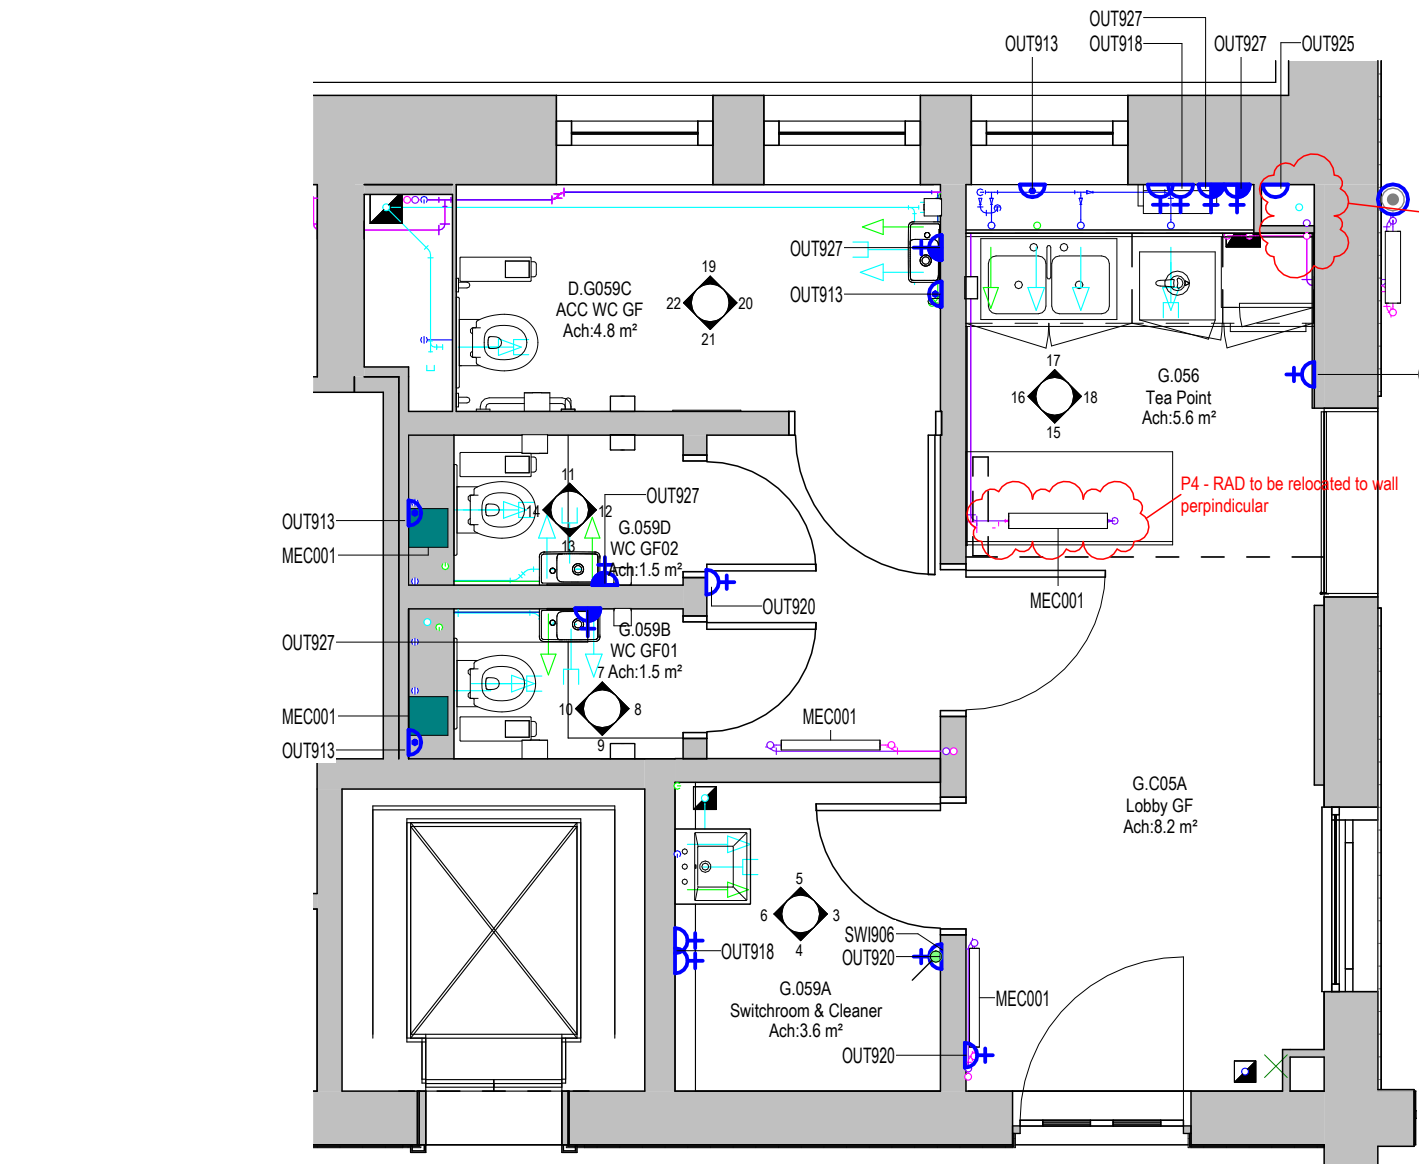


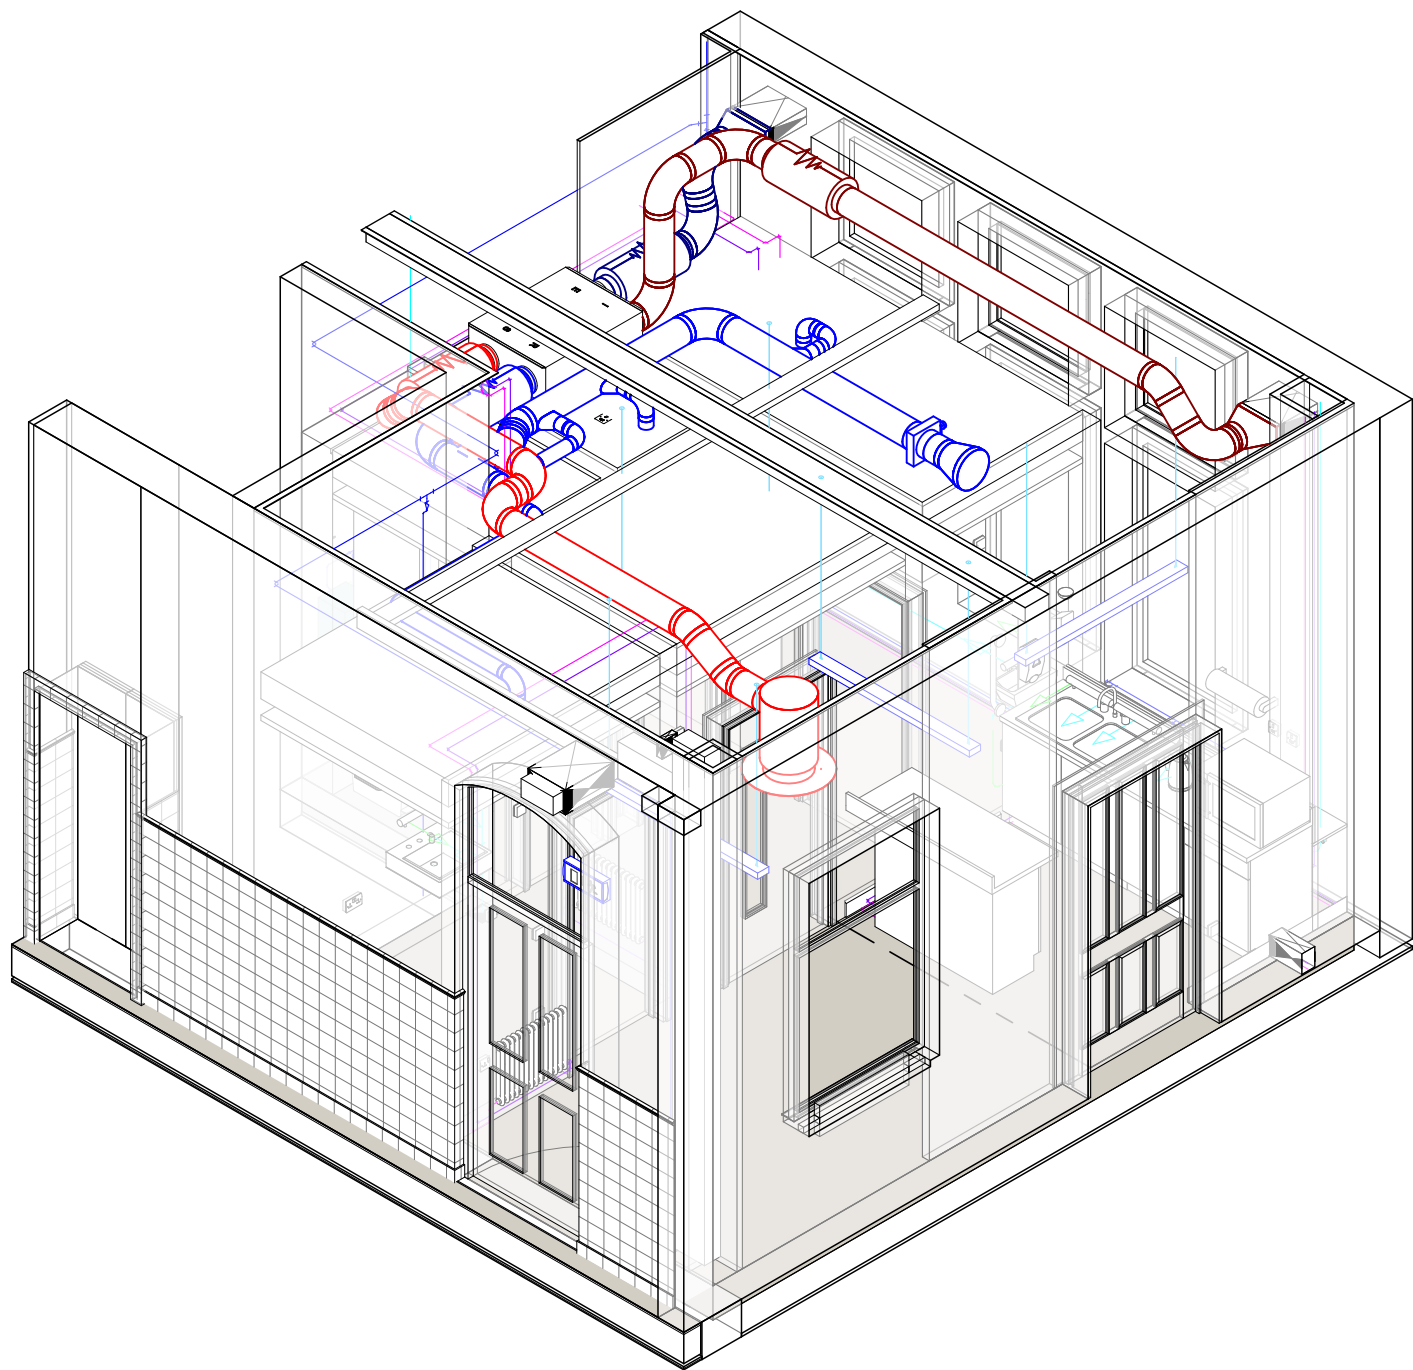

Space Number	Space Name	ADBCode	ADBDescription	ADBGroup
G.056	Tea Point	FAP000	Multi Detector (FA)	1
G.056	Tea Point	LGH001	Lighting Fixture	1
G.056	Tea Point	MEC001	Mechanical Equipment	1
G.056	Tea Point	OUT913	Single Flex Outlet Plate - Plastic	1
G.056	Tea Point	OUT918	Double Switched Socket Outlet - Plastic	1
G.056	Tea Point	OUT920	Single Switched Socket Outlet - Plastic	1
G.056	Tea Point	OUT925	Single Unswitched Socket Outlet - Plastic	1
G.056	Tea Point	OUT927	Switched Fused Connection Unit - Plastic	1

Space Number	Space Name	ADBCode	ADBDescription	ADBGroup
D.G059C	ACC WC GF	ART001	Air Terminal	1
D.G059C	ACC WC GF	ART001	Overhead WC Ceiling Mounted Pull Cord	1
D.G059C	ACC WC GF	CAL902	Nurse Call Emergency Push Button and Reset Unit	1
D.G059C	ACC WC GF	CON902	Temperature Sensor/ Controller	1
D.G059C	ACC WC GF	FAP938	Fire Alarm Xenon Beacon Base	1
D.G059C	ACC WC GF	LGH001	Lighting Fixture	1
D.G059C	ACC WC GF	MEC001	Mechanical Equipment	1
D.G059C	ACC WC GF	OUT913	Single Flex Outlet Plate	1
D.G059C	ACC WC GF	OUT927	Switched Fused Connection Unit - Plastic	1
G.059A	Switchroom & Cleaner	ART001	Air Terminal	1
G.059A	Switchroom & Cleaner	FAP000	Multi Detector (FA)	1
G.059A	Switchroom & Cleaner	OUT913	Single Flex Outlet Plate	1
G.059A	Switchroom & Cleaner	OUT918	Double Switched Socket Outlet - Plastic	1
G.059A	Switchroom & Cleaner	OUT920	Single Switched Socket Outlet - Plastic	1
G.059A	Switchroom & Cleaner	OUT927	Switched Fused Connection Unit - Plastic	1
G.059A	Switchroom & Cleaner	SW906	Night Light Switch - Metal Clad	1
G.059B	WC GF01	ART001	Air Terminal	1
G.059B	WC GF01	FAP938	Fire Alarm Xenon Beacon Base	1
G.059B	WC GF01	LGH001	Lighting Fixture	1
G.059B	WC GF01	OUT913	Single Flex Outlet Plate	1
G.059B	WC GF01	OUT927	Switched Fused Connection Unit - Plastic	1
G.059D	WC GF02	ART001	Air Terminal	1
G.059D	WC GF02	LGH001	Lighting Fixture	1
G.059D	WC GF02	OUT913	Single Flex Outlet Plate	1
G.059D	WC GF02	OUT927	Switched Fused Connection Unit - Plastic	1

Notes:

- This drawing is copyright.
- Do not scale dimensions from this drawing.
- This drawing is to be read in conjunction with all other relevant drawings.
- All discrepancies on this drawing are to be reported to the architect.
- Do not modify any element of this drawing.
- Use drawing only for purpose(s) issued.
- This drawing may contain colour.

Scale Bar

Key Plan


The following external model files are included within this drawing:

1 Tea Point G.056 & WCs G.059 Floor Plan

1 : 50

2 Tea Point G.056 & WCs G.059 Isometric View

1 : 50

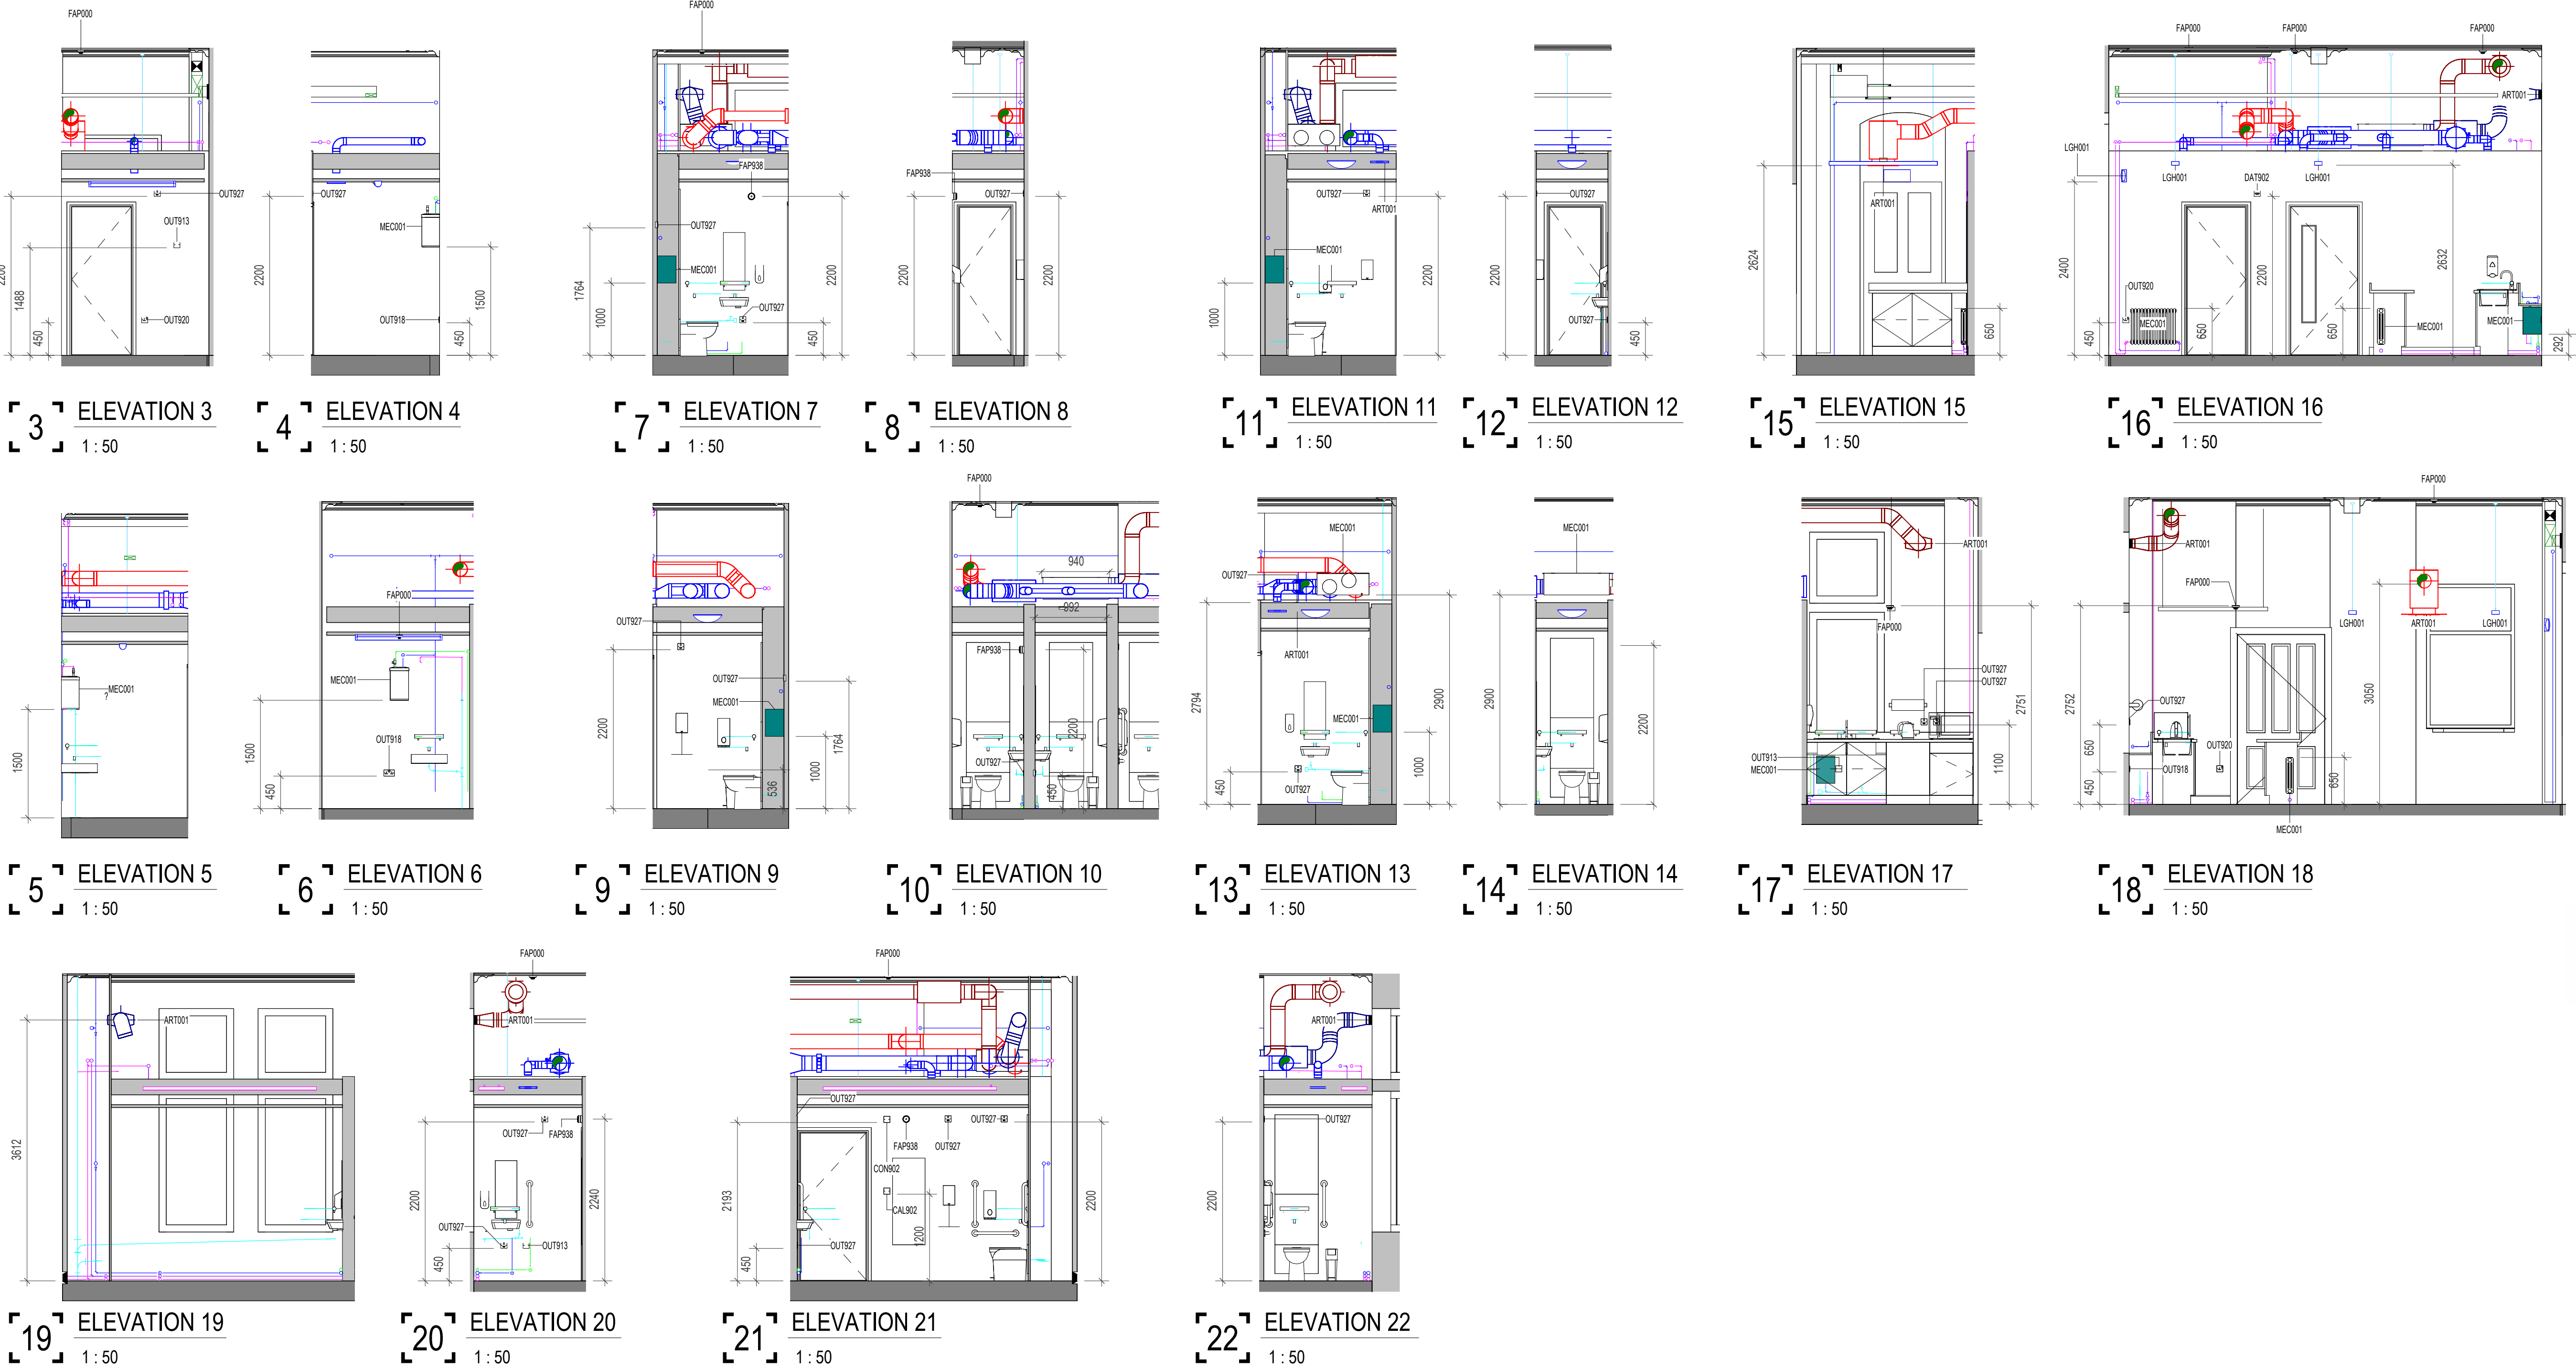

P4	2024/12/17	C-sheets issued to contractor	AB	RM
P3	2024/12/13	C-sheets issued to MCC	AB	RM
P2	2024/07/26	C-sheets issued to MCC	AB	RM
P1	2024/07/12	Co-ordination with MEP	AB	RM
Rev	Date	Revision Notes	Drawn	Review

MANCHESTER
1824
The University of Manchester

ARCADIS

Project
Rutherford Building

Drawing Title
G.056 & G.059 - Tea Point & WCs

Job Number 141532	Date	Security Classification	Drawn By AJ
Scale@A1 1 : 50	Purpose LISTED BUILDING CONSENT		Reviewed By AB
Drawing Number 4905-RBUM-ARC-XX-ZZ-DR-A-4905			Revision P4