


NOTHING IN THIS CONTRACT CONFERS OR PURPORTS TO CONFER ON ANY THRID PARTY ANY BENEFIT OR ANY RIGHT TO ENFORCE ANY TERM OF THIS CONTRACT

THE CONSTRUCTION WORK DETAILED ON THIS DRAWING SHOULD NOT BE COMMENCED UNTIL BUILDING REGULATION APPROVAL HAS BEEN GRANTED, THE WORK IF STARTED BEFORE BUILDING REGULATION APPROVAL HAS BEEN OBTAINED IS AT THE CONTRACTOR'S OWN RISK.

IF IN DOUBT - ASK

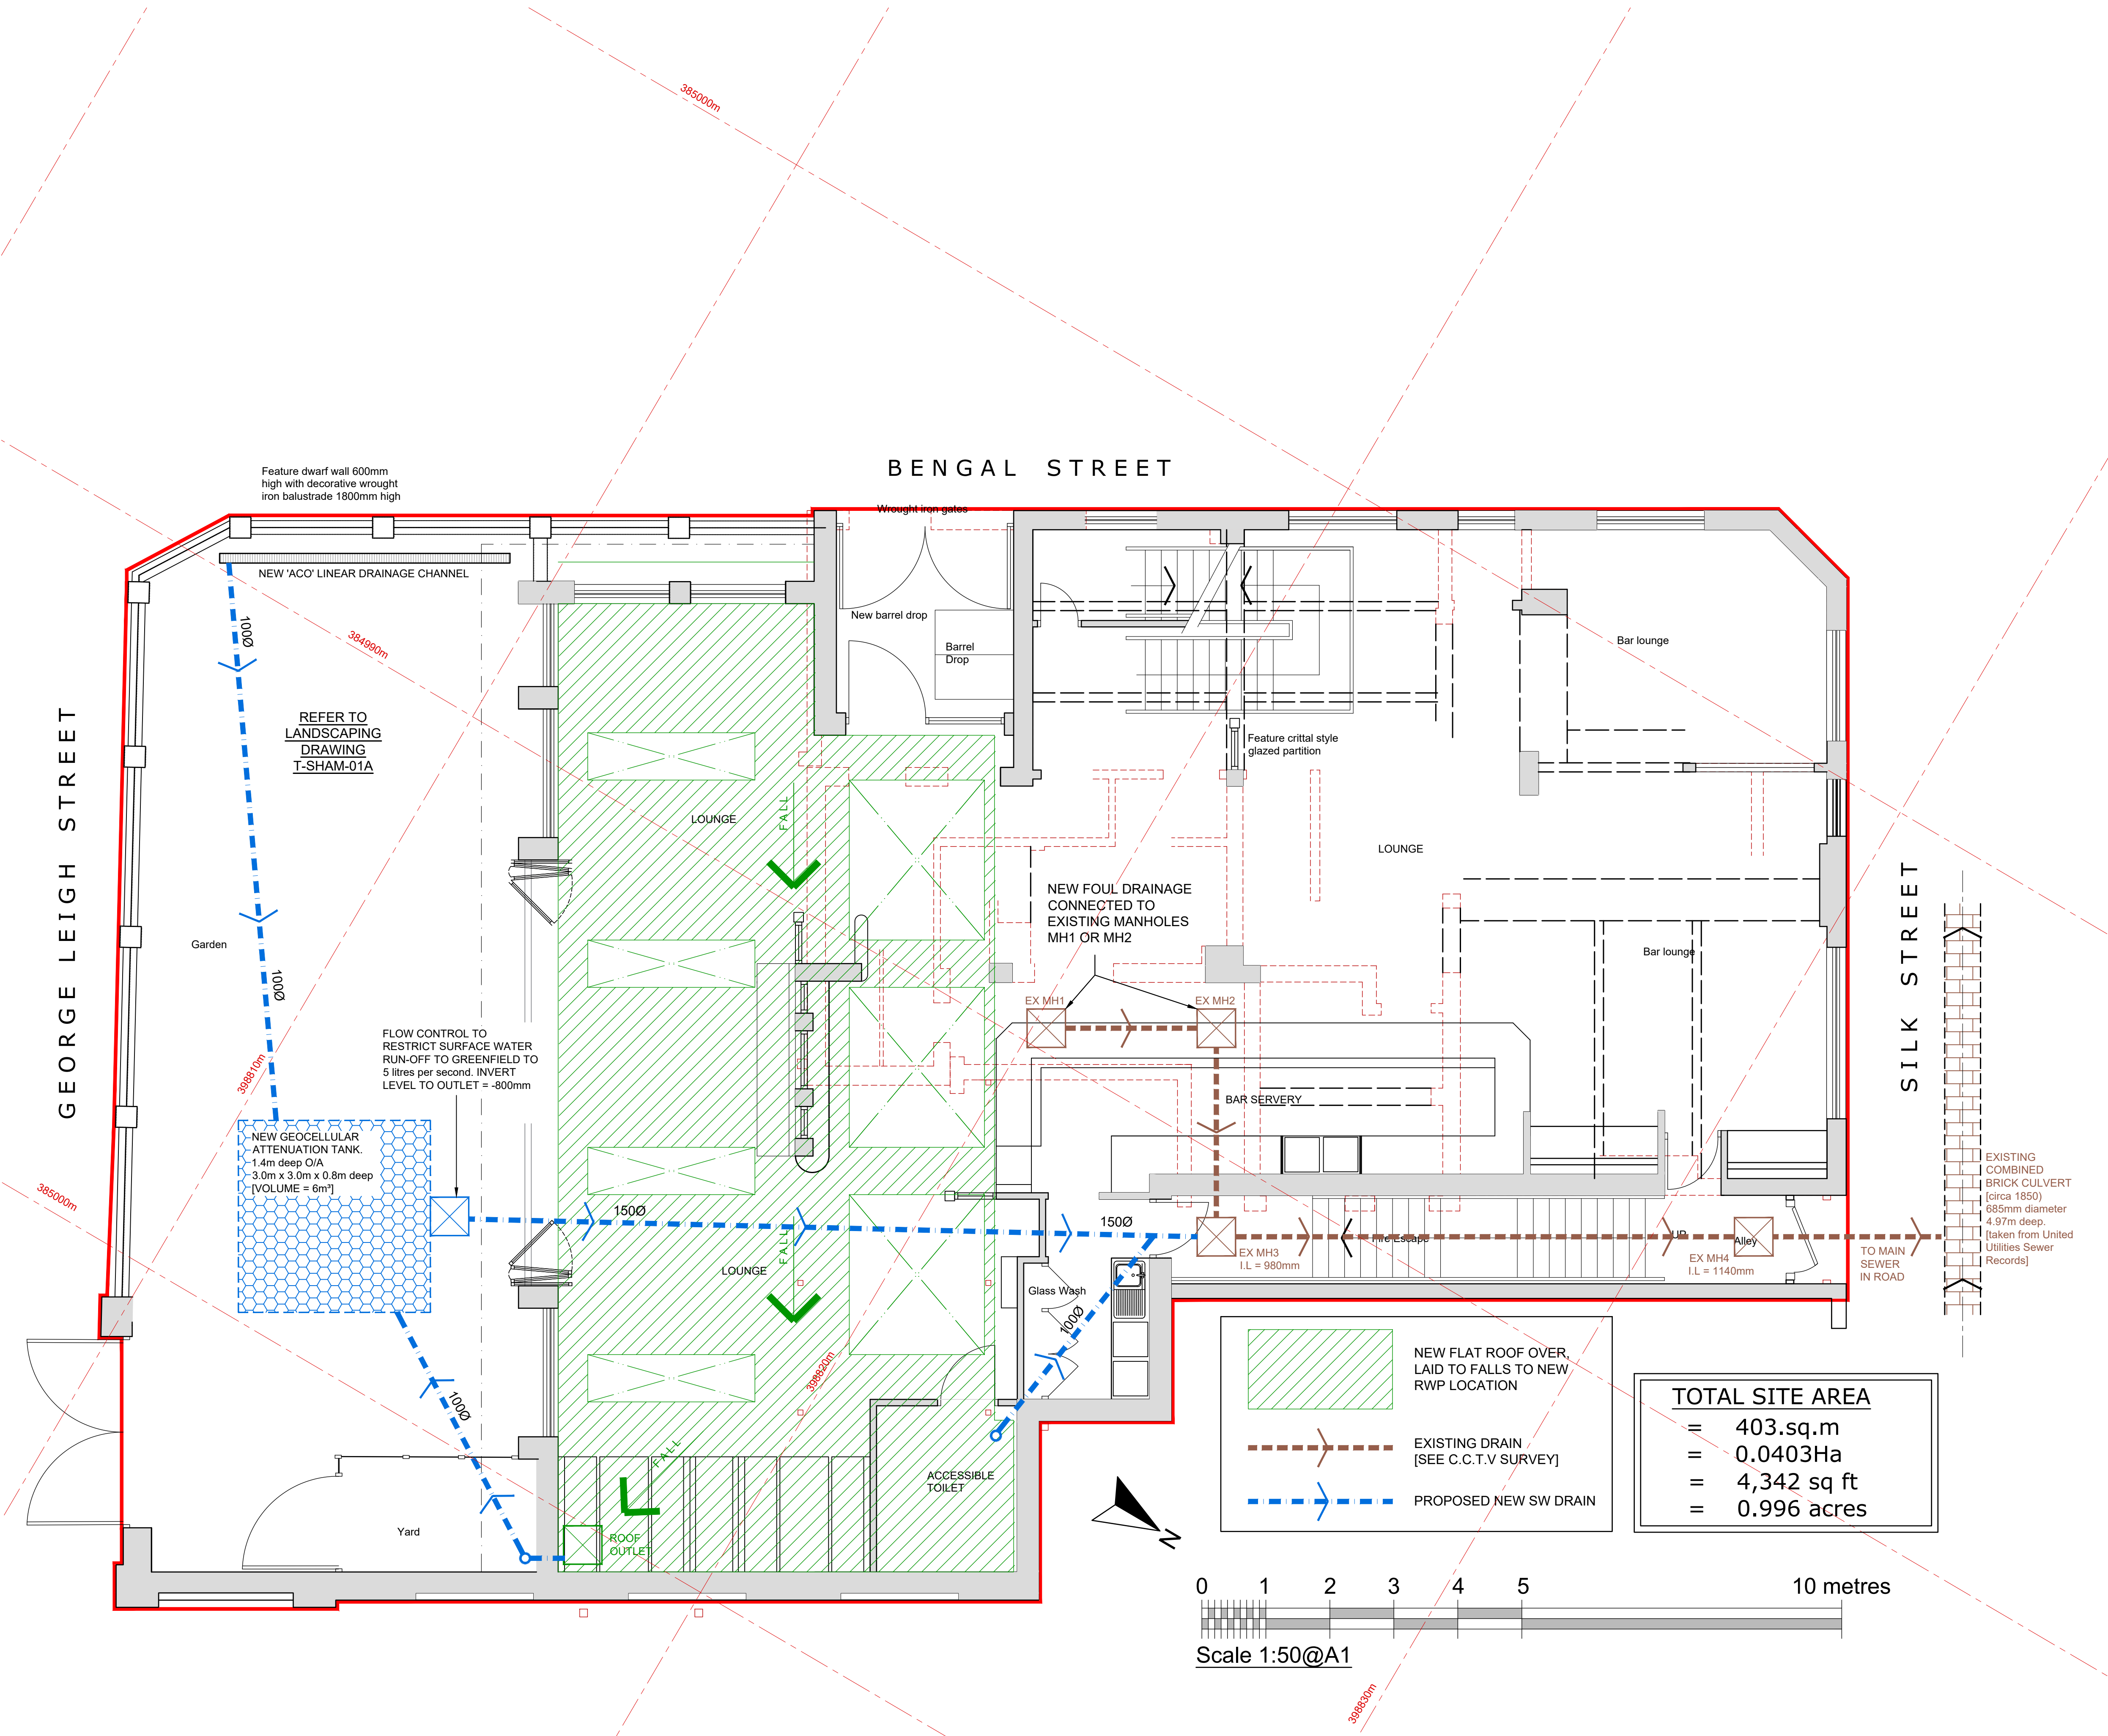

C	UPDATED WITH LATEST JDA PLAN DRAINAGE UPDATED. GRID REF ADDED	06.02.25
B	SW ATTENUATION TANK/ HYDRO BRAKE ADDED	12.11.24
A	ISSUED FOR INFORMATION	07.11.24
REV	AMENDMENTS	DATE

Crawford & Co
Consulting Engineers

Ferndale Court, Chester Road, Pentre, Deeside, Flintshire, CH5 2DJ
T: 01244 520463 M: 07966 141318 E: brian@crawford-td.co.uk

CLIENT
JOSEPH HOLT

PROJECT
THE SHAMROCK, BENGAL STREET
MANCHESTER

DRAWING DESCRIPTION
PROPOSED GROUND FLOOR PLAN
DRAINAGE STRATEGY

DRAWN BY MH
SCALE 1:50@A1
DATE 07.11.24

DRAWING No
BJH14_05

ISSUE / REV
C