
 


PLANNING

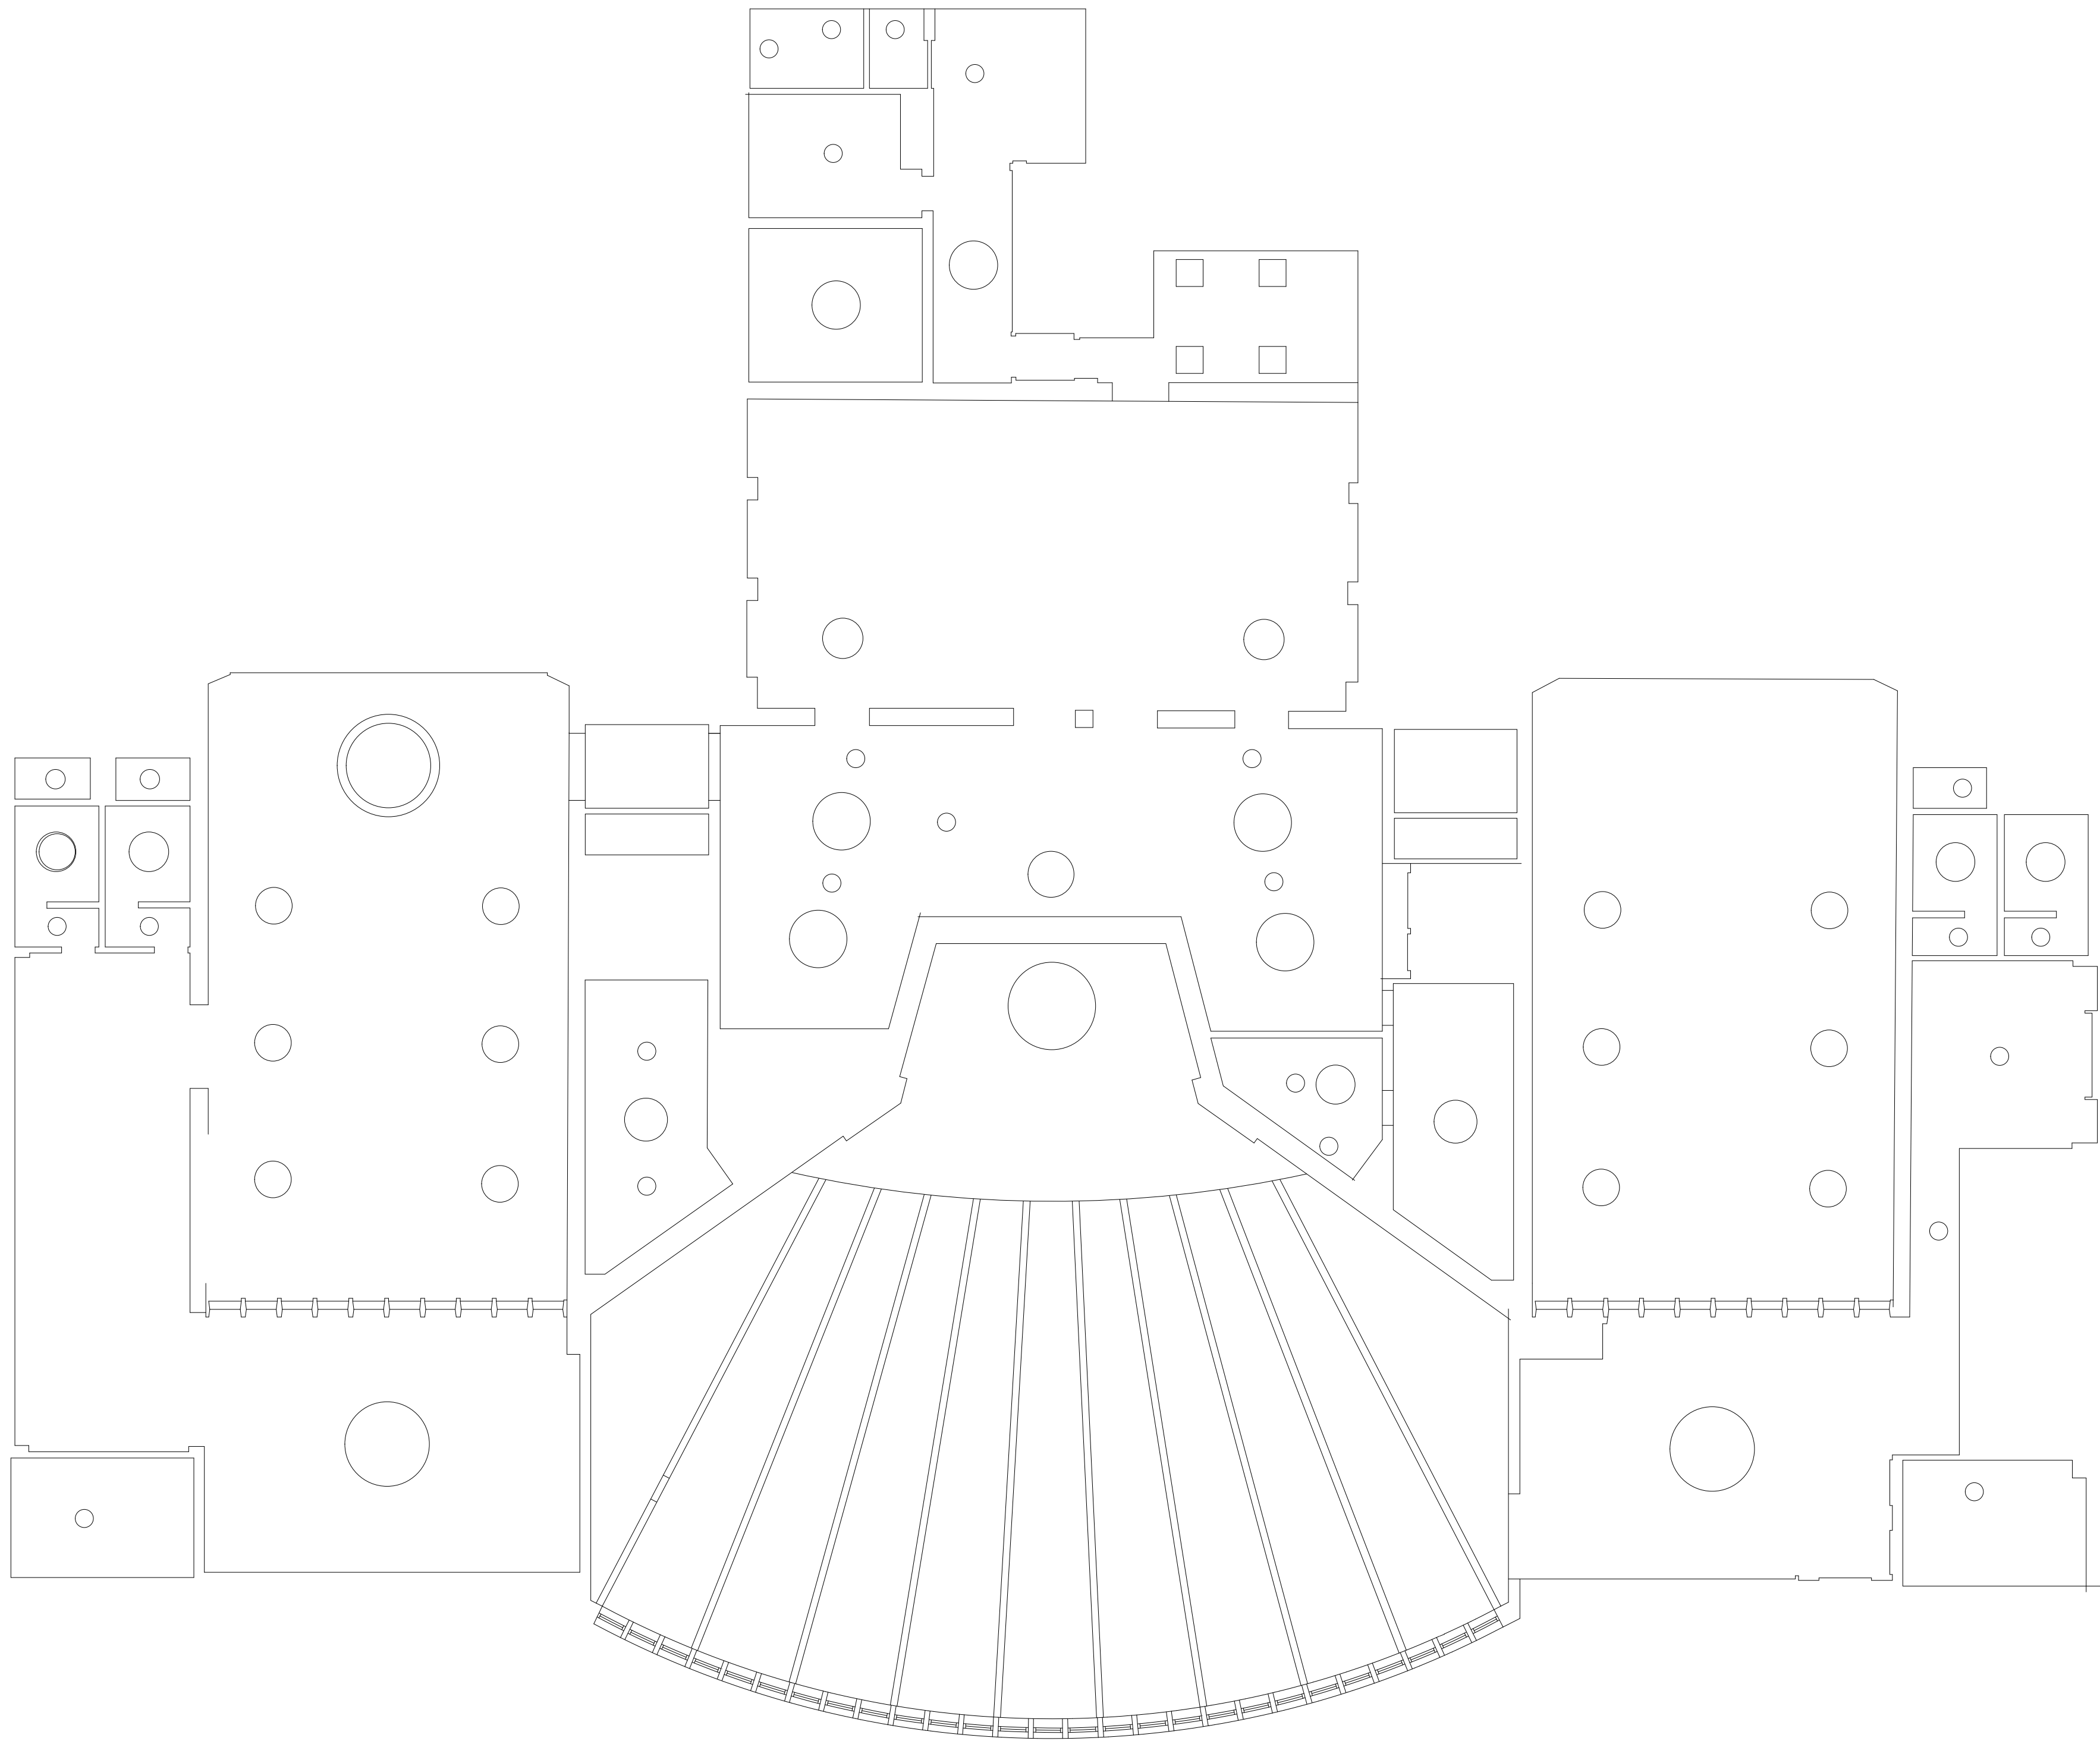

BLACKLEY CREMATORIUM Reflected Ceiling Plan  
Scale 1:100



Notes:

Copyright: All rights reserved. This drawing must not be reproduced without permission from Drees & Sommer UK Ltd. Do not scale off this drawing. All dimensions are to be checked on site by contractor / sub contractor. Any discrepancies to be reported to Drees & Sommer UK Ltd.

DREES & SOMMER

Office Locations  
Ashford, Birmingham, Leeds, Liverpool, London, Manchester & Oxford.  
www.dreso.uk

|                        |      |                                                |       |       |          |
|------------------------|------|------------------------------------------------|-------|-------|----------|
|                        |      |                                                |       |       |          |
| Rev                    | Date | Revision notes                                 |       |       | By Check |
| Client                 |      | Drawing Title                                  |       |       |          |
| MCC Equans PSDS        |      | Blackley Crematorium<br>Reflected Ceiling Plan |       |       |          |
| Project Title          |      | Drawn                                          | Date  |       |          |
| Decarbonisation Scheme |      | RCR                                            | 11/24 |       |          |
| Blackley Crematorium   |      | Checked                                        | Date  |       |          |
|                        |      | GM                                             | 11/24 |       |          |
| DWG No.                |      | 24598.103                                      | Scale | 1:100 | Revision |