




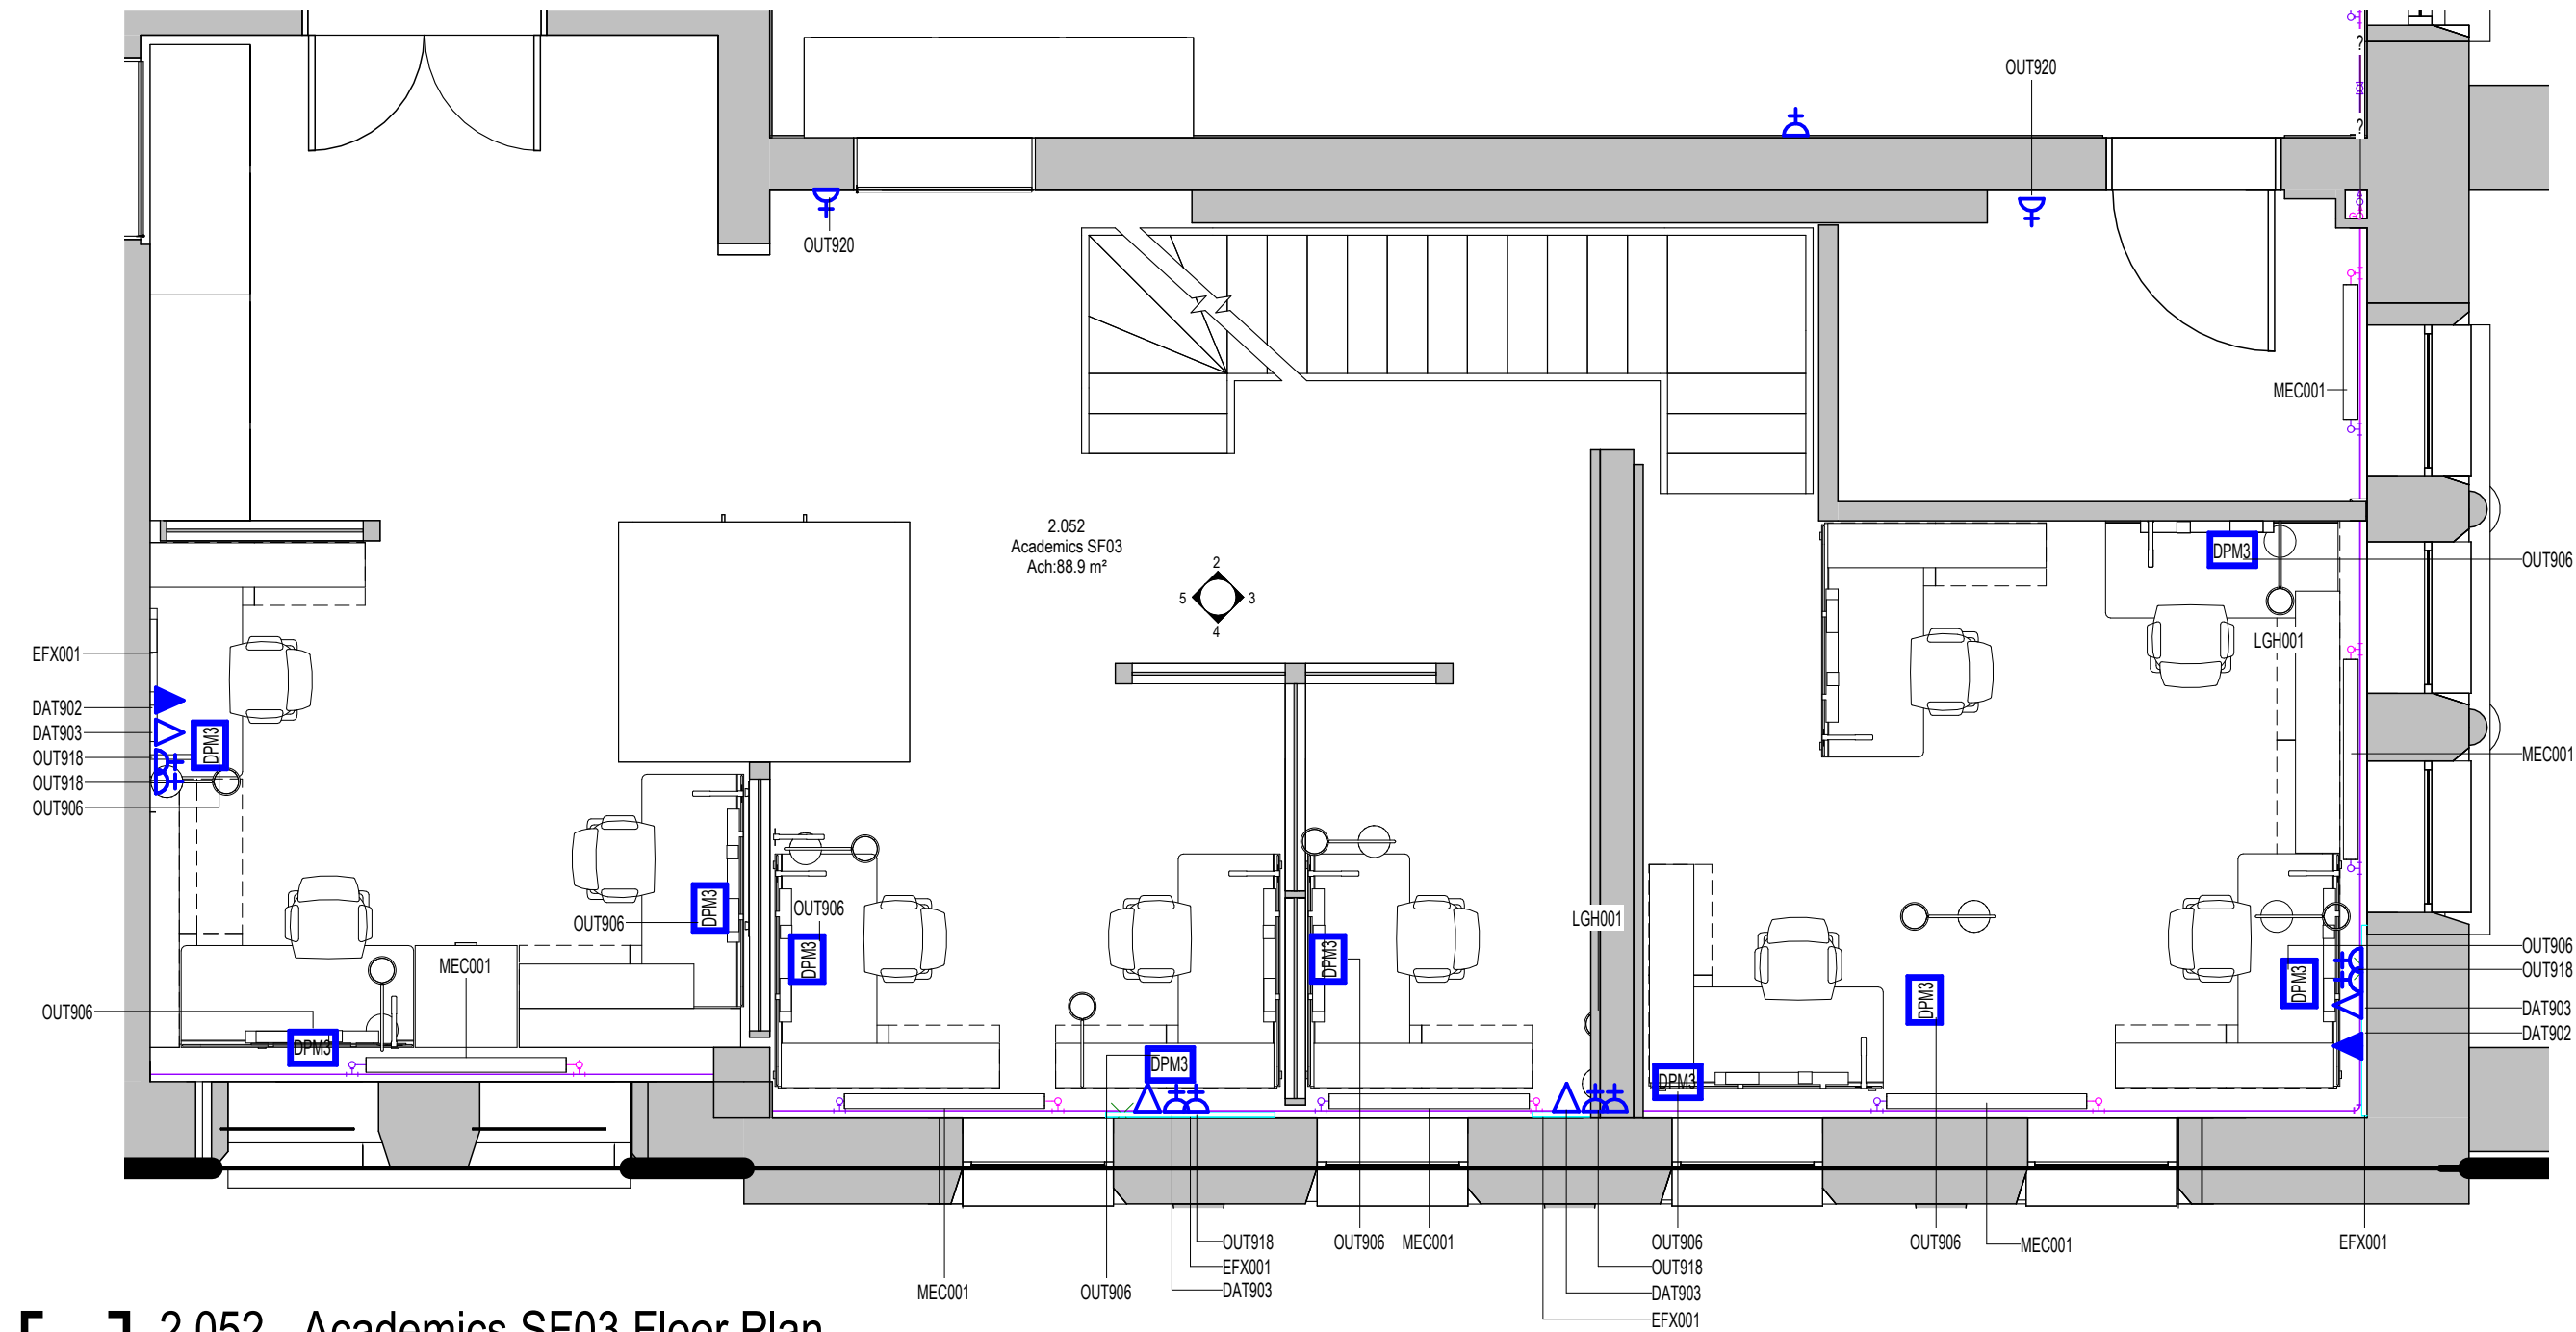


2.052 - Academics SF03 Floor Plan
1 : 50

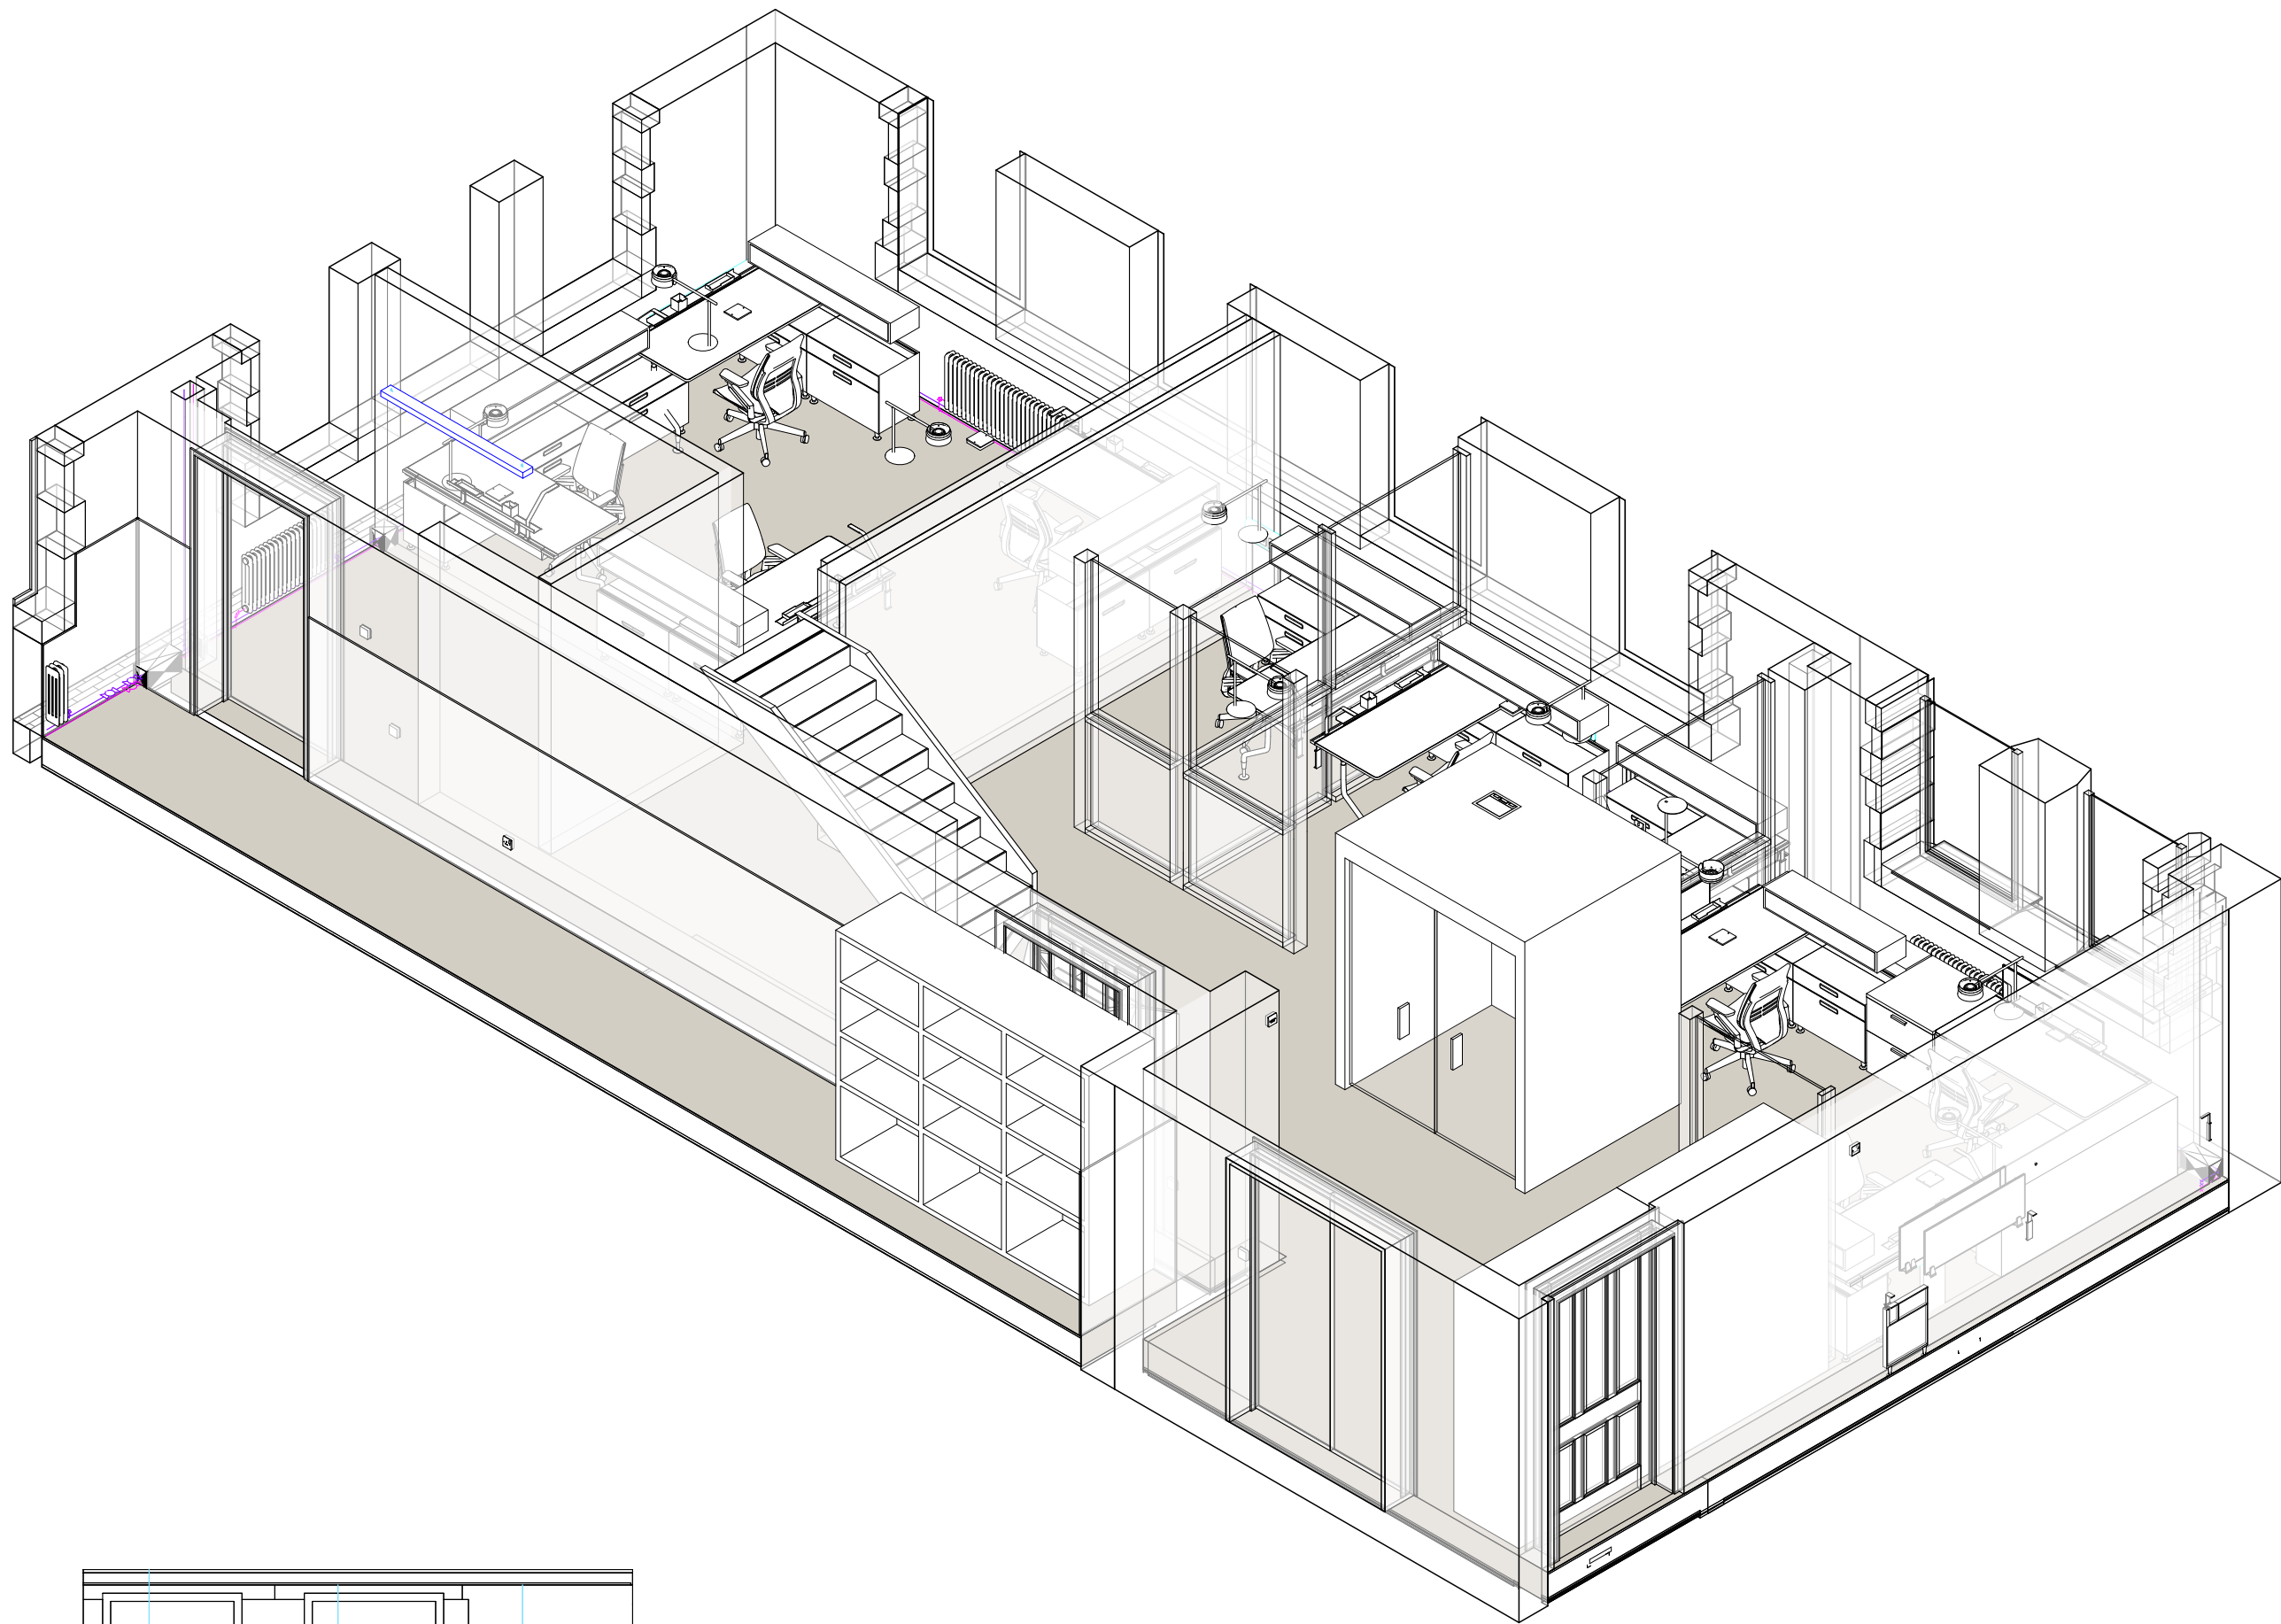

2.052 - Academics SF03 Isometric View
1 : 50

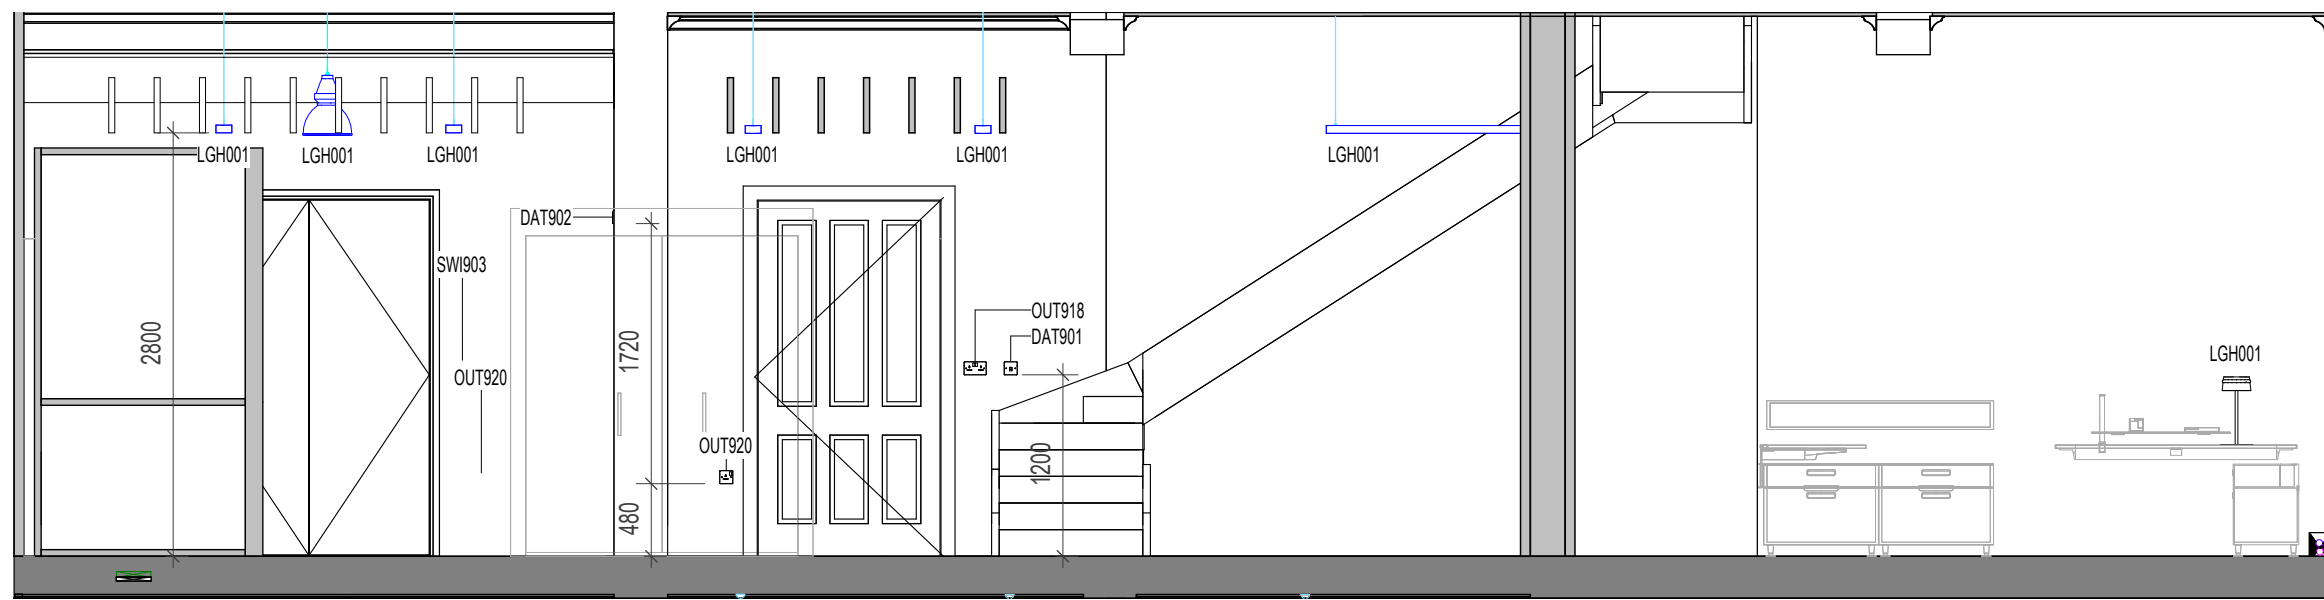


ELEVATION 2
1 : 50

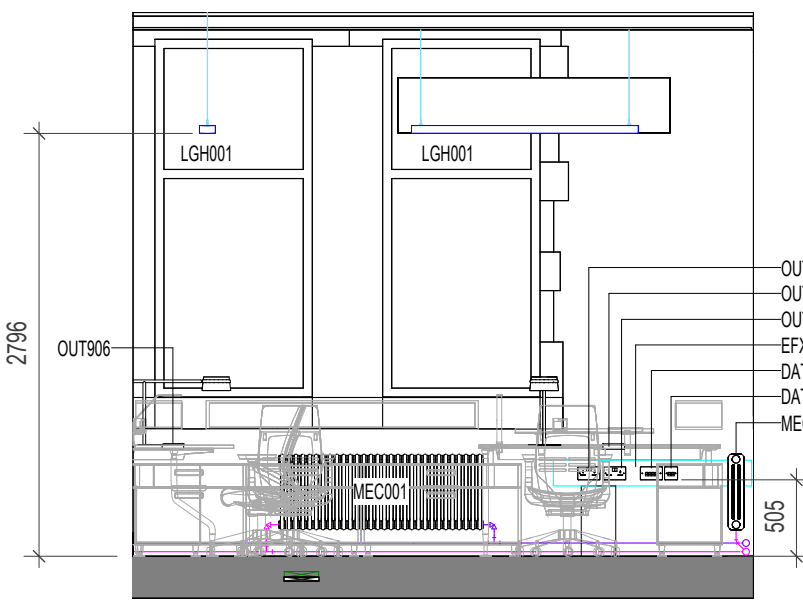


ELEVATION 3
1 : 50

Space Number	Space Name	ADBCode	ADBDescription	ADBGroup
2.052	Academics SF03	DA1902	Double Gang RJ45 Outlet	1
2.052	Academics SF03	DA1903	Four Gang RJ45 Outlet	1
2.052	Academics SF03	EFX001	Electrical Future	1
2.052	Academics SF03	FAP000	Multi Detector (FA)	1
2.052	Academics SF03	LGH001	Lighting Future	1
2.052	Academics SF03	MEC001	Mechanical Equipment	1
2.052	Academics SF03	OUT906	Automatic Changerover Switch	1
2.052	Academics SF03	OUT918	Double Switched Socket Outlet - Plastic	1
2.052	Academics SF03	OUT920	Single Switched Socket Outlet - Plastic	1
2.052	Academics SF03	OUT927	Switched Fused Connection Unit - Plastic	1
2.052	Academics SF03	SW903	Plastic Retractive Light Switch	1

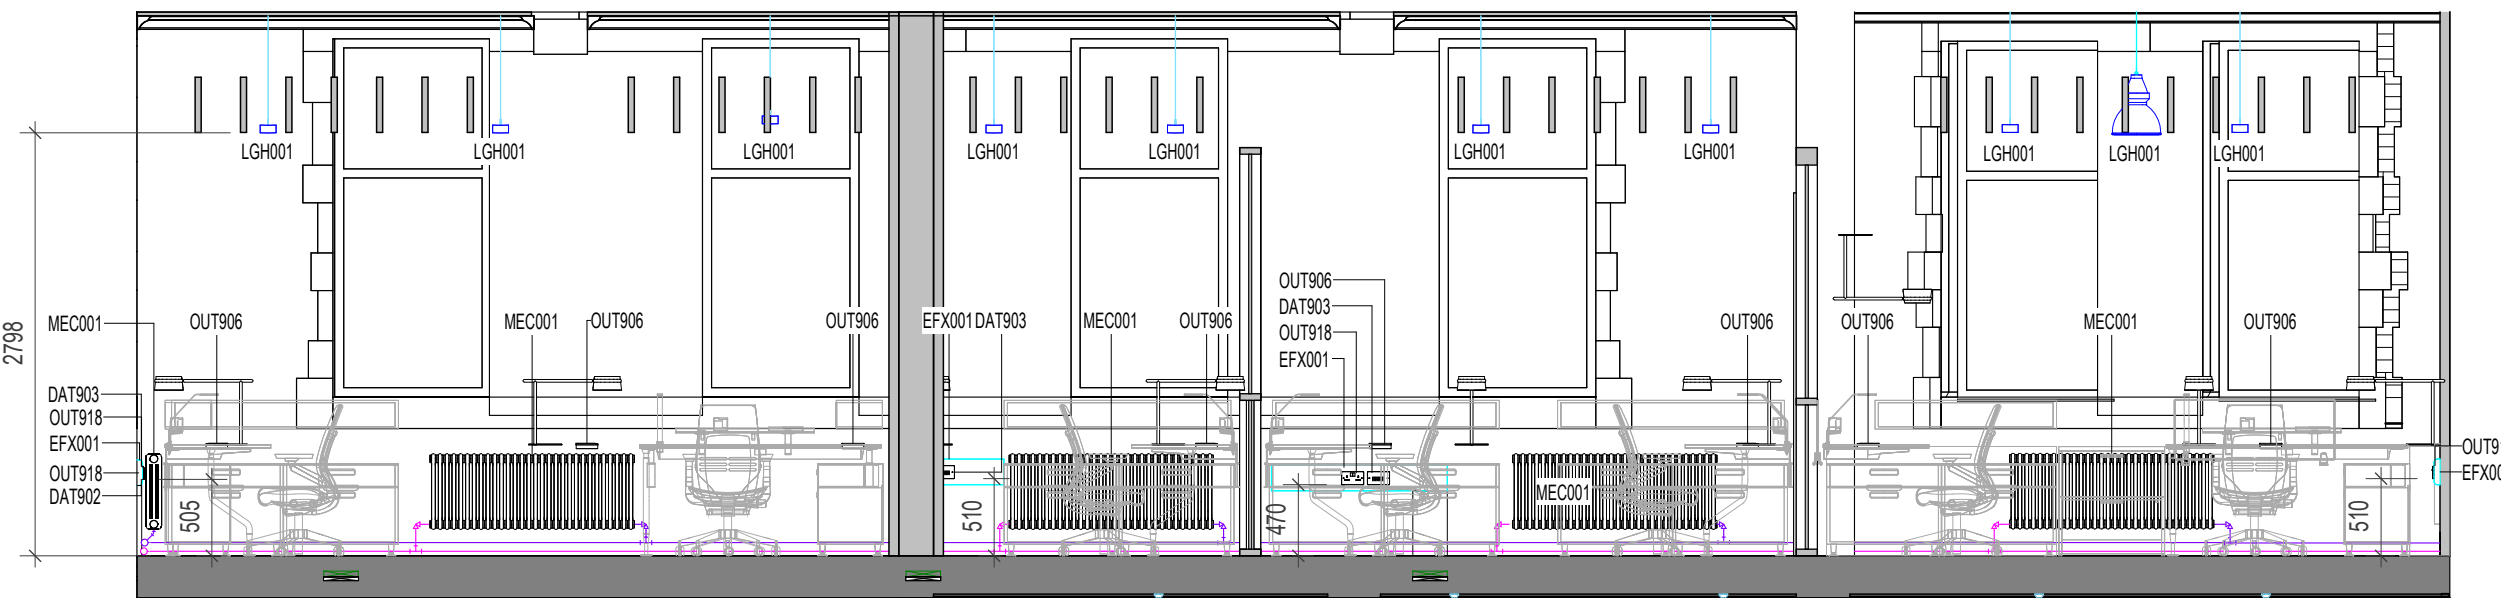

ELEVATION 4
1 : 50

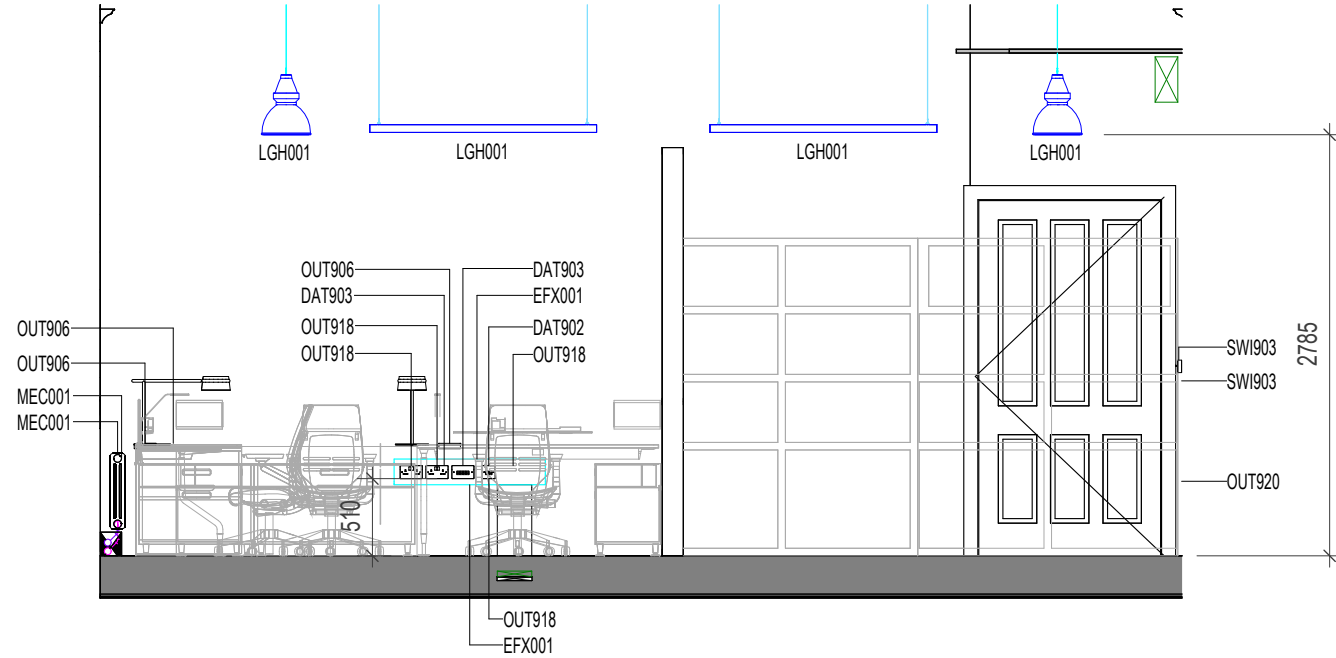

ELEVATION 5
1 : 50

Notes:
• This drawing is copyright.
• Do not scale dimensions from this drawing.
• This drawing is to be read in conjunction with all other relevant drawings.
• All discrepancies on this drawing are to be reported to the architect.
• Do not modify any element of this drawing.
• Use drawing only for purpose(s) issued.
• This drawing may contain colour.
Scale Bar

North Point

Key Plan

The following external model files are included within this drawing:

P4	2024/12/13	C-sheets issued to MCC	AB	RM
P3	2024/10/02	Existing wall retained, screen removed, FFE changed within	EM	AB
P2	2024/07/26	C-sheets issued to MCC	AB	RM
P1	2024/07/12	Co-ordination with MEP	AB	RM
Rev	Date	Revision Notes	Drawn	Review

MANCHESTER
1824
The University of Manchester

ARCADIS

Project
Rutherford Building

Drawing Title
2.052 - Academics SF03

Job Number 141532	Date JULY '24	Security Classification	Drawn By AJ
Scale@A1 1 : 50	Purpose LISTED BUILDING CONSENT	Reviewed By AB	Revision P4
Drawing Number 4916-RBUM-ARC-XX-ZZ-DR-A-4916			