



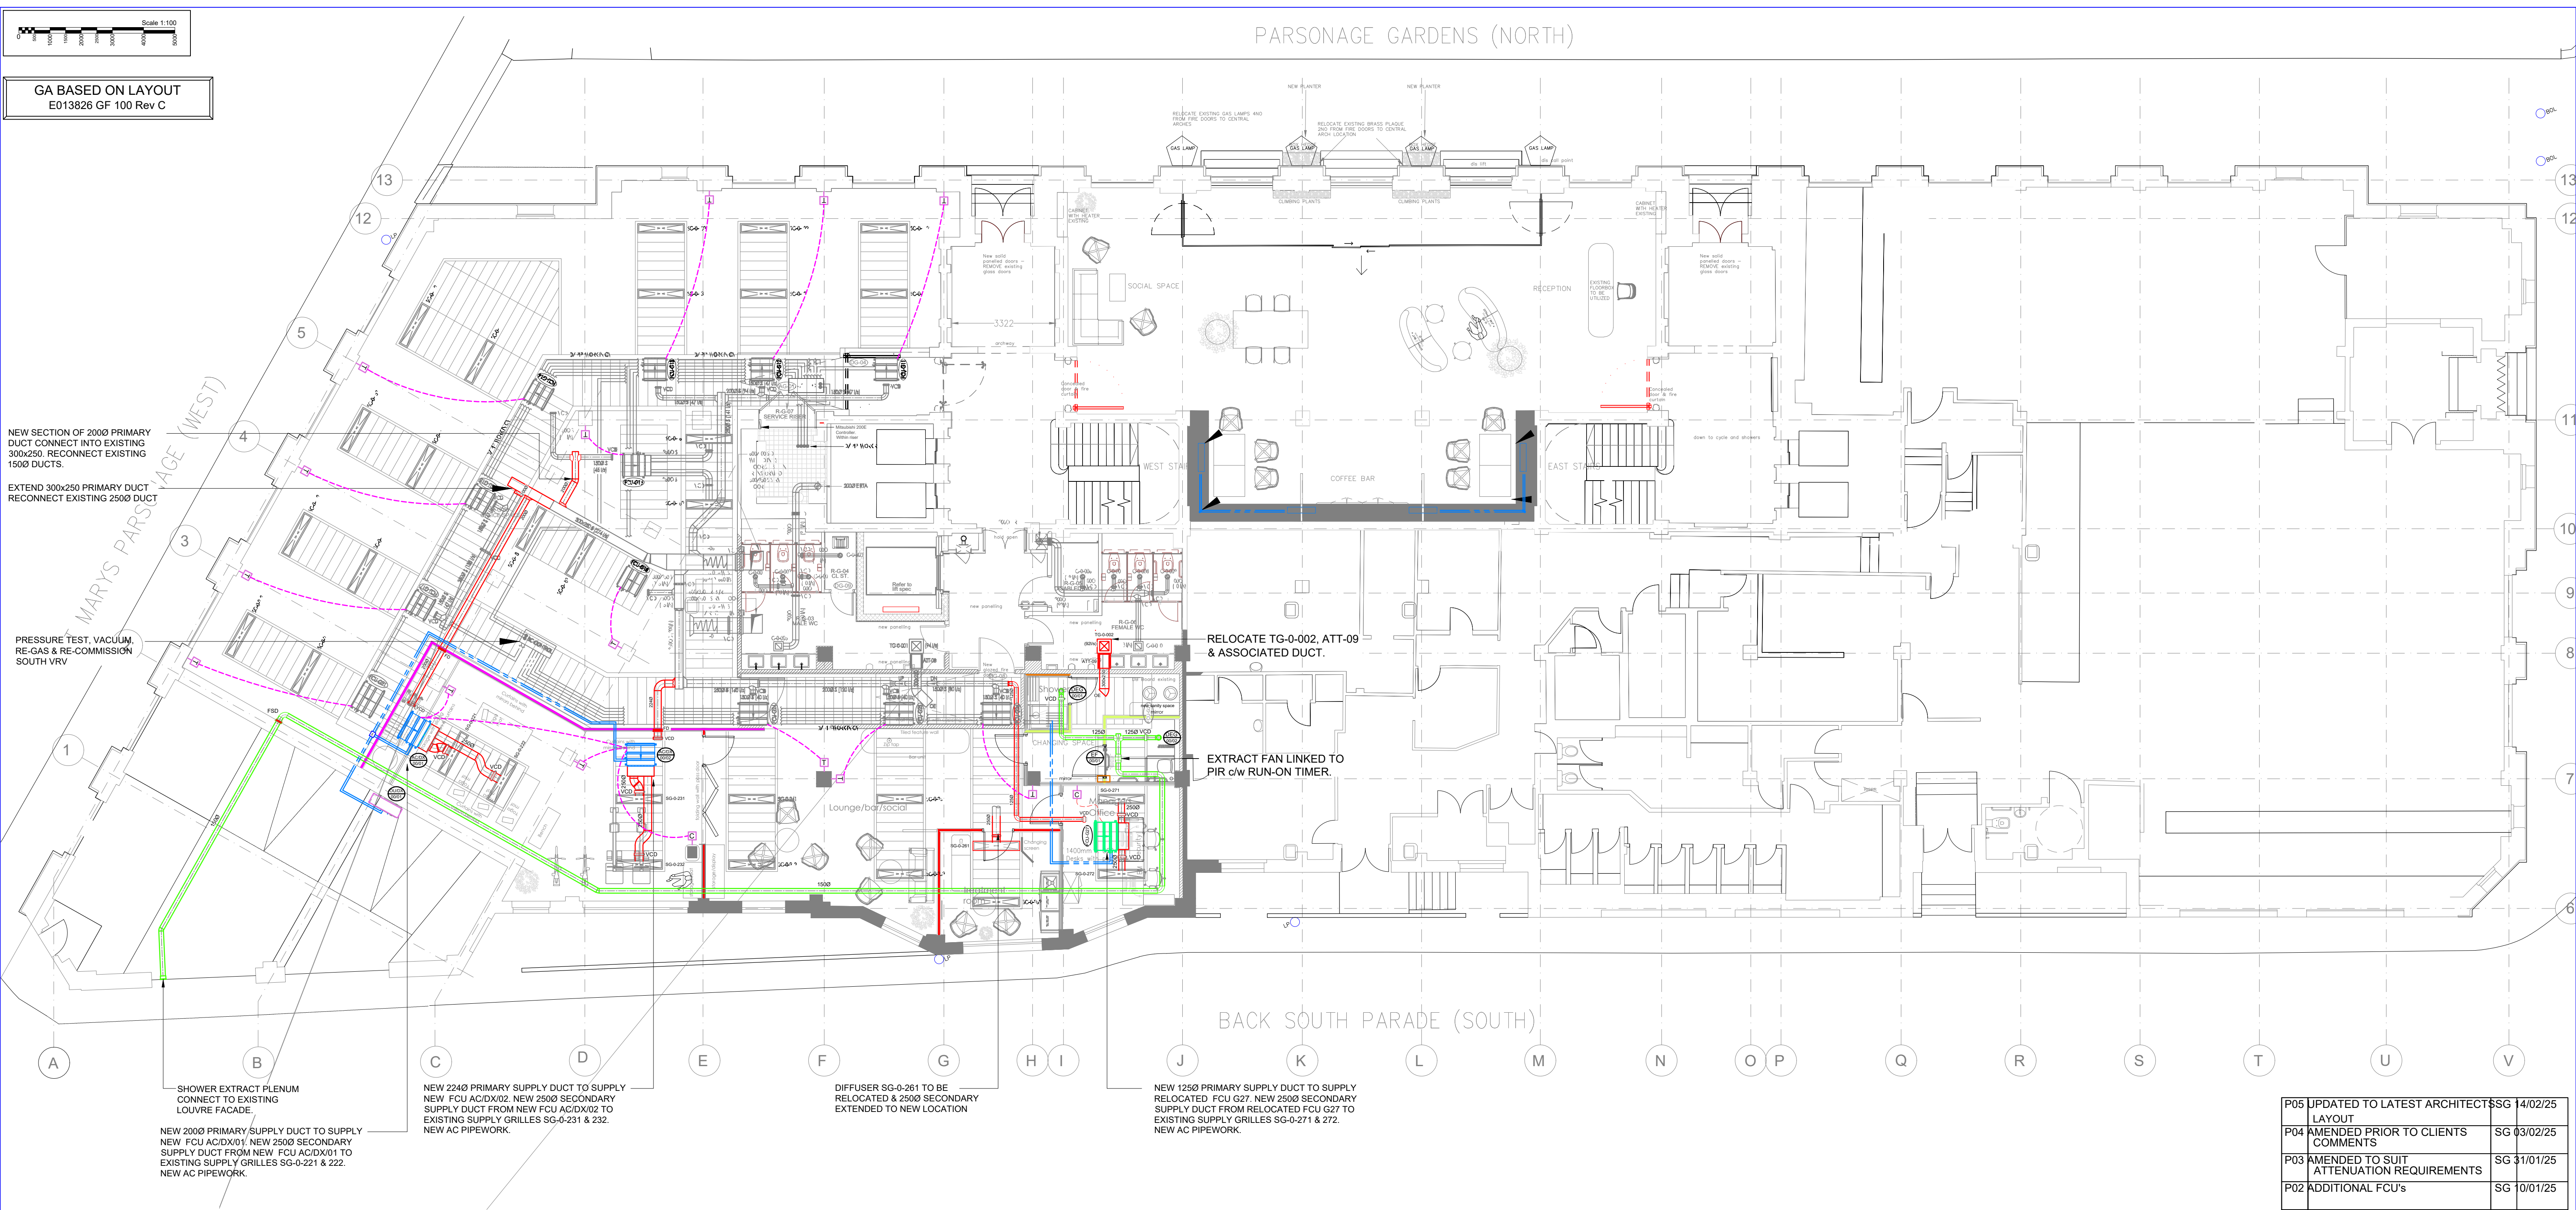

NOTES:

- THIS DRAWING SHOULD BE READ IN CONJUNCTION WITH ALL CONSTRUCTION ISSUED PROJECT INFORMATION - DRAWINGS, REPORTS, SPECIFICATIONS & CONTRACTORS PROPOSAL PACK.
- ALL DIMENSIONS TAKEN FROM THIS DRAWING SHOULD BE MEASURED & VERIFIED ON SITE PRIOR TO INSTALLATION.
- ALL WORKS ARE TO BE UNDERTAKEN IN LINE WITH THE CURRENT M&E PROGRAMME OF WORKS.
- ALL SERVICES SHALL BE PROVIDED IN LINE WITH THE ARCHITECTS LAYOUT DRAWINGS & WHERE DISCREPANCIES BETWEEN THE M&E INFORMATION & CONSTRUCTION LAYOUTS OCCUR THIS MUST BE BROUGHT TO THE ATTENTION OF THE PROJECT TEAM FOR FURTHER CLARIFICATION.
- THE VENTILATION INSTALLATION SHALL CONFORM TO ALL PARTS OF BUILDING REGULATIONS, APPROVED DOCUMENT F.
- THE DUCTWORK INSTALLATION SHALL COMPLY WITH BS 5720 & THE CONSTRUCTION OF DUCTWORK SHALL BE IN ACCORDANCE WITH THE SPECIFICATION FOR SHEET METAL DUCTWORK DW/144 & DW/TM2.
- ALL DUCTWORK SHALL BE MANUFACTURED, INSTALLED & TESTED TO SUIT PRESSURE TEST CLASSIFICATION A, LOW PRESSURE.
- ALL DUCTWORK SHALL BE MANUFACTURED FROM BEST QUALITY COLD REDUCED CONTINUOUSLY HOT DIPPED GALVANISED SHEET STEEL WITH A MINIMUM SHEET THICKNESS OF 0.8mm.
- FIXINGS SHALL BE MECHANICALLY CLOSED TO NEGATE LEAKAGE. FIXING BY SELF-TAPPING SCREWS IS NOT ACCEPTABLE. SELF-ADHESIVE TAPE SHALL NOT BE USED TO SEAL DUCTWORK.
- ALL FANS & ITEMS OF PLANT CONTAINING MOVING EQUIPMENT SHALL BE PROVIDED WITH FLEXIBLE CONNECTIONS TO TO PREVENT TRANSMISSION OF VIBRATION.
- FIRE DAMPERS ARE TO BE LOCATED WHERE ANY DUCTWORK PASSES THROUGH A FIRE COMPARTMENT OR WALL. ALL FIRE DAMPERS WILL HAVE A MINIMUM 2 HOUR FIRE RATING & BE COMPLETE WITH BLADES EXTERNAL TO THE DUCT.
- ALL DUCT VOLUME CONTROL DAMPERS SHALL BE MANUFACTURED WITH MULTI-OPPOSED AERODYNAMIC DOUBLE SKIN STAINLESS STEEL BLADES SUITABLE FOR BALANCING & SHUT OFF. SINGLE BLADE DAMPERS SHALL NOT BE USED.
- ACCESS DOORS SHALL BE INSTALLED FULLY IN ACCORDANCE WITH BESA DW DOCUMENTS, WITH ADDITIONAL ACCESS DOORS REQUIRED FOR FUTURE CLEANING ALSO INSTALLED DURING THE INSTALLATION, TO SUIT METU ACCESS PORT IPR-RRD WITH RETAINING CABLE
- FLEXIBLE CONNECTIONS FOR CONNECTION TO GRILLES / DIFFUSERS SHALL BE MANUFACTURED BY LINDAB, THEIR THERMALLY INSULATED TECSONIC 400S RANGE & SHALL BE NO LONGER THAN 500mm.
- ALL GENERAL SUPPLY & EXTRACT DUCTWORK INDICATED ON THE VENTILATION LAYOUT TO BE THERMALLY INSULATED GENERALLY WITH MINERAL WOOL TO A MINIMUM THICKNESS OF 40mm ACCORDANCE WITH BS 5422:2009. UTILITY EXTRACT VENTILATION SYSTEMS ARE NOT TO BE INSULATED.

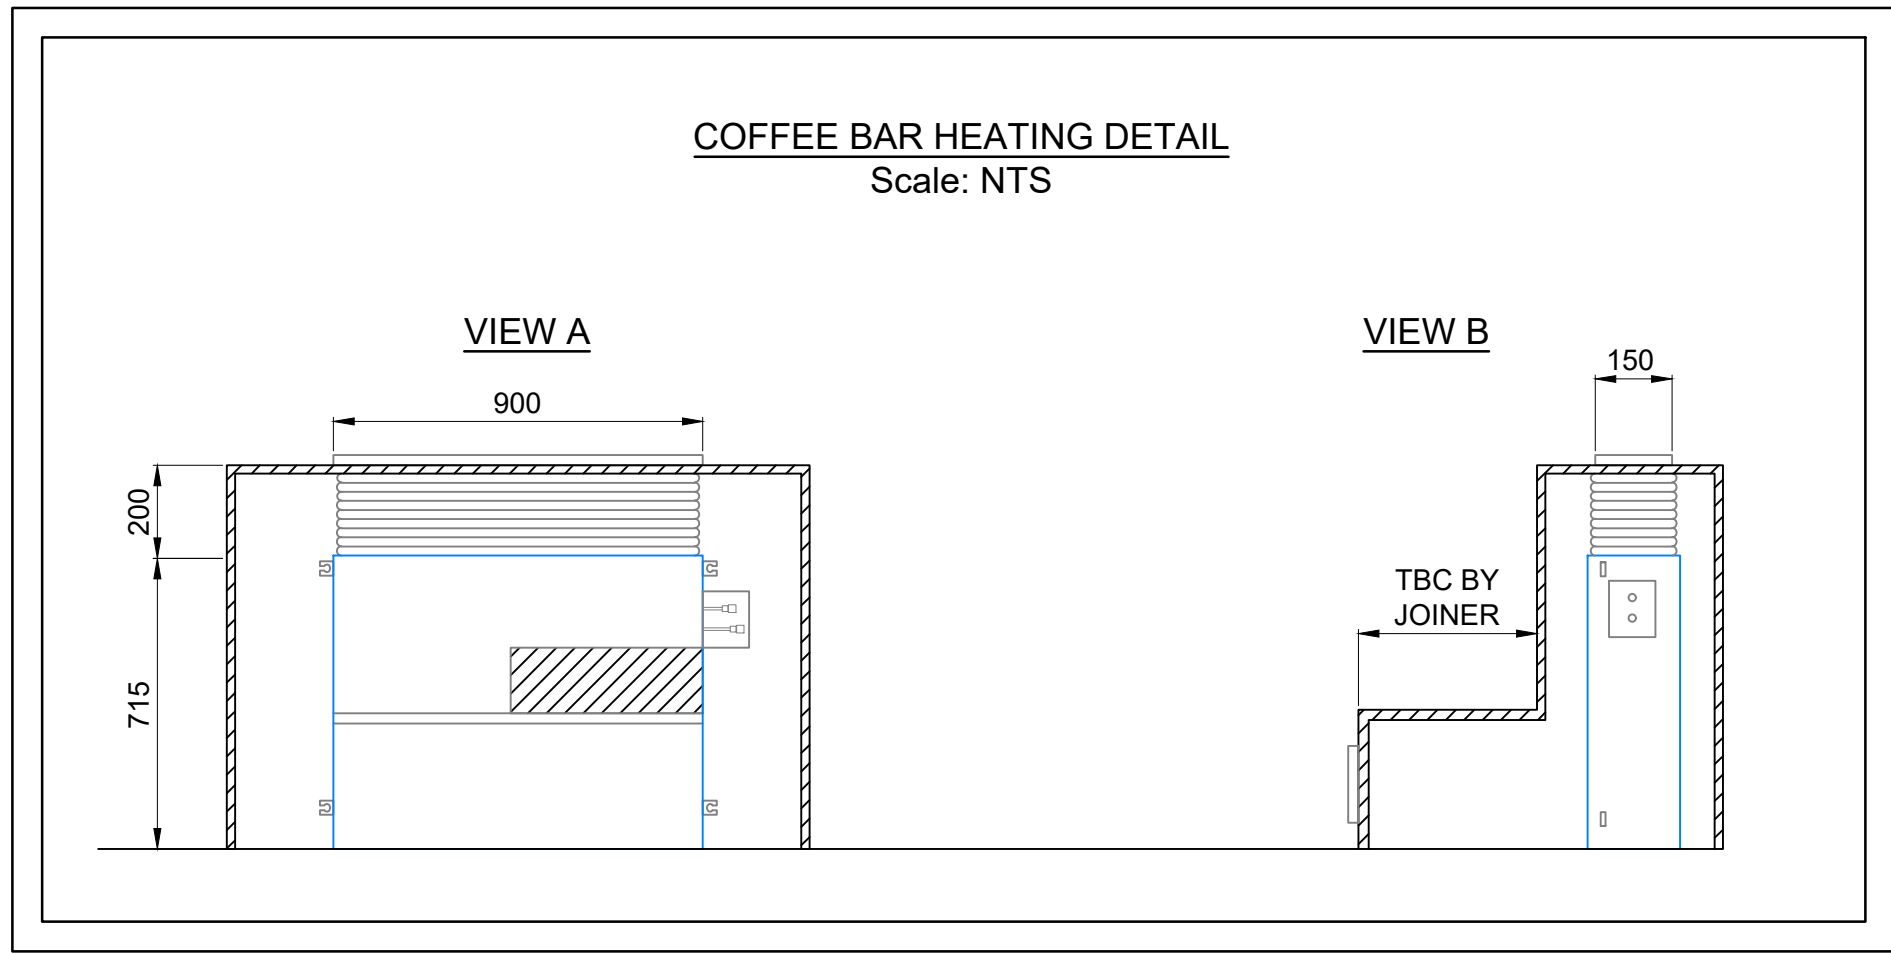

P05	UPDATED TO LATEST ARCHITECTS	SG	14/02/25
P04	LAYOUT		
P04	AMENDED PRIOR TO CLIENTS	SG	03/02/25
P03	COMMENTS		
P03	AMENDED TO SUIT	SG	31/01/25
P03	ATTENUATION REQUIREMENTS		
P02	ADDITIONAL FCU's	SG	10/01/25
P01	FIRST ISSUE	GD	29/11/24

CONTRACTORS PROPOSAL

DL PROJECT No C/24/4270

ARKWRIGHT HOUSE
MANCHESTER
M3 2LF



TITLE
GROUND FLOOR
MECHANICAL SERVICES

DRAWN	GD	CAD	GD	CHECKED	-
SCALE	1:100 @ A1	DATE	NOVEMBER 2024		
DRAWING No	244270-M-00-2551	REV	P05		