


1 1.058 Meeting FF Floor Plan
1 : 50


Space Number	Space Name	ADBCode	ADBDescription	ADBGroup
1.058	Meeting FF	DAT902	Double Gang R45 Outlet	1
1.058	Meeting FF	LGH001	Lighting Fixture	1
1.058	Meeting FF	MEC001	Mechanical Equipment	1
1.058	Meeting FF	OUT920	Single Switched Socket Outlet - Plastic	1
1.058	Meeting FF	SW903	Plastic Retractive Light Switch	1

Space Number	Space Name	ADBCode	ADBDescription	ADBGroup
1.001	Circ FF	LGH001	Lighting Fixture	1


Space Number	Space Name	ADBCode	ADBDescription	ADBGroup
1.002	Circ FF	DAT902	Double Gang R45 Outlet	1
1.002	Circ FF	FAP909	Disabled Refuge Call Handset	1
1.002	Circ FF	OUT920	Single Switched Socket Outlet - Plastic	1

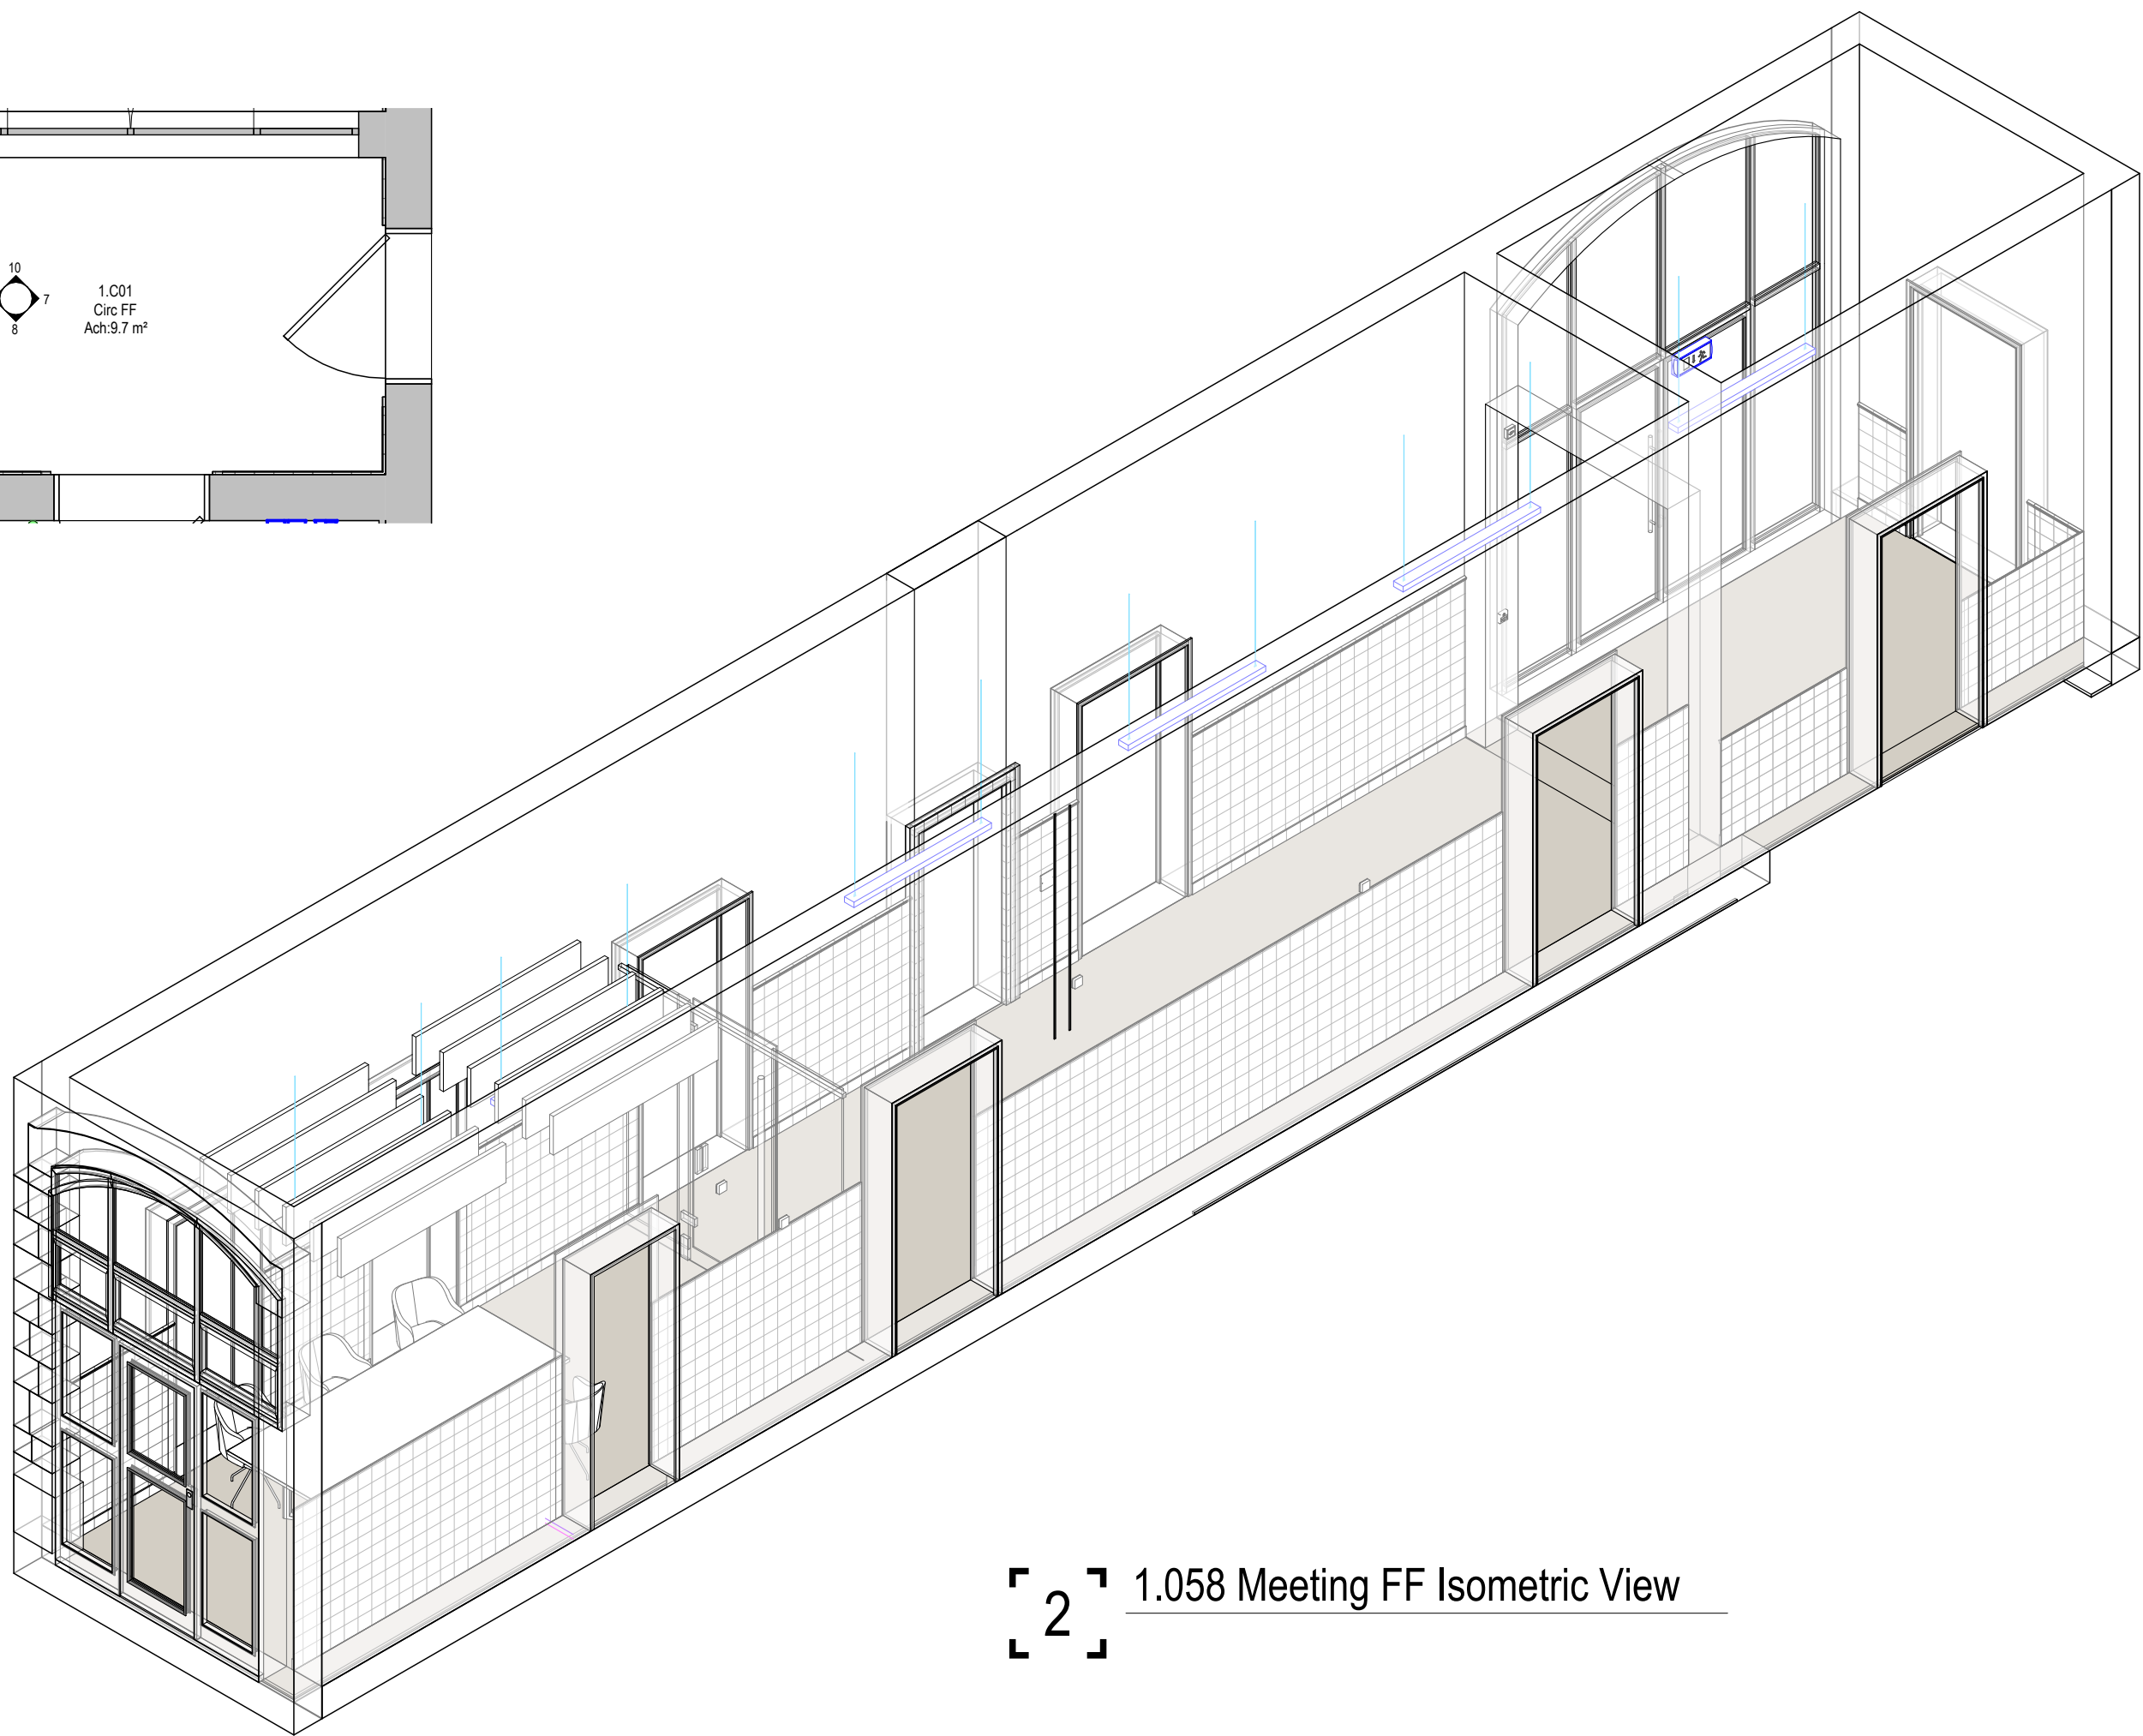


2 1.058 Meeting FF Isometric View

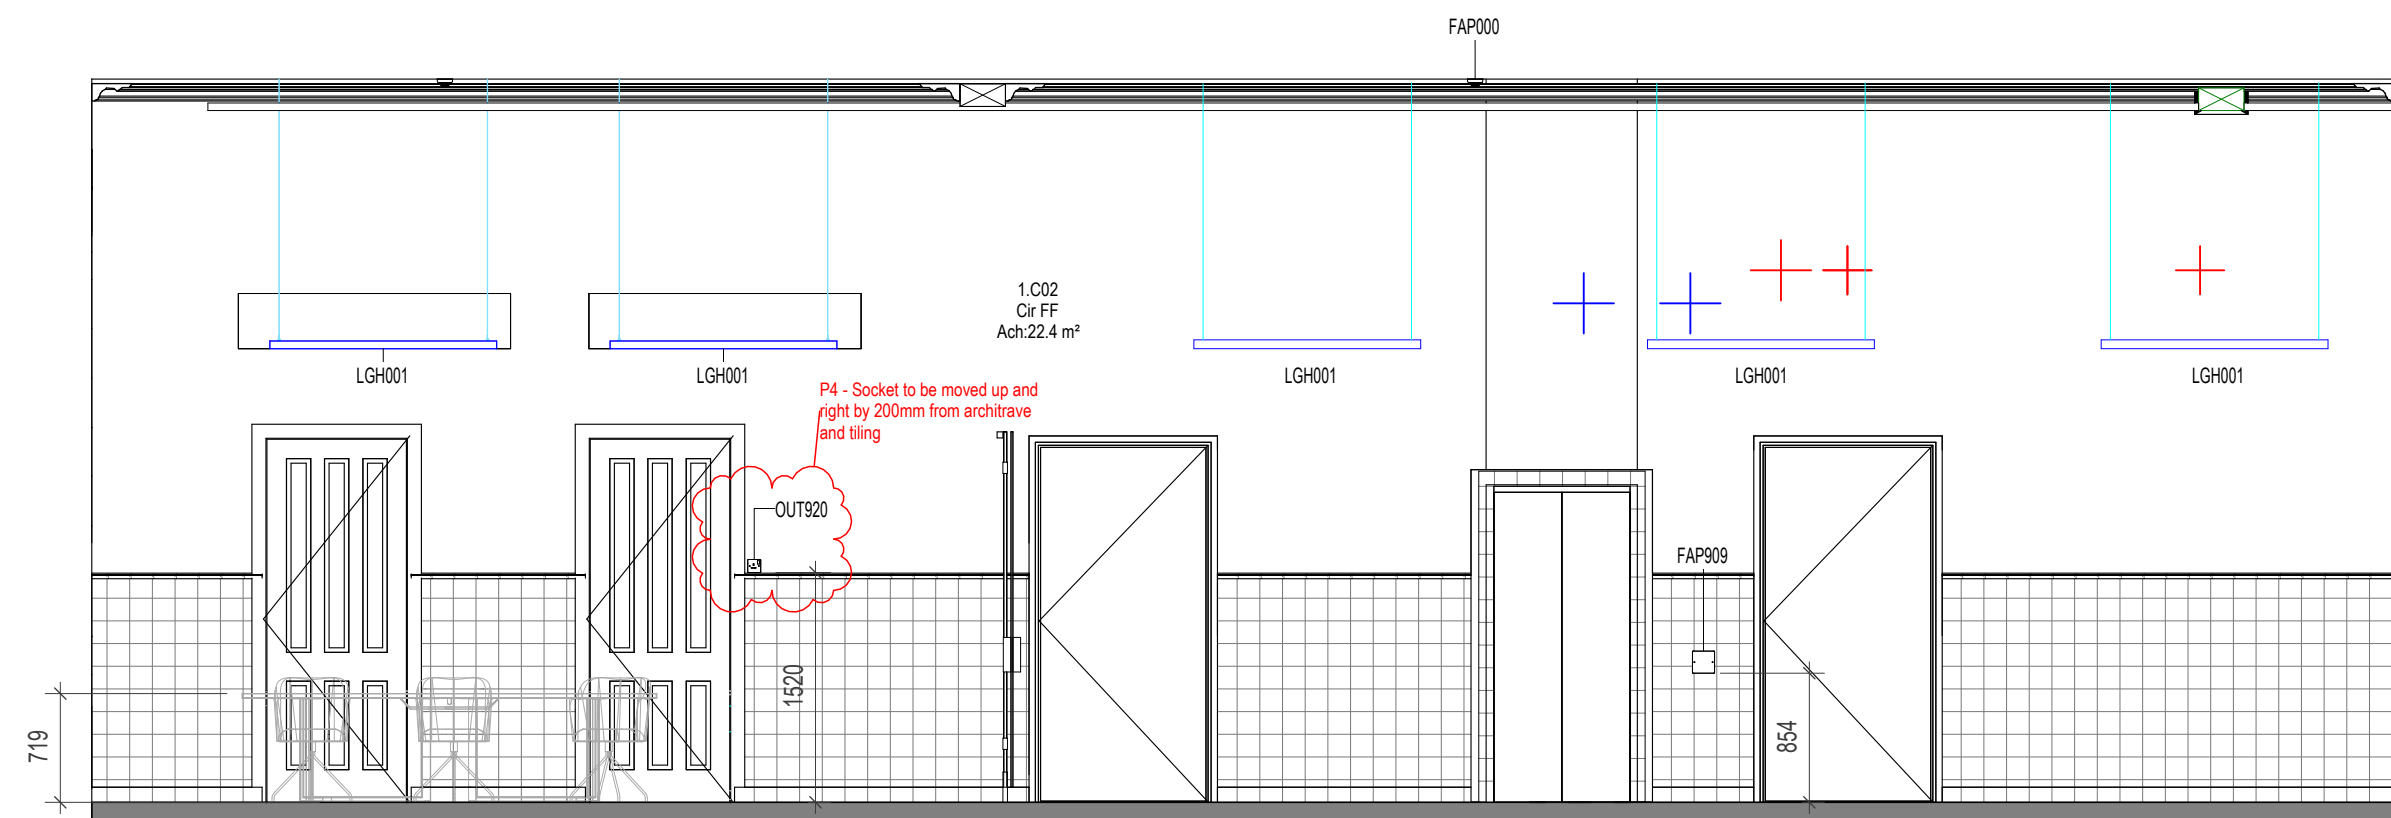


3 ELEVATION 3
1 : 50

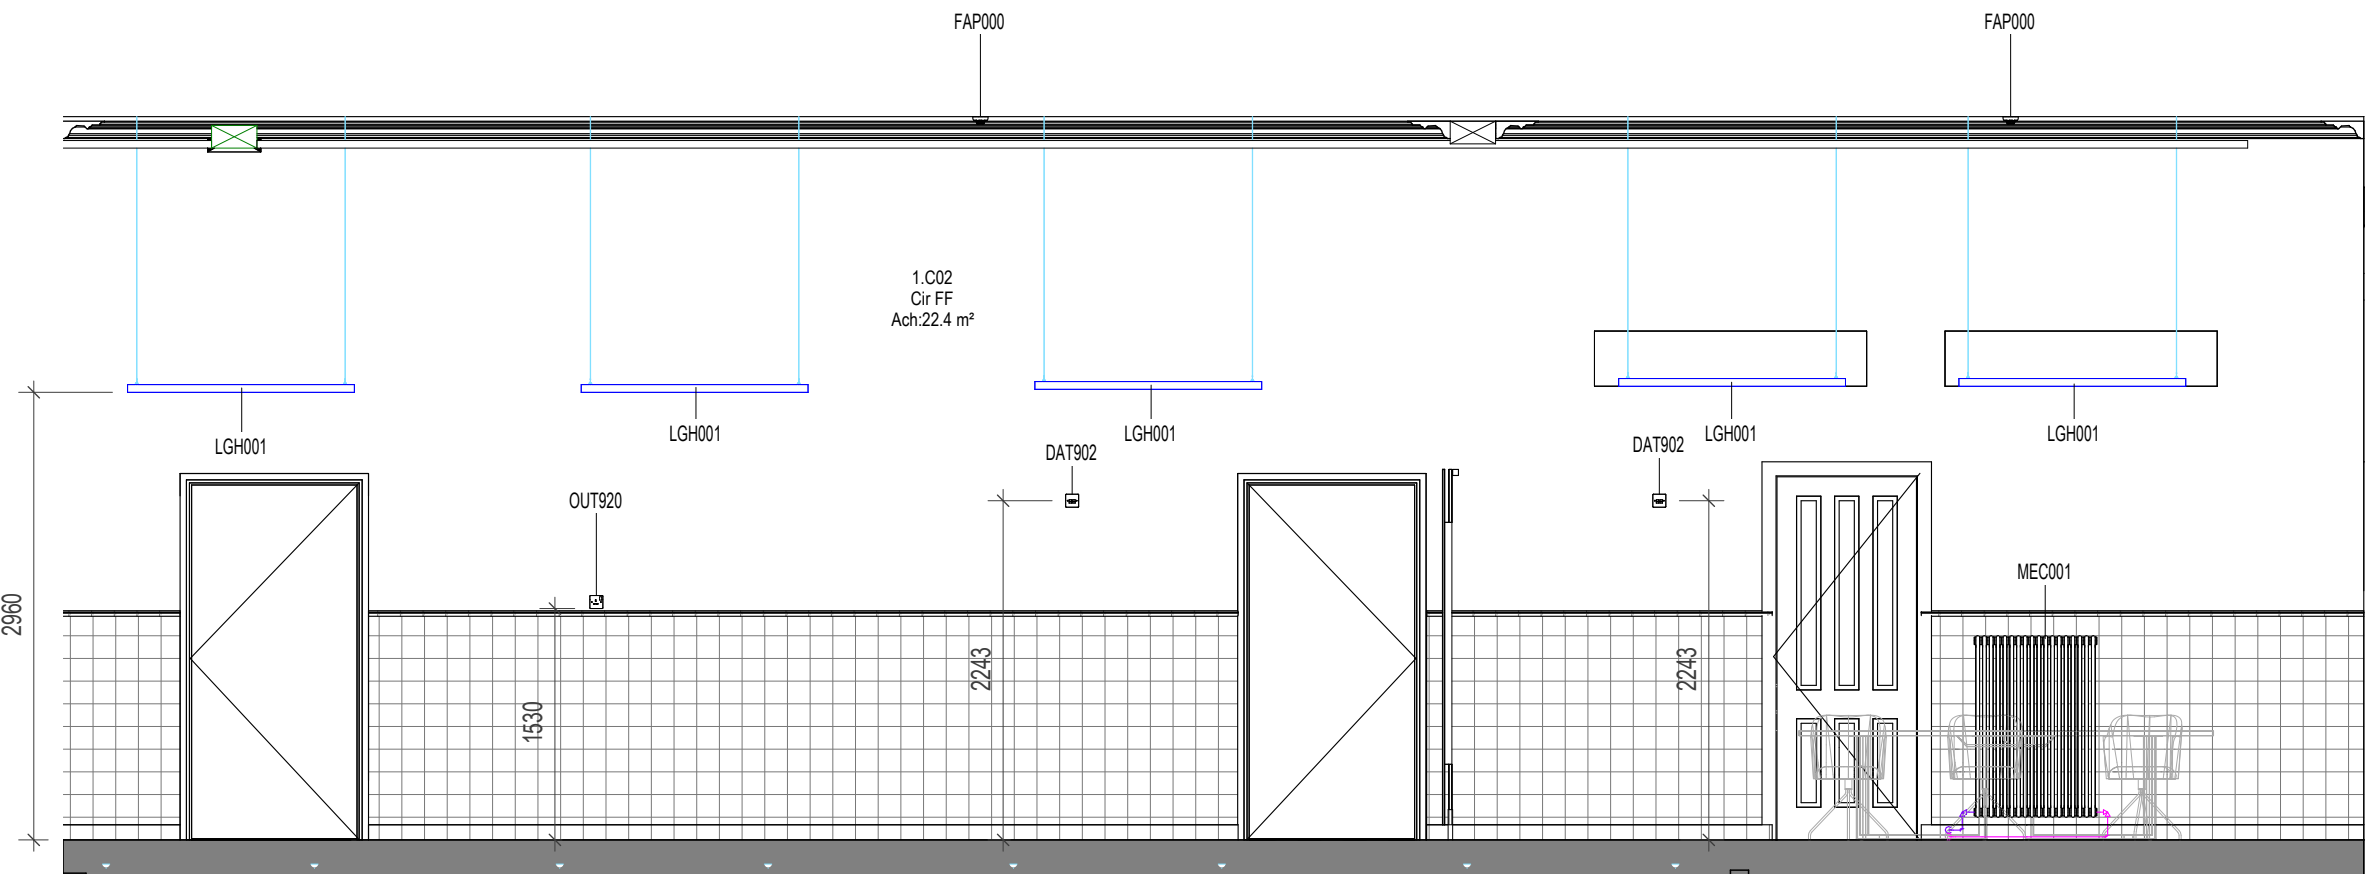


5 ELEVATION 5
1 : 50

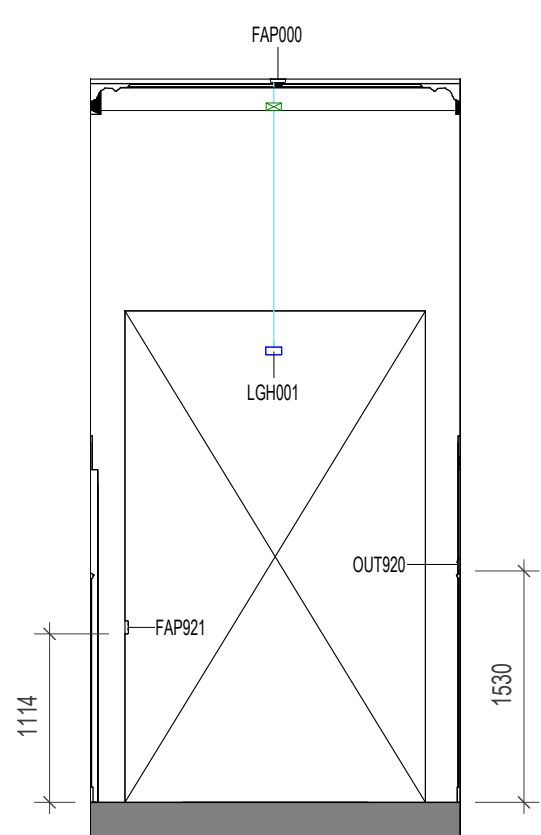


4 ELEVATION 4
1 : 50

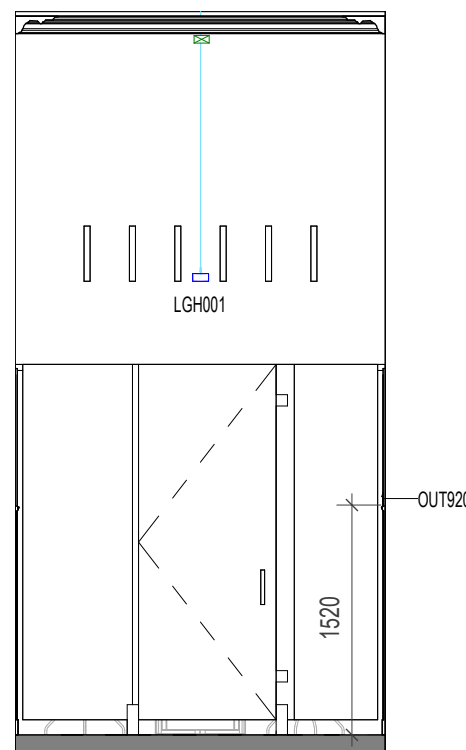


6 ELEVATION 6
1 : 50

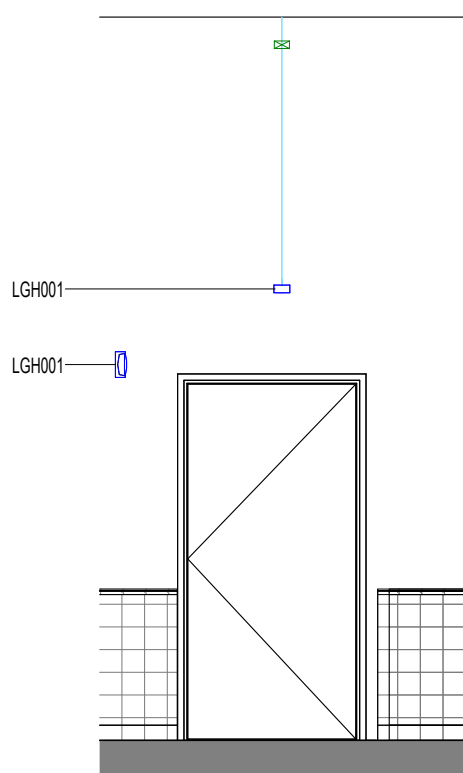


7 ELEVATION 7
1 : 50

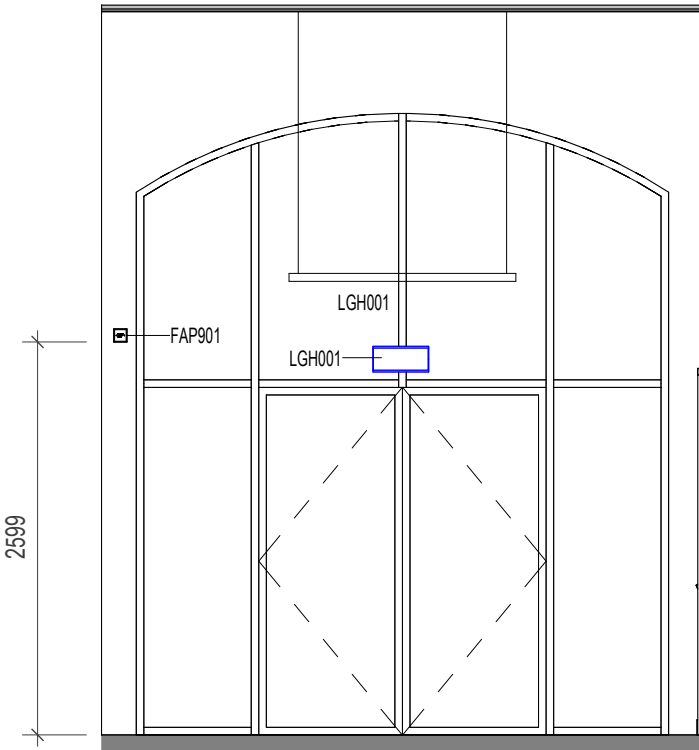

10 ELEVATION 10
1 : 50

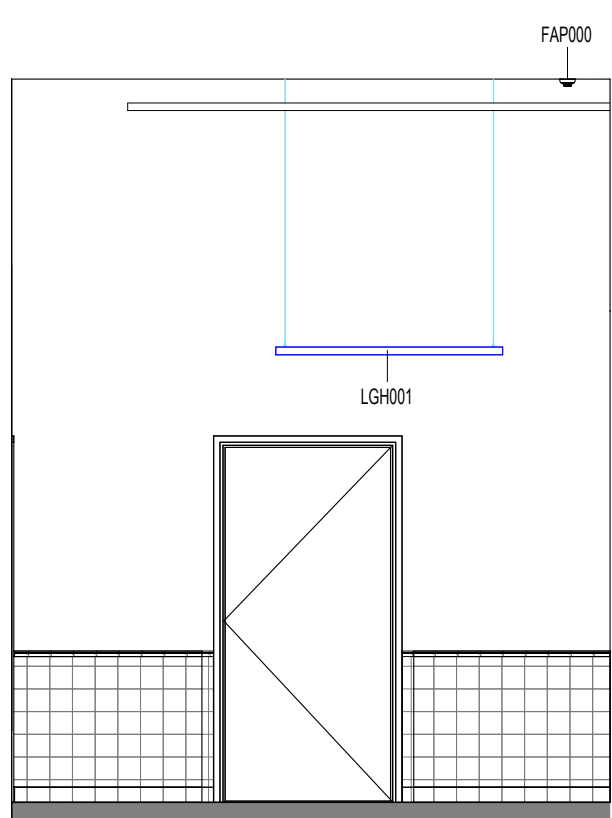

8 ELEVATION 8
1 : 50

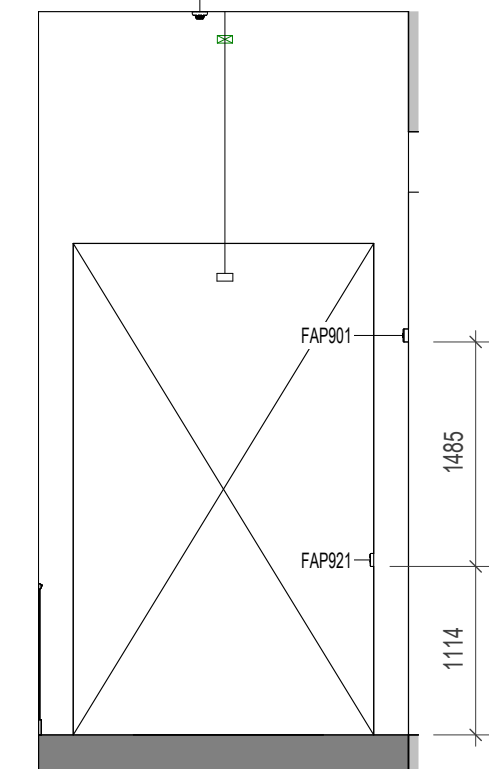

9 ELEVATION 9
1 : 50

Notes:
• This drawing is copyright.
• Do not scale dimensions from this drawing.
• This drawing is to be read in conjunction with all other relevant drawings.
• All discrepancies on this drawing are to be reported to the architect.
• Do not modify any element of this drawing.
• Use drawing only for purpose(s) issued.
• This drawing may contain colour.
Scale Bar

North Point

Key Plan

The following external model files are included within this drawing:

P4	2024/12/17	C-sheets issued to contractor	AB	RM
P3	2024/12/13	C-sheets issued to MCC	AB	RM
P2	2024/07/26	C-sheets issued to MCC	AB	RM
P1	2024/07/12	Co-ordination with MEP	AB	RM
Rev	Date	Revision Notes	Drawn	Review

MANCHESTER
1824
The University of Manchester

ARCADIS

Project
Rutherford Building

Drawing Title
1.058 - Meeting FF & Circulation

Job Number 141532	Date	Security Classification	Drawn By AJ
Scale@A1 1 : 50	Purpose LISTED BUILDING CONSENT	Reviewed By AB	Revision P4
Drawing Number 4911-RBUM-ARC-XX-ZZ-DR-A-4911			