


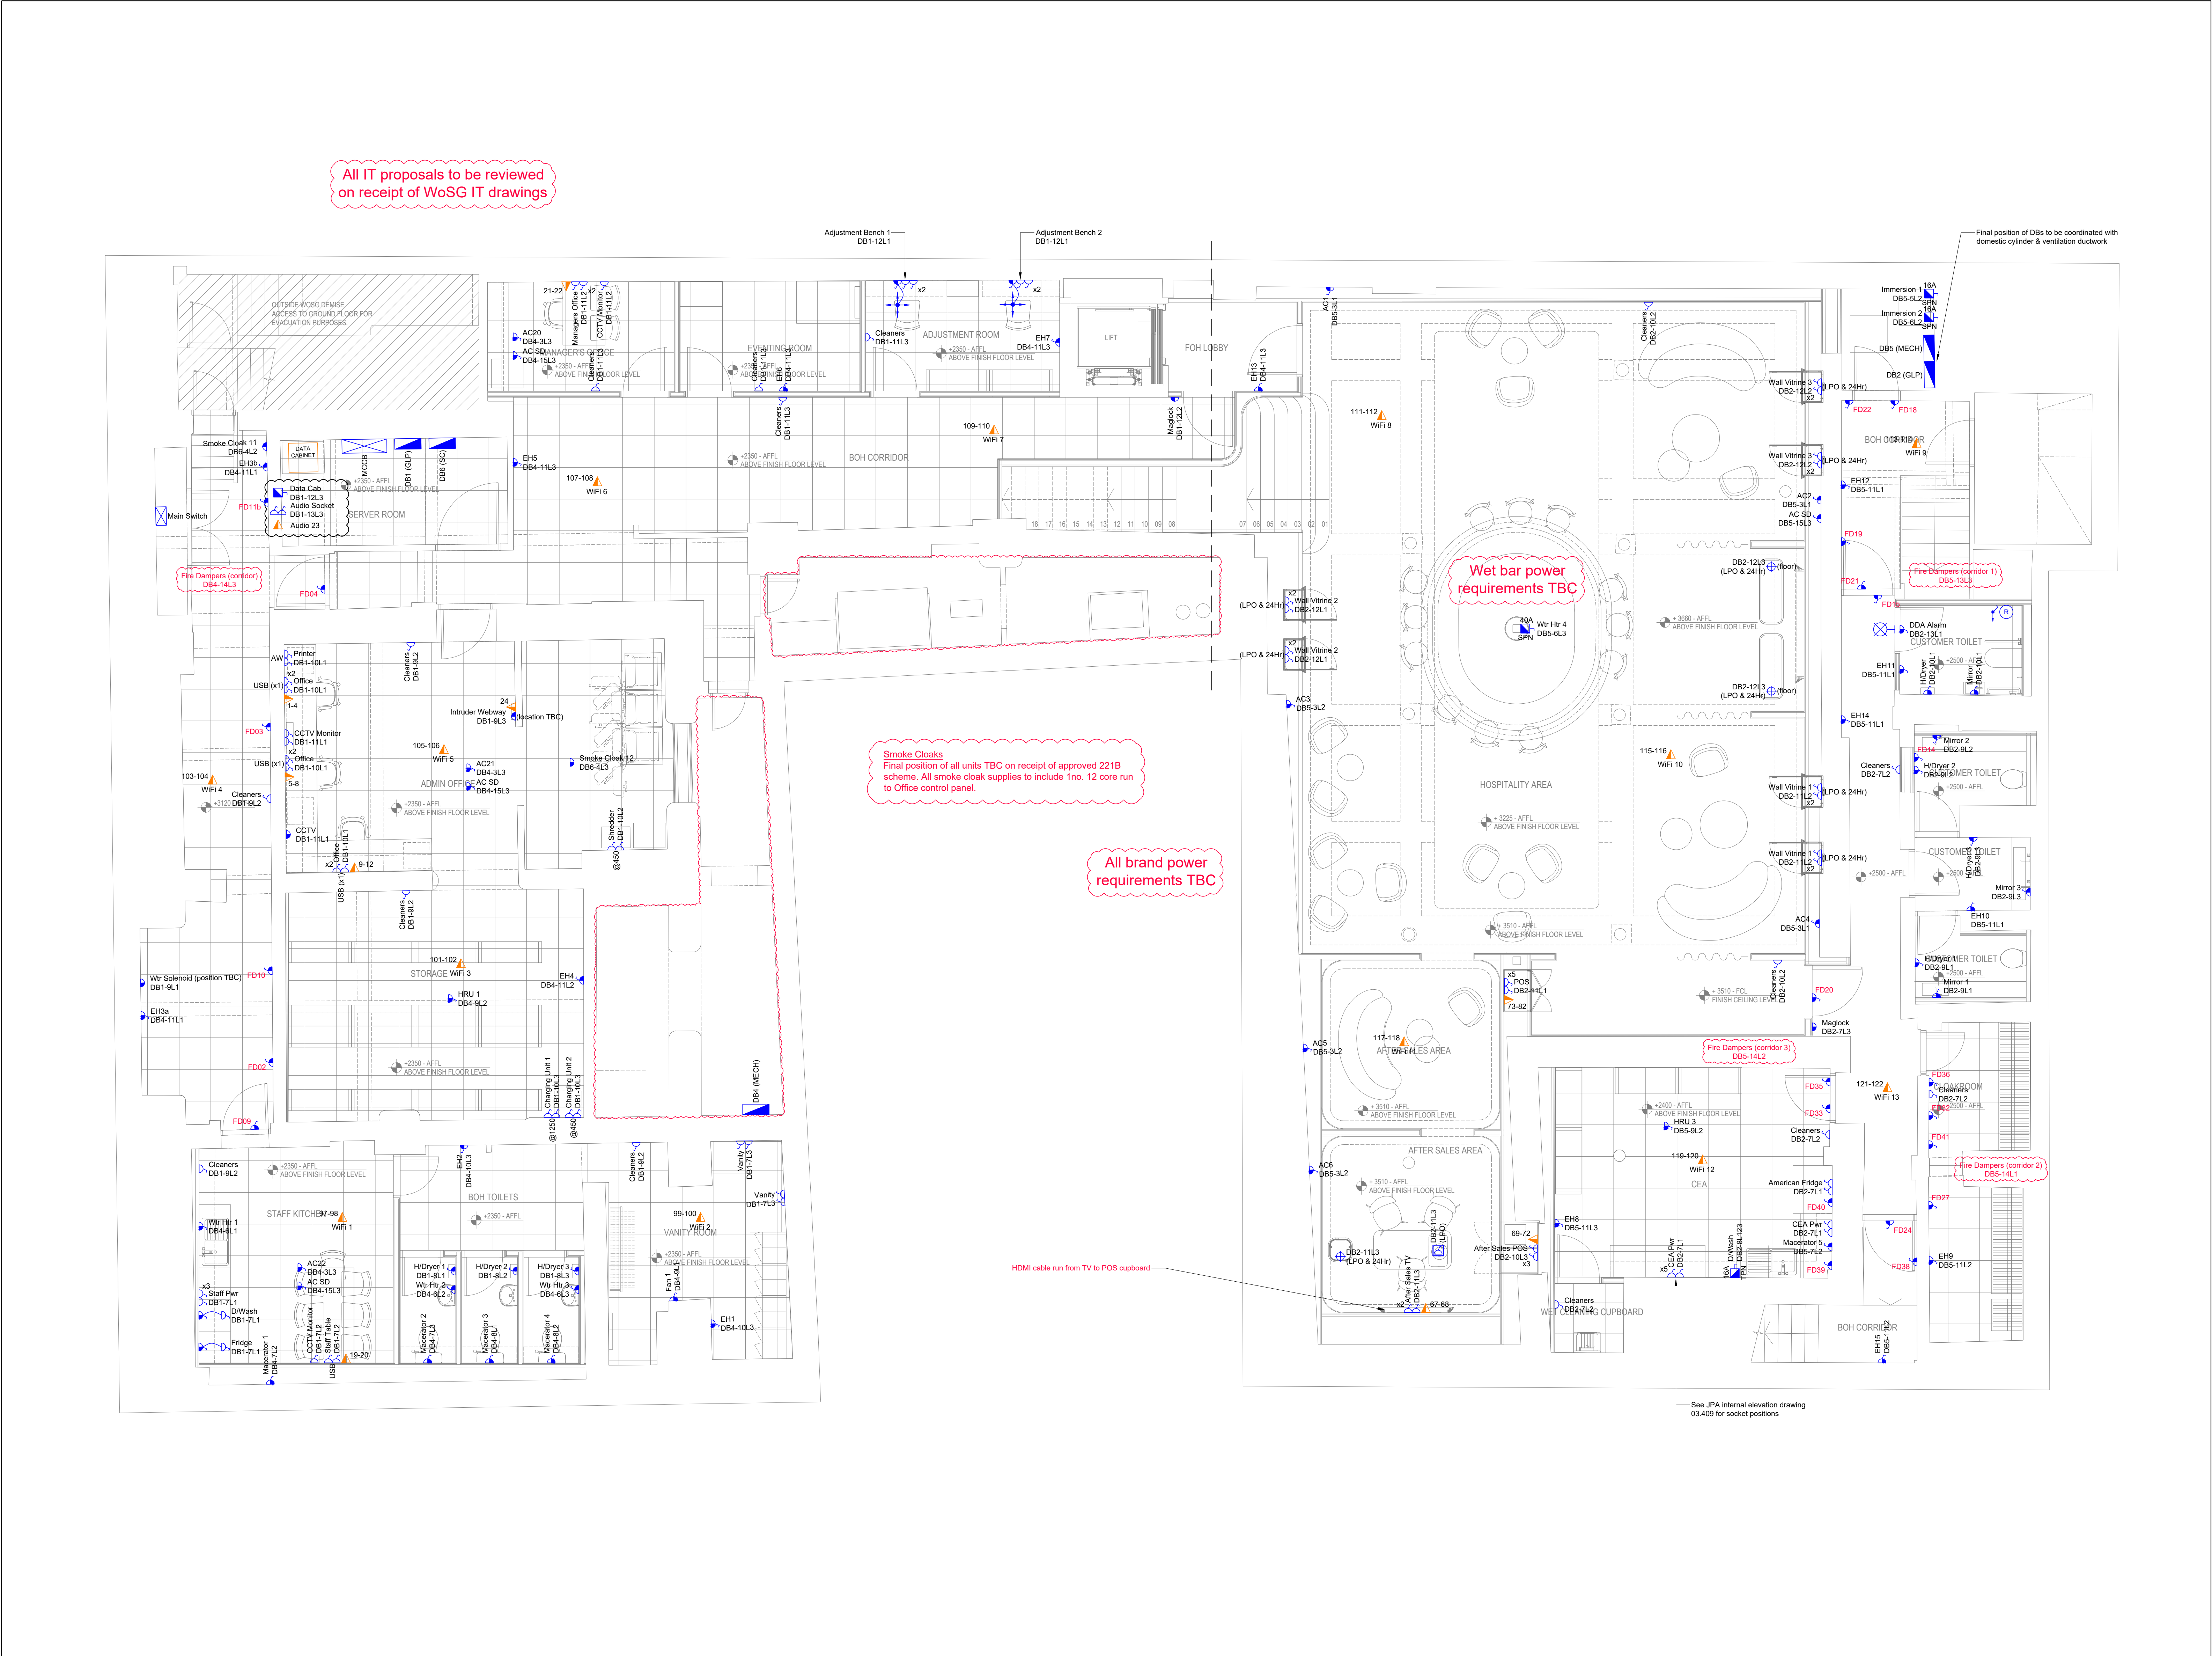

Small Power & Data

Small Power & Data Legend	
Symbol	Description
	Distribution Board
	General 13A Twin Switched Socket
	General 13A Single Switched Socket
	Switched Connection Unit
	Unswitched Connection Unit
	Floor Flex Outlet
	Floor Box
	Task Light JCC/OV LED Floodlight IP65 Aiu 4000k White JCA5200WH
	IP65 Surface Mounted Isolator switch
	Fire Alarm Isolator Switch Key Operated
	DDA Alarm Pull Cord
	DDA Alarm Reset Button
	DDA Alarm Indicator
	Data Cabinet Floor Standing - (final size TBC)
	CAT5e Structured Network Point

OAK COPYRIGHT STATEMENT

This drawing is the property of Oak Electrical Ltd. Copyright is reserved by them and is issued on the condition that it is not copied either wholly or in part without consent in writing from Oak Electrical Ltd.

General Notes:

- This drawing should be read in conjunction with all other relevant project drawings and specifications.
- The system is designed and installed in accordance with all relevant British Standards, Regulations, and Codes of practice and methods of working.
- Any conflict in design is to be highlighted and appropriate action / approval given prior to alterations being carried out.

A	24/09/24	Smoke cloak supplies added	AC	BP
Rev	31/08/24	First Issue	AC	BP
Rev	Date	Description	By	CHK

FOR APPROVAL

Oak Electrical
BUILDING SERVICES ENGINEERS

Werner Court, Blue Ridge Park, Glasshoughton
(M62 - J22) Castleford, West Yorkshire
Telephone: (01977) 55 55 92 Fax: (01977) 55 52 46
● CASTLEFORD ● BIRMINGHAM
www.oak-electrical.com info@oak-electrical.com

Client:
Watches of Switzerland Group
2 Elland Road
Braunstone
Leicester, LE3 1TT

Project:
Mappin & Webb
17-21 St Anns Square
Manchester
M2 7PW

Drawing Title:
ELECTRICAL SERVICES
E02.1 - Small Power & Data Layout - Basement

Drawing No	Revision
C3016 - 24 - E - 02.1	A
Scale: 1:50 @ A0	Date: SEP 24
Engineer: AC	Checked: BP