


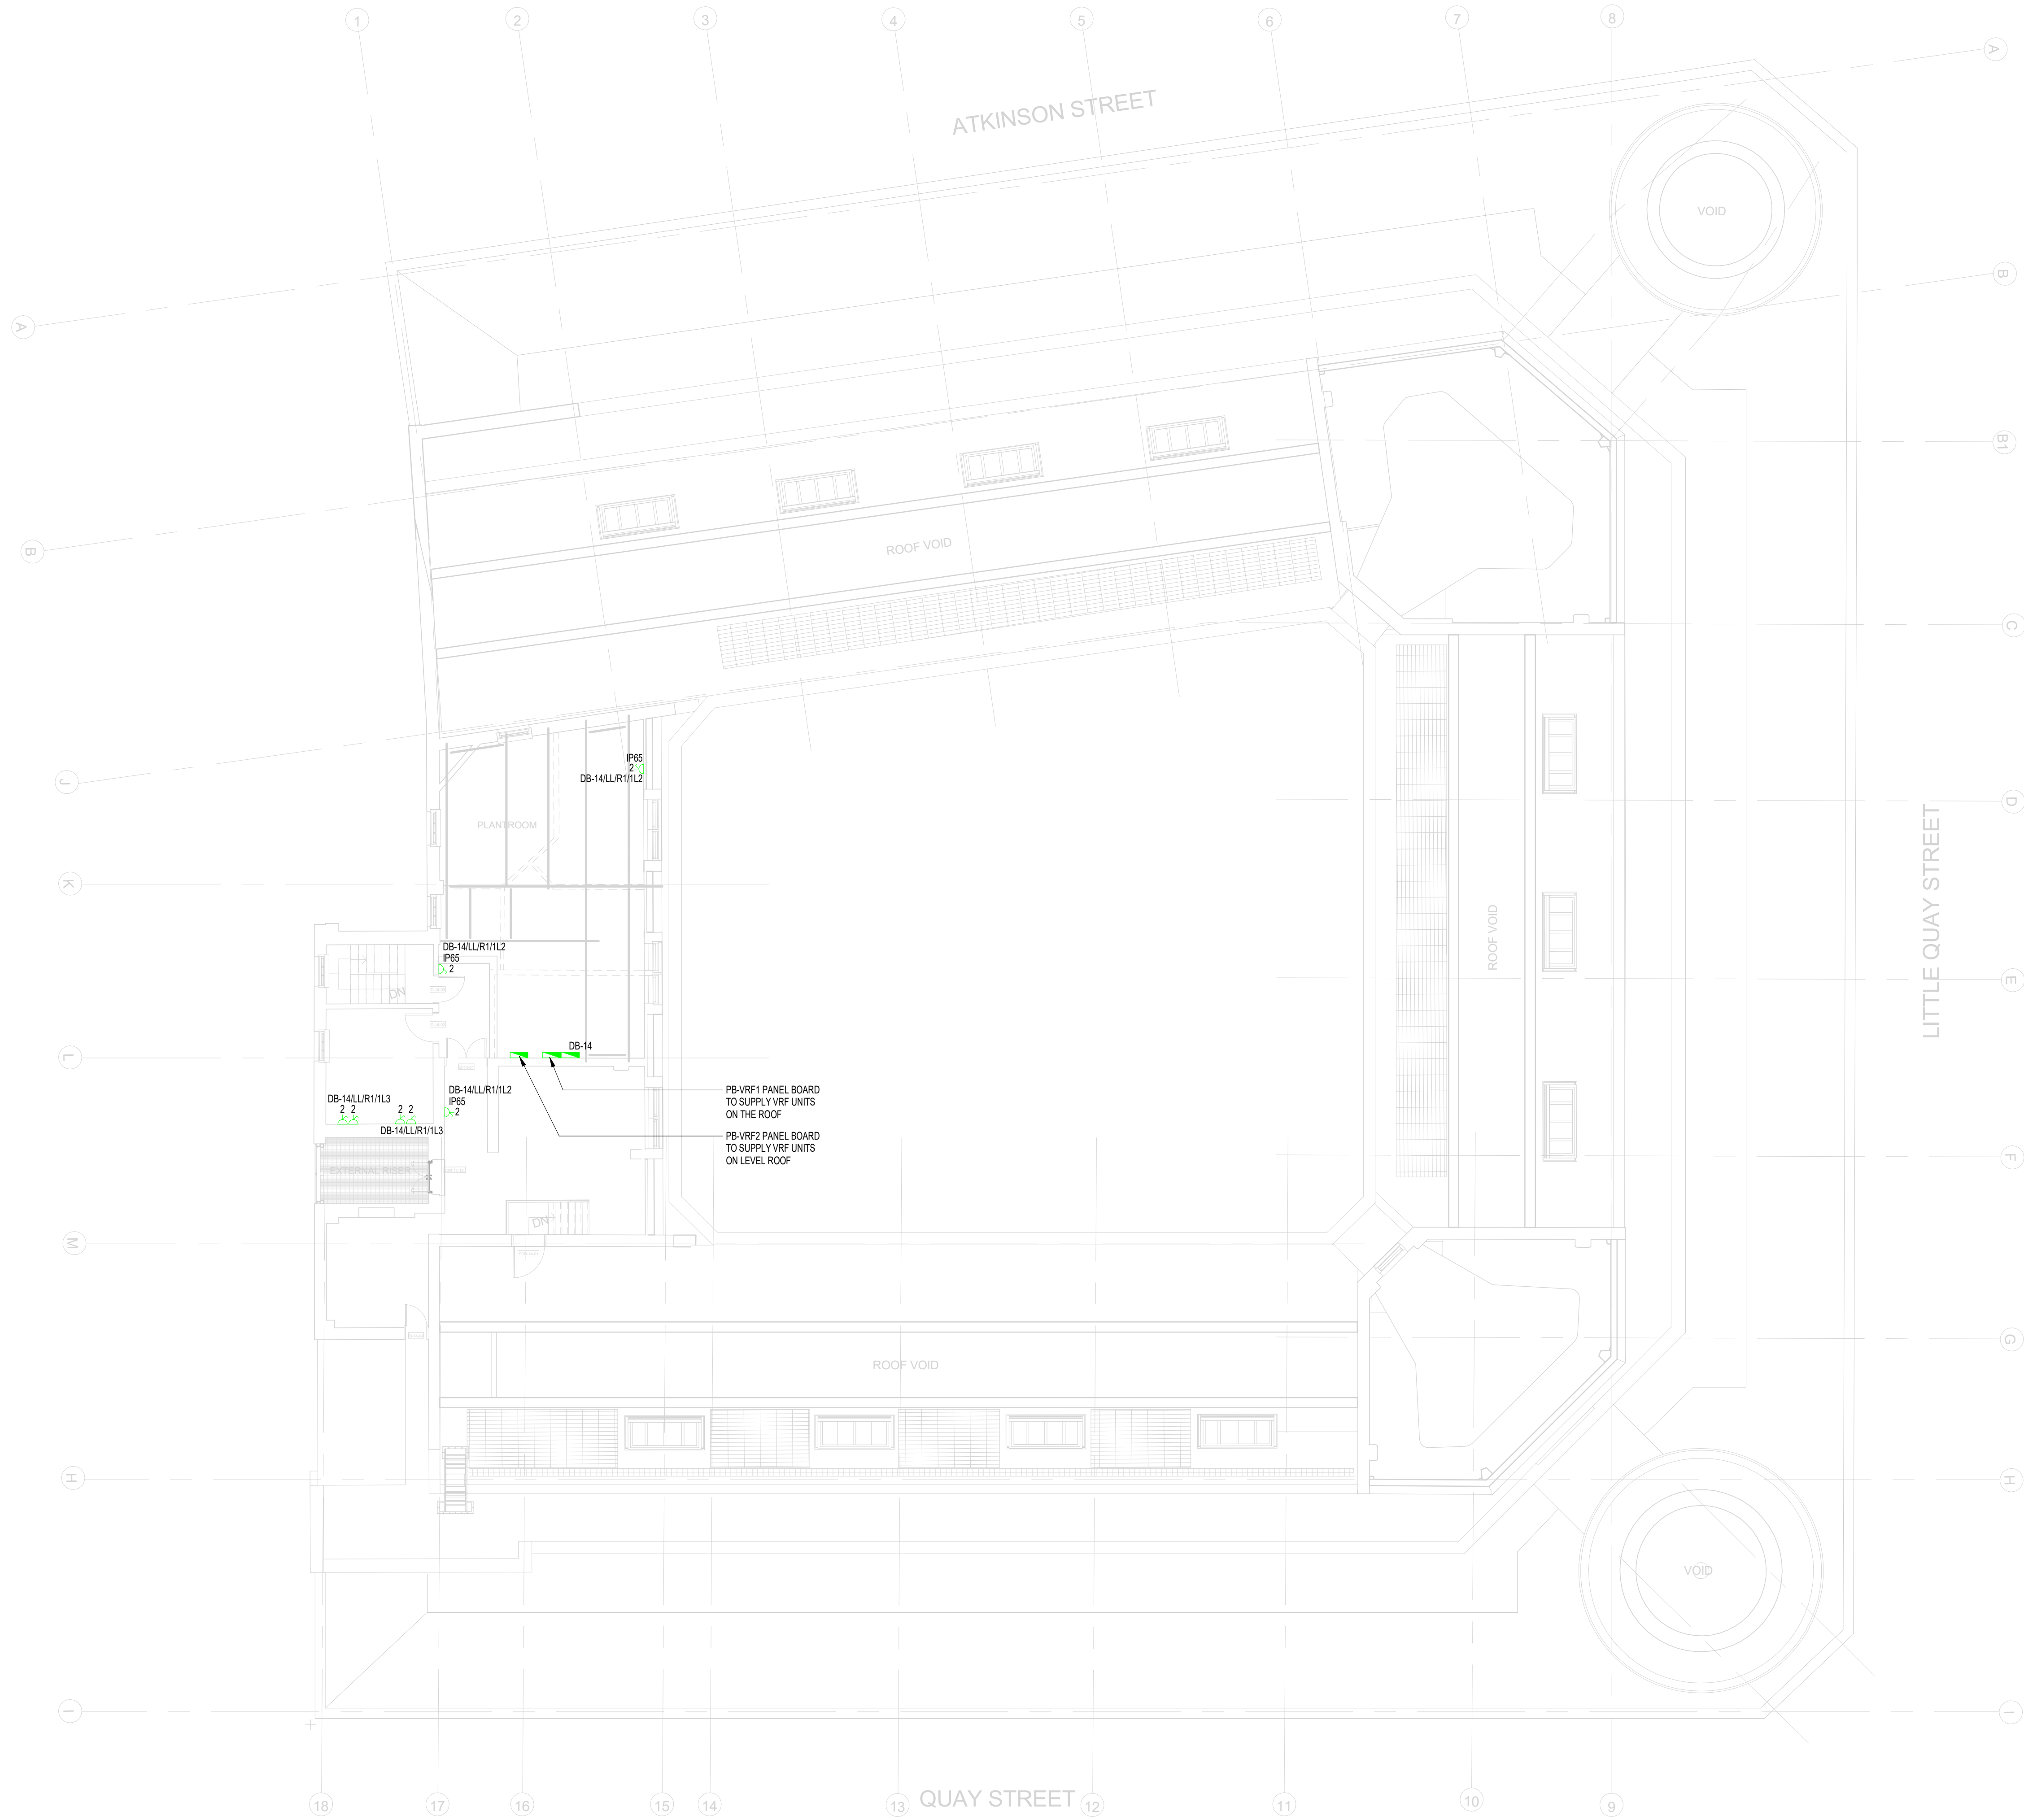

ABBREVIATIONS:	
HD	HAND DRYER
EF	EXTRACT FAN
CV	CEILING VOID
EPH	ELECTRIC PANEL HEATER
ST	SENSOR TRAP
CLN	CLEANERS SOCKET
FS	FLOW SWITCH
FCU	FAN COIL UNIT
AC	ACCESS CONTROL
EGR	ELECTRIC CONTROL RADIATOR
WH	WATER HEATER
DP	DRAIN PUMP
LL	MOUNTED AT LOW LEVEL
ML	MOUNTED AT MID LEVEL
HL	MOUNTED AT HIGH LEVEL
DAS	DISABLE ALARM SYSTEM
EAC	ELECTRIC AIR CURTAIN
HT	HOT WATER TAP
FSN	FIBRE SPLITTER NODE
BC	BRANCH CONTROLLER
FR	FRIDGE
MW	MICROWAVE
WT	WORK TOP (FOR KITCHENETTES)
BWT	BELOW WORK TOP (FOR KITCHENETTES)
DW	DISH WASHER

THIS DRAWING IS FOR INFORMATION ONLY DO NOT SCALE

CDM REGULATIONS

HAZARD	DATE ASSESSED	DATE INITIATED	DATE ASSESSMENT

LEGEND

SPIN DISTRIBUTION BOARD

TPAN DISTRIBUTION BOARD

MAIN SWITCH BOARDLY PANEL

UNSWITCHED 13A SINGLE SOCKET OUTLET

UNSWITCHED 13A TWIN SOCKET OUTLET

SWITCHED 13A SINGLE SOCKET OUTLET

SWITCHED 13A TWIN SOCKET OUTLET

CLN DENOTES CLEANERS SOCKET

UNSWITCHED FUSED CONNECTION UNIT

SWITCHED FUSED CONNECTION UNIT

SWITCHED FUSED CONNECTION UNIT

SWITCHED FUSED CONNECTION UNIT

RED DP 13A FUSED CONNECTION UNIT

DOUBLE POLE ISOLATING SWITCH (20A)

THREE POLE ISOLATING SWITCH

3 POLE ISOLATOR

SPIN ISOLATOR

TPAN ISOLATOR

RJ45 DATA OUTLET POINT

TELEPHONE OUTLET POINT

COOKER CONNECTION UNIT

AUDIOVISUAL PLATE

DADO TRUNKING

HDMI

HDMI PORT

DADO DROPPERS

EMERGENCY STOP BUTTON

1 No. TWIN SWITCHED SOCKET & 2 No. DATA OUTLETS (2 COMPARTMENT FLOORBOX)

DISABLED ALARM PULL CORD SWITCH

RESET PUSH BUTTON

DISABLED ALARM INDICATOR LAMP

3 COMPARTMENT DADO DROPPER

DISTRIBUTION UNIT BOX

CLEANERS SOCKET FLOOR GORMET

SOCKET & 2No. DATA OUTLETS (4 COMPARTMENT FLOORBOX)

UNSWITCHED FUSE SPUR FOR FIRE CURTAIN

CLG-131 SUSPENDED PLASTERBOARD

63A UNDERFLOOR BUS BAR POWER TRACK

FIBRE SPLITTER NOOE

SMART METER

MID METER

WIFI AP

BOOSTER PUMP

INVERTER

REV	DATE	ISSUED FOR COMMENT & APPROVAL	SB	SH
REV	DATE	AMENDMENTS	BY	CHK

FOR COMMENT & APPROVAL

Commercial Services Design Ltd

Unit 5
Woodside Court
Claydon Wood Rise
LE11 1B
Tel: 0113 3223190
Web: www.csdesign.co.uk

G&H

GROUP OF COMPANIES

CLIENT
G&H BUILDING SERVICES

PROJECT
SUNLIGHT HOUSE
LITTLE QUAY STREET
MANCHESTER M3 3HP

TITLE
ELECTRICAL SERVICES SMALL POWER AND DATA LAYOUT
LEVEL 14

SCALE @ 1:100	CDR REF: CSD 1298
DRAWN: MW	ENGINEER: DB
STARTED: AUGUST 24	ISSUED: AUGUST 24
DESIGNED: DB	APPROVED: BW

1298-CSD-XX-14-DR-E-6215

P01

Project Originator: Valued Local Type-Designer: Drawing Number

This drawing is the property of Commercial Services Design Ltd. It is not to be used for any other purpose without the written consent of Commercial Services Design Ltd. It is not to be used for any other purpose without the written consent of Commercial Services Design Ltd. It is not to be used for any other purpose without the written consent of Commercial Services Design Ltd.

ARCHITECTURE IS BASED ON MANOLY DESIGN
ARCHITECTS DRAWING NO. SL-H-AND-PO-14-DR-A-05114
(030) LEVEL 14 PLAN
REVISED 03.08.2024