



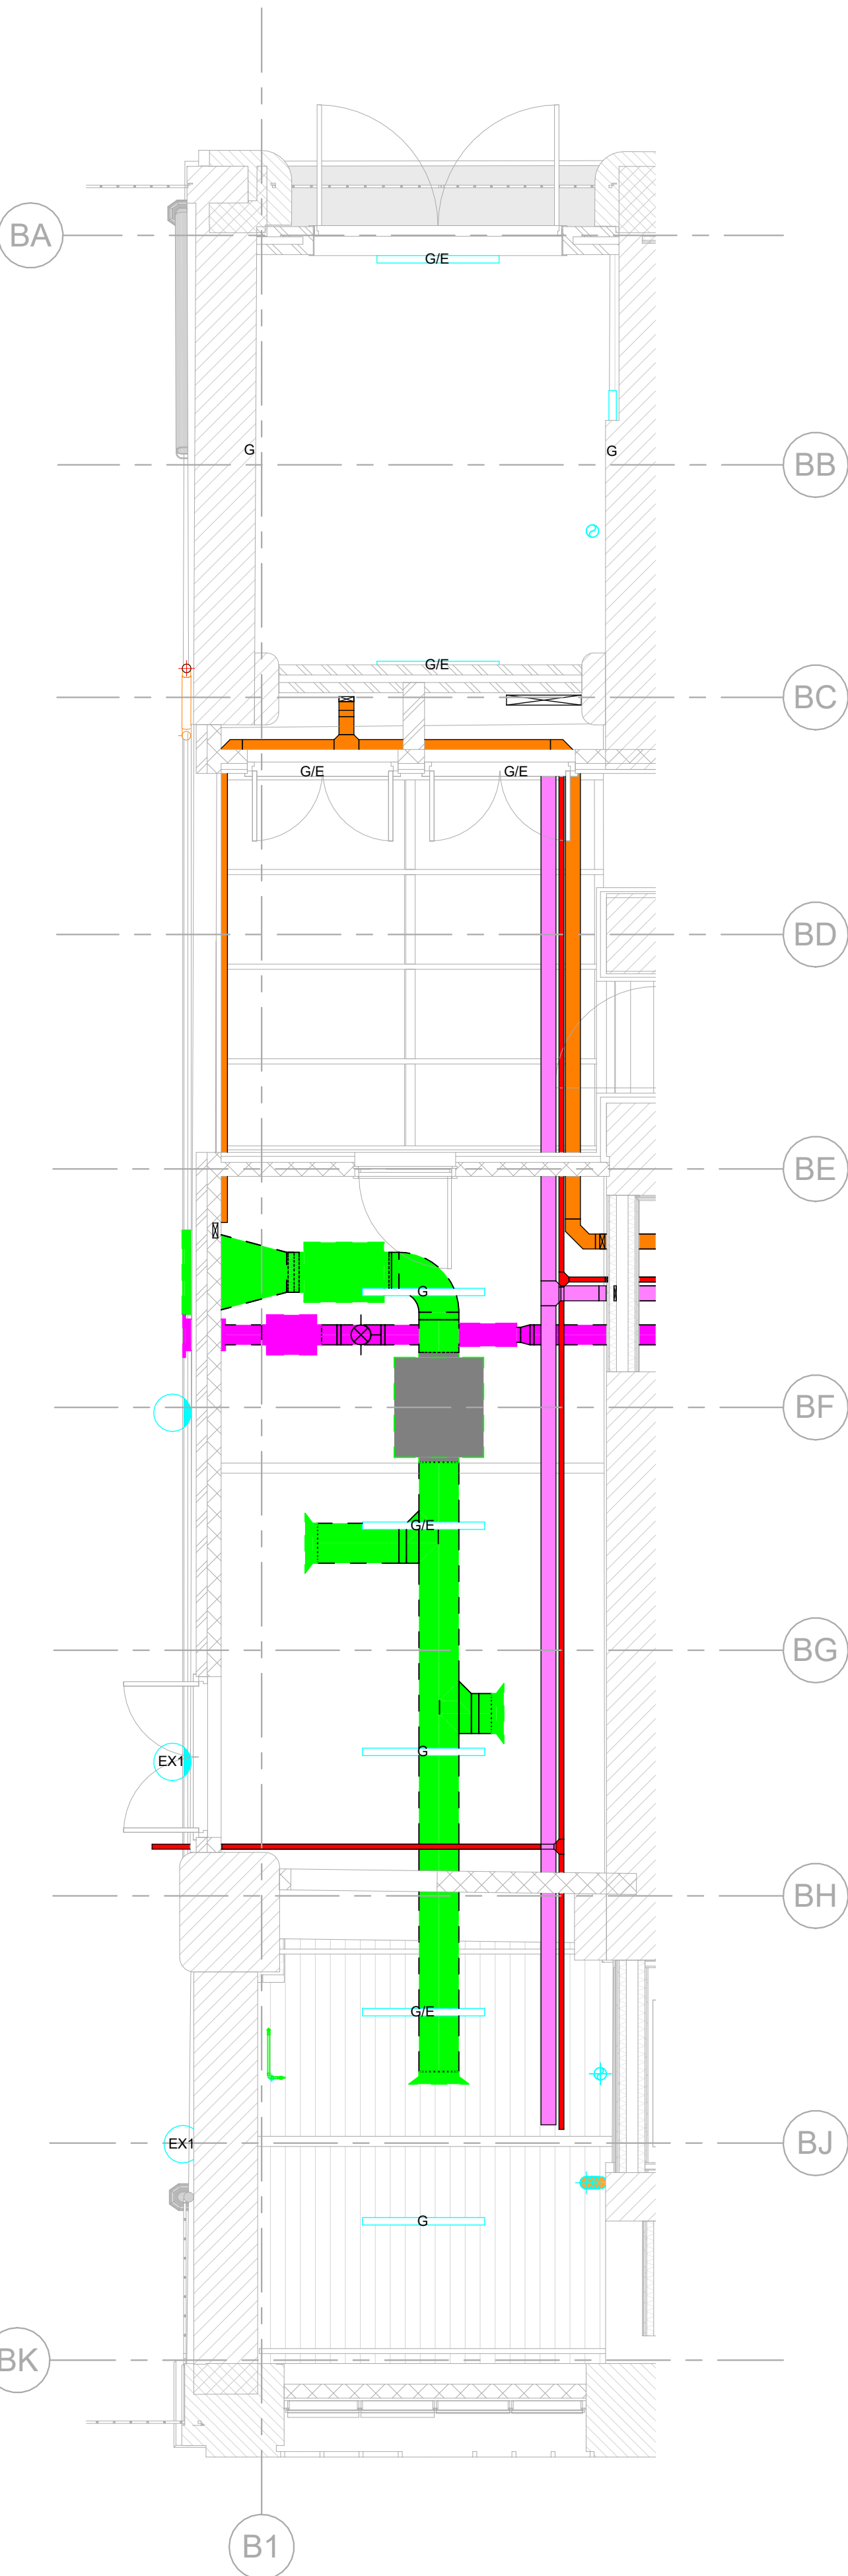

2 5-6-Z2-00 RCP
1 : 50

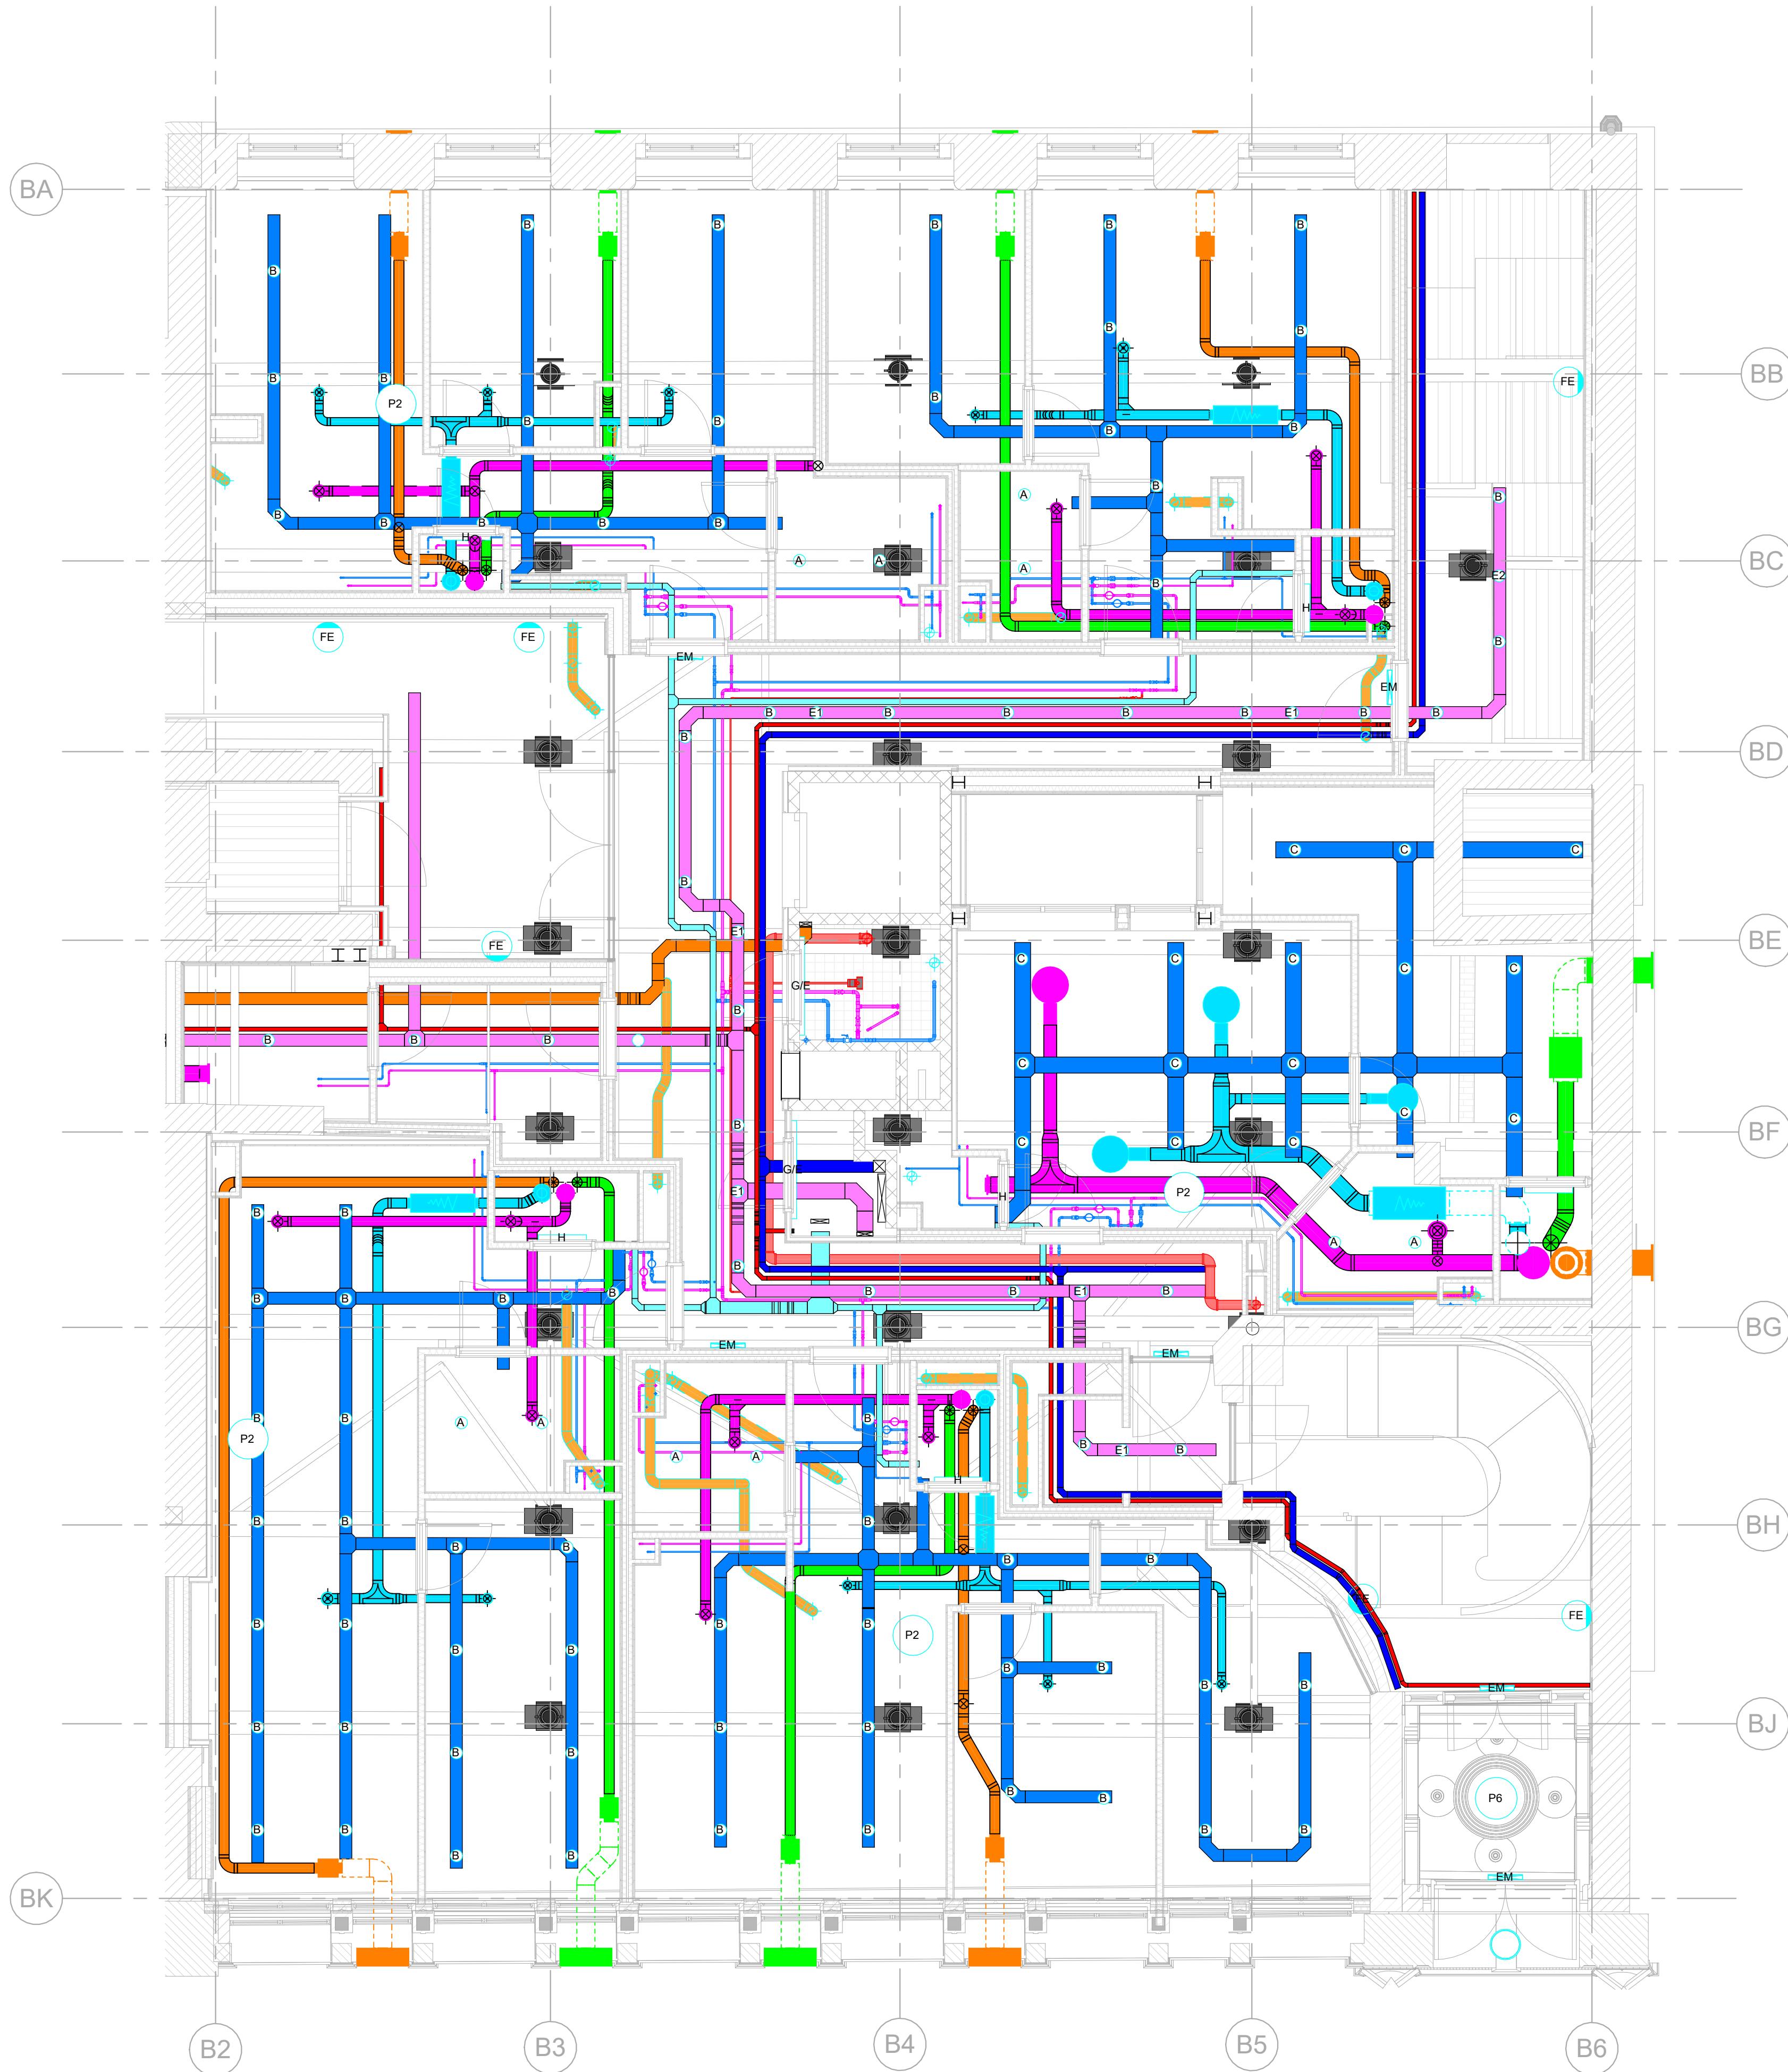

1 5-6-Z1-00 RCP
1 : 50

CONTAINMENT LEGEND

- Data Trunking
- Fire Alarm Tray
- Landlord L&SP Tray
- Tenant L&SP Tray c/w Divider
- Tenant Submain Tray
- Life Safety Submain Tray
- Primary Submain Ladder

VENTILATION LEGEND

- Fresh Air Intake Duct (FAI)
- Supply Air Duct (SD)
- Extract Duct (ED)
- Exhaust Air Duct (EX)

WATER SERVICES LEGEND

- Mains Water Supply (MWS)
- Domestic Hot Water Supply (HW_F)
- Domestic Hot Water Return (HW_R)
- Boosted Cold Water Supply (BCW)

28/11/2024	Revised Based on Updated Arch Model	P03	MS/UR
28/06/2024	Revised to Suit Design Team Comments	P02	UR
14/06/2024	Issued for Tender	P01	MS

Date	Description	Rev.	By
Revision Description			



Manchester Office
2 Commercial Street
Castlefield
Manchester
M15 4RQ
T: 0161 832 2030
E: hk.manchester@hulley.co.uk

...Making Buildings Work

Project: Piccadilly Warehouse, Bloom Street					
Drawing Title: MEP HIGH LEVEL REFLECTED CEILING PLAN LEVEL 0					
ISO 19650 Drawing Number: 24006-HAK-BS-00-DR-Z-5-601					
Project	Originator	Functional Breakdown	Spatial Breakdown	Form	Discipline
Scale:	As indicated	Creation Date:	14/06/2024		
Revision:	P03	Rev Date:	28/11/2024		
Drawn By:	M.Smith	Checked By:	D.Farrimond		
		Approved By:	P.Metcalf		
Arch Rev:	24006-HFR-BS-ZZ-M3-A-9801_P3				
Struct Rev:	N/A				
Issue Status: TENDER					