
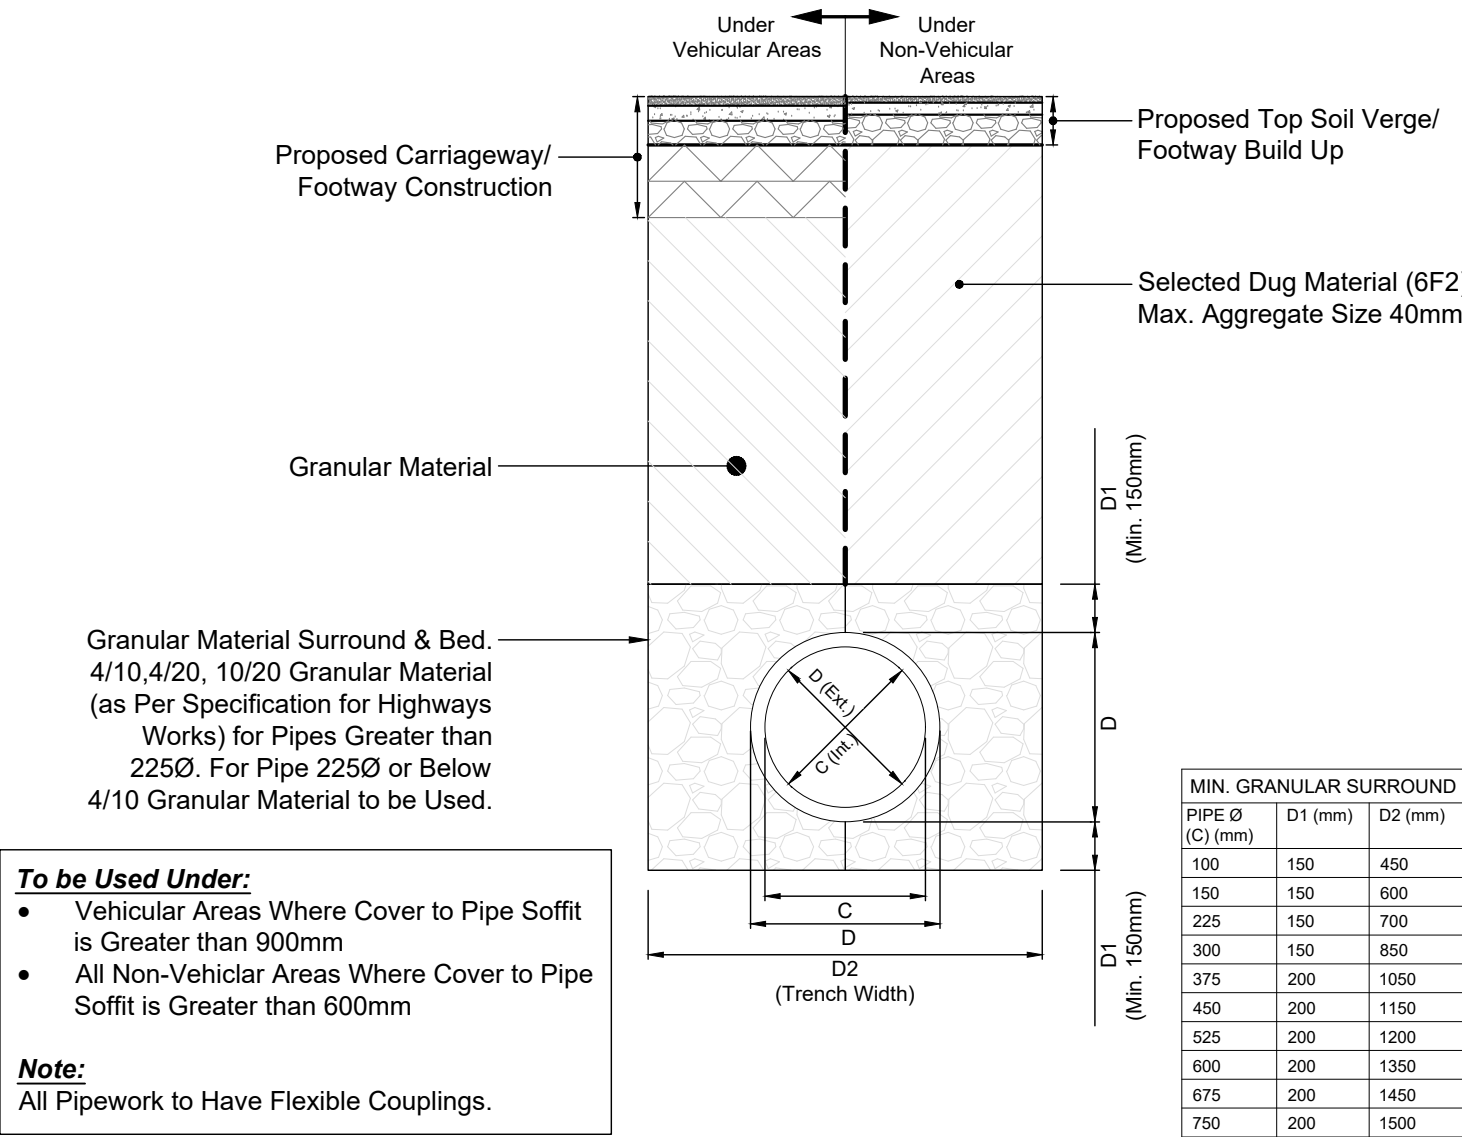
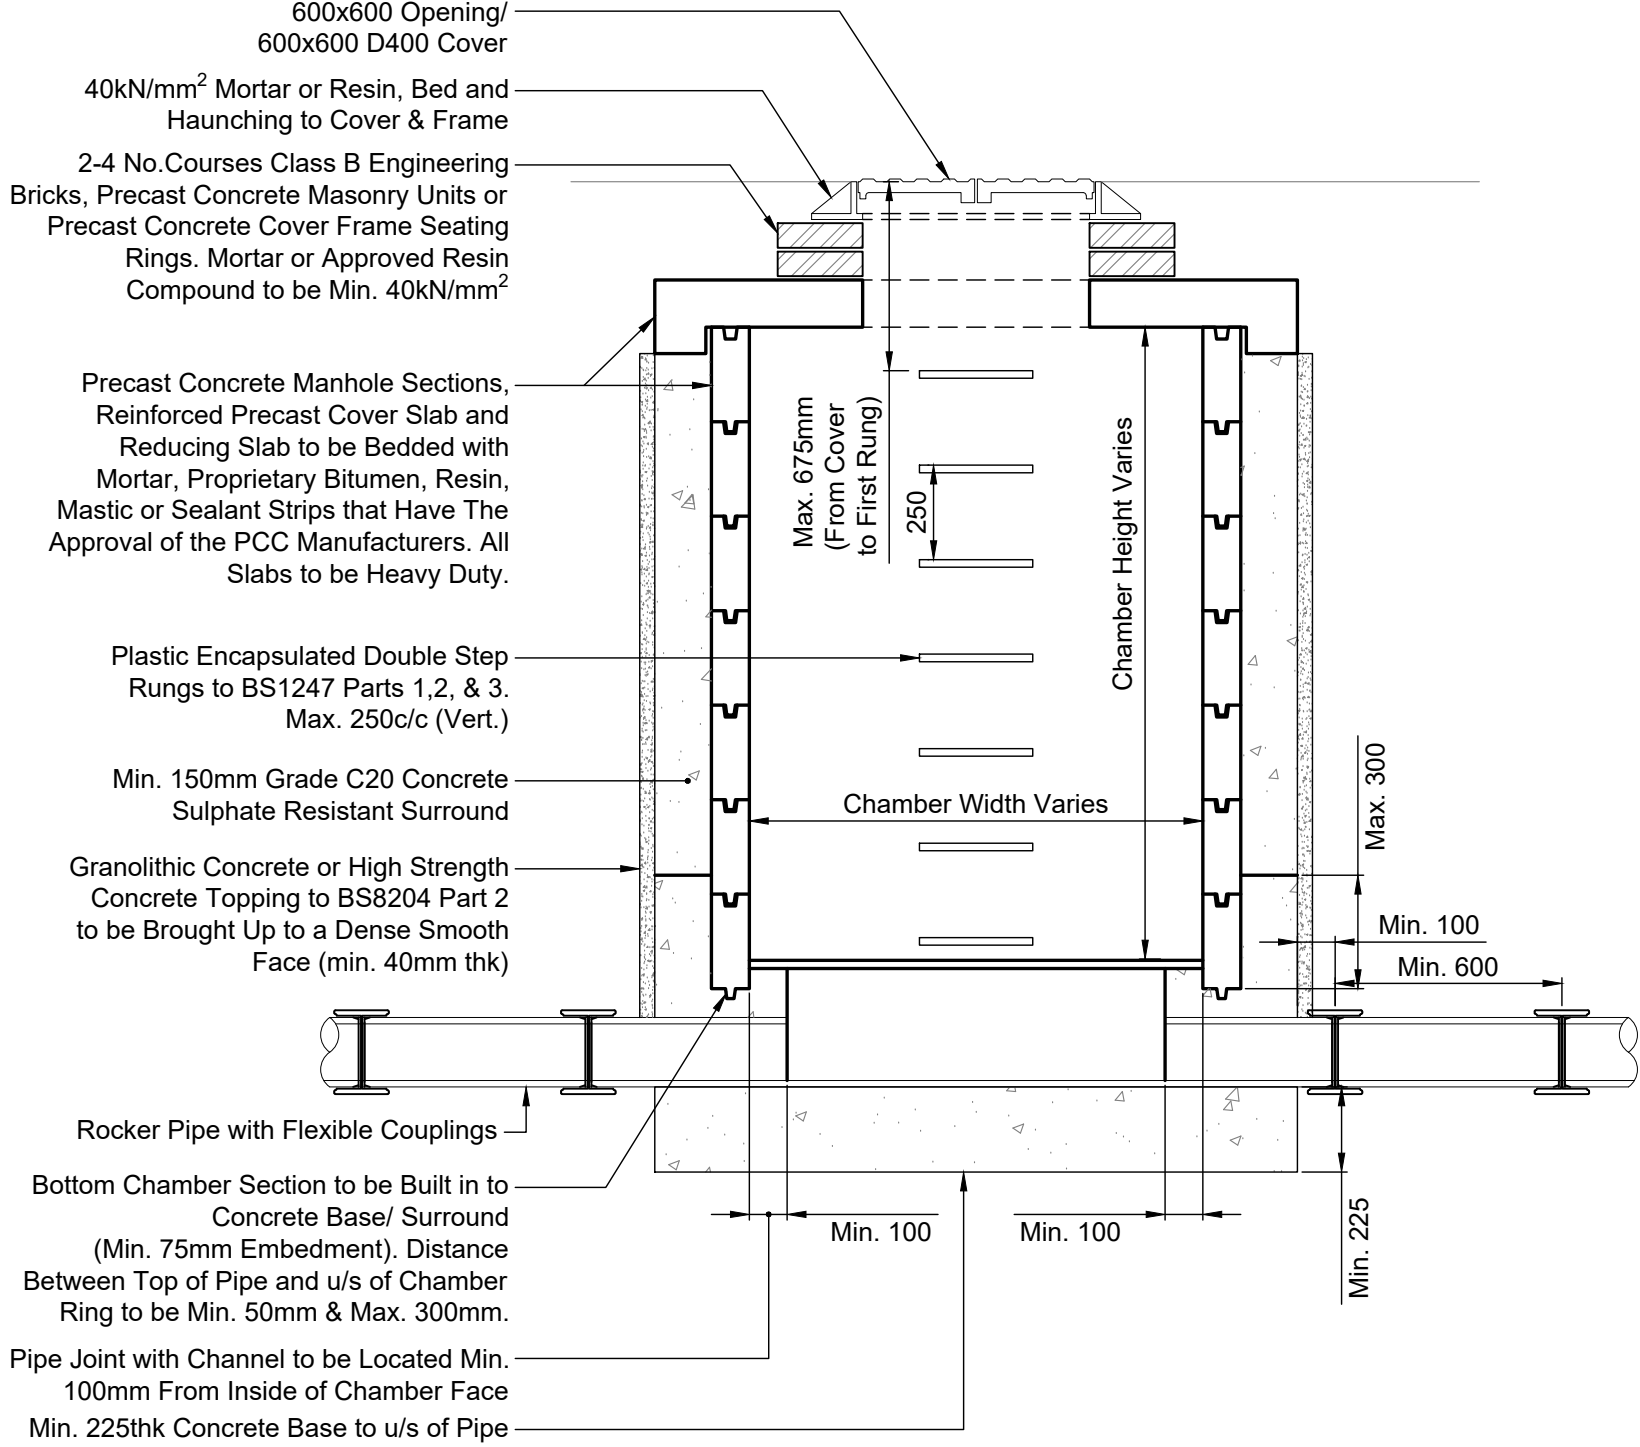
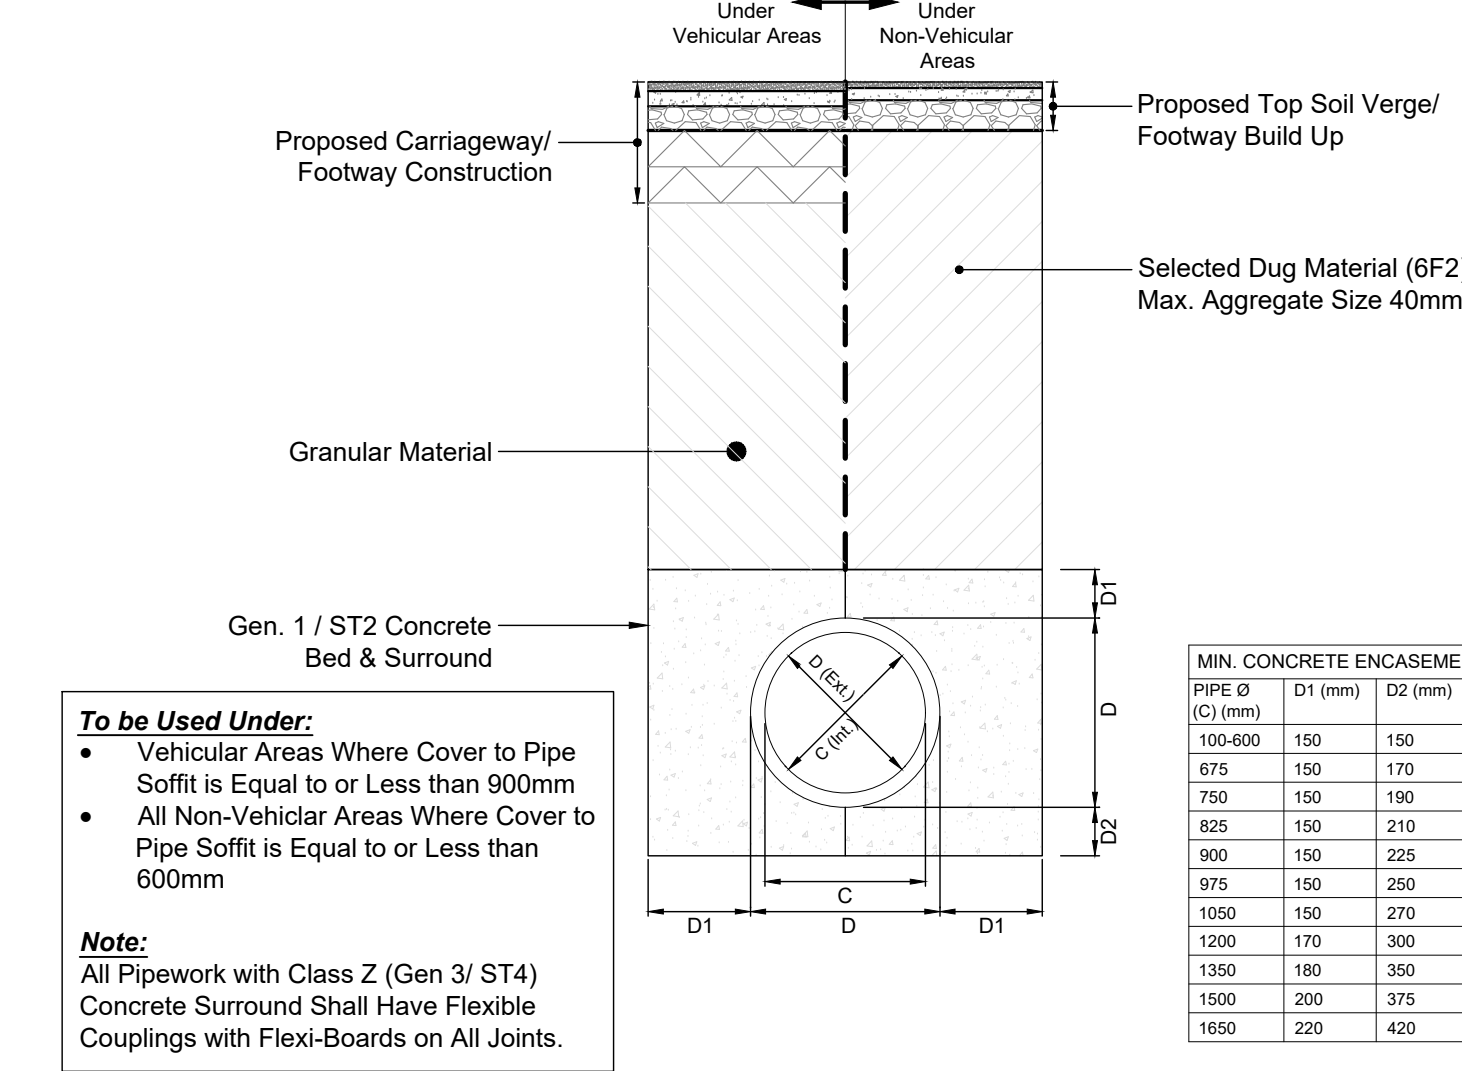
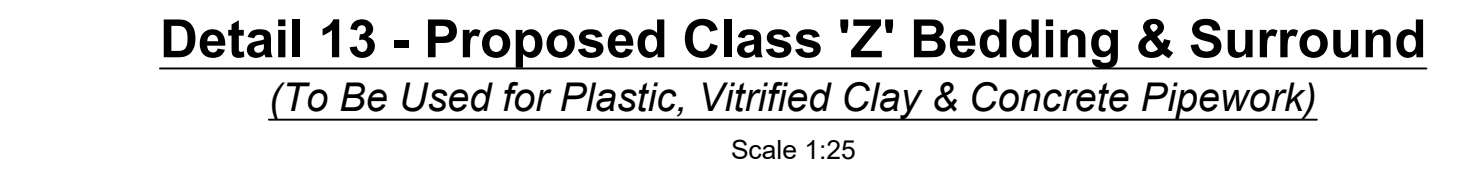
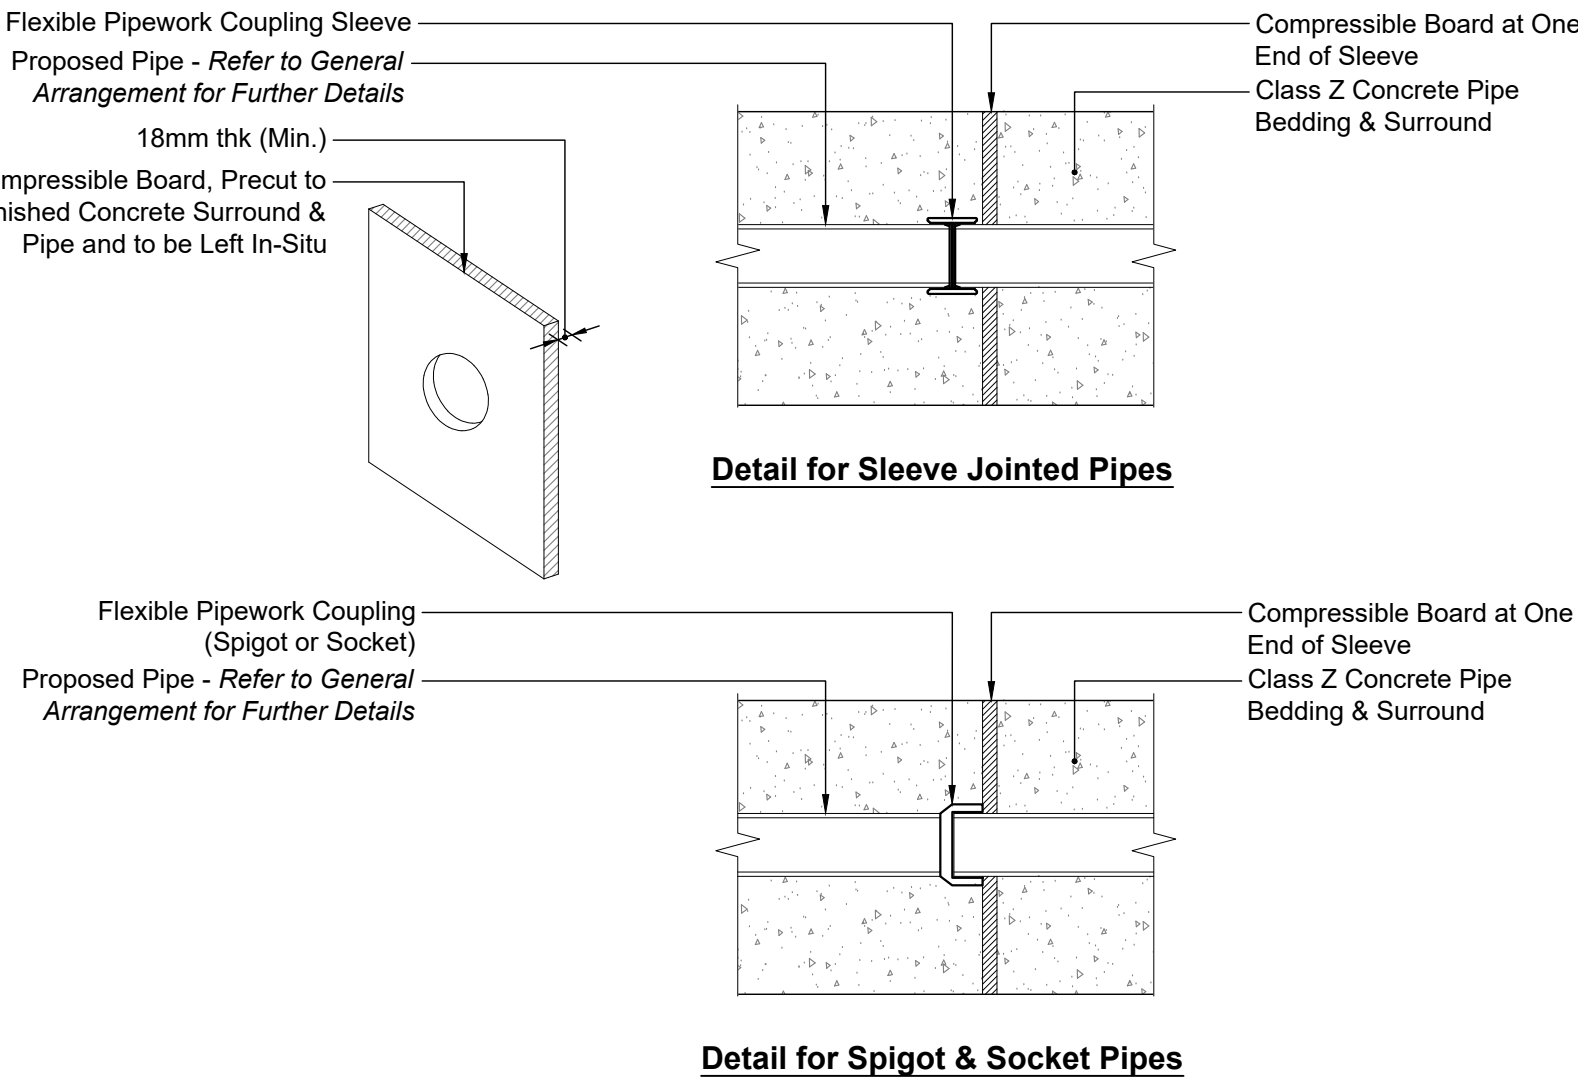


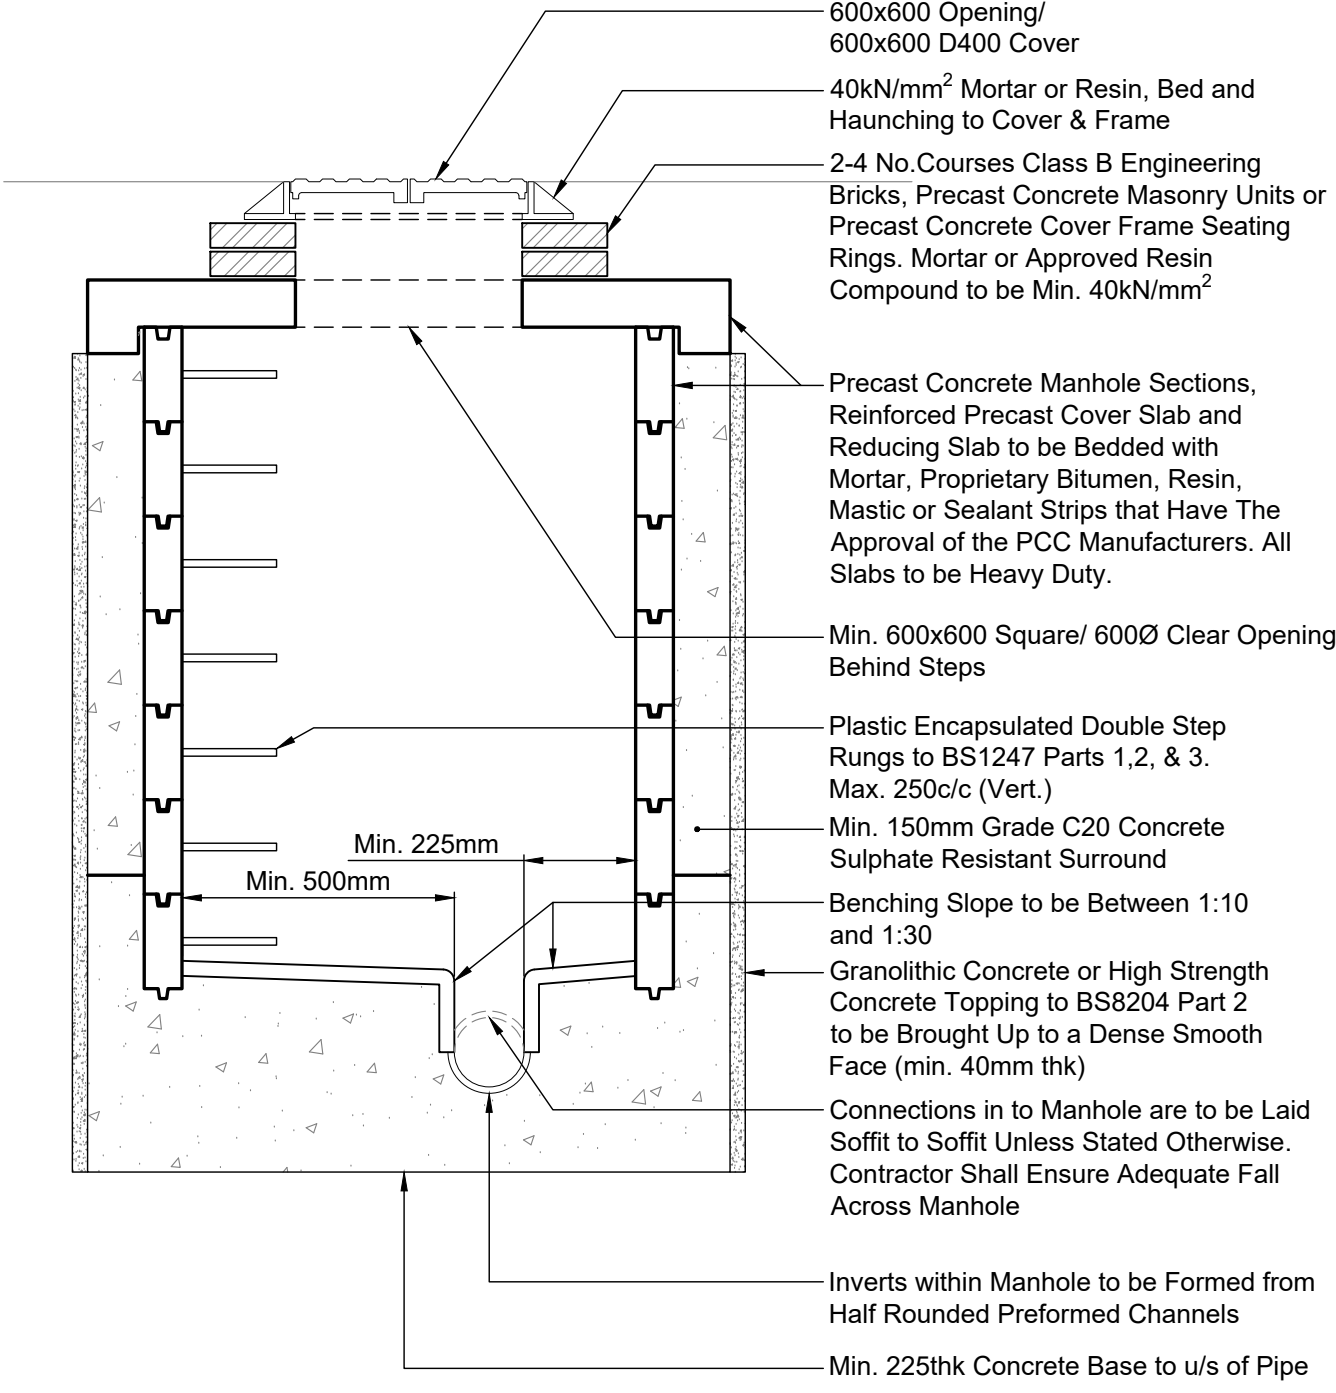

- notes :**
- IF THIS DRAWING HAS BEEN RECEIVED ELECTRONICALLY IT IS THE RECIPIENTS RESPONSIBILITY TO PRINT THE DOCUMENT TO THE CORRECT SCALE
 - ALL DIMENSIONS ARE IN MILLIMETRES UNLESS STATED OTHERWISE. IT IS RECOMMENDED THAT INFORMATION IS NOT SCALED OFF THIS DRAWING
 - THIS DRAWING SHOULD BE READ IN CONJUNCTION WITH ALL OTHER RELEVANT DRAWINGS AND SPECIFICATIONS
 - ANY DISCREPANCIES NOTED ON SITE ARE TO BE REPORTED TO THE ENGINEER IMMEDIATELY.
 - REFER TO FOLLOWING CCS CONSULTING DRAWINGS FOR EXTERNAL WORKS & BELOW GROUND DRAINAGE PLANS AND TYPICAL DETAILS:
 - 22182-CCS-WCH006-XX-M2-S-90000 (EXT. WORKS PLAN)
 - 22182-CCS-WCH006-XX-M2-S-90001 (EXT. WORKS TYPICAL DETAILS)
 - 22182-CCS-WCH006-XX-M2-S-93000 (BGD PLAN)
 - REFER TO FOLLOWING SQUAREYARD DRAWINGS FOR LANDSCAPING GENERAL ARRANGEMENT & DETAILS:
 - 2301-SQU-XX-00-DR-L-001

T1	STAGE 04 ISSUE	31.05.24	JF	KLE
P1	STAGE 03 ISSUE	26.04.24	JF	KLE
REV.	DESCRIPTION	DATE	DRW.	CHK.

Tender Issue - For Costing Purposes Only

MANCHESTER UNIVERSITY
NHS Foundation Trust

APPOINTED PARTY LOGO/INFORMATION

ccs consulting
MANCHESTER • LONDON • LEEDS

PROJECT
CDC - CARDIORESPIRATORY,
WITHINGTON COMMUNITY HOSPITAL

TITLE
PROPOSED BELOW GROUND DRAINAGE -
TYPICAL DETAILS SHEET 1 OF 2

STATUS T1	PURPOSE OF ISSUE FOR COSTING
--------------	---------------------------------

DRAWN BY JF	CHECKED BY KLE	DATE APRIL '24
----------------	-------------------	-------------------

SCALE (@A1) AS SHOWN	PROJECT NUMBER HE-014
-------------------------	--------------------------

FILE DRAWING NUMBER 22182-CCS - WCH006- XX- DR - S - 93001	REV. T1
---	------------