


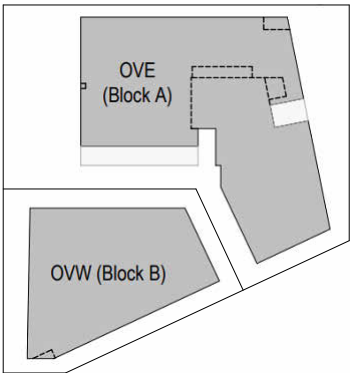

This document and its contents are the property of the Purchaser/Employer and Crookes Walker Consulting. They may not be copied or reproduced in any way, in part or whole, without prior written approval of both parties. Violations will result in legal action.
This drawing shall be read in conjunction with the CWC Mechanical and / or Electrical Specification(s).
DO NOT SCALE FROM THIS DRAWING

DESIGNERS RISK ASSESSMENT SCHEDULE
REFER TO APPENDIX 1 OF M&E SPECIFICATION FOR DESIGNERS RISK ASSESSMENT SCHEDULE


ACTIVE REVIT LINKS

ARCHITECTS:
1345-22-DAY-XX-XX-M3-A-00-0001

STRUCTURAL:
204-CIV-10-ZZ-M3-S-0001_WIP

- GENERAL NOTES**
- THIS DRAWING SHALL BE READ IN CONJUNCTION WITH ALL RELEVANT STRUCTURAL, ARCHITECTURAL AND CONSULTANTS INFORMATION AND DRAWINGS.
 - DO NOT SCALE FROM THIS DRAWING
 - ALL DIMENSIONS IN mm UNLESS OTHERWISE STATED.
 - ALL PLANT AND EQUIPMENT IS TO BE INSTALLED TO MANUFACTURERS RECOMMENDATIONS, ALLOWING FULL ACCESS FOR COMMISSIONING, MAINTENANCE AND REMOVAL/REPLACEMENT.
 - ALL PLANTAND EQUIPMENT SHALL BE SUITABLE FOR THE ENVIROMENTAL LOCATION.
 - THE MAIN CONTRACTOR SHALL BE RESPONSIBLE FOR ALL FIRE STOPPING WHERE SERVICES PASS THROUGH FIRE COMPARTMENTS. THE CONTRACTOR SHALL ENSURE THE INSTALLATION ALIGNS WITH THE FIRE ENGINEER, ARCHITECTURAL AND STRUCTURAL FIRE COMPARTMENTATION STRATEGIES.

LIGHTING LEGEND	
SYMBOL	DESCRIPTION
• H	DOWNLIGHTS - ANSELL VANTAGE
• E1	EMERGENCY - ANSELL MERLIN LED EMERGENCY DOWNLIGHT
↑EXIT↑	EMERGENCY - ANSELL EAGLE 3-IN-1 CEILING MOUNTED EXIT SIGN
EXIT	EMERGENCY - ANSELL EAGLE 3-IN-1 WALL MOUNTED EXIT SIGN
• I	BULKHEADS - ANSELL LUCCA
• J/E	BULKHEADS - ANSELL ECLIPSE C/W EMERGENCY BACK UP & INTEGRAL PIR
□ K/E	BULKHEADS - ANSELL SLEEK C/W EMERGENCY BACKUP
— L	SURFACE MOUNTED LINEAR - ANSELL TORNADO
E1	EMERGENCY BULKHEADS - ANSELL GUARDIAN
↗	2-WAY LIGHT SWITCH
☀ PIR	CEILING MOUNTED PRESENCE DETECTOR
☀ MW	WALL MOUNTED MICROWAVE DETECTOR

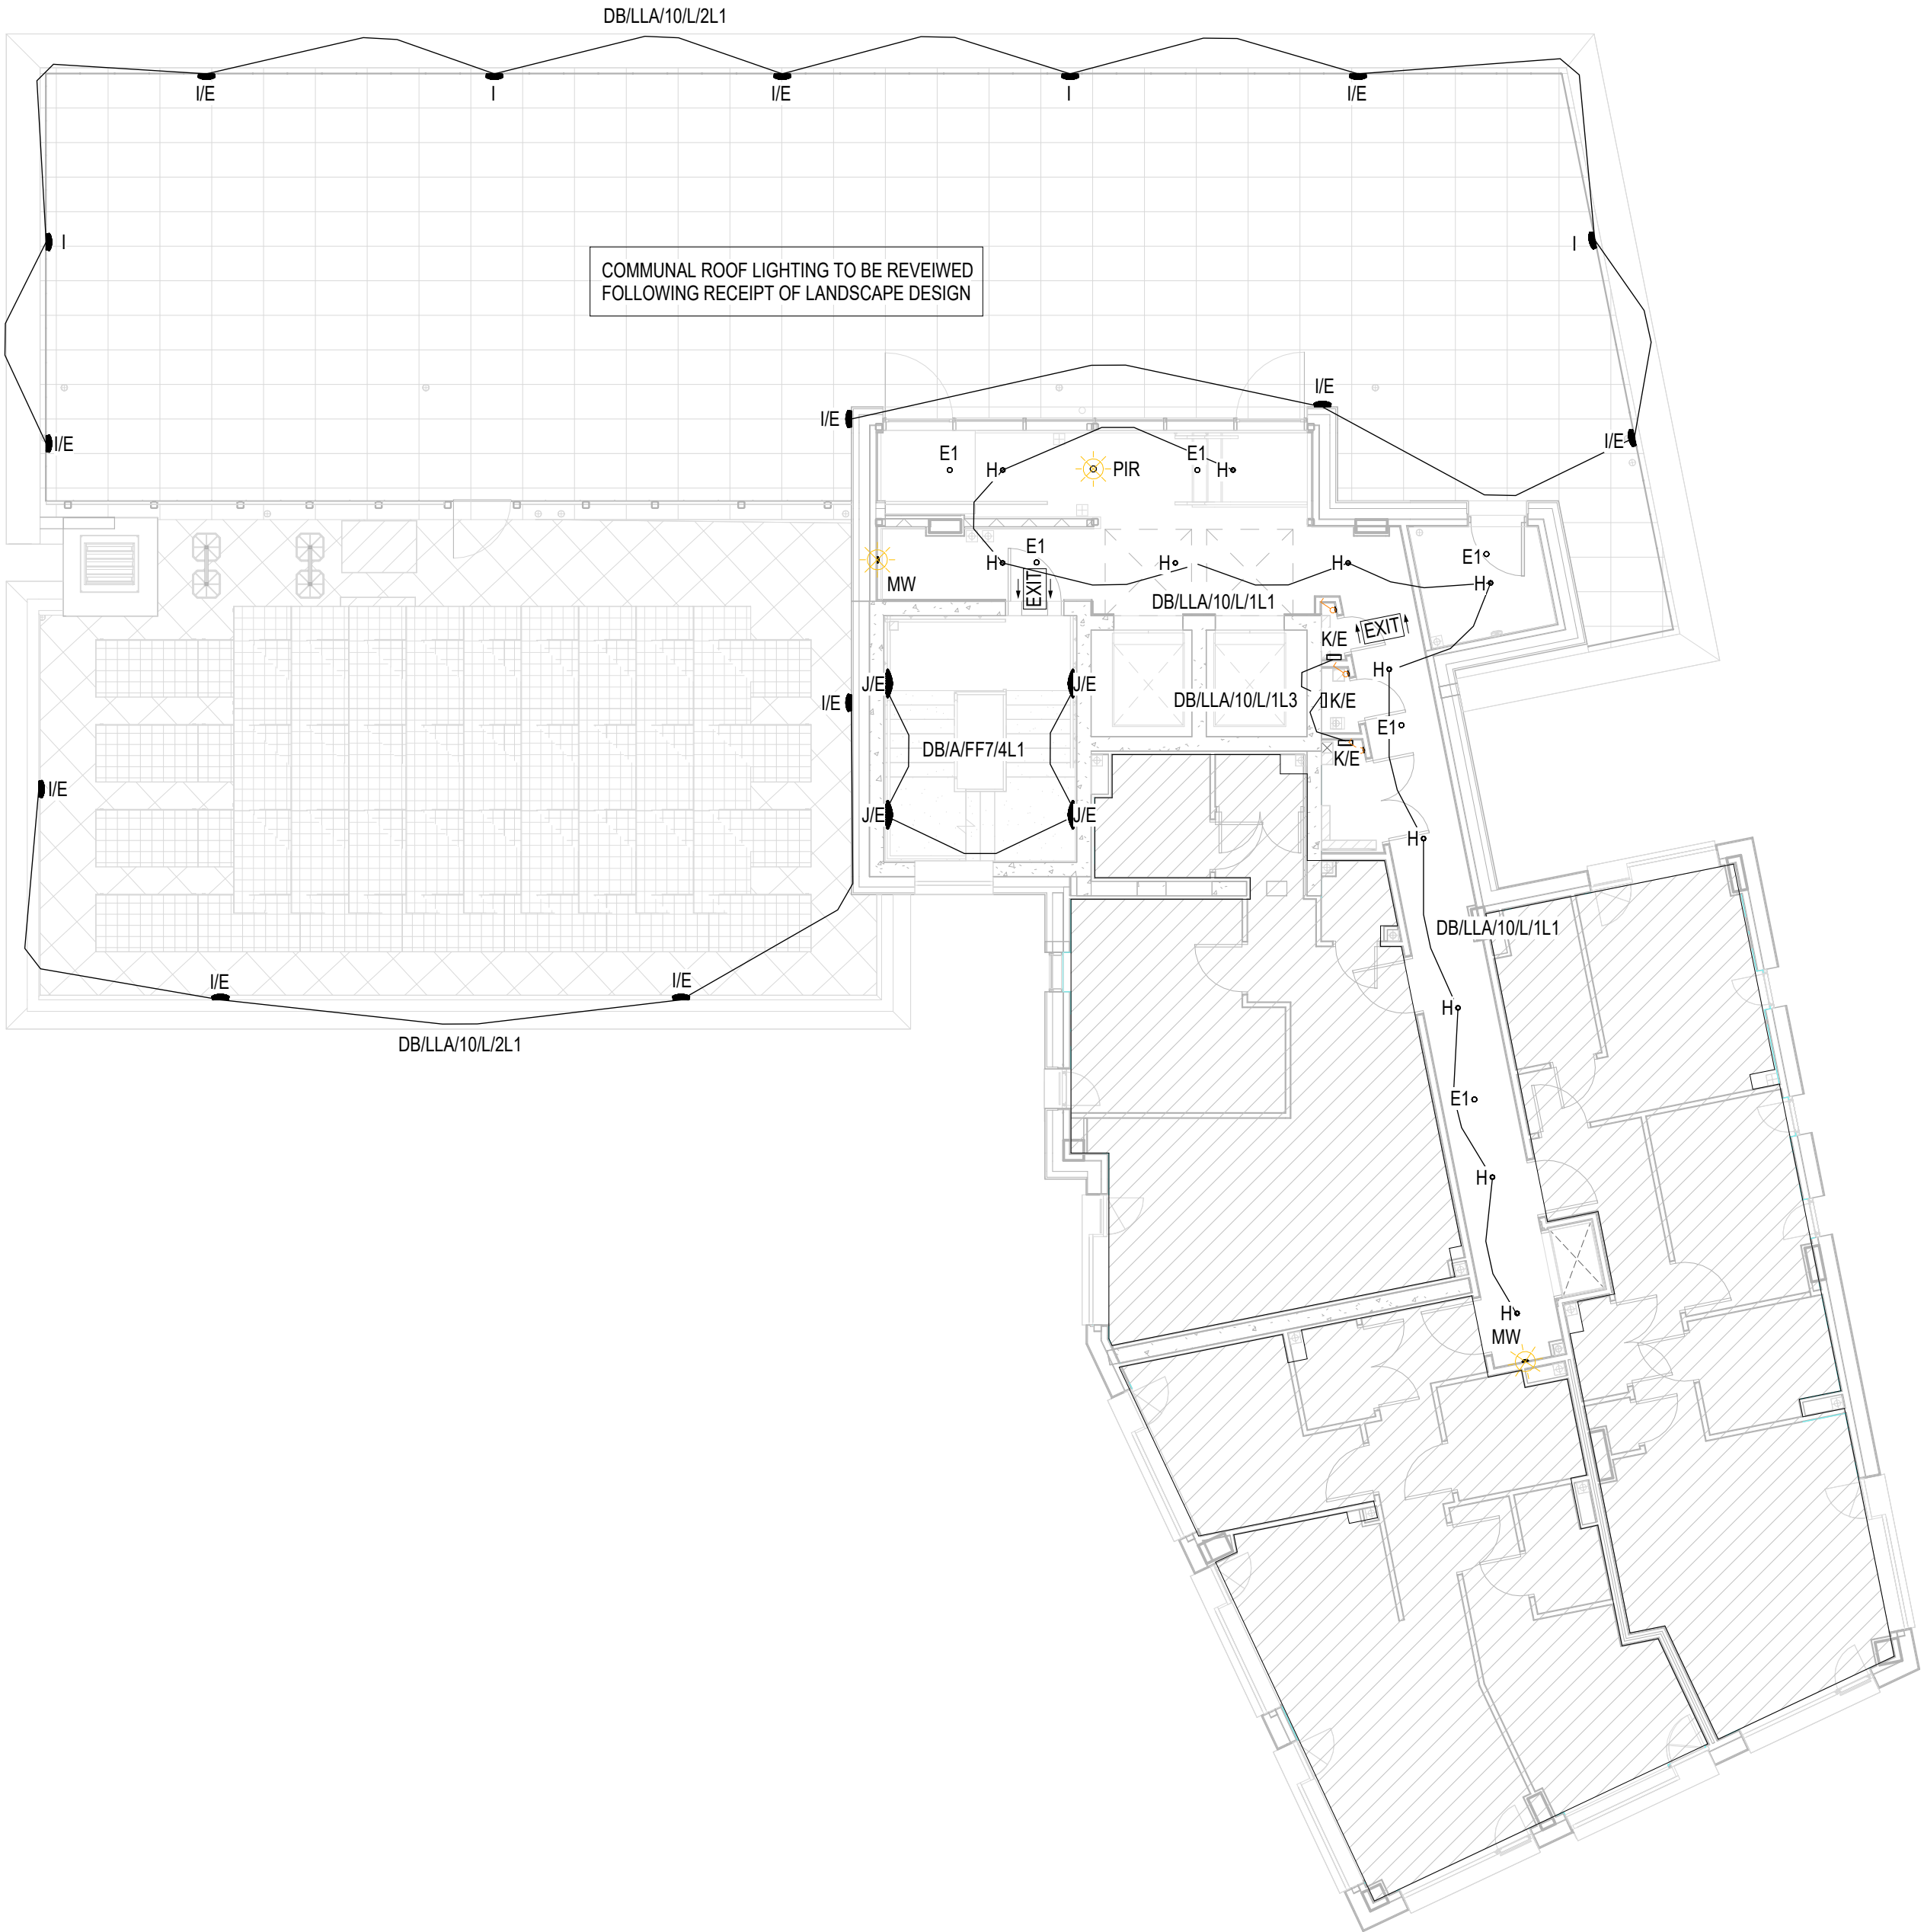

C01	01/03/24	CONSTRUCTION ISSUE	RW	AS
P02	14/02/24	FOR COMMENT	RW	AS
P01	12/01/24	PRELIMINARY ISSUE	RW	LS
Rev	Date	Description	Eng	CHK



crookes walker consulting

Suite 9a, Bloc, 17 Marble Street
Manchester M2 3AW
Tel: 0161 834 9999

The Plaza, Old Hall Street,
Liverpool L3 9QJ
Tel: 0151 600 5409

Cornwall Building, 45 Newhall Street,
Birmingham B3 3QR
Tel: 0121 262 4046
E-mail: admin@cwcon.co.uk
Website: www.cwcon.co.uk

Client



KIMPTON
Established 1963

Project
**ONE VICTORIA,
MANCHESTER**

Drawing Title
**OVE LEVEL 10
LIGHTING LAYOUT**

Status
CONSTRUCTION

Project No. 3135	Drawn RW	Scale / Paper Size 1 : 100 @ A1
---------------------	-------------	------------------------------------

Drawing No. 204-KIM-BA-10-DR-E-6301	Rev C01
--	------------

1 Block A - Level 10 - Lighting Layout
1 : 100