


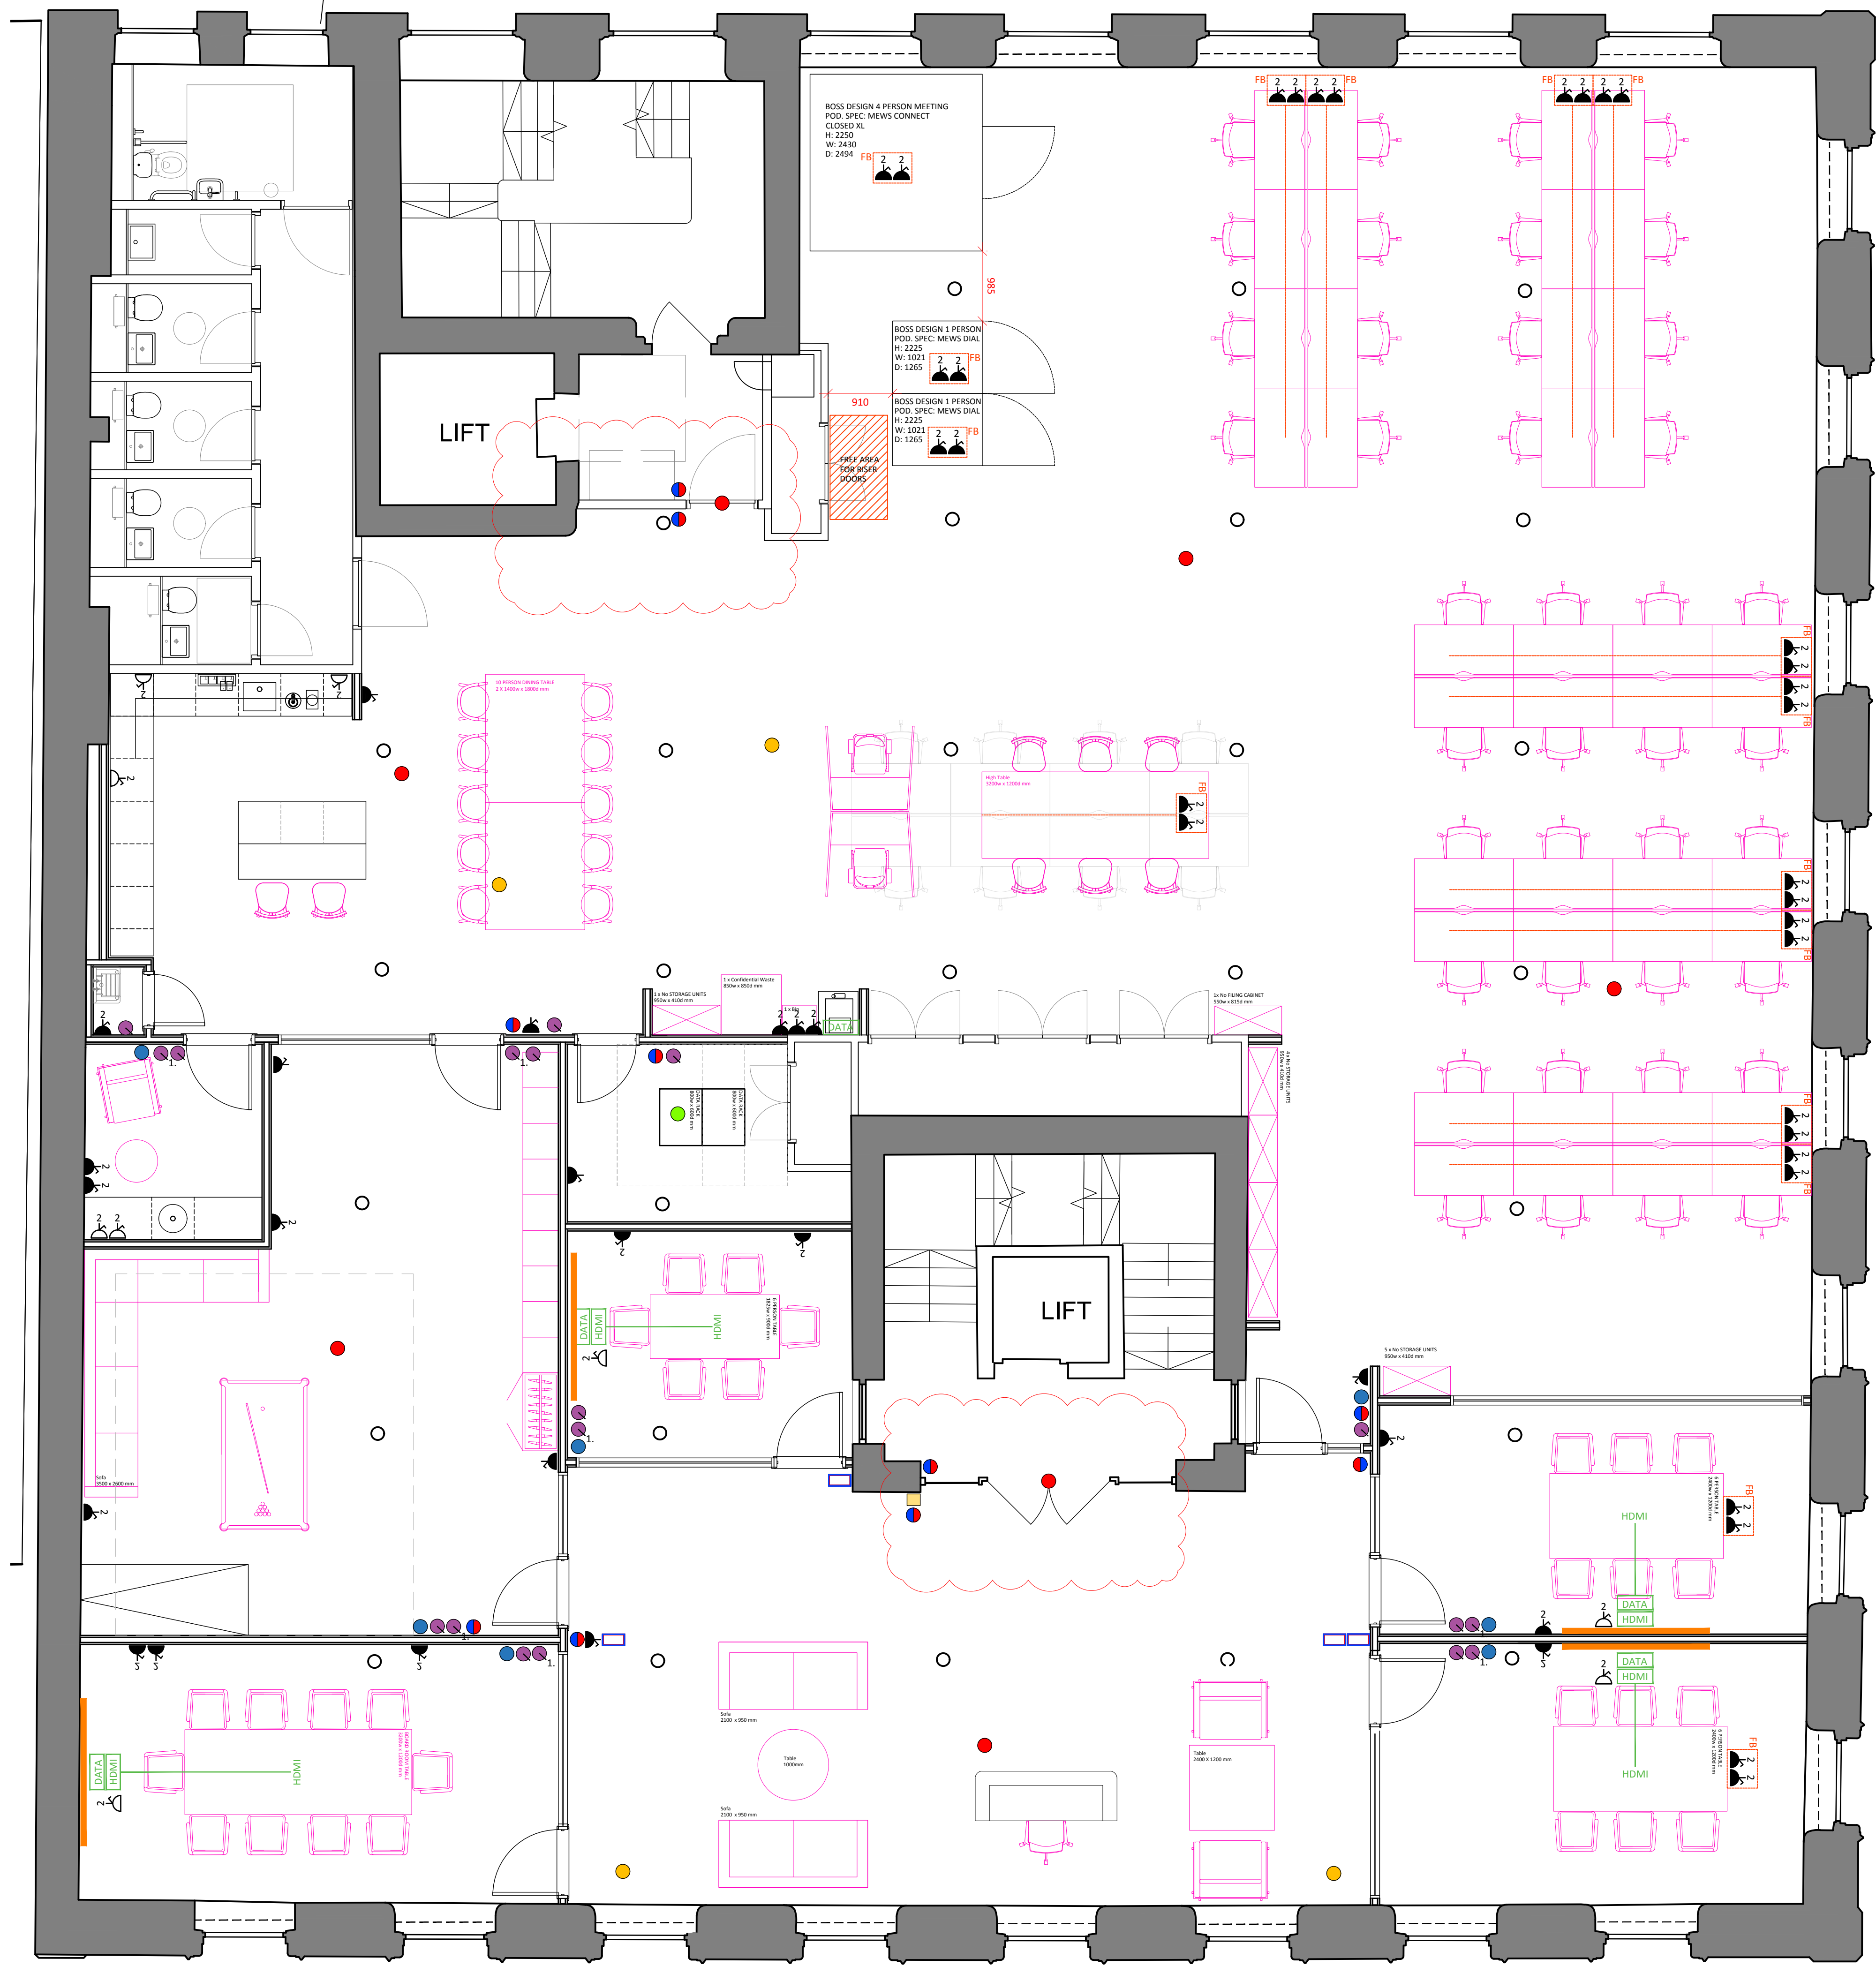

01 FOURTH FLOOR SMALL POWER PLAN
SCALE - 1:50 @ A1
AS PROPOSED

SERVICES KEY	
	SWITCHED TWIN SOCKET OUTLET - HIGH LEVEL.
	SWITCHED TWIN SOCKET OUTLET - LOW LEVEL. POWER SUPPLIED BY GALVANIZED TUBE FROM SKIRTING TO SOCKET
	SWITCHED SINGLE SOCKET OUTLET - LOW LEVEL (CLEANER SOCKET)
	TWIN DATA OUTLET
	SINGLE HDMI OUTLET (TO HAVE TABLETOP INPUT IN MEETING/BOARD ROOMS)
	LOCATION OF WALL MOUNTED TV
	LOCATION OF FLOOR BOX HOUSING DSSO'S, TO ALLOW FOR DAISY CHAIN TO DESKS (DASHED LINE)
	DOUBLE LIGHT SWITCH FOR ROOM PENDANT/ROOM TASK LIGHTING
	GENERAL AREA TASK LIGHTING SWITCH
	ROOM SPECIFIC HEATING AND COOLING CONTROL SYSTEM
	TABLET BOOKING SYSTEM
SECURITY REQUIREMENTS, AS PROPOSED BY AVIGILON. REFER TO AVIGILON SPEC (18/11/24)	
	ACS C6000 CONTROLLER CCTV HD (IN RACK) INTRUDER POWER PACK
	ACS BADGE READER
	INTRUDER KEYPAD
	CCTV DOME CAMERA
	INTRUDER DOOR CONTACT/360 SENSOR
EXACT POSITIONS AND QUANTITY OF ALL ELECTRIC FITTINGS TO BE CONFIRMED BY CLIENT. WHERE OUTLETS SHOWN ON EXISTING WALL, GALVANIZED TUBING TO BE INSTALLED TO BRING POWER UP THROUGH RAISED ACCESS FLOORING. CLIENT TO ADVISE ON ANY ADDITIONAL FEATURES REQUIRED TO SOCKETS, E.G. DIMMERS, ADDITIONAL DATA POINTS, ETC. CCTV AND ALARM LOCATIONS TO BE DETERMINED BY SPECIALIST INSTALLER. REFER TO RELEVANT DETAIL ELEVATION DRAWINGS FOR SETTING OUT OF DSSO POWER SOCKETS. PLEASE REFER TO CLIENT/CONSULTANT DATA SHEETS FOR FURTHER REQUIREMENTS ON POWER AND DATA PROVISION.	

REV CLOUD DENOTES AREAS WHERE LANDLORD APPROVAL /COORDINATION IS NEEDED AS SITS WITHIN THEIR DEMISE. THERE MAY BE A EXISTING SYSTEM IN PLACE WE CAN USE. CONFIRMATION NEEDED

NOTES

DO NOT SCALE FROM THIS DRAWING.
ALL DIMENSIONS TO BE CHECKED ON SITE.
(DRAWINGS MAYBE SCALED FOR LOCAL AUTHORITY & PLANNING PURPOSE ONLY)
COPYRIGHT PROTECTED.

00.51.02.5

0.51.02.5

1.01.02.5

2.01.02.5

2.51.02.5

Scale 1:50

FOR COMMENT

CONSULTANT REFERENCES IN DRAWING:

STRUCTURAL - REF/REVISION

GENERAL NOTES:

THE CONTRACTOR IS NOT TO SCALE FROM THIS DRAWING BUT FOLLOW THE WRITTEN FINISHED DIMENSIONS. ANY DISCREPANCIES BETWEEN THE DRAWING AND THE OTHER CONTRACT DOCUMENTS OR ANY DISCREPANCIES WITHIN A DRAWING OR BETWEEN DRAWINGS MUST BE REPORTED IMMEDIATELY TO THE ARCHITECT.

THE CONTRACTOR IS TO INSPECT THE SITE PRIOR TO TENDER AND IS RESPONSIBLE FOR STRIPPING OUT IN ACCORDANCE WITH THE DRAWINGS ENSURING THAT THE WORK IS UNDERTAKEN SAFELY.

THE CONTRACTOR WILL BE RESPONSIBLE FOR THE SETTING OUT OF THE WORKS.

CONTRACTOR IS TO ALLOW FOR ALL FIRE STOPPING THROUGH WALLS, CEILINGS AND FLOORS.

THE ELECTRICAL INSTALLATION IS TO BE IN ACCORDANCE WITH THE CURRENT EDITION OF THE IEE REGULATIONS AND ALL CABLEING TO BE LSF.

THE CONTRACTOR IS RESPONSIBLE FOR THE DETAILED SERVICES DESIGN INCLUDING LOADINGS, CABLE AND PIPEWORK ROUTES AND PIPEWORK / CABLE SIZING AND SPECIFICATION. ALL CABLE TRAY, MS CONDUIT AND OTHER SERVICES ARE TO BE EXPOSED BELOW SLAB/ CEILINGS.

ANY H&V PROPOSAL IS INDICATIVE ONLY AND THE SPECIALIST CONTRACTOR IS TO BE RESPONSIBLE FOR THE DETAIL DESIGN & ALL SWITCH/ SOCKET OUTLETS TO COMPLY WITH CLIENT'S STANDARD SPECIFICATION. ANY SOCKETS IN RETAIL AREA TO BE FINISHED BRUSHED STAINLESS STEEL.

NOTE - ALL EXISTING FIRE RESISTING ENCLOSURES TO SERVICE RISERS TO BE MAINTAINED OR MADE GOOD WHERE DISTURBED. NEW AND EXISTING CABLES, PIPES AND DUCTS PASSING THROUGH FIRE RESISTING CONSTRUCTION TO BE ADEQUATELY FIRE STOPPED. NEW AND EXISTING DUCTWORK PASSING THROUGH FIRE RESISTING CONSTRUCTION TO HAVE FIRE DAMPERS.

ANY WALL, CEILING LININGS TO BE TO EUROCLASS A (CLASS O EQUIVALENT).

CONTRACTOR AND SUPPLIERS OF SPECIALIST JOINERY/ EQUIPMENT TO ENSURE ALL TIMBER MATERIALS ARE TREATED WITH FIRE RETARDANT FINISH TO ACHIEVE CLASS O RATING. NDF TO BE ACHIEVE CLASS O RATED.

CONTRACTOR AND SUPPLIERS OF SPECIALIST EQUIPMENT TO PROVIDE FIRE RATING CERTIFICATES FOR ALL SPECIALIST LININGS AND LAMINATES TO BE USED FOR NWR APPROVAL.

ALL PAINTS TO BE WATER BASED

ALL DIMENSIONS TO BE CHECKED ON SITE PRIOR TO ANY MANUFACTURE OR CONSTRUCTION OF EQUIPMENT, FINISH, SIGNAGE ETC.

3.00	20/11/24	ISSUED FOR COMMENT	DC	FWE
REV	DATE	DESCRIPTION	DRAWN	CHECKED
<div>A X I</div>				
ADDRESS : 4th FLOOR CALICO 53-55 MOSLEY STREET, MANCHESTER, M2 3HQ				
TELEPHONE : +44 (0)161 879 7357				
EMAIL : www.ani.studio				
COMPANY No : 11847325				
CLIENT				
ZURICH				
PROJECT				
4th Floor				
FREETRADE EXCHANGE				
MANCHESTER				
FOURTH FLOOR FLOOR POWER PLAN				
AS PROPOSED				
JOB REFERENCE	DRAWING SCALE	DATE	DRAWN	CHECKED
24 - 231	1:50 @ A1	24/10/24	DC	AB
DRAWING REFERENCE	STAGE	REV		
AXI - 105	3	00		