

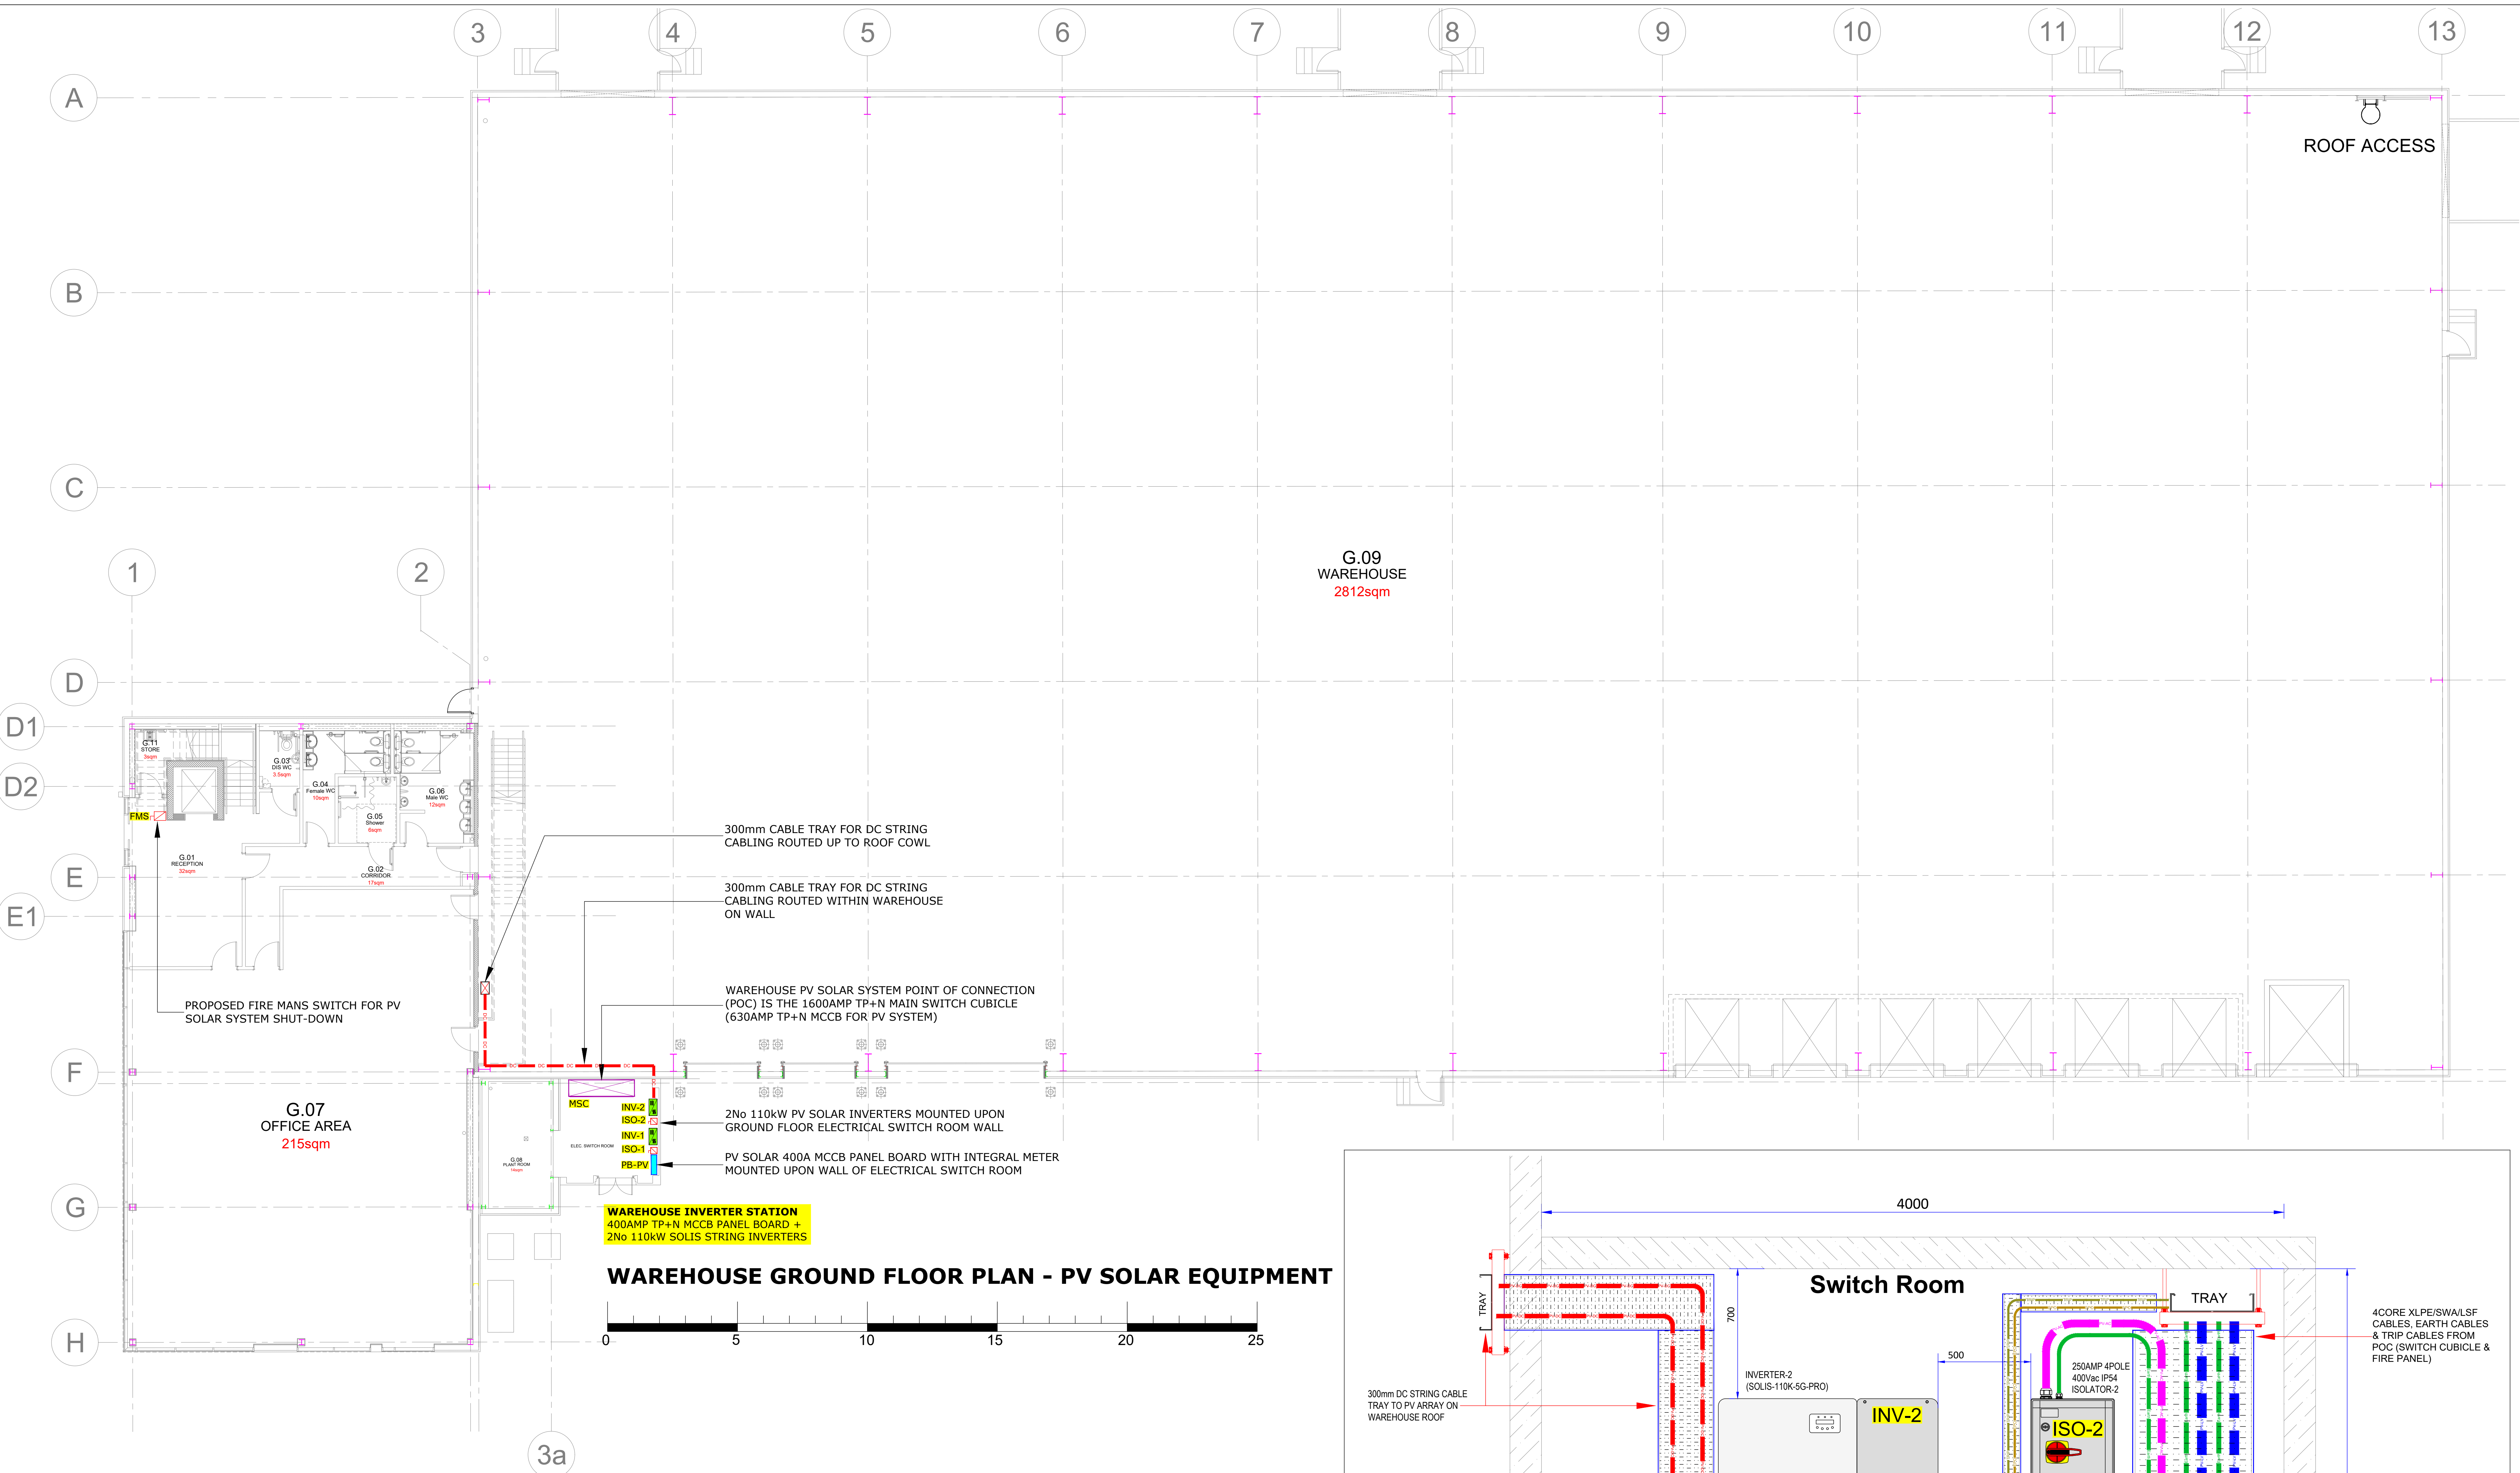


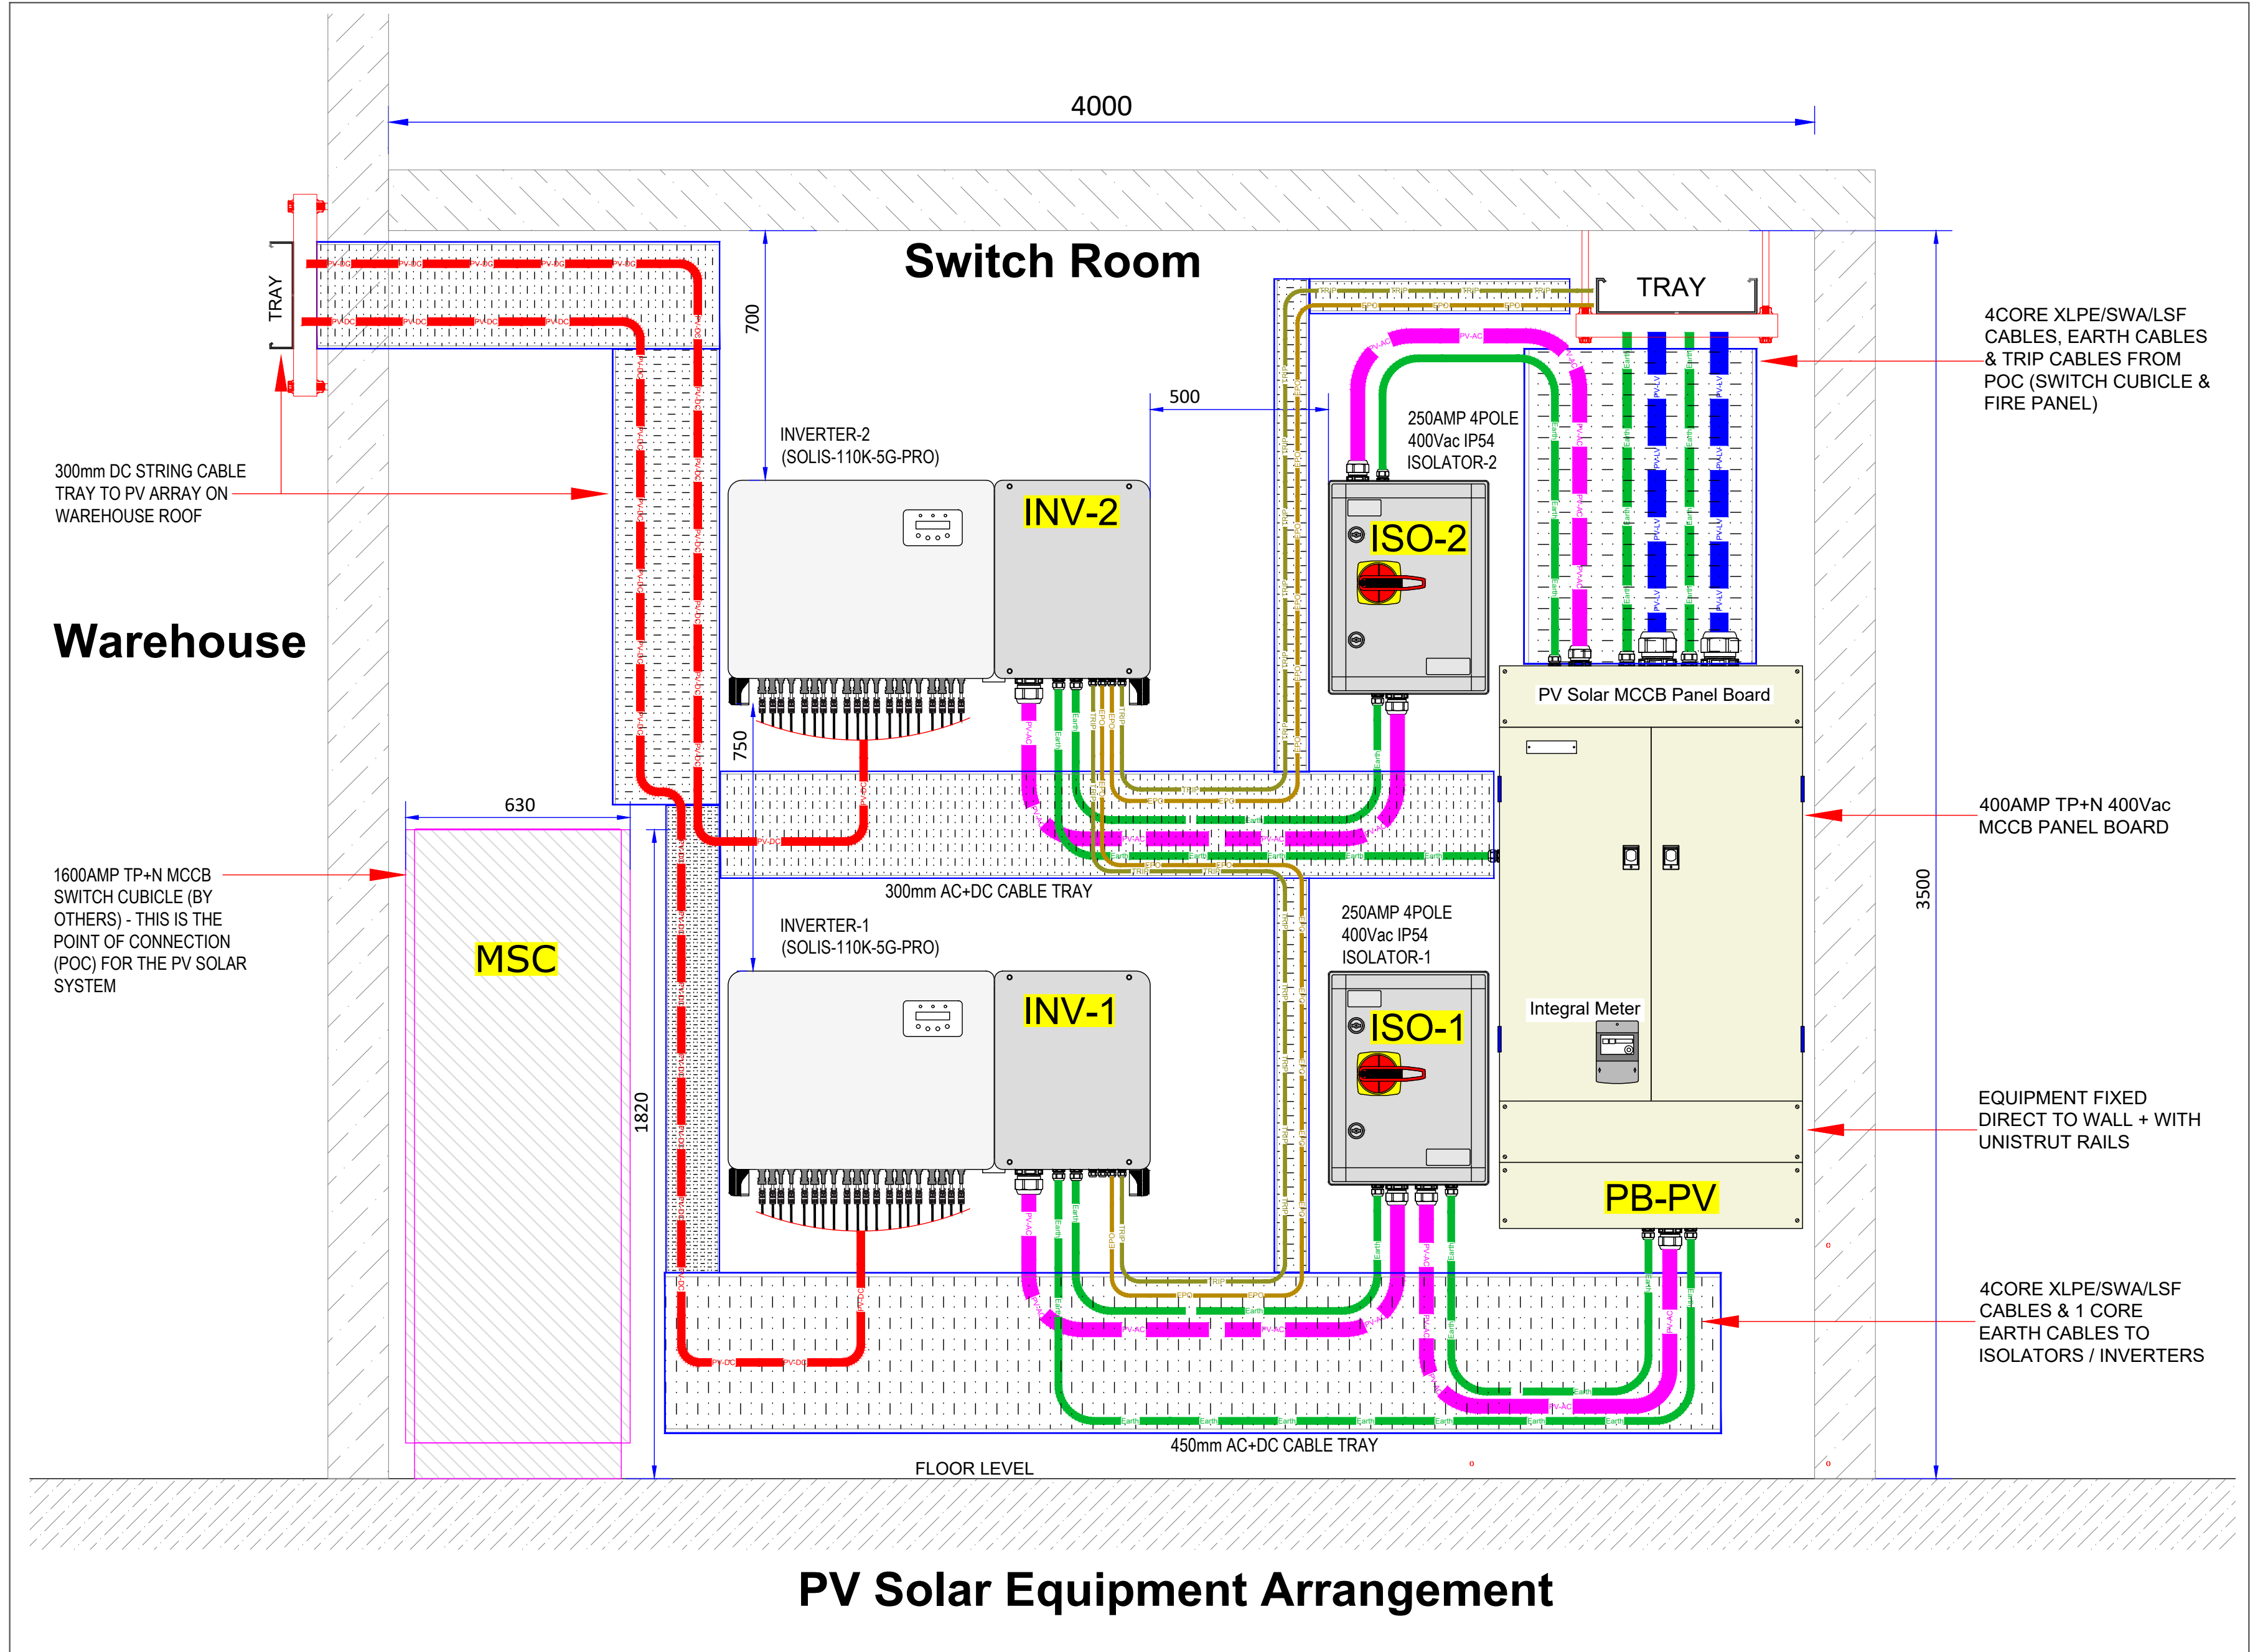

WAREHOUSE GROUND FLOOR PLAN - PV SOLAR EQUIPMENT

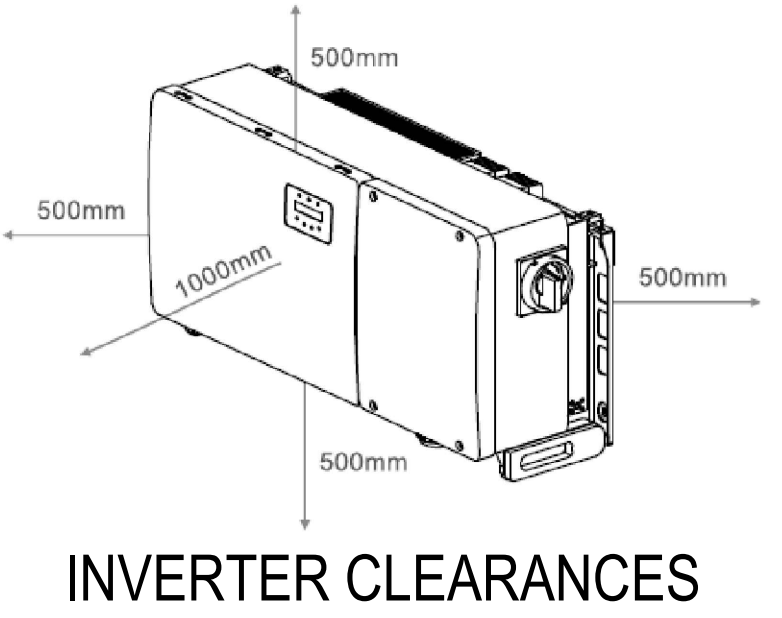

PV Solar Equipment Arrangement

A	AMc	RM	RS	ISSUED FOR COMMENT	25/08/24
VERSION	DRWN	CHKD	AUTH	REASON FOR ISSUE	DATE
S4				DEVELOPED DESIGN	
SUITABILITY CODE	SUITABILITY DESCRIPTION				



DHL INTERNATIONAL
2 SUNBANK LANE, AIRPORT CITY, WA15 0PT
294.68kWp ROOF PV SOLAR SCHEME
GROUND FLOOR PLAN - PV SOLAR EQUIPMENT

DRAWING NUMBER	2806-E0003	SHEET SIZE	A0
REVISION	A		