




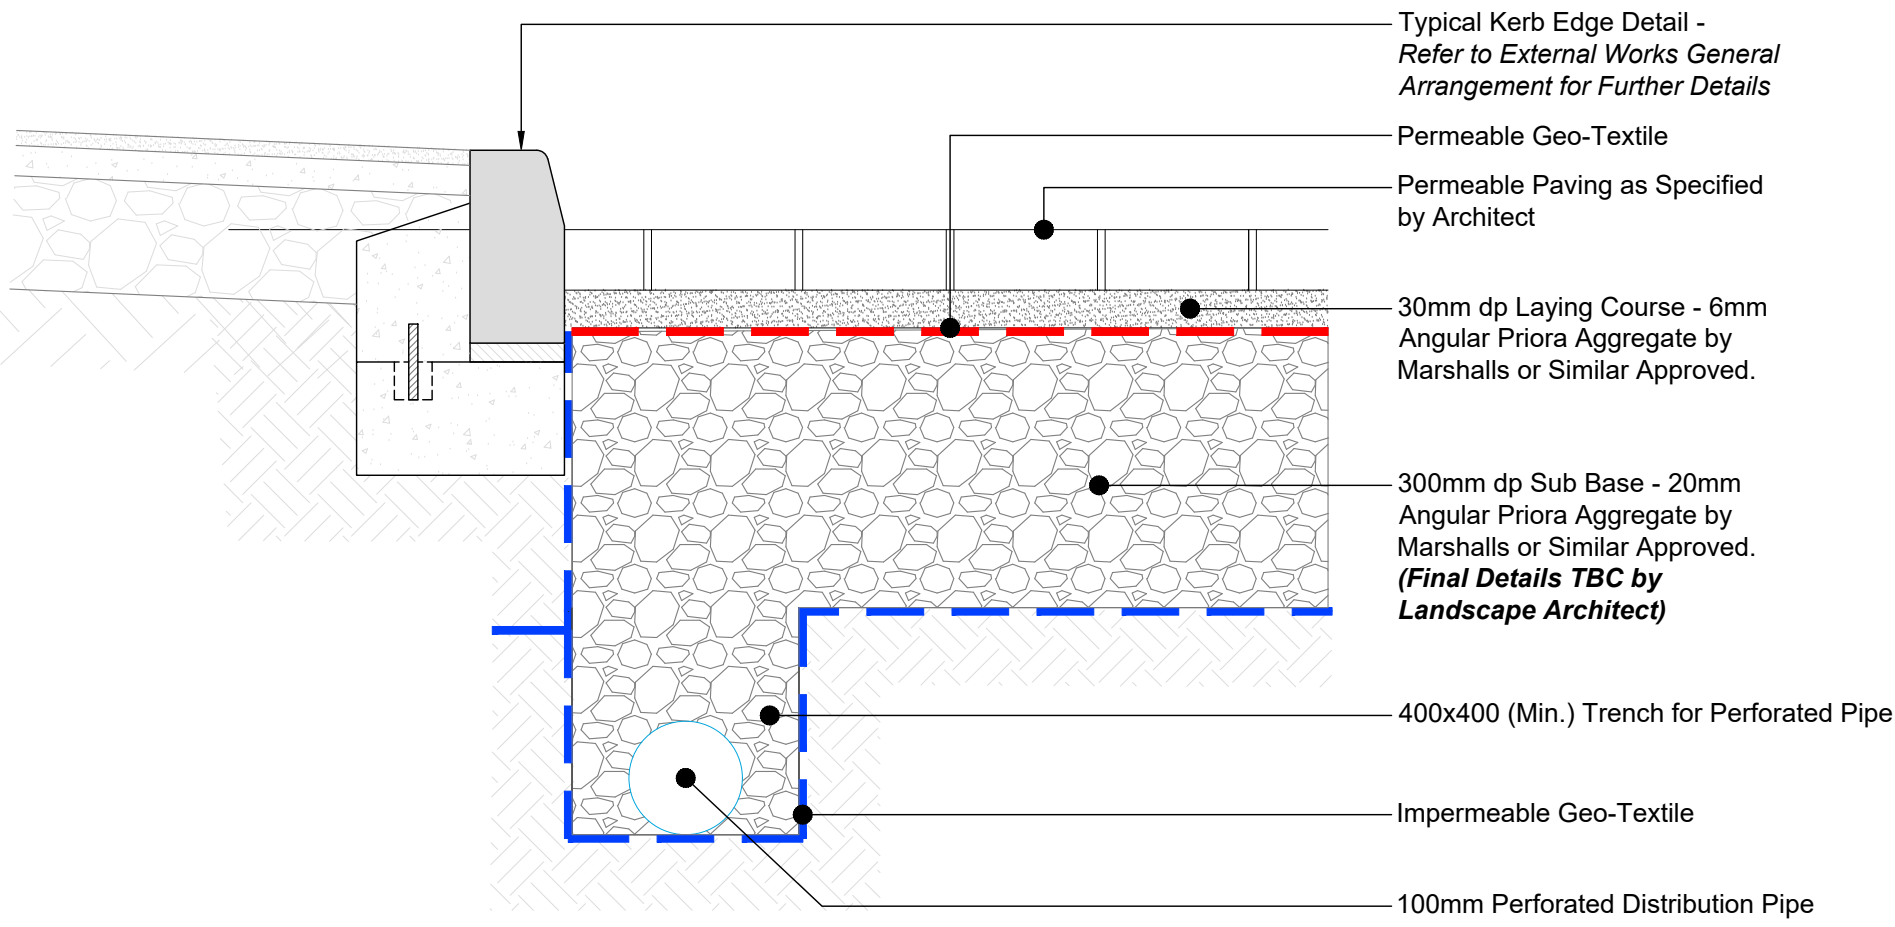


Detail 17 - Typical Permeable Paving Drainage Detail

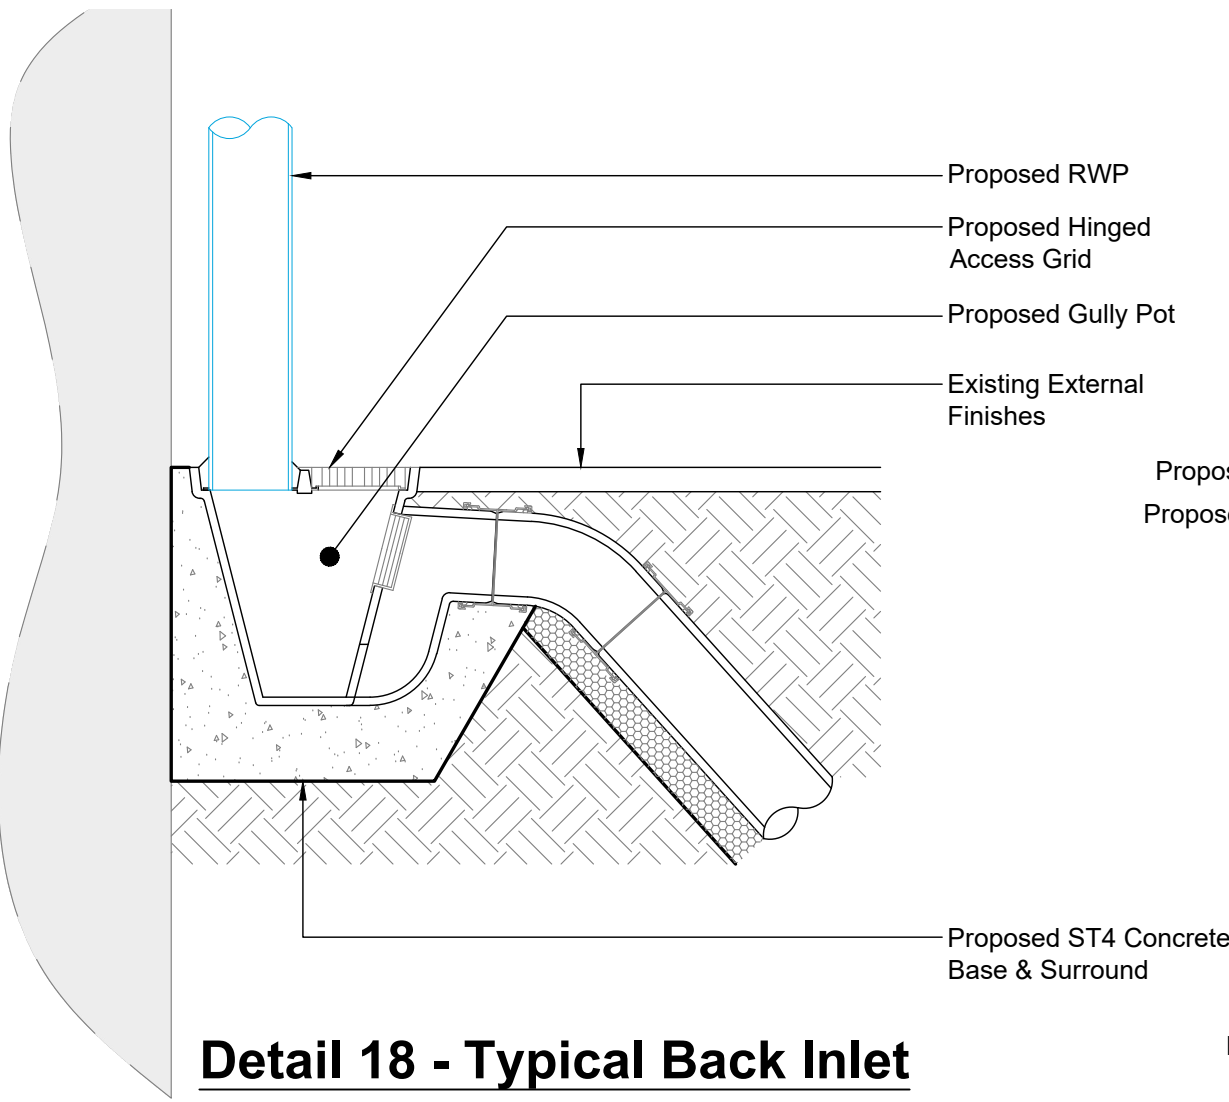


Detail 18 - Typical Back Inlet Gully (Trapped) Detail

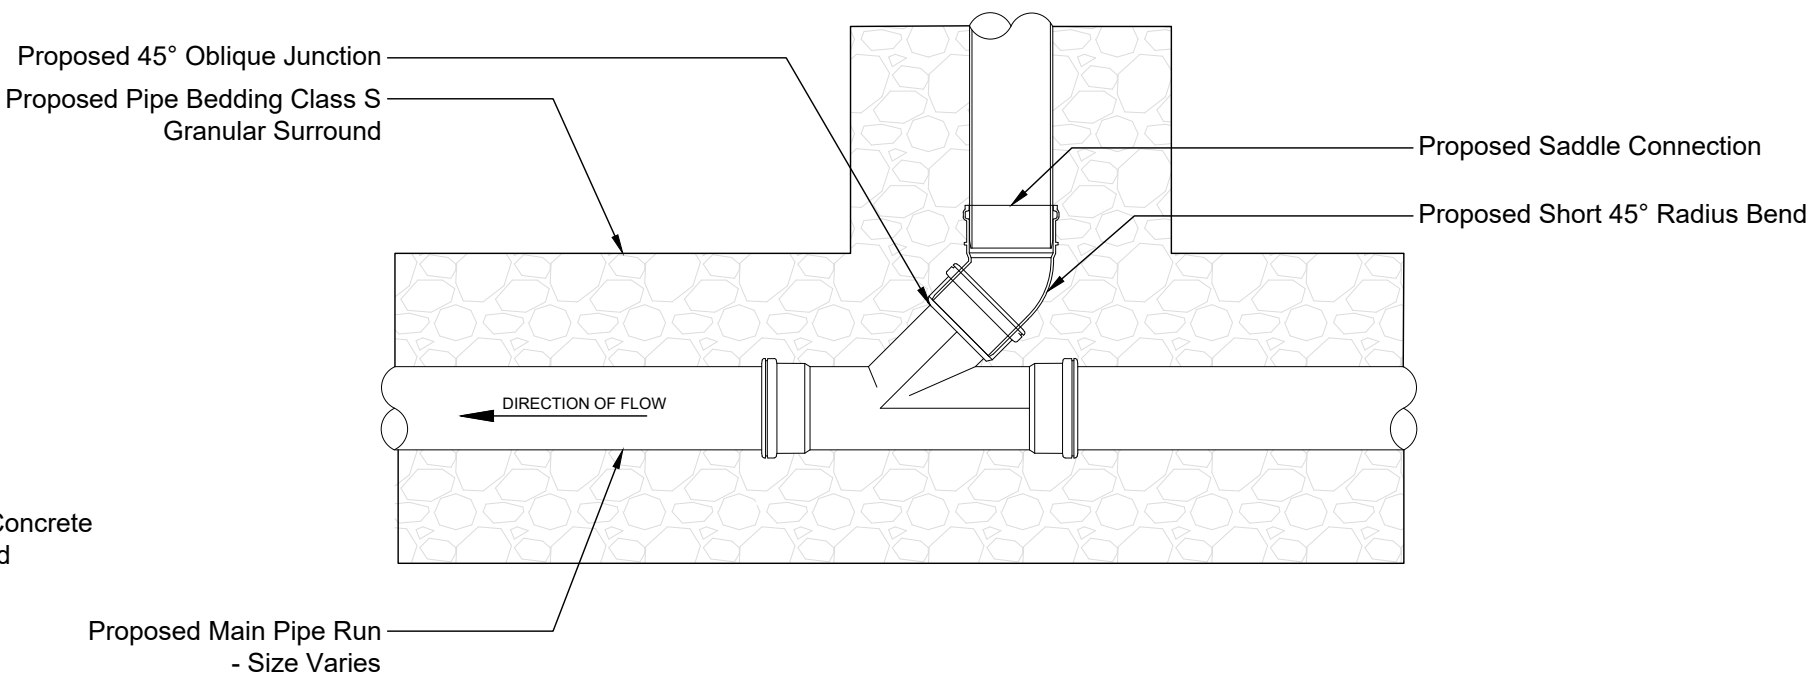


Detail 19 - Proposed Saddle Connection Detail

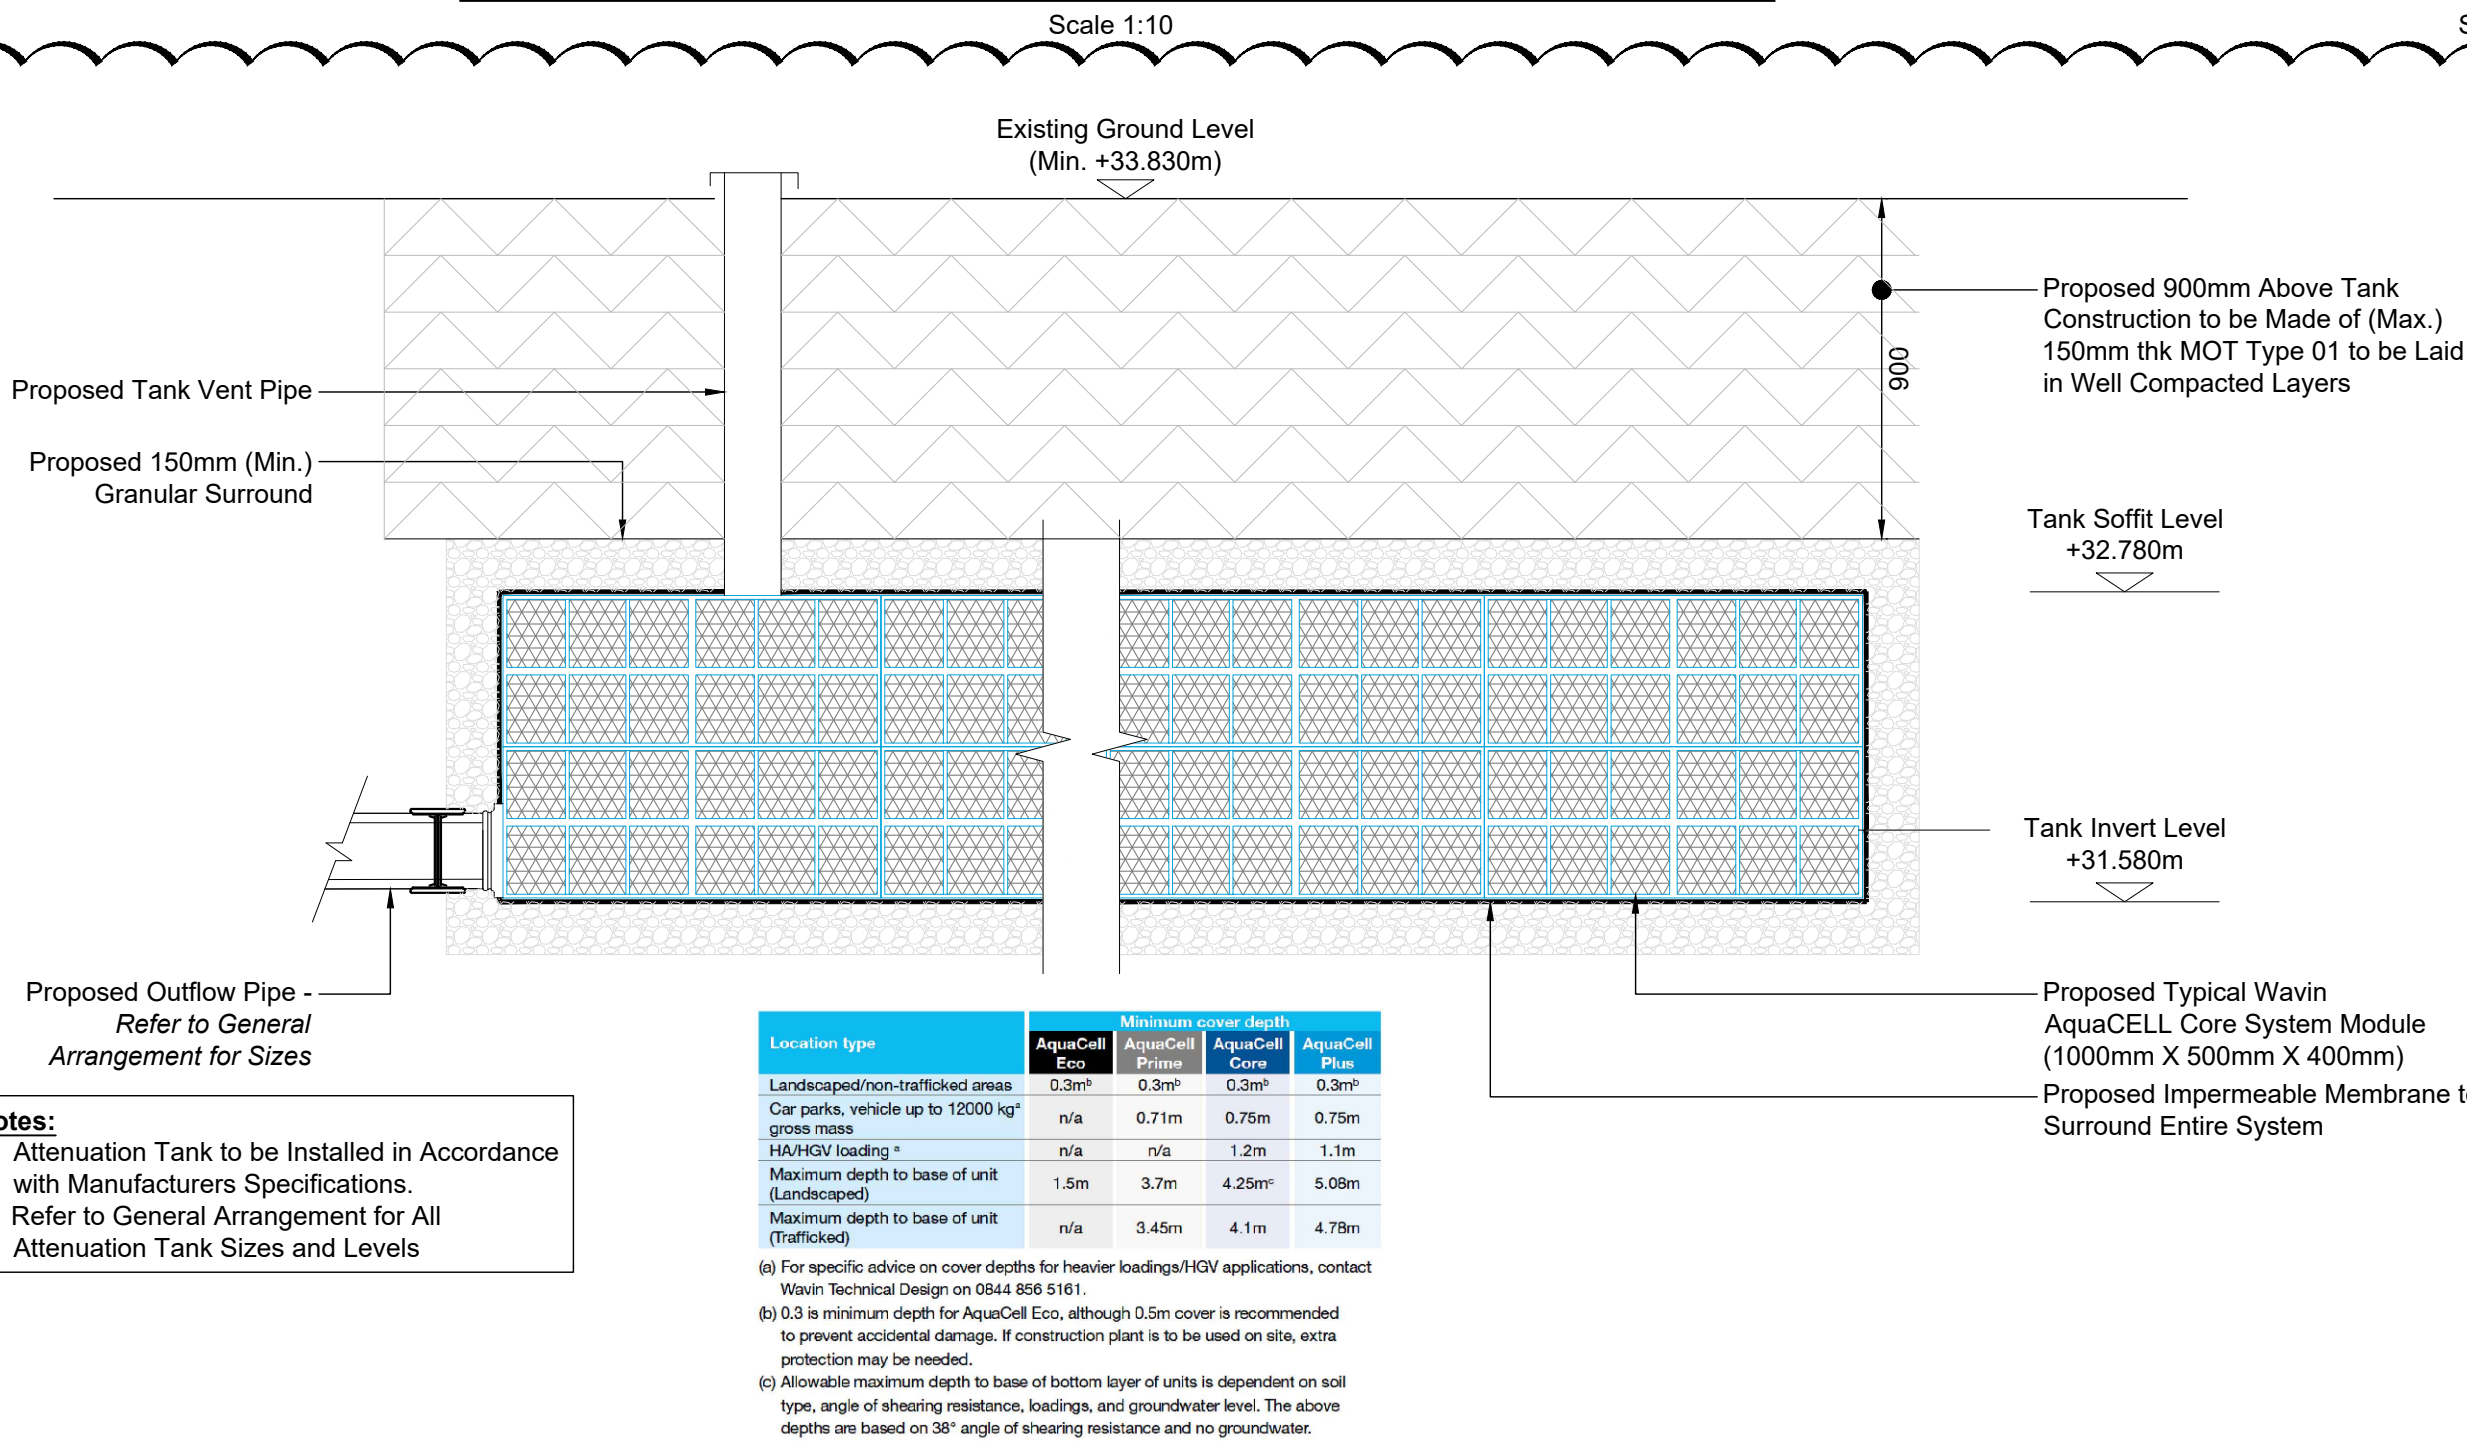

Detail 20 - Proposed Typical Attenuation Tank Detail

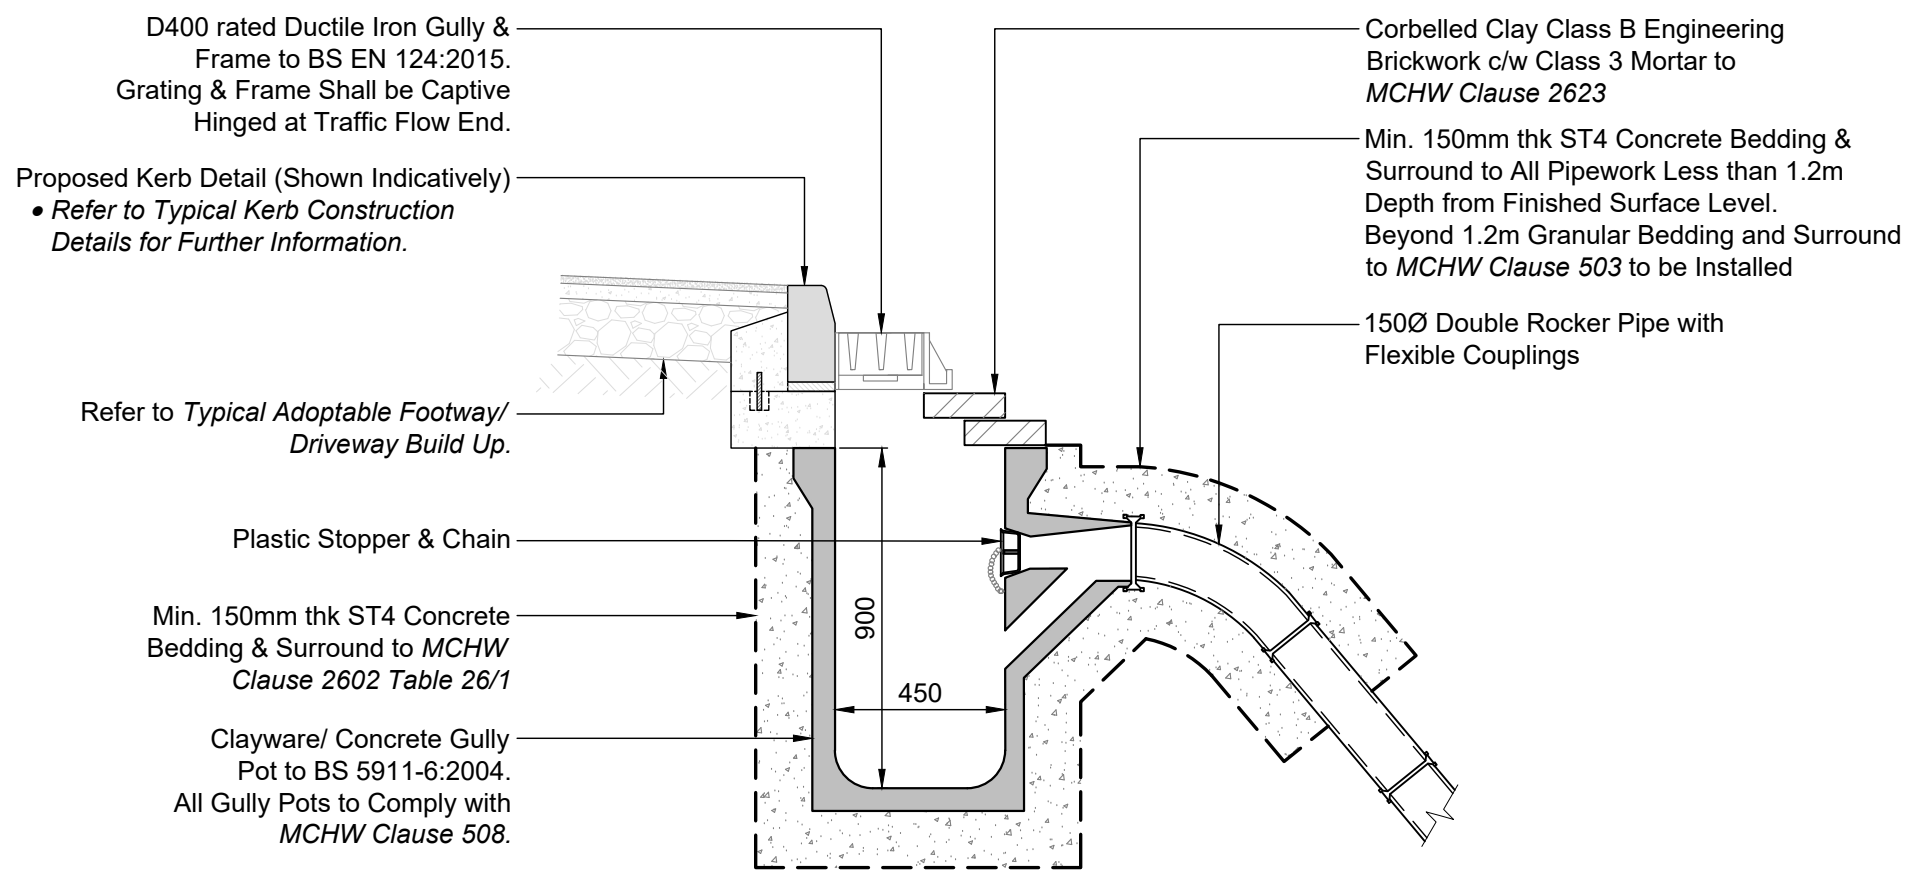

Detail 21 - Typical Highway Gully Detail

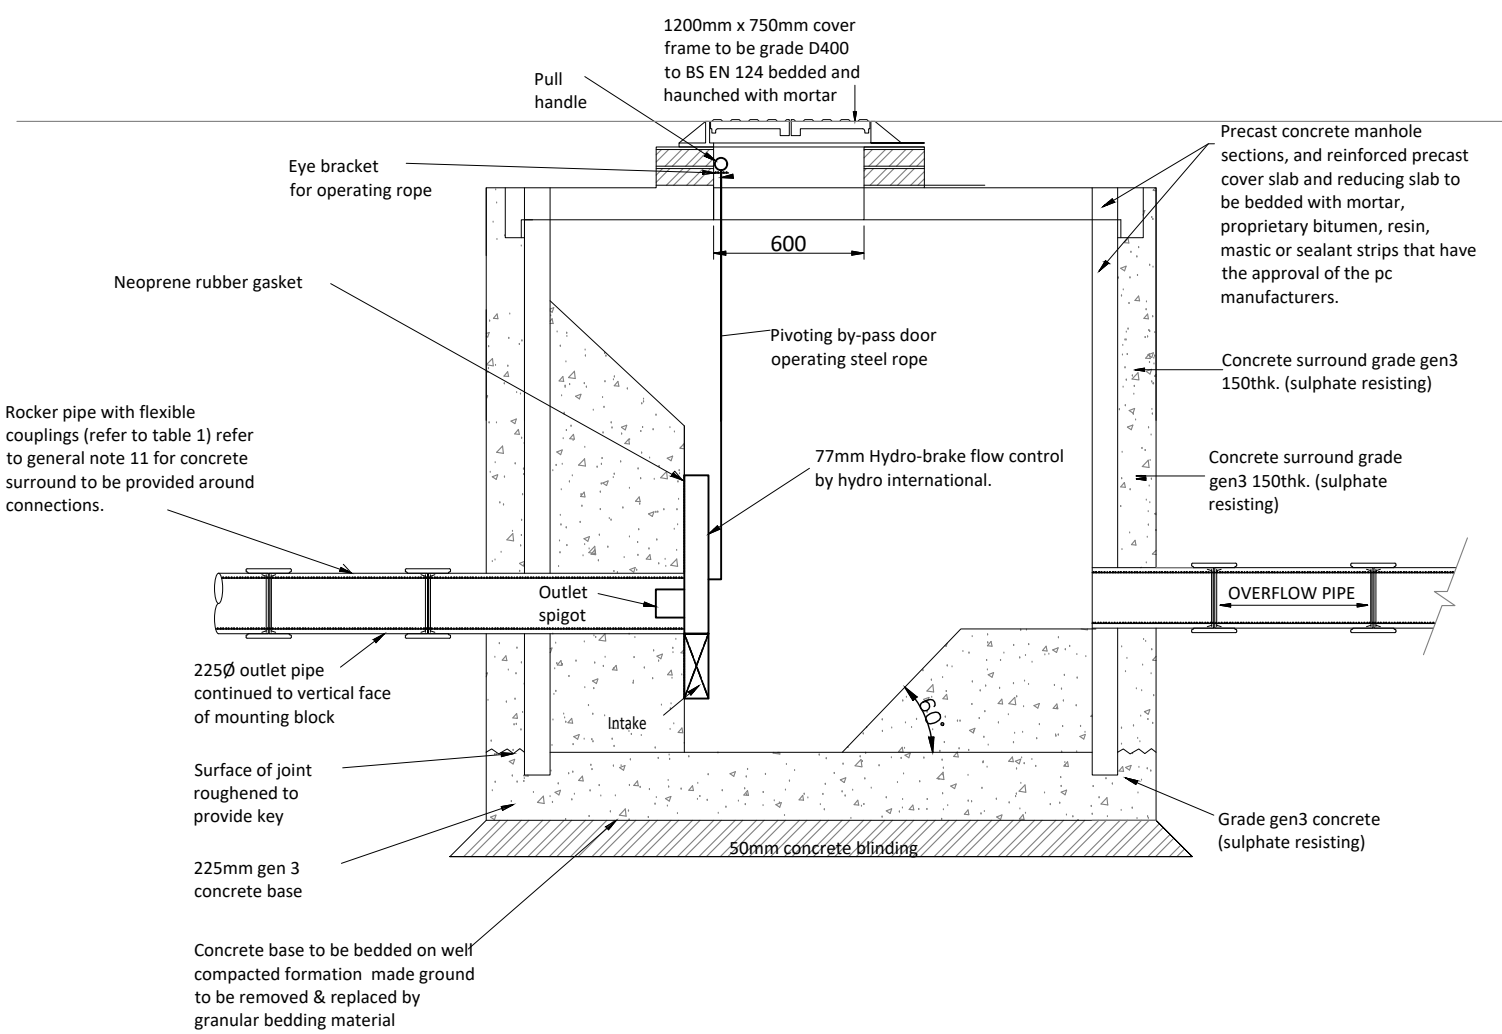

Detail 22 - Typical Flow Control Chamber Detail

notes :

1. IF THIS DRAWING HAS BEEN RECEIVED ELECTRONICALLY IT IS THE RECIPIENTS RESPONSIBILITY TO PRINT THE DOCUMENT TO THE CORRECT SCALE
2. ALL DIMENSIONS ARE IN MILLIMETRES UNLESS STATED OTHERWISE. IT IS RECOMMENDED THAT INFORMATION IS NOT SCALED OFF THIS DRAWING
3. THIS DRAWING SHOULD BE READ IN CONJUNCTION WITH ALL OTHER RELEVANT DRAWINGS AND SPECIFICATIONS
4. ANY DISCREPANCIES NOTED ON SITE ARE TO BE REPORTED TO THE ENGINEER IMMEDIATELY.
5. REFER TO FOLLOWING CCS CONSULTING DRAWINGS FOR EXTERNAL WORKS & BELOW GROUND DRAINAGE PLANS AND TYPICAL DETAILS:
 - 22182-CCS-WCH006-XX-M2-S-90000 (EXT. WORKS PLAN)
 - 22182-CCS-WCH006-XX-M2-S-90001 (EXT. WORKS TYPICAL DETAILS)
 - 22182-CCS-WCH006-XX-M2-S-93000 (BGD PLAN)
6. REFER TO FOLLOWING SQUAREYARD DRAWINGS FOR LANDSCAPING GENERAL ARRANGEMENT & DETAILS:
 - 2301-SQU-XX-00-DR-L-001

T3	DETAIL 20 UPDATED TO SHOW FURTHER MANUFACTURES INSTALLATION INFORMATION.	28.08.24	JF	KLE
T2	DETAIL 20 UPDATED TO SHOW FURTHER REQUIRED INFORMATION	22.07.24	JF	KLE
T1	STAGE 04 ISSUE	31.05.24	JF	KLE
P1	STAGE 03 ISSUE	26.04.24	JF	KLE
REV.	DESCRIPTION	DATE	DRW.	CHK.

Tender Issue - For Costing Purposes Only



APPOINTED PARTY LOGO/INFORMATION



PROJECT
CDC - CARDIORESPIRATORY,
WITHINGTON COMMUNITY HOSPITAL

TITLE
PROPOSED BELOW GROUND DRAINAGE -
TYPICAL DETAILS SHEET 2 OF 2

STATUS D2	PURPOSE OF ISSUE FOR COSTING
--------------	---------------------------------

DRAWN BY JF	CHECKED BY KLE	DATE APRIL '24
----------------	-------------------	-------------------

SCALE (@A1) AS SHOWN	PROJECT NUMBER HE-014
-------------------------	--------------------------

FILE DRAWING NUMBER 22182-CCS - WCH006- XX- DR - S - 93002	REV. T3
---	------------