


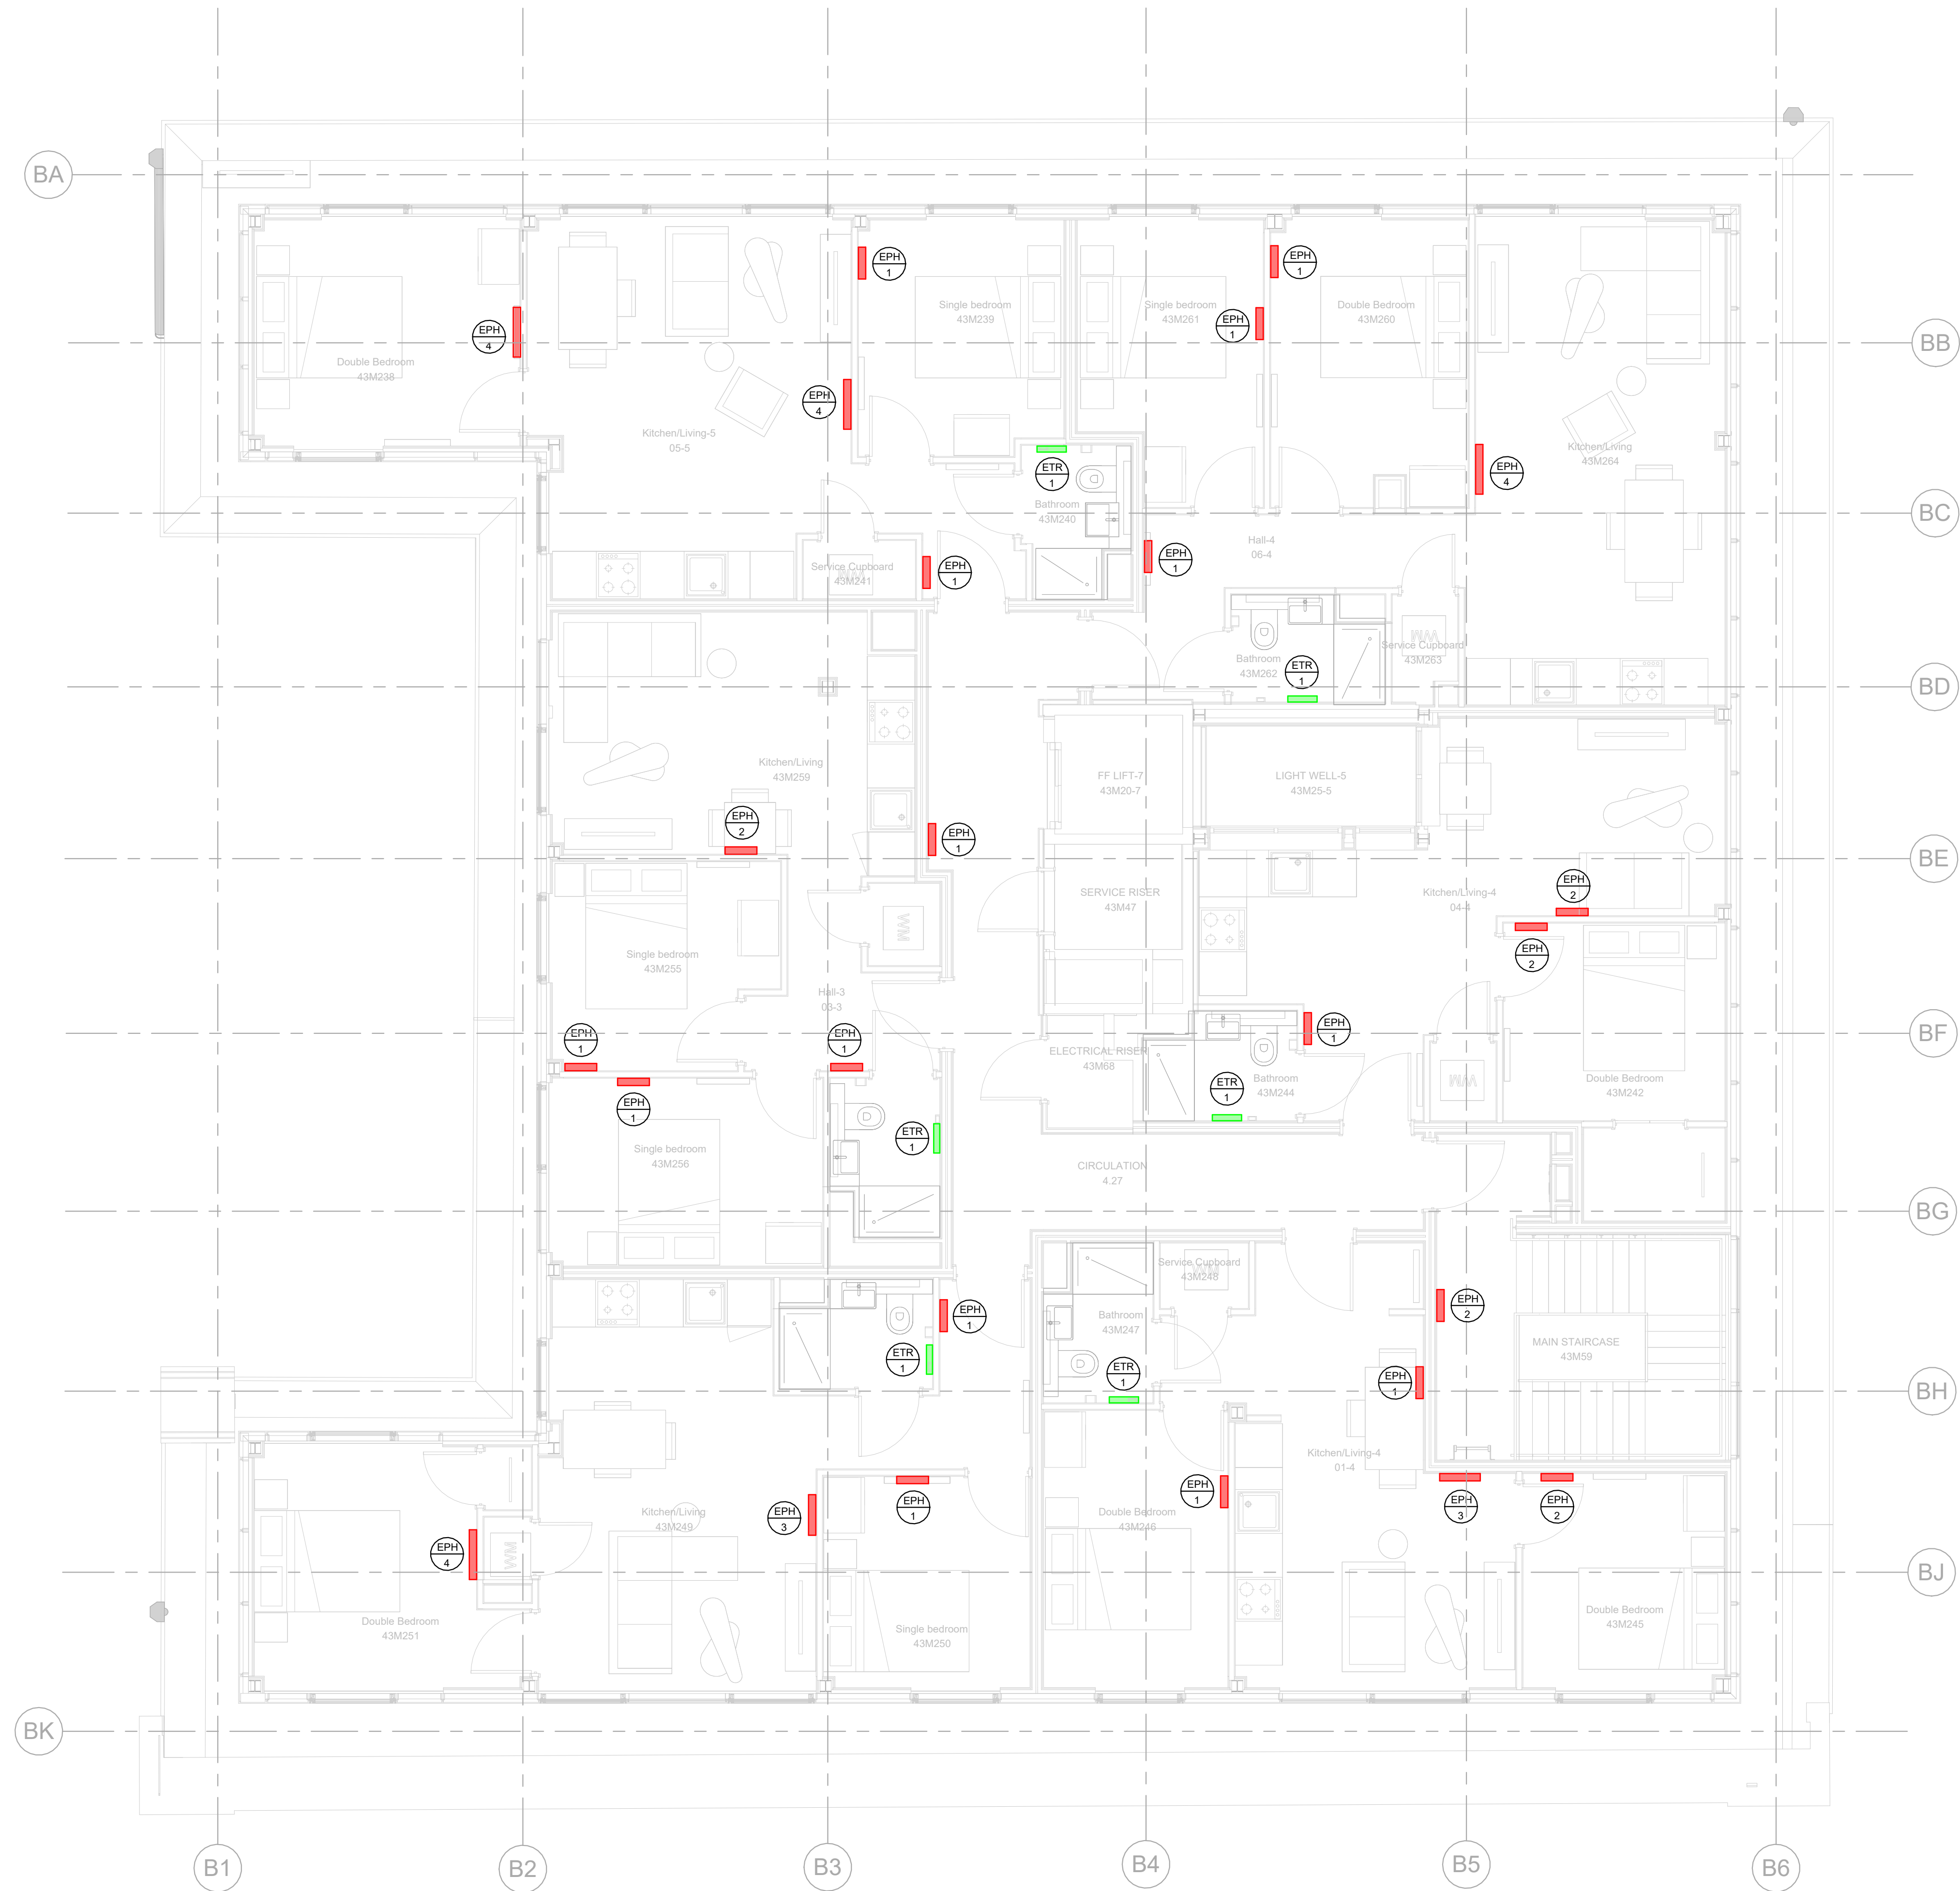

1 560-05-01-HEATING
1 : 50

HEATING NOTES

- THIS DRAWING SHALL BE READ IN CONJUNCTION WITH ALL OTHER RELEVANT PROJECT DRAWINGS AND DOCUMENTATION BEFORE COMMENCING WORK.
- THIS DRAWING SHALL BE READ IN CONJUNCTION WITH THE M&E SERVICES SPECIFICATION. ANY DISCREPANCIES BETWEEN THE DRAWINGS AND THE SPECIFICATION SHALL BE BROUGHT TO THE ATTENTION OF THE ENGINEER.
- DO NOT SCALE FROM THIS DRAWING.
- THERE SHALL BE NO CHANGES TO THE PROPOSALS WITHOUT THE AGREEMENT OF THE ENGINEER.
- THIS DRAWING SHOULD BE READ IN COLOUR.
- THE CONTRACTOR SHALL PROVIDE OPERATION AND MAINTENANCE MANUALS, AS FITTED DRAWINGS AND BUILDING LOG BOOK IN ACCORDANCE WITH CIBSE TM31.
- CONTRACTOR TO CONDUCT A SITE VISIT PRIOR TO THE SUBMISSION OF A TENDER RETURN TO FAMILIARISE THEMSELVES OF THE SITE AND THE EXTENT OF WORKS REQUIRED - NO CLAIMS SHALL BE MADE FOR ADDITIONAL COSTS AS A RESULT OF THIS NOT HAVING TAKEN PLACE.
- THIS DRAWINGS SHALL BE READ IN CONJUNCTION WITH BOTH THE ARCHITECTURAL DRAWINGS IN PARTICULAR THE HERITAGE DRAWINGS SHOWING THE POSITION OF RETAINED CAST IRON RADIATORS.
- THE RADIATORS INDICATED ON THIS DRAWING AND REFERENCES THEREIN ARE SPECIFIC TO THIS DRAWING ONLY AND SHOULD NOT BE USED IN CONJUNCTION WITH ANY OTHER DRAWING.
- THE MECHANICAL CONTRACTOR SHALL CONFIRM ALL RADIATOR SIZES AND FINISHES WITH THE M&E CONSULTANT AND ARCHITECT PRIOR TO ORDERING.
- THE RADIATOR POSITIONS SHOWN ON THIS DRAWING SHOW THE DESIGN INTENT. FINAL POSITIONS SHALL BE AGREED WITH THE CLIENT.
- CONTRACTOR TO INCLUDE FOR CO-ORDINATING HIS WORK WITH ALL OTHER TRADES IN PARTICULAR WITH THE ELECTRICAL CONTRACTOR TO ENSURE POWER SUPPLIES FOR THE HEATERS ARE PROVIDED IN THE CORRECT POSITIONS.
- EQUIPMENT SHALL BE POSITIONED TO ENSURE MANUFACTURERS MAINTENANCE ACCESS REQUIREMENTS ARE PROVIDED.
- THE CONTRACTOR SHALL ALLOW FOR SCHEDULING AND PROGRAMMING OF ALL THE ELECTRIC RADIATORS. SCHEDULES, TEMPS ETC. ARE TO BE CONFIRMED WITH THE CLIENT.


HEATING LEGEND

-  Electric Panel Heater
-  Electric Towel Rail
-  EPH XX Electric Panel Heater Reference
-  ETR XX Electric Towel Rail Reference

28/11/2024	Revised Based on Updated Arch Model	P03	MS/UR
28/06/2024	Revised to Suit Design Team Comments	P02	UR
14/06/2024	Issued for Tender	P01	UR

Date	Description	Rev.	By
------	-------------	------	----

Revision Description

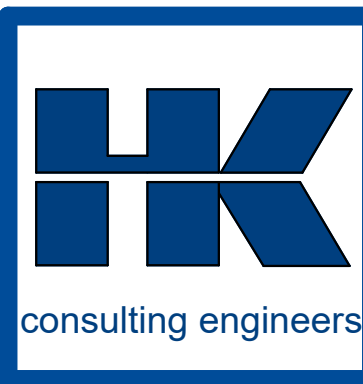

Manchester Office
2 Commercial Street
Castlefield
Manchester
M15 4RQ
T: 0161 832 2030
E: hk.manchester@huley.co.uk

...Making Buildings Work

Project:
Piccadilly Warehouse, Bloom Street

Drawing Title:
HEATING LAYOUT LEVEL 05

ISO 19650 Drawing Number:
24006-HAK-BS-05-DR-M-56001

Project	Originator	Functional Breakdown	Special Breakdown	Form	Discipline	ServiceNumber
---------	------------	----------------------	-------------------	------	------------	---------------

Scale: As indicated **Creation Date:** 10/06/2024
Revision: P03 **Rev Date:** 28/11/2024

Drawn By: S.Miah **Checked By:** A.Moore
Approved By: P.Metcalf

Arch Rev: 24006-HFR-BS-ZZ-M3-A-9801_P3
Struct Rev: N/A

Issue Status:
TENDER