


1:200 0 2 4 6 8 10 12 14 16 18 20 30 40m

Rev:	Description:	By:	Date:
------	--------------	-----	-------

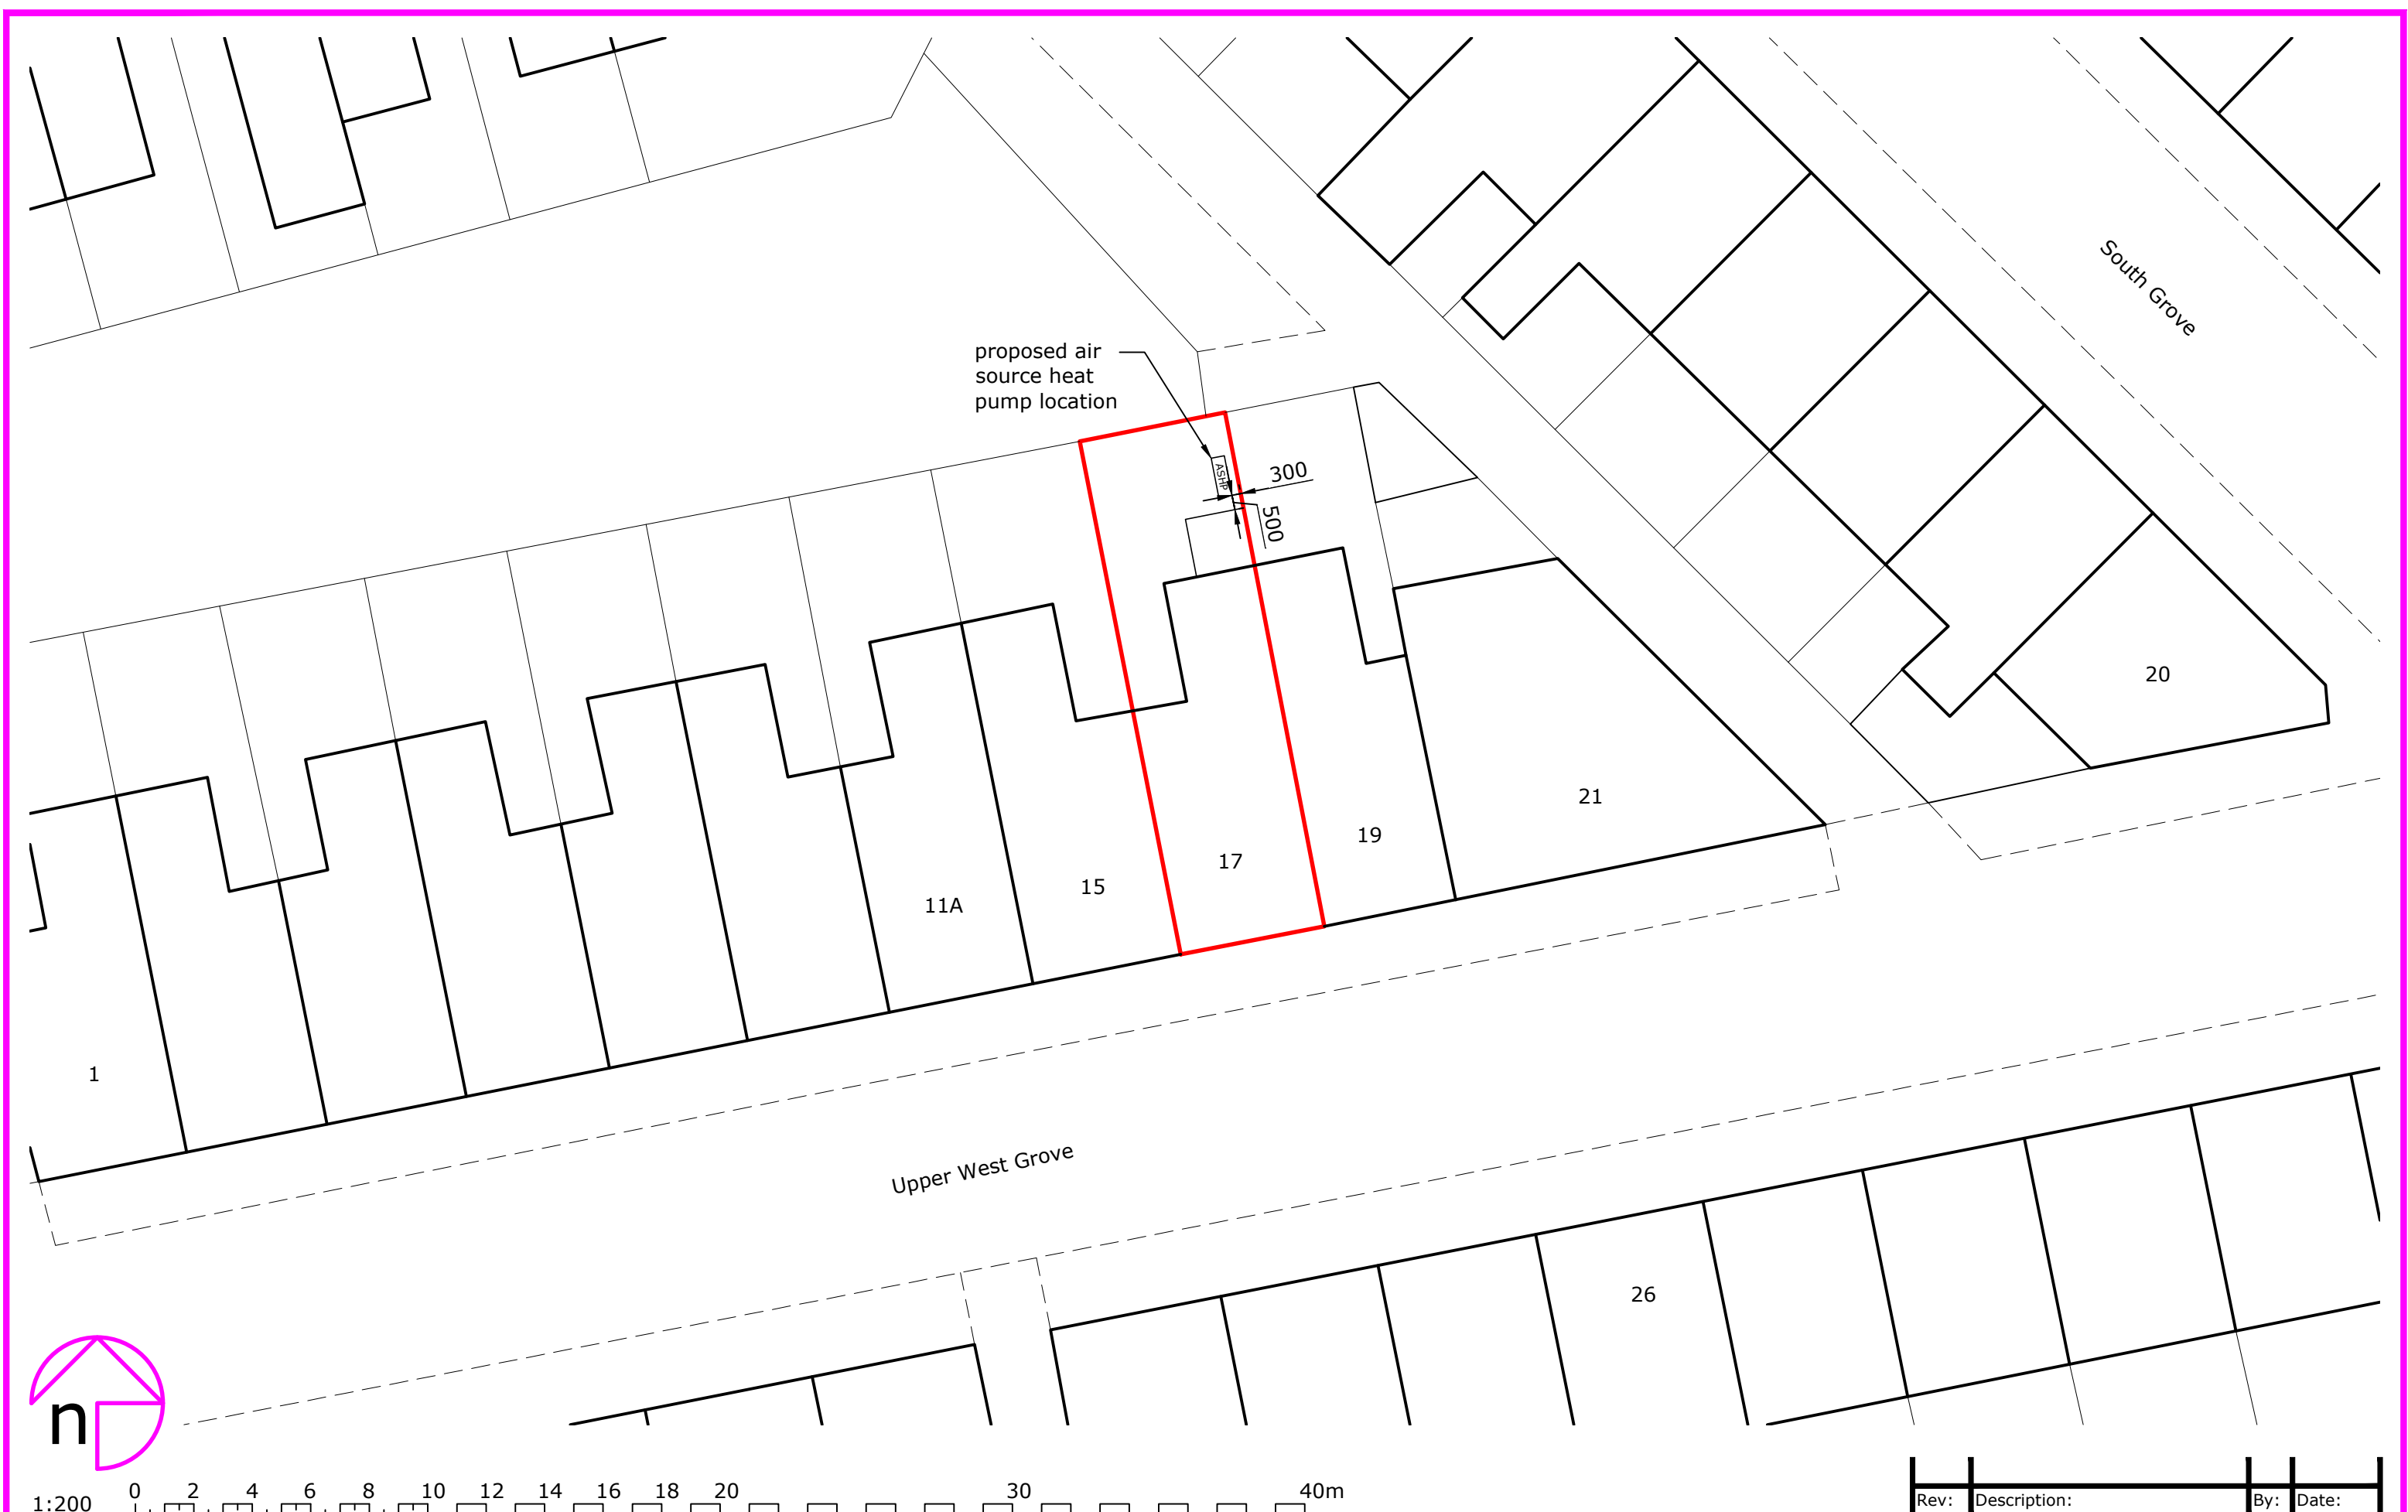

octopusenergy
services

Approved by:



Client/Project: Paul Keeble, 17 Upper West Grove, Manchester, Greater Manchester, M13 0BB	Project status: PLANNING (installation of air source heat pump)
	Drawing title: Site plan as proposed

Scale: 1:200	Paper Size: A3	Drawn: A Walton	Checked: ...
Project ID: J-9D540205	Drawing No: 03	Revision:	Date: 09.01.2025