
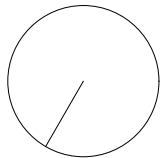


GUN STREET

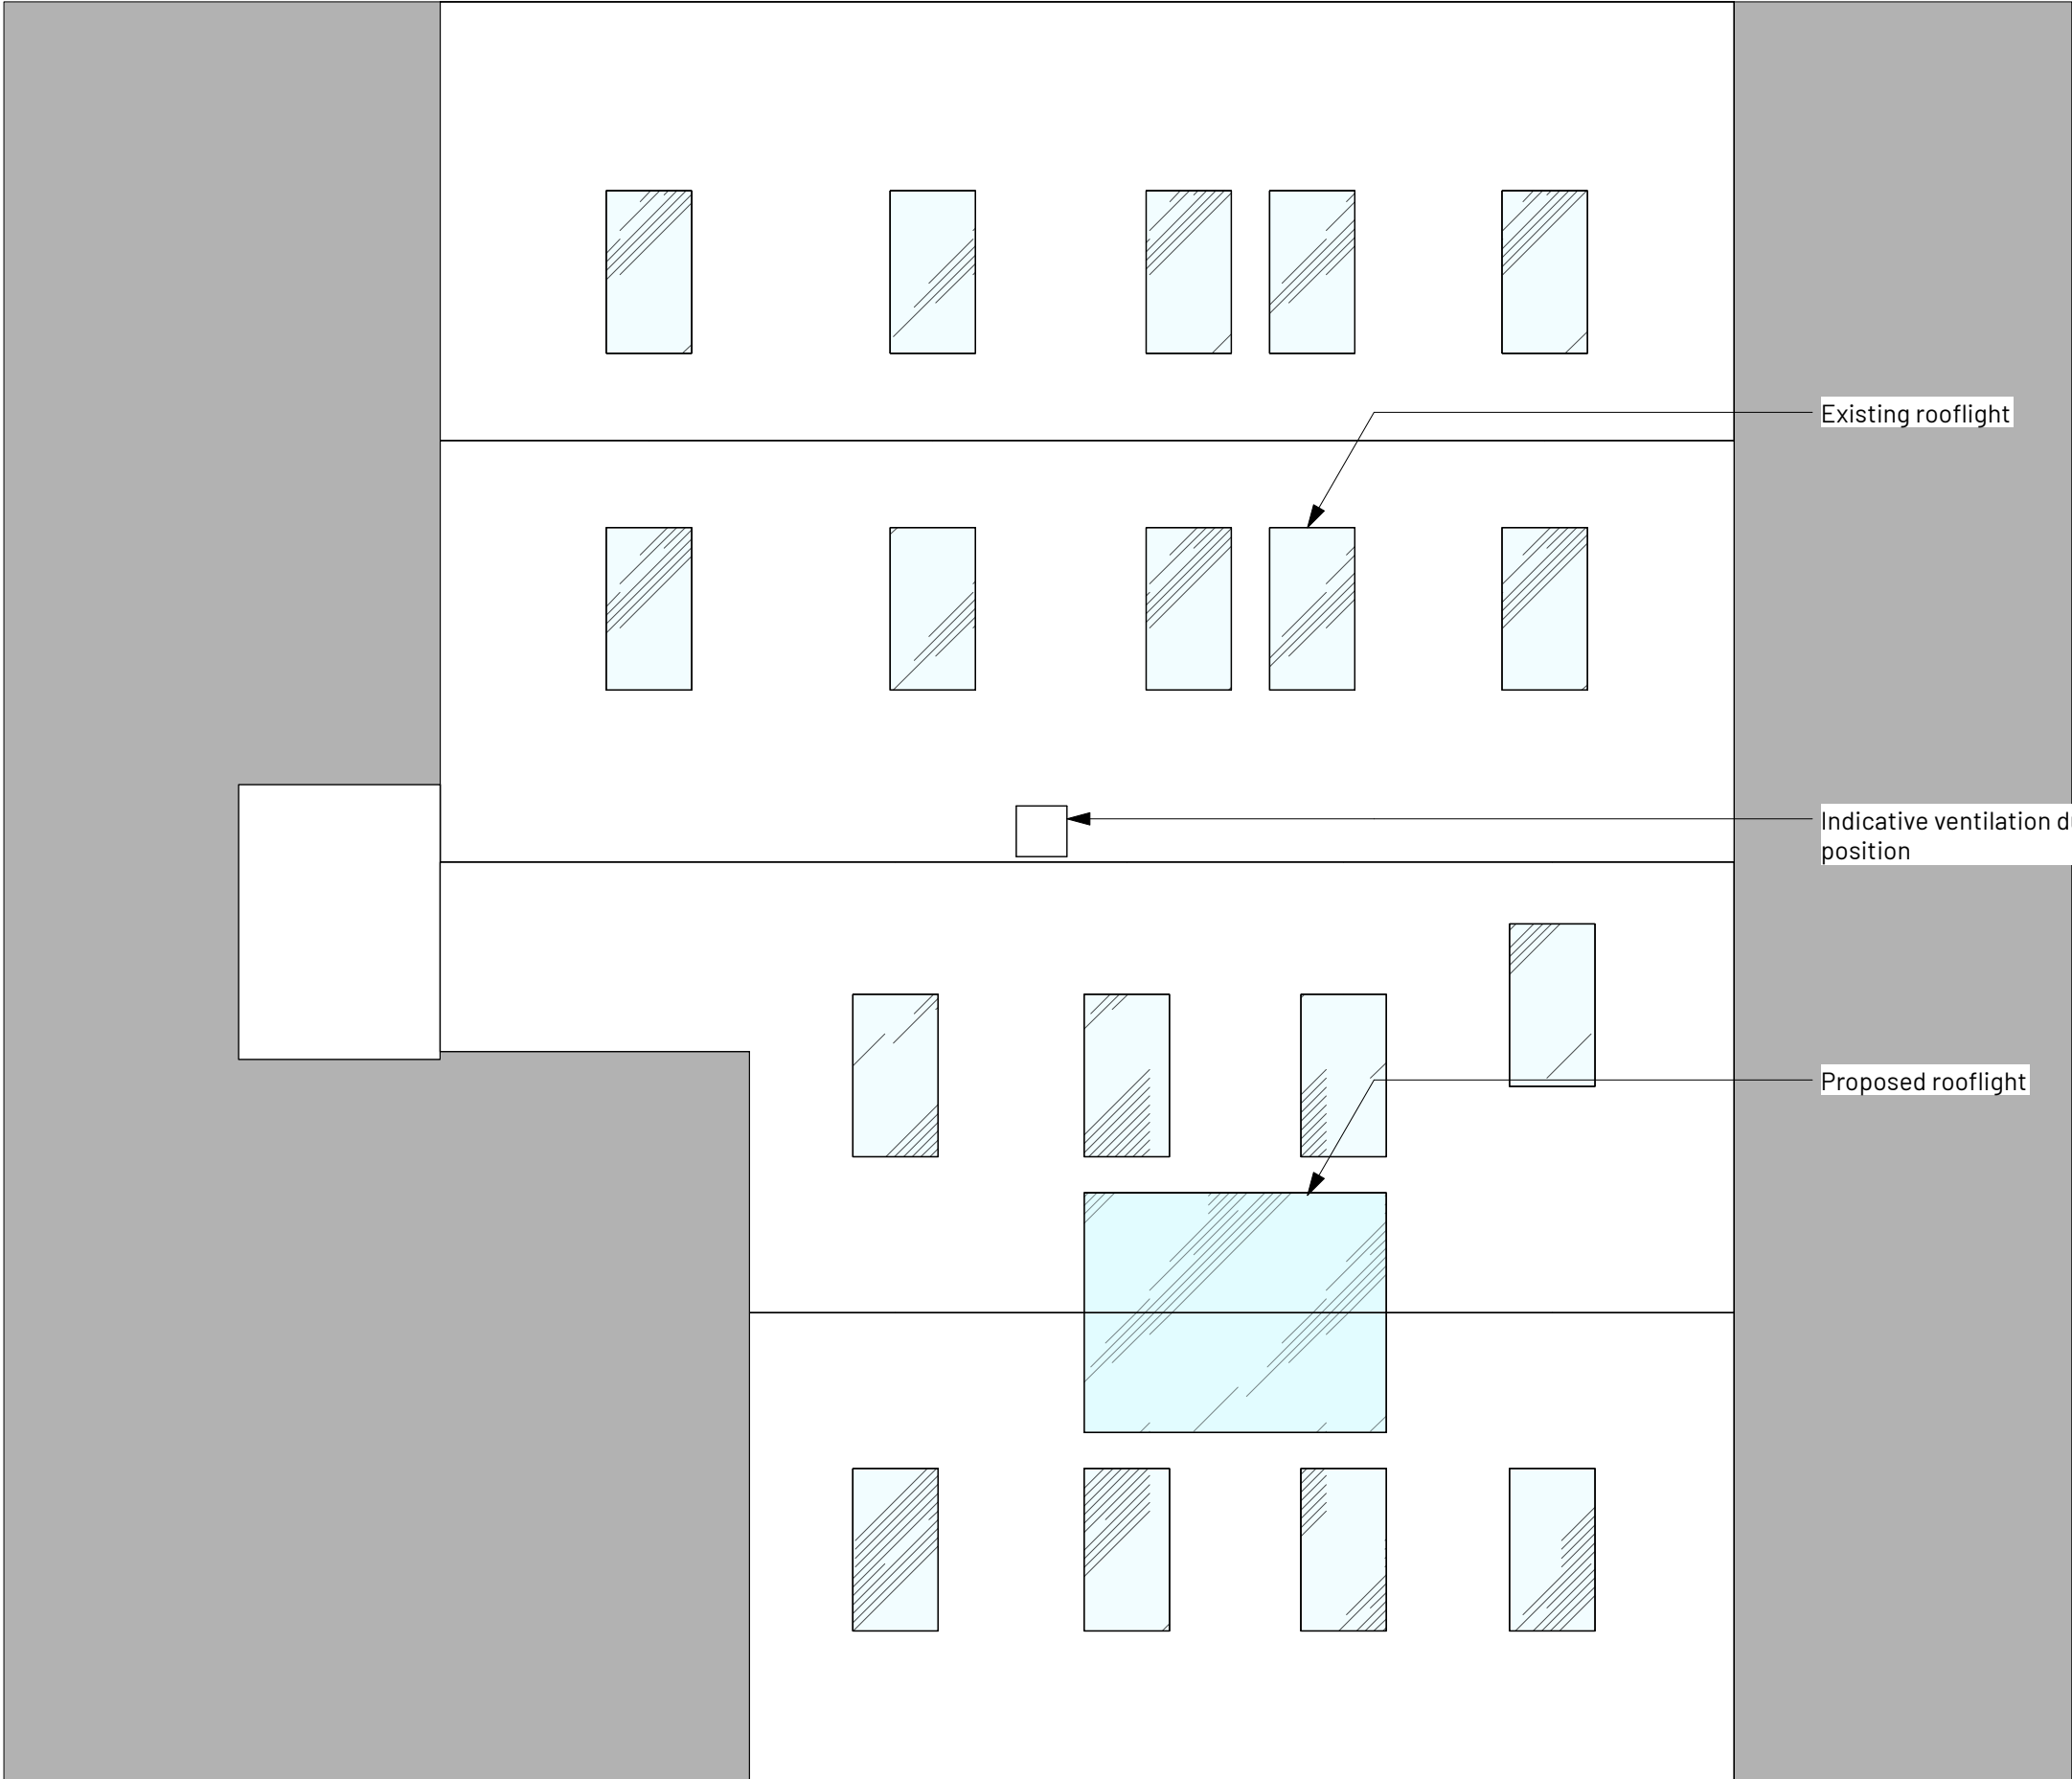

Existing rooflight

Indicative ventilation duct outlet position

Proposed rooflight

A
12/12/2024
Various updates following client comments.
REV | NOTE | DRN | CHK

Blossom Market

 
Roof Plan - Proposed

PROJECT REF. 2062
DRWG NO. P(120)
REVISION A
SCALE 1:100 @ A3
DATE 1st Oct
DRAWN RG

SK sketch E existing P proposed T tender C construction FI final issue

+44 161 236 0051
ARCHITECT@ATELIERMB.CO.UK

ATELIER.MB



1:100 @A3

HENRY STREET