



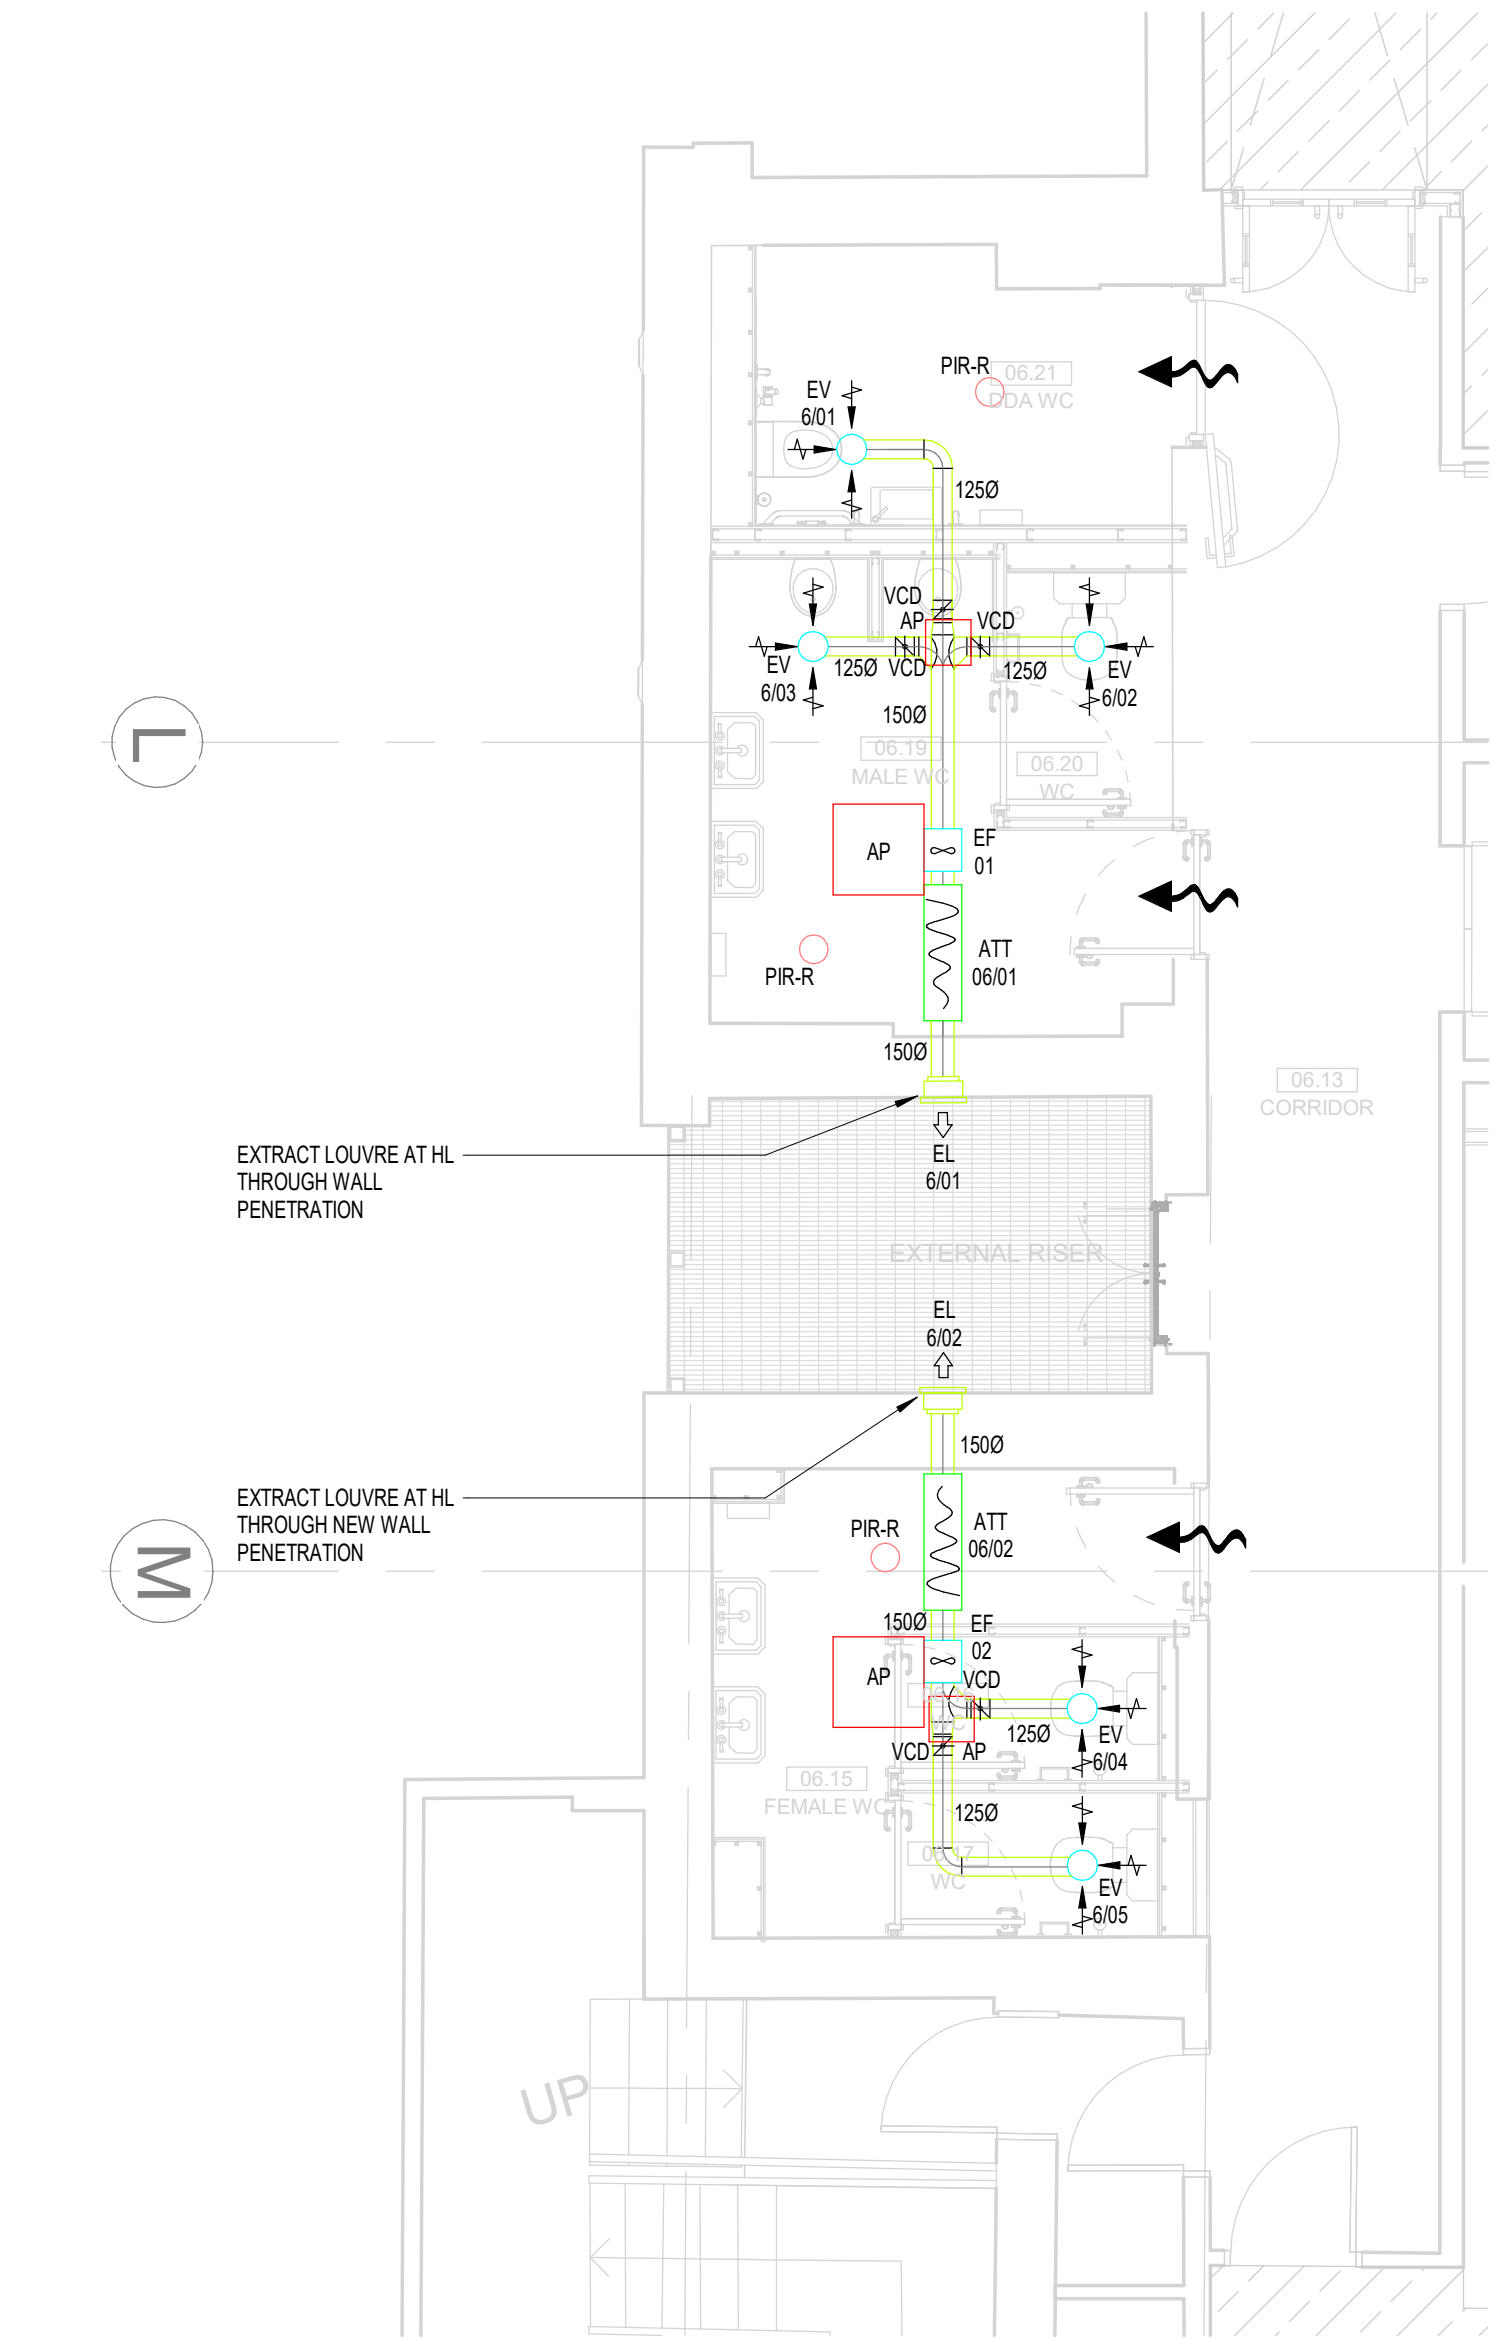

1 MECHANICAL SERVICES VENTILATION LAYOUT LEVEL 06 - BACK OF HOUSE WC
1 : 50

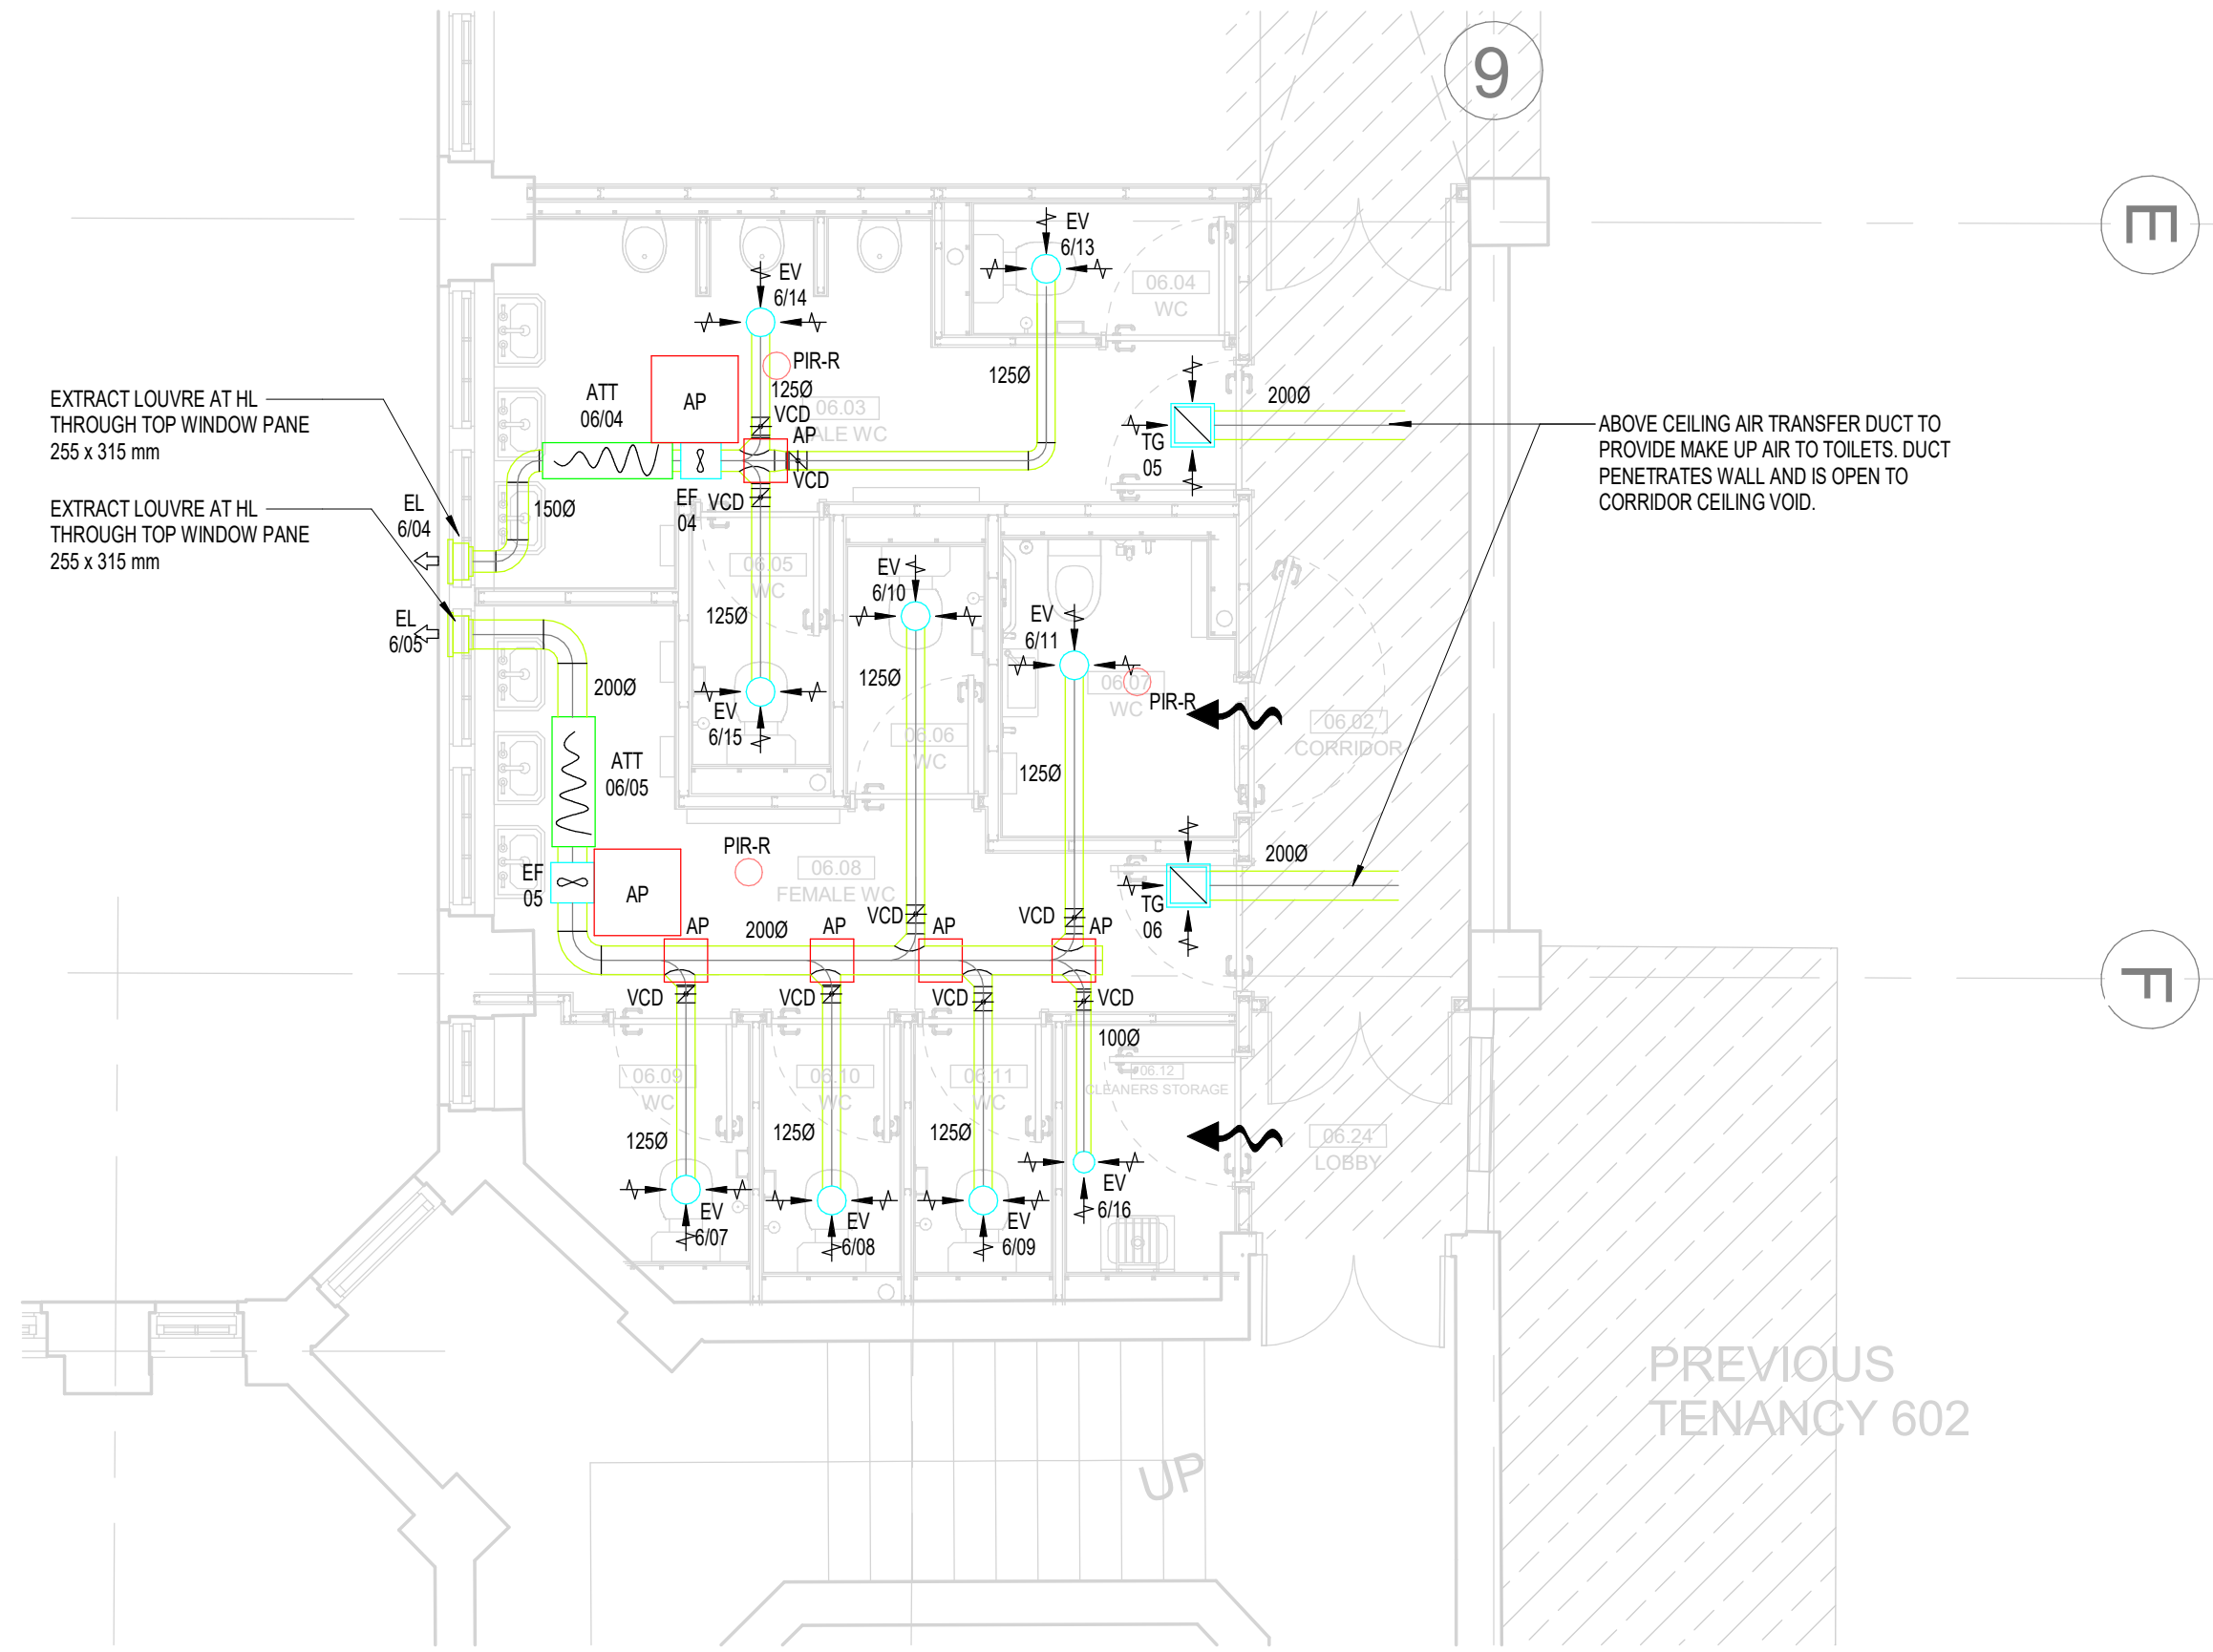

2 MECHANICAL SERVICES VENTILATION LAYOUT LEVEL 06 - FRONT OF HOUSE WC
1 : 50

- LEGEND:
- EF EXTRACT FAN
 - ATT ATTENUATOR
 - VCD VOLUME CONTROL DAMPER (VCD)
 - FD FIRE DAMPER (as VISUAL INDICATOR)
 - SD MOTORISED FIRE/SMOKE DAMPER (as VISUAL INDICATOR)
 - EG EXTRACT GRILLE
 - EGV EXTRACT AIR VALVE
 - SG SUPPLY GRILLE
 - SGV SUPPLY AIR VALVE
 - FCU FAN COIL UNIT
 - 10mm DOOR UNDERCUT (8mm IF FIRE DOOR) (3mm IF SMOKE SEALED DOOR)
 - PIR-R PRESENCE DETECTOR
 - CO2 CARBON DIOXIDE SENSOR
 - AP ACCESS PANEL

- THIS DRAWING IS FOR INFORMATION ONLY DO NOT SCALE
- CDM REGULATIONS
- | NO. | DATE | DATE | DATE |
|-----|------|------|------|
| NO. | DATE | DATE | DATE |
| | | | |
| | | | |
- VENTILATION NOTES:
- THIS DRAWING IS CONFIDENTIAL AND MAY NOT BE USED, COPIED OR DISCLOSED TO ANYONE WITHOUT PERMISSION OF CSD LTD.
 - DRAWINGS TO BE READ IN CONJUNCTION WITH THE TECHNICAL SPECIFICATION.
 - DO NOT SCALE FROM THIS DRAWING.
 - ALL DIMS ARE IN mm UNLESS INDICATED OTHERWISE.
 - SITE VERIFY ALL DIMENSIONS PRIOR TO CONSTRUCTION.
 - REPORT ALL DISCREPANCIES TO THE DRAWING ORIGINATOR IMMEDIATELY.
 - THIS DRAWING IS TO BE READ IN CONJUNCTION WITH ALL RELEVANT DOCUMENTS, DRAWINGS AND SCHEMATICS.
 - ALL LEVELS TO BE TAKEN FROM DATUM.
 - FIRE DAMPERS AND FIRE/SMOKE DAMPERS INSTALLED AS PER MANUFACTURERS RECOMMENDED INSTALLATION INSTRUCTIONS, INCLUDING FRAME WORK.
 - TURNING VANES TO BE INCLUDED IN ALL BENDS IN RECTANGULAR DUCTWORK.
 - DUCTWORK TO BE INSTALLED IN ACCORDANCE WITH THE GUIDELINES FOR CLASS C DUCTWORK SET OUT IN DW144 SPECIFICATION FOR SHEET METAL DUCTWORK.
 - 10mm DOOR UNDERCUT (8mm IF FIRE DOOR) (3mm IF SMOKE SEALED DOOR).
 - ACCESS & CLEANING DOORS TO BE FITTED IN DUCTWORK IN ACCORDANCE WITH DW144 TR19.
 - DUCTWORK IN GALVANISED SHEET METAL UNLESS STATED OTHERWISE. INTERNAL SUPPLY DUCTWORK IN ACCORDANCE WITH DW144 CLASS A AIR LEAKAGE. INTERNAL EXTRACT DUCTWORK IN ACCORDANCE WITH DW144 CLASS A AIR LEAKAGE. ALL EXTERNAL DUCTWORK TO BE CLASS A AIR LEAKAGE.
 - DUCTWORK PASSING THROUGH FIRE RATED STRUCTURE FORMING FIRE BARRIERS & COMPARTMENTS SHALL BE PROVIDED WITH FIRE DAMPERS EQUAL TO THE RATING OF THE ELEMENT/COMPARTMENT. FIRE DAMPERS TO BE OF THE FOLDING CURTAIN TYPE WITH BLADES OUTSIDE OF THE AIR STREAM TO PROVIDE MAXIMUM FREE AREA IN THE AIRWAY.
 - ALL GRILLE PLENUM BOXES TO BE INSTALLED BY DUCTWORK SUB-CONTRACTOR (INCLUDING ACOUSTIC LINING).

REV	DATE	AMENDMENTS	BY	CHKD
P02	20.06.24	001 TOILET VENTILATION TERMINATES TO EXTERNAL ROOF	DB	SH
P01	20.06.24	ISSUED FOR COMMENT & APPROVAL	DB	SH

FOR COMMENT & APPROVAL

Commercial Services Design Ltd
Unit 5
Woodside Court
Clayton Wood Rise
Leeds
LS15 8HF
Tel: 0113 3223190
Web: www.csdesign.uk.com

G&H
GROUP OF COMPANIES

CLIENT
G&H BUILDING SERVICES

PROJECT
SUNLIGHT HOUSE
LITTLE QUAY STREET
MANCHESTER M3 3HP

TITLE
MECHANICAL SERVICES
VENTILATION LAYOUT
LEVEL 06

SCALE @ 1:50	DESIGN	CSD 1298	
DRAWN	MM	ENGINEER	DB
STARTED	JUNE 24	ISSUED	AUGUST 24
APPROVED	DB	APPROVED	BW

1298-CSD-XX-06-DR-M-5707 P02

ARCHITECTURE IS BASED ON ANKALY DESIGN
ARCHITECTS DRAWING NO. SJ-HANDPO-06-DR-A-0100
(01) LEVEL 06 PLAN
19/03/2024