

COPYRIGHT




STRUCTURAL WORKS

ALL DIMENSIONS

THIS DRAWING IS PROTECTED UNDER COPYRIGHT.
COPYRIGHT REMAINS THE PROPERTY OF BRAWN DESIGN
LTD UNLESS OTHERWISE ASSIGNED.

ANY STRUCTURAL INFORMATION ON THIS DRAWING IS
INDICATIVE ONLY. NO STRUCTURAL DETAILS TO BE
TAKEN FROM THIS DRAWING. ALL STRUCTURAL DETAILS
TO BE REFERRED TO A STRUCTURAL ENGINEER.

FIGURED DIMENSIONS ONLY TO BE TAKEN FROM THIS DRAWING. DO NOT SCALE. ALL DIMENSIONS TO BE
VERIFIED ON SITE PRIOR TO THE COMMENCEMENT OF WORK. ALL CONTRACTORS MUST VISIT THE SITE
AND BE RESPONSIBLE FOR CHECKING ALL SETTING OUT DIMENSIONS. NOTIFY BRAWN DESIGN LTD OF
ANY DISCREPANCIES PRIOR TO ANY MANUFACTURE OR CONSTRUCTION WORKS.

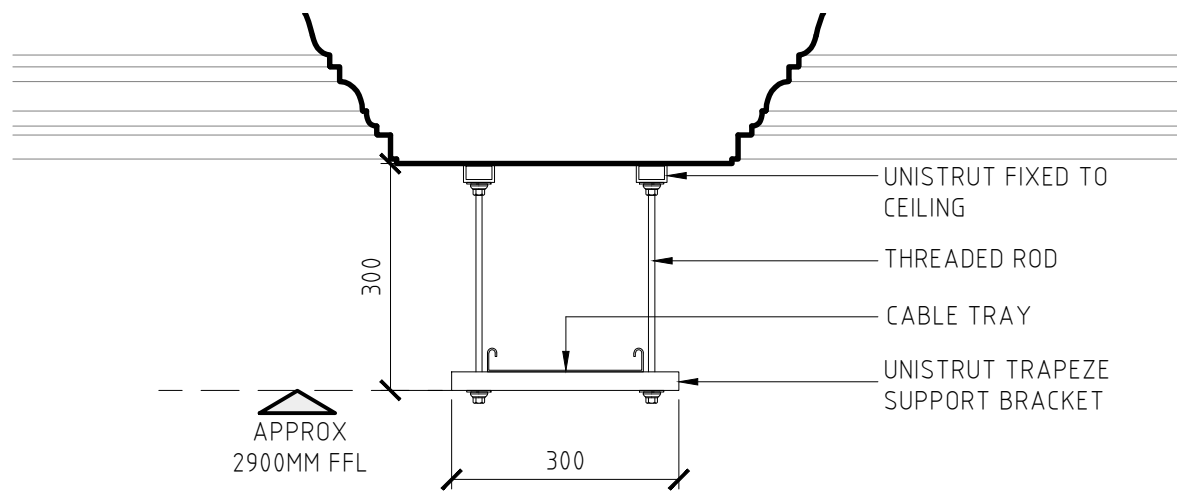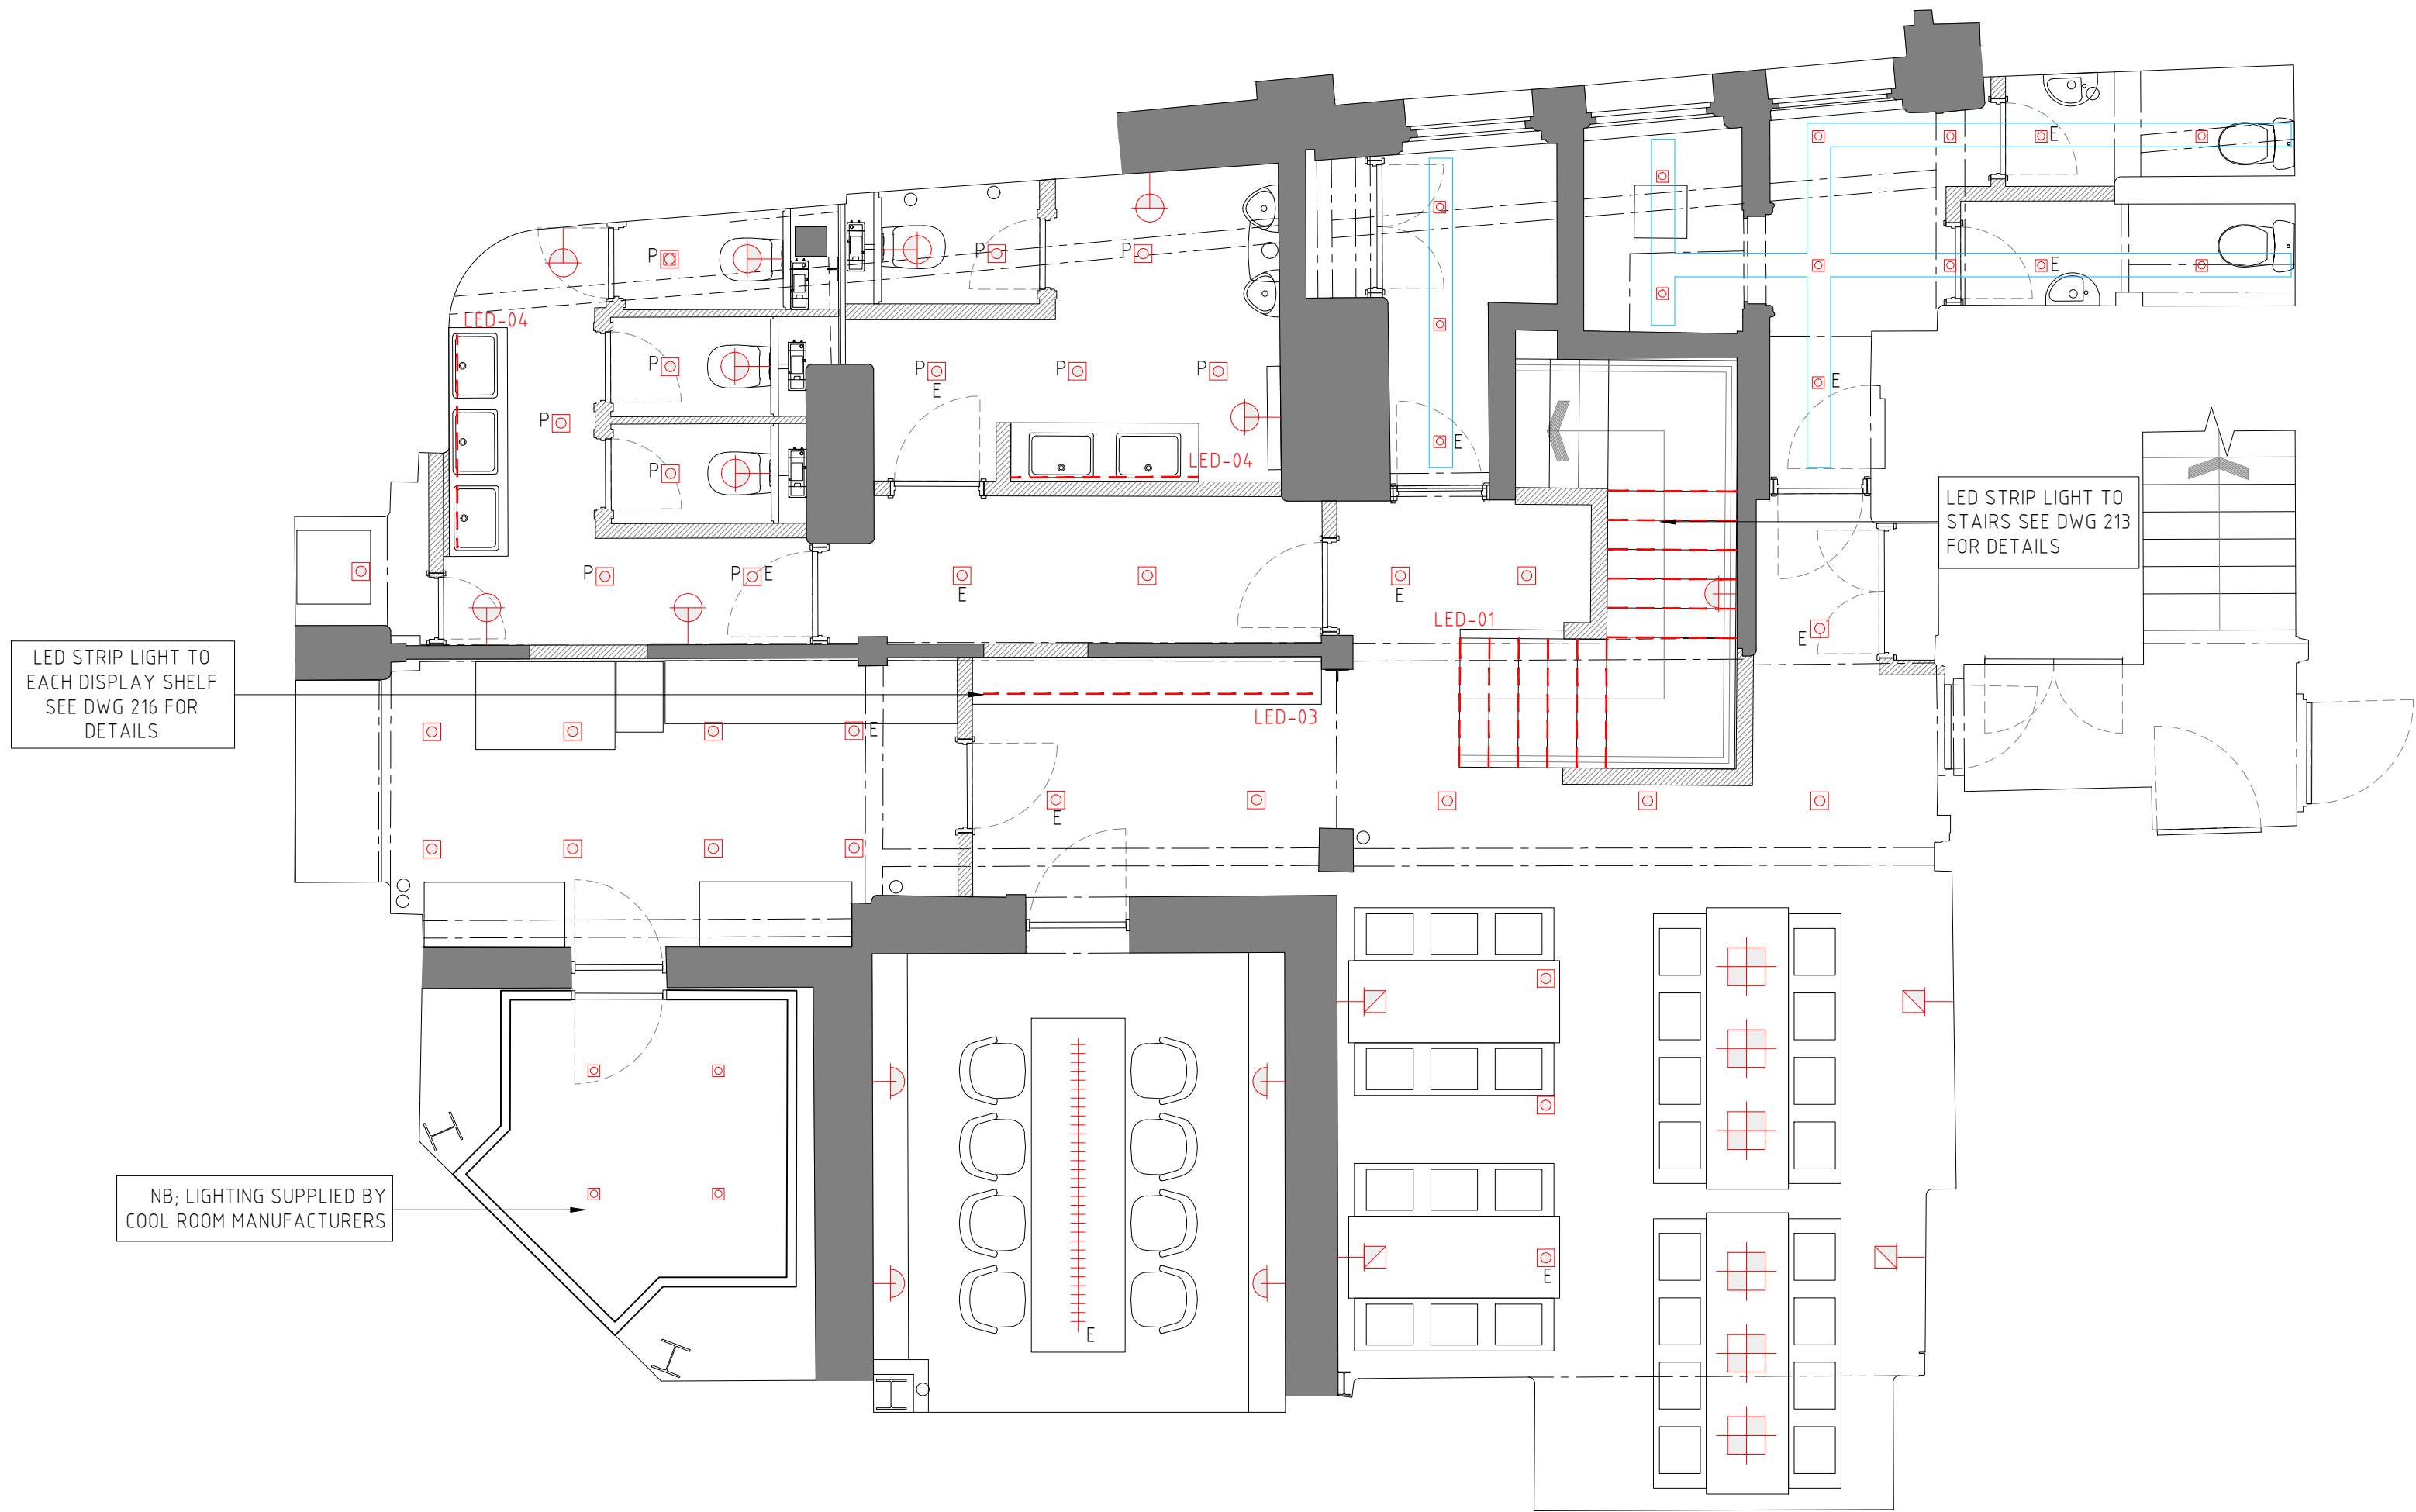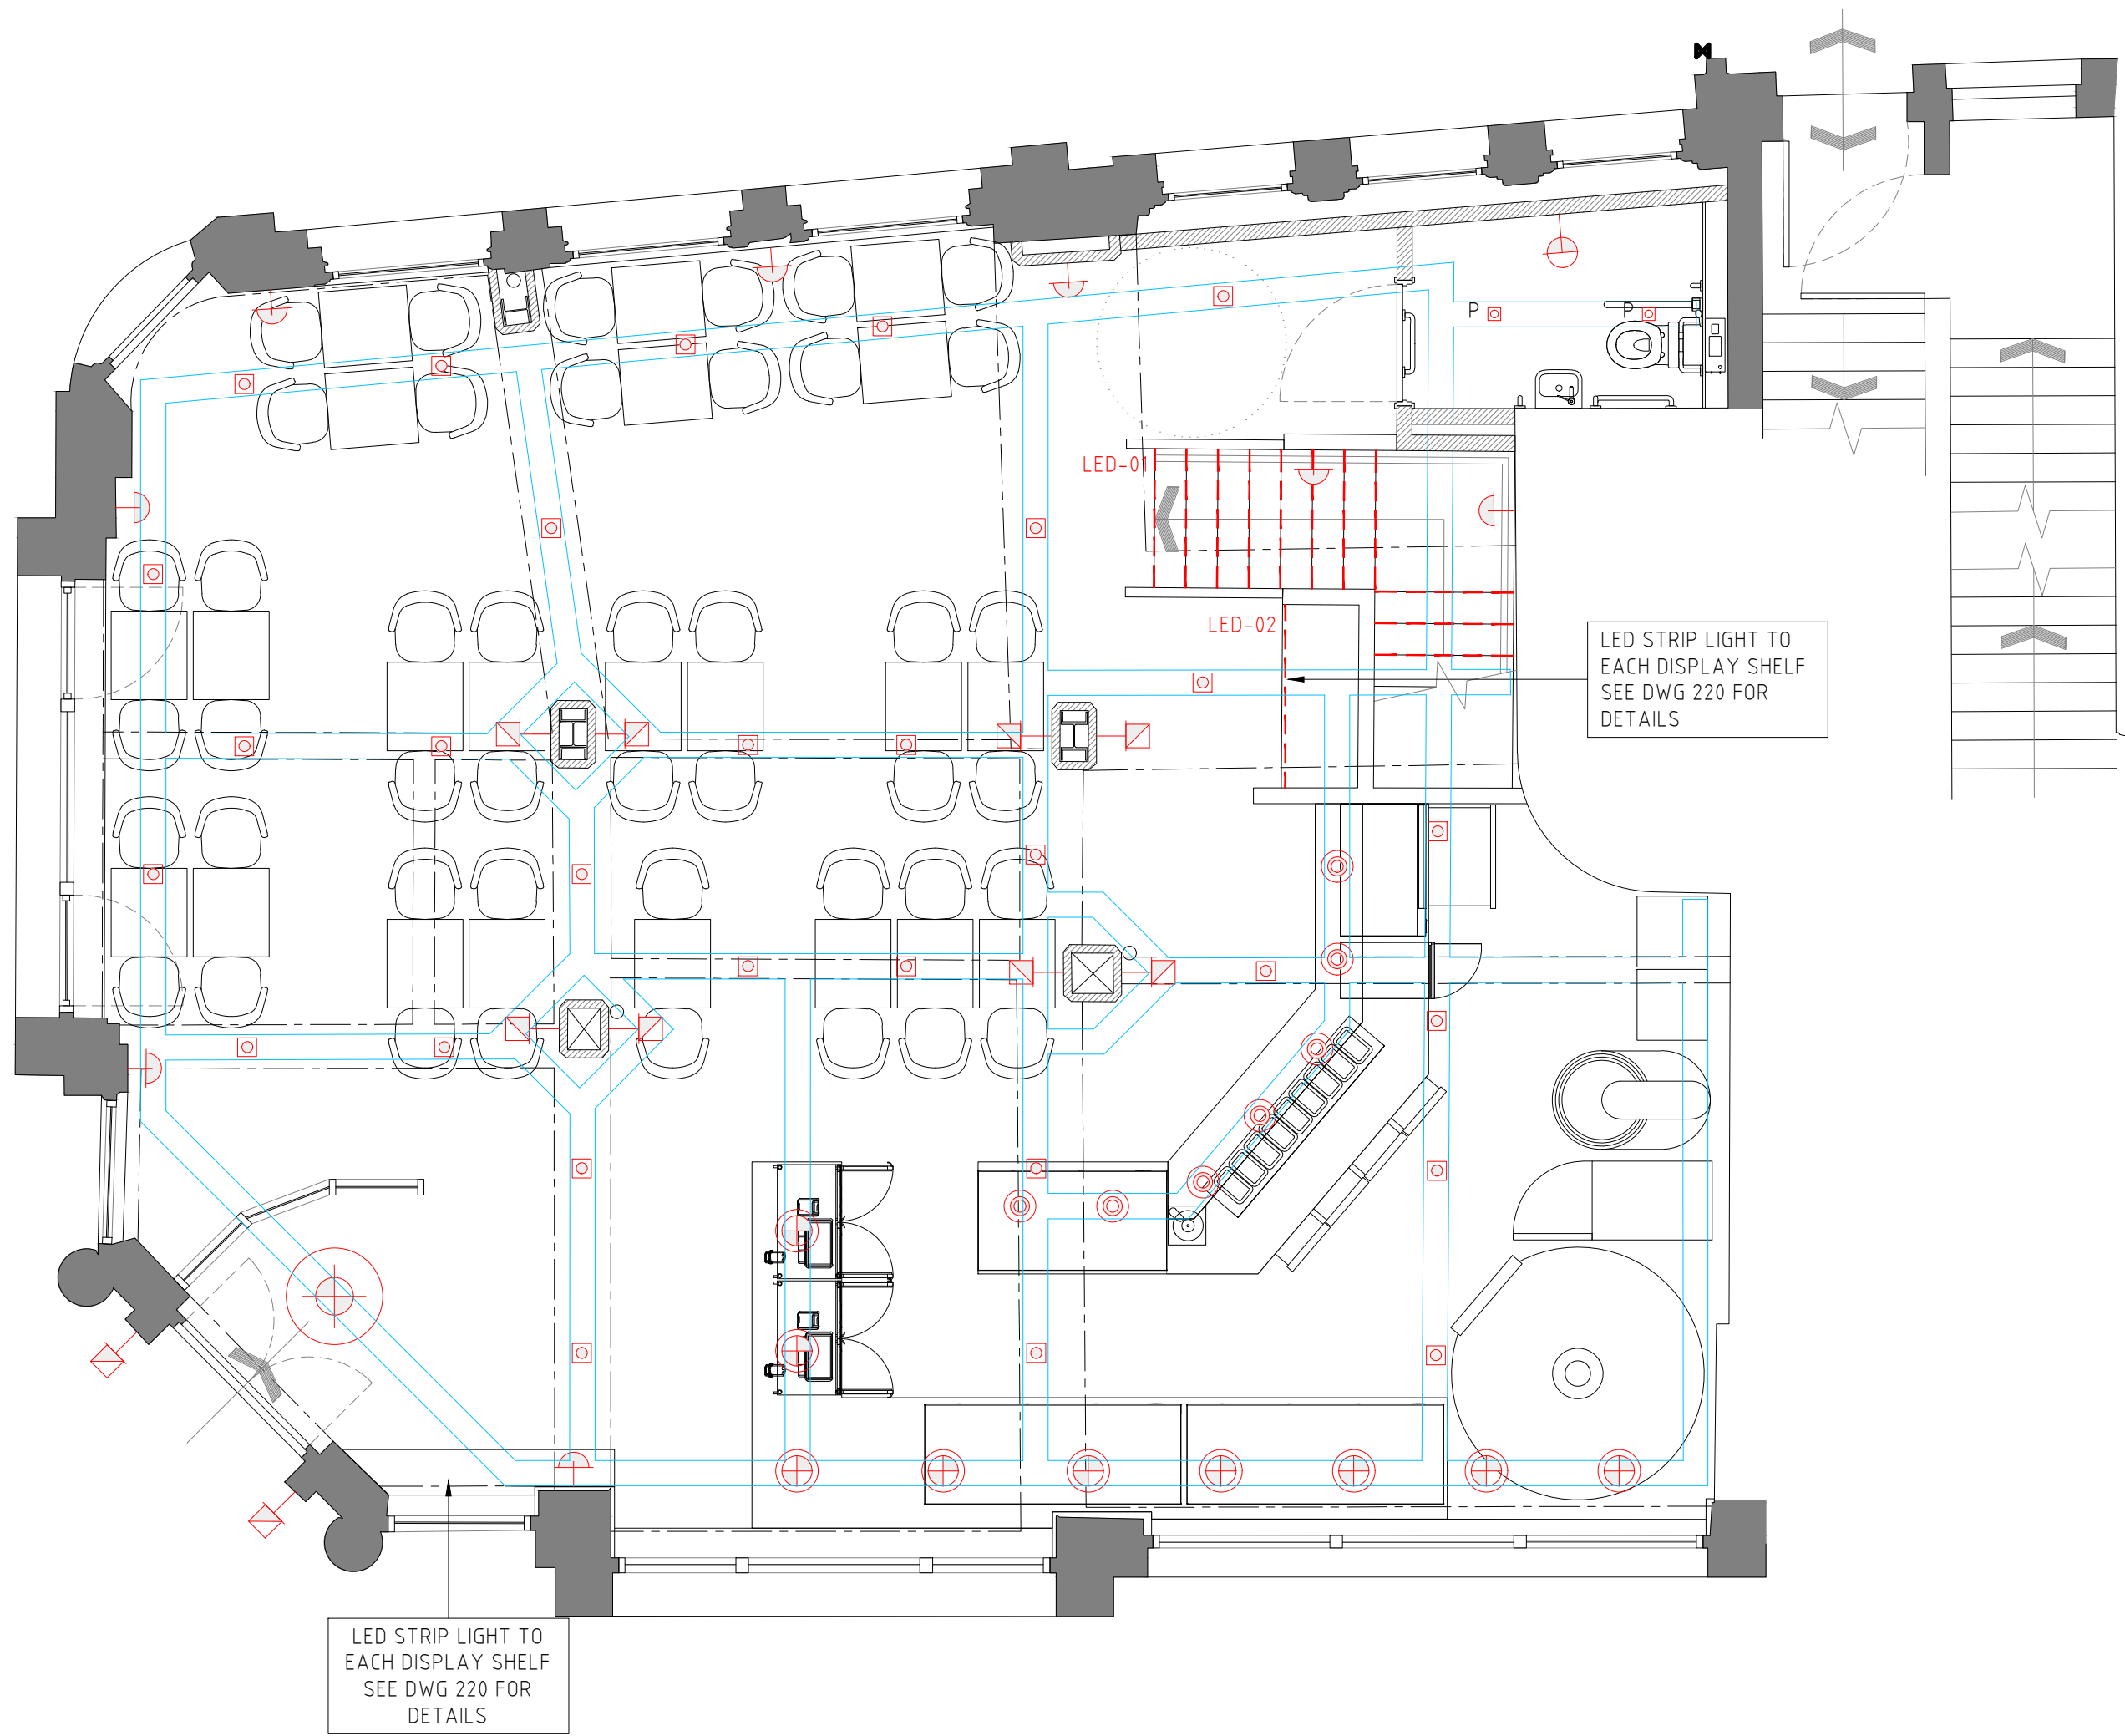

TYPICAL SECTION
THRU' CABLE TRAY
SCALE 1:10

REF	KEY	GENERAL LIGHTING	QTY	SUPPLIED BY
WL-01		DESCRIPTION: INTERNAL GLOBE WALL LIGHTS ON SWAN FINISH: TBC FLEX: TBC LAMP: WARM WHITE	SEE PLAN	LIGHTING SPECIALIST
WL-02		DESCRIPTION: INTERNAL WALL LIGHTS - GLAZED CERAMIC / BULB FINISH: TBC FLEX: TBC LAMP: WARM WHITE	SEE PLAN	LIGHTING SPECIALIST
WL-03		DESCRIPTION: INTERNAL TOILET LIGHTS - GLAZED CERAMIC / BULB FINISH: TBC FLEX: TBC LAMP: WARM WHITE IP RATED	SEE PLAN	LIGHTING SPECIALIST
GL-01		DESCRIPTION: RECESSED SPOT LIGHT (IP RATED) FINISH: TBC FLEX: TBC LAMP: WARM WHITE	SEE PLAN	LIGHTING SPECIALIST
GL-02	P	DESCRIPTION: PIR RECESSED SPOT LIGHT FINISH: TBC FLEX: TBC LAMP: WARM WHITE	SEE PLAN	LIGHTING SPECIALIST
GL-03		DESCRIPTION: 'RECESSED' SPOT LIGHT FINISH: TBC FLEX: TBC LAMP: WITH ADJUSTABLE GIMBLE	SEE PLAN	LIGHTING SPECIALIST
GL-04		DESCRIPTION: 'SURFACE CABLE TRAY' SPOT LIGHT FINISH: TBC FLEX: TBC LAMP: WITH ADJUSTABLE GIMBLE	SEE PLAN	LIGHTING SPECIALIST

REF	KEY	GENERAL LIGHTING	QTY	SUPPLIED BY
LED-01		DESCRIPTION: LED STRIP LIGHT FINISH: TBC FLEX: TBC LAMP: WARM WHITE	SEE PLAN	LIGHTING SPECIALIST
PL-01		DESCRIPTION: CHANDELIER FINISH: TBC FLEX: TBC LAMP: WARM WHITE	SEE PLAN	LIGHTING SPECIALIST
PL-02		DESCRIPTION: TEXTURED CONCRETE PENDANT LIGHT FINISH: TBC FLEX: TBC LAMP: WARM WHITE	SEE PLAN	LIGHTING SPECIALIST
PL-03		DESCRIPTION: GLOBE PENDANT LIGHT FINISH: TBC FLEX: TBC LAMP: WARM WHITE	SEE PLAN	LIGHTING SPECIALIST
PL-04		DESCRIPTION: TIMBER PENDANTS FINISH: TBC FLEX: TBC LAMP: WARM WHITE	SEE PLAN	LIGHTING SPECIALIST
PL-05		DESCRIPTION: TROUGH PENDANT LIGHT FINISH: TBC FLEX: TBC LAMP: WARM WHITE	SEE PLAN	LIGHTING SPECIALIST
EX-01		DESCRIPTION: EXTERNAL WALL LIGHTS FINISH: TBC FLEX: TBC LAMP: WARM WHITE	SEE PLAN	LIGHTING SPECIALIST

FURTHER NOTES;

ALL LAMPS FOR GENERAL & DECORATIVE TO BE 'WARM WHITE' LED, 2000K-2200K SUPPLIED BY SPECIALIST


IT AND SECURITY TO BE WIRED BACK TO COMMS CUPBOARD

ALL ELECTRICAL CABLING TO BE WIRED BACK TO DISTRIBUTION BOARDS WITHIN COMMS CUPBOARD

ALL SMALL POWER ITEMS AND LED FITTINGS TO BE SUPPLIED BY ELECTRICAL CONTRACTOR

ALL BATHROOM FITTINGS TO BE IP44 FITTINGS

PROPOSED RUNS OF CABLE TRAY HUNG FROM EXISTING BEAMS

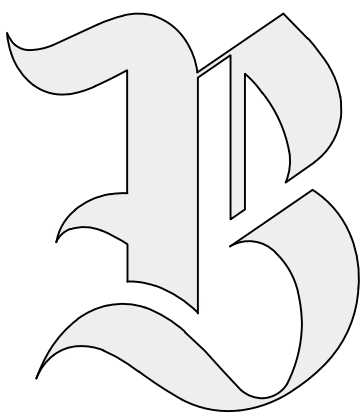

BRAWN DESIGN LIMITED.

BIZ HUB, ROOM G01, MELTON COURT, GIBSON LN,
NORTH FERRIBY, HU14 3HH
EMAIL: RICHARD@BRAWNDESIGN.CO.UK
MOBILE: 07985 344636

CLIENT

INDIVIDUAL RESTAURANTS/
FORBICI

PROJECT

MANCHESTER
CROSS STREET

DRAWING TITLE

PROPOSED
LIGHTING PLAN

JOB NUMBER

2405

DRAWING NUMBER

208

REVISION

C2

SCALE

1:50

DRAWN BY

BN

APPROVED BY

DIRECTOR

REV

C1

22-08-24

C2

26-11-24

NOTES

INITIAL PLAN FOR DISCUSSION
PROPOSED CABLE TRAY RUNS ADDED TO PLAN

BY

RCN

SCALE BAR

1:50

1:100

