
 


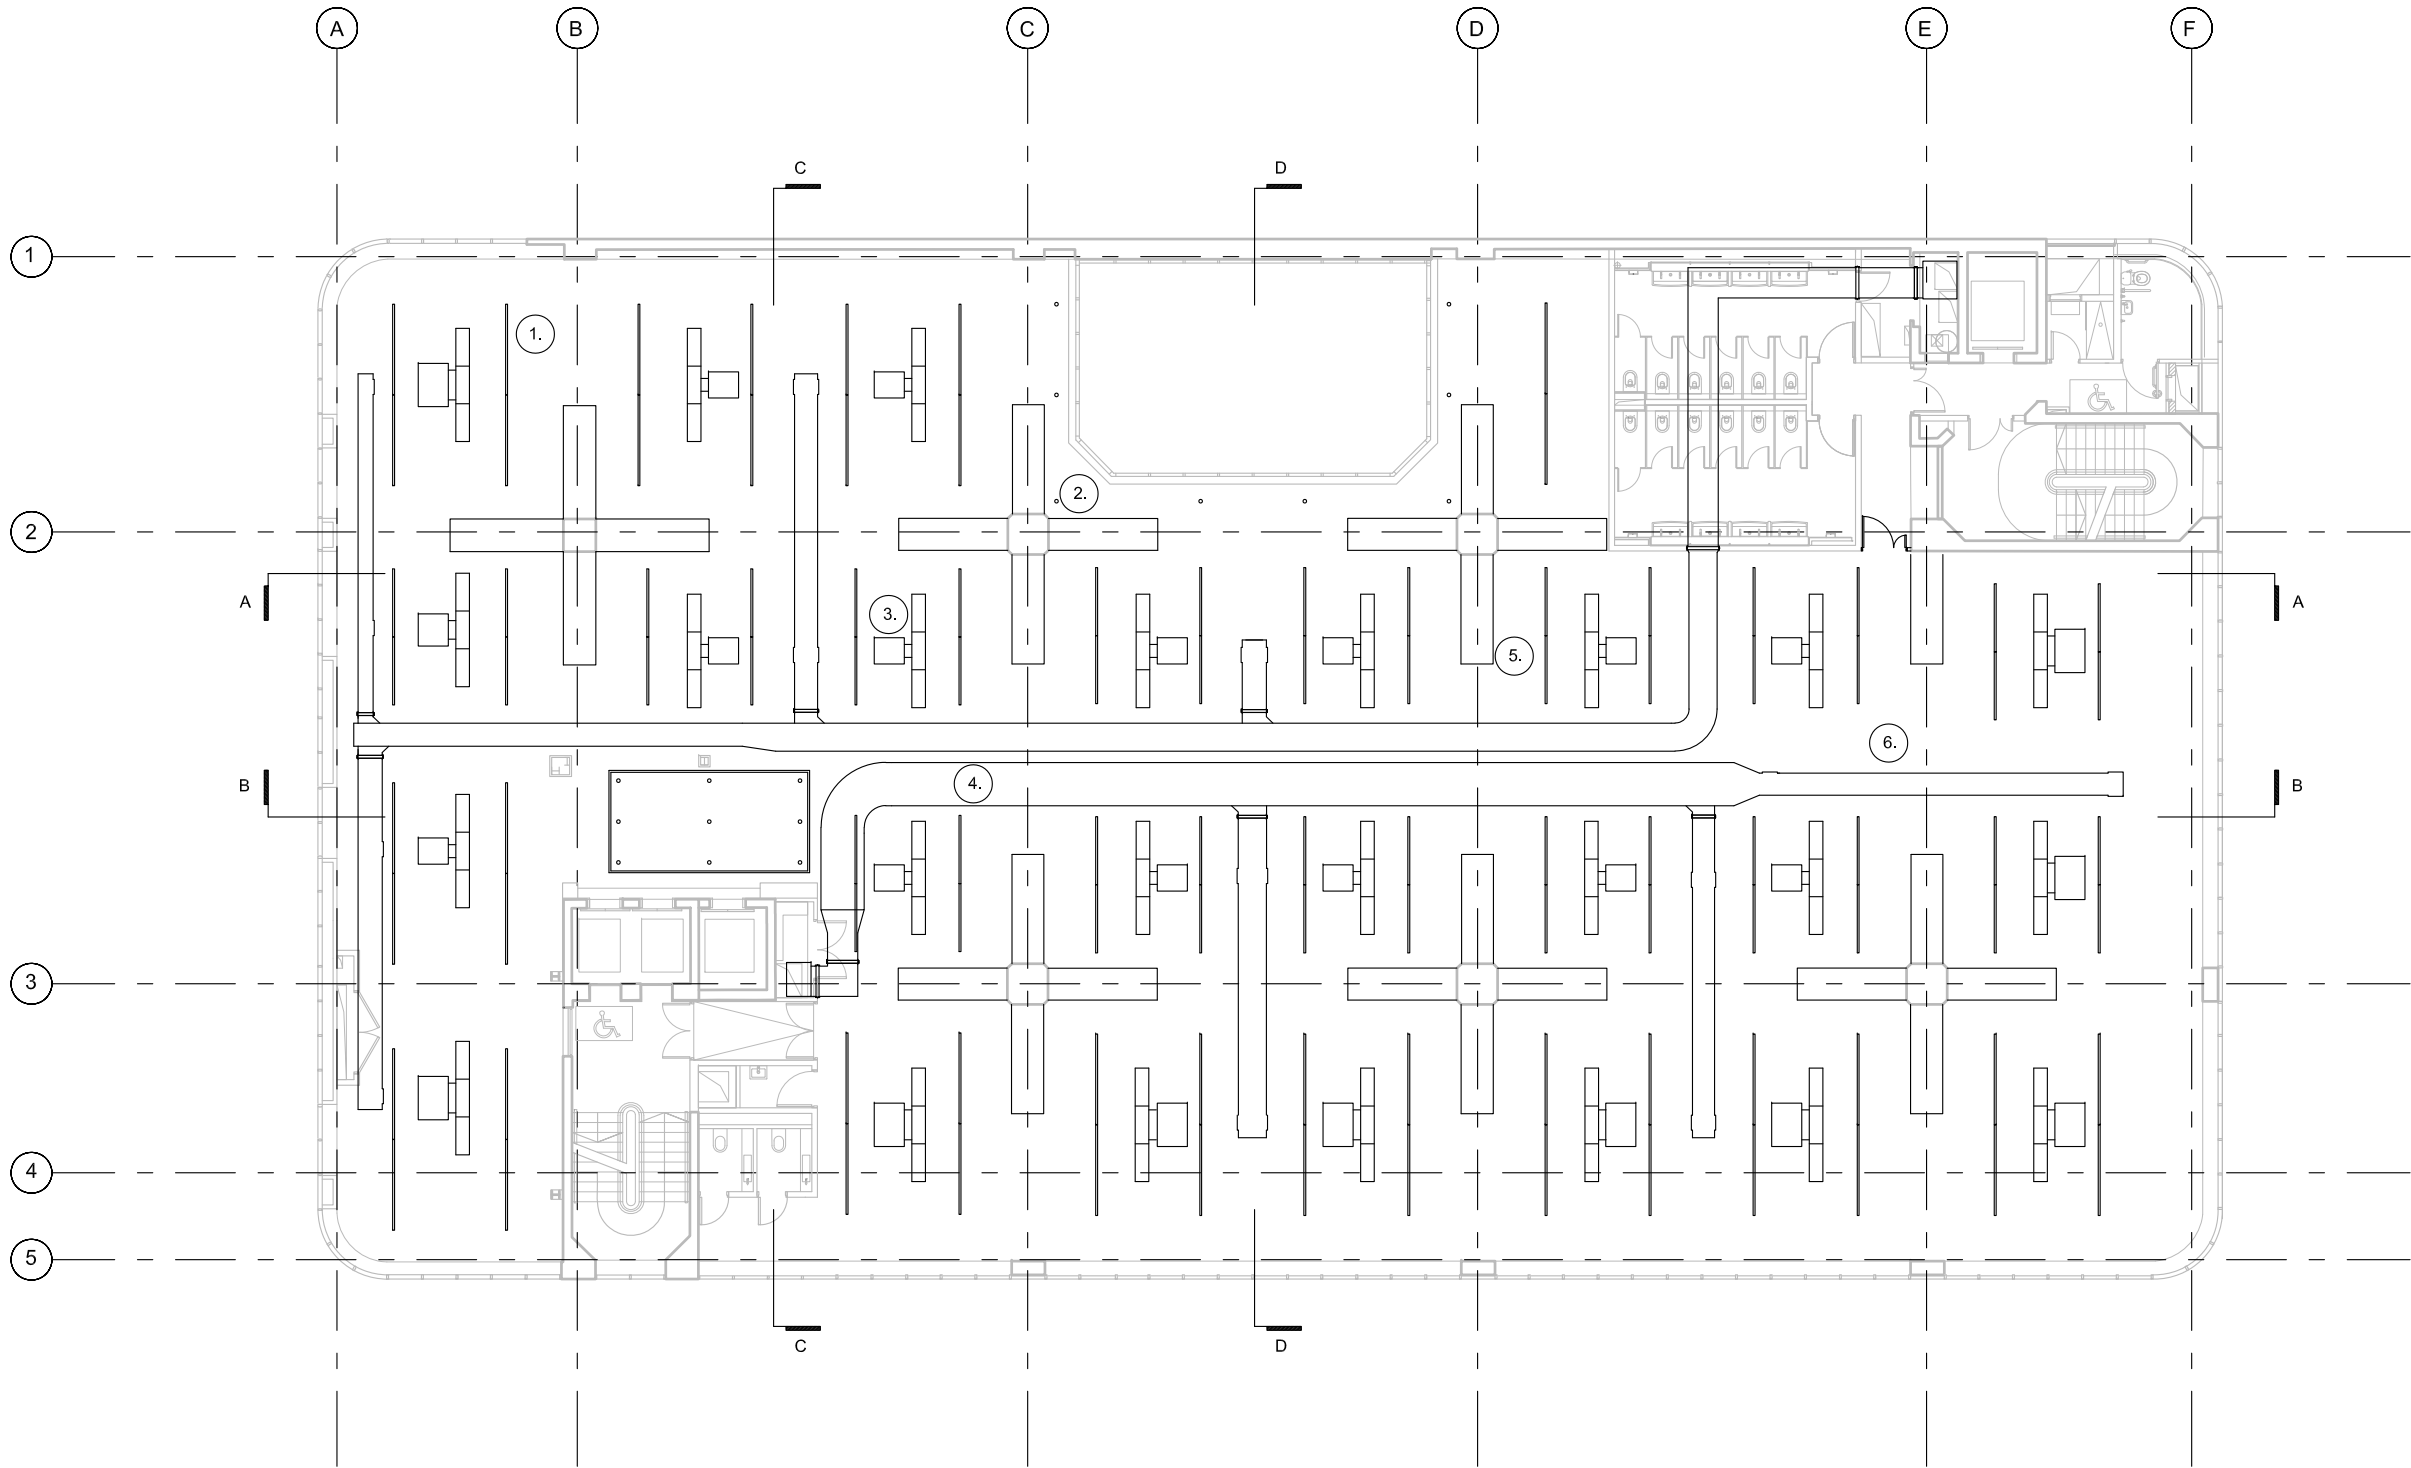

- Drawing Key
- 1. Existing suspended strip lights
 - 2. Existing recessed lights
 - 3. Existing fan coil units
 - 4. Existing ductwork
 - 5. Existing angled, concrete column heads.
 - 6. Existing drywall ceiling

Existing 3rd Floor Reflecting Ceiling Plan



GENERAL NOTES:

LISTED BUILDING CONSENT
THIS DOCUMENT HAS BEEN PREPARED FOR LISTED BUILDING CONSENT
AND IS SUBJECT TO REVIEW AND MODIFICATION

NOTES:
1. ALL DIMENSIONS ARE METRES
2. THIS DRAWING IS TO BE READ IN CONJUNCTION WITH ALL RELEVANT CONTRACT DOCUMENTS
3. THIS DRAWING IS TO BE READ IN CONJUNCTION WITH ALL ENGINEER'S DRAWINGS
4. DO NOT SCALE FROM THIS DRAWING
5. REPORT ANY ERRORS, CONTRADICTIONS AND OMISSIONS AS SOON AS POSSIBLE
6. THESE PRELIMINARY DRAWINGS HAVE BEEN PREPARED FOR OUR CLIENT, THE DRAWINGS ARE APPROXIMATE ONLY AND ARE SUBJECT TO FURTHER DESIGN DEVELOPMENT, THE BASE FOR THESE DRAWINGS IS RECORD INFORMATION PREPARED BY OTHERS, WHOSE ACCURACY CANNOT BE VERIFIED, WHEN THIS DRAWING IS ISSUED IN .DWG FORMAT IT IS AN UNCONTROLLED VERSION ISSUED TO ENABLE THE RECIPIENT TO PREPARE THEIR OWN DRAWINGS FOR WHICH THEY ARE SOLELY RESPONSIBLE. IT IS BASED ON BACKGROUND INFORMATION CURRENT AT TIME OF ISSUE, KAP STUDIOS ACCEPTS NO LIABILITY FOR ANY SUCH ALTERATIONS OR ADDITIONS TO OR DISCREPANCIES ARISING OUT OF CHANGES TO SUCH BACKGROUND INFORMATION WHICH OCCUR AFTER IT IS ISSUED BY KAP STUDIOS.

REV	DATE	DESCRIPTION

JOB NO:	26 004
BLDG DEPT, NO. /	
SCALE:	1:200 @ A3
STATUS:	Listed Building Consent
DATE:	09/10/24
DRAWING NAME:	Existing 3rd Floor Reflected Ceiling Plan
PROJECT NAME:	40 Princess Street - Express Building
DRAWING NO:	EX C /103



ARCHITECT
T 07728 398 203
E michael.kap@kapstudios.com
W www.kapstudios.com