

**Notes:**

Drawings are based on survey data and may not accurately represent what is physically present.

Do not scale from this drawing. All dimensions are to be verified on site before proceeding with the work.

All dimensions are in millimeters unless noted otherwise.

Purcell shall be notified in writing of any discrepancies.

**Wall Key**

- Existing Fabric
- Proposed Fabric

**Levels Key:**

- + 40200 Proposed Level Internal
- (+ 40200) Existing Level Internal
- + 40200 Proposed Level External
- (+ 40200) Existing Level External
- Levels TBC - All falls shown approximately

**Area Key**

- Hotel (C1)
- Screening Room (B1, A3, A4, D2, C1)
- Unit A (A1, A3, A4)
- Unit F (A1, A3, A4, D2)
- Unit G (A1, A3, A4)
- Unit H (A1, A3, A4)
- Workspace (B1)
- Workspace (B1) shared
- Workspace External (B1)
- Unit K (B1, A3, A4)
- Landlord Areas

**Areas**

See area and occupancy schedule  
240242-PUR-00-XX-SH-A-0007

**Notes:**

All furniture is shown indicatively

Hotel bedroom furniture and bathroom layouts  
as per the General Arrangement Plans as  
produced by Helen Hughes Interior Design.

|      |            |                                                    |
|------|------------|----------------------------------------------------|
| C.12 | 05.07.2024 | Aconex upload - Update to GAs. WC layouts updated. |
| C.13 | 26.07.2024 | Coordination of workspace shower walls             |
| P.23 | 06.12.2024 | Planning issue                                     |

| REV | DATE | DESCRIPTION |
|-----|------|-------------|
|-----|------|-------------|

**CLIENT**

Allied London

**PROJECT**

London Road Fire Station

**JOB NUMBER**

240242

**TITLE**

Proposed Second Floor Plan

| SIZE | SCALE | LAST REVISED | DRAWN | CHECKED |
|------|-------|--------------|-------|---------|
|------|-------|--------------|-------|---------|

A1L As indicated 06/12/2024 10:09:25 JPH


| REV | SUITABILITY/REASON FOR ISSUE |
|-----|------------------------------|
|-----|------------------------------|

P.23 S4 - PLANNING


**DRAWING NUMBER**

LRFS-PUR-00-02-DR-A-0202

St James', 79 Oxford Street, Manchester, M1 6FQ  
© PURCELL 2019. PURCELL IS THE TRADING NAME OF PURCELL ARCHITECTURE LTD.

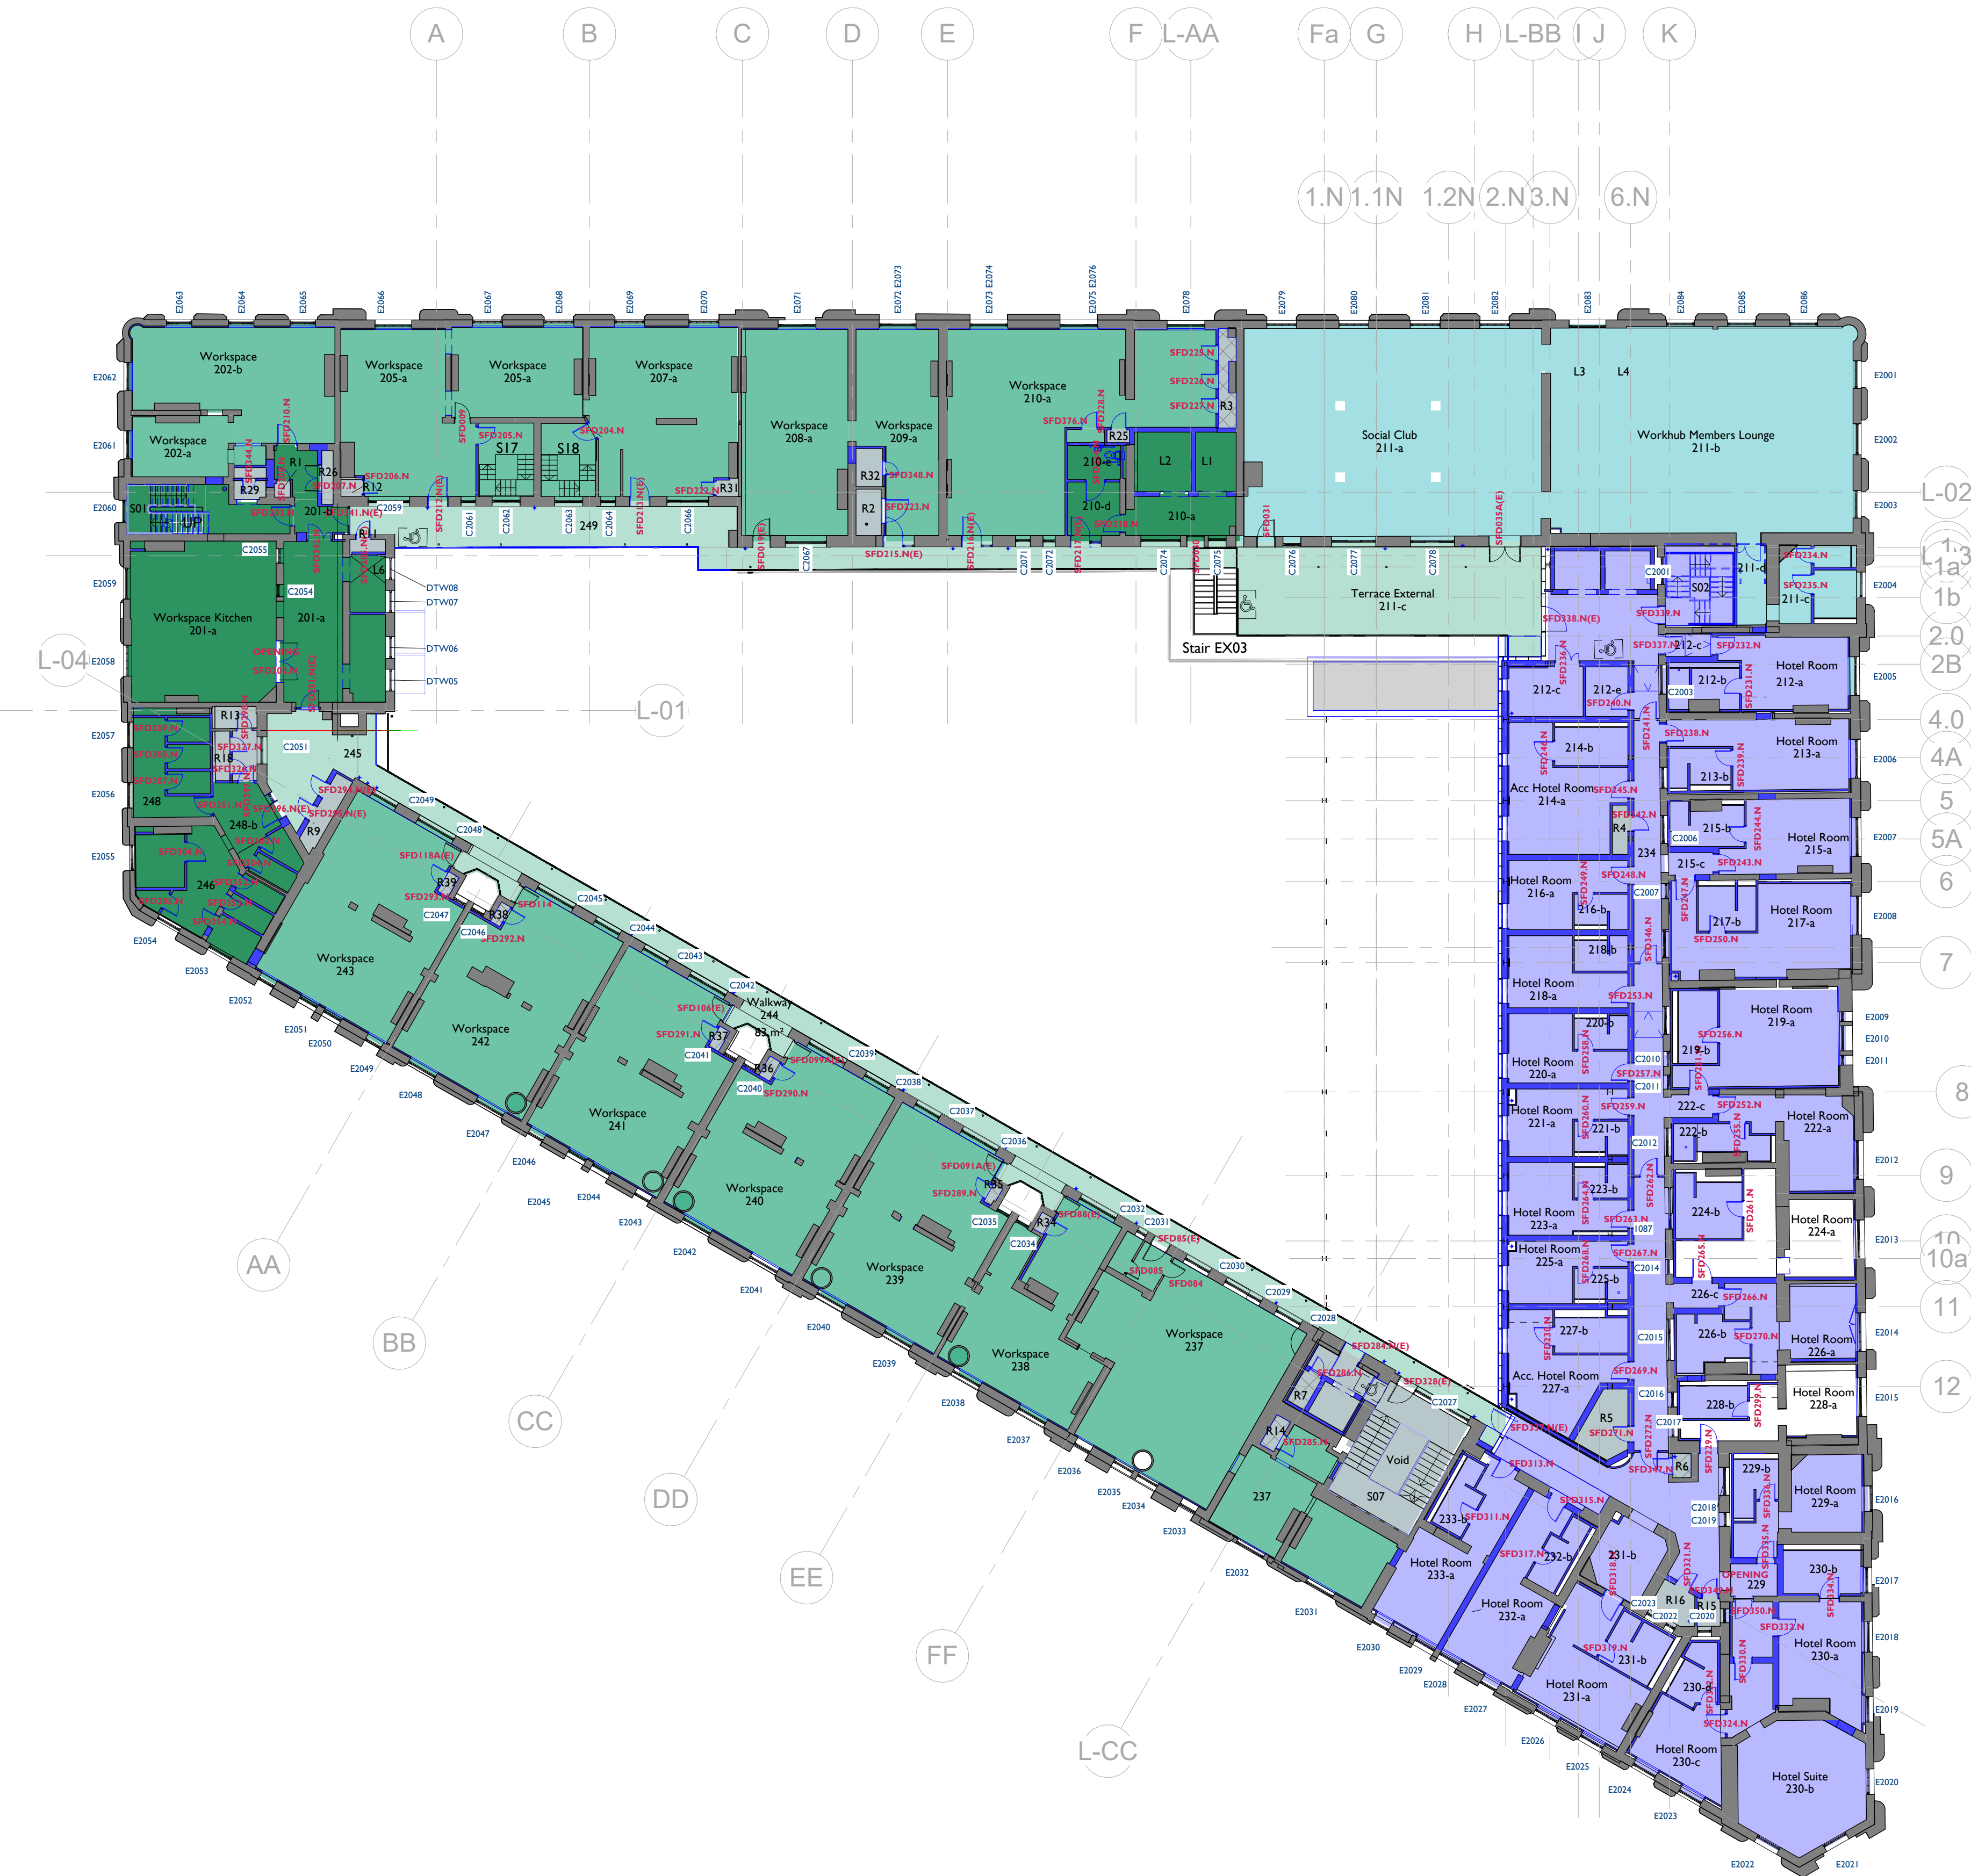

**02 Second Floor GA**  
I : 200

 

Plans include all phases of the project.  
Fit out proposals are subject to change.