


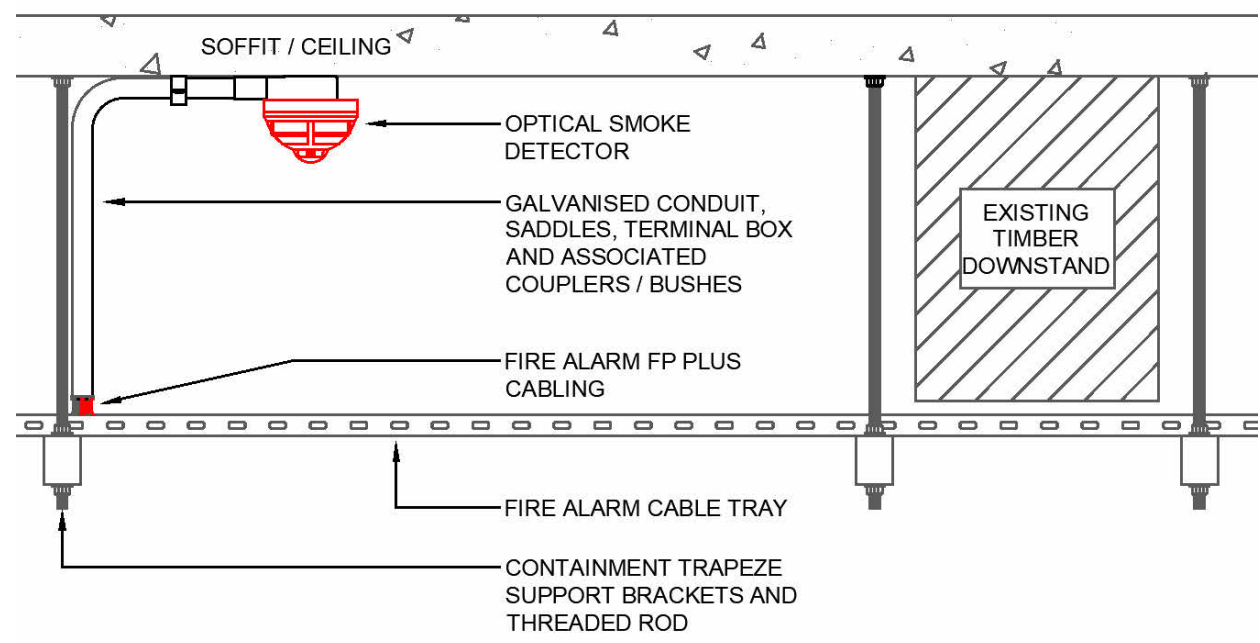

DETAIL A:
TYPICAL FIRE ALARM INSTALLATION DETAIL
NOT TO SCALE



LEGEND

- Manual Call Point
- FAI Fire Alarm Interface
- FAP Fire Alarm Panel
- S Smoke Detector
- S Smoke Detector With Sounder & Beacon
- Internal Visual Flashing Fire Alarm Indicator
- SA Smoke Alarm
- HA Heat Alarm
- IF Relay Module to interface with Gent Fire Alarm System
- WP Weatherproof Sounder With Beacon
- Evacuation Alert System Sounder
- EAS Evacuation Alert System Main Panel


NOTES

- FIRE ALARM INSTALLATION SHALL BE IN COMPLIANCE WITH BS 5839.
- DO NOT SCALE FROM THIS DRAWING, IF IN DOUBT REQUEST FURTHER INFORMATION.
- THIS DRAWING SHALL BE READ IN CONJUNCTION WITH THE MAIN CONTRACT CONDITIONS, THE BUILDING SERVICES SPECIFICATION AND SCHEDULES, THE ARCHITECT'S DRAWINGS.
- REFER TO ARCHITECTS DRAWINGS FOR DETAILS OF ALL SETTING OUT INFORMATION. NO DIMENSIONS SHALL BE MEASURED FROM THIS DRAWING.
- ANY OBSERVED DESCREPANCY WITH THIS DRAWING MUST BE REPORTED AND CLARIFICATION SOUGHT.
- THE COMPLETE ELECTRICAL INSTALLATION SHALL BE IN ACCORDANCE WITH BS 7671, BS 5266, BS EN 12464.
- THE CONTRACTOR SHALL ALLOW FOR THE SUPPLY, INSTALLATION AND COMMISSIONING OF ALL SYSTEMS AS GENERALLY SHOWN.
- EVACUATION ALERT SYSTEM INSTALLATION SHALL BE IN COMPLIANCE WITH BS 8629.

28/11/2024	Revised Based on Updated Arch Model	P04	MS/UR
12/07/2024	Amended Inline with Client Comments	P03	MS
28/06/2024	Amended Inline with Client Comments	P02	MS
14/06/2024	Issued for Tender	P01	MS

Date	Description	Rev.	By
------	-------------	------	----

Revision Description

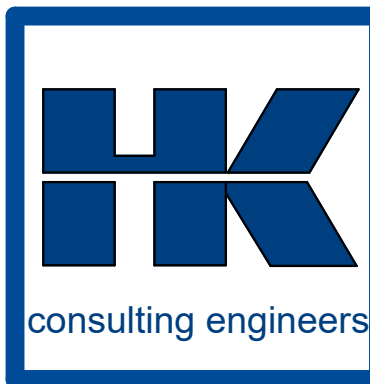

Manchester Office
2 Commercial Street
Castlefield
Manchester
M15 4RQ
T: 0161 832 2030
E: hk.manchester@hulley.co.uk

...Making Buildings Work

Project:
Piccadilly Warehouse, Bloom Street

Drawing Title:
FIRE ALARM LAYOUT LEVEL 0

ISO 19650 Drawing Number:
24006-HAK-BS-00-DR-E-68001

Project	Originator	Functional Breakdown	Spatial Breakdown	Form	Discipline	ServiceNumber
---------	------------	----------------------	-------------------	------	------------	---------------

Scale: As indicated **Creation Date:** 10/05/2024
Revision: P04 **Rev Date:** 28/11/2024

Drawn By: W.Slater **Checked By:** D.Farrimond
Approved By: P.Metcalf

Arch Rev: 24006-HFR-BS-ZZ-M3-A-9801_P3

Struct Rev: N/A

Issue Status:

TENDER