


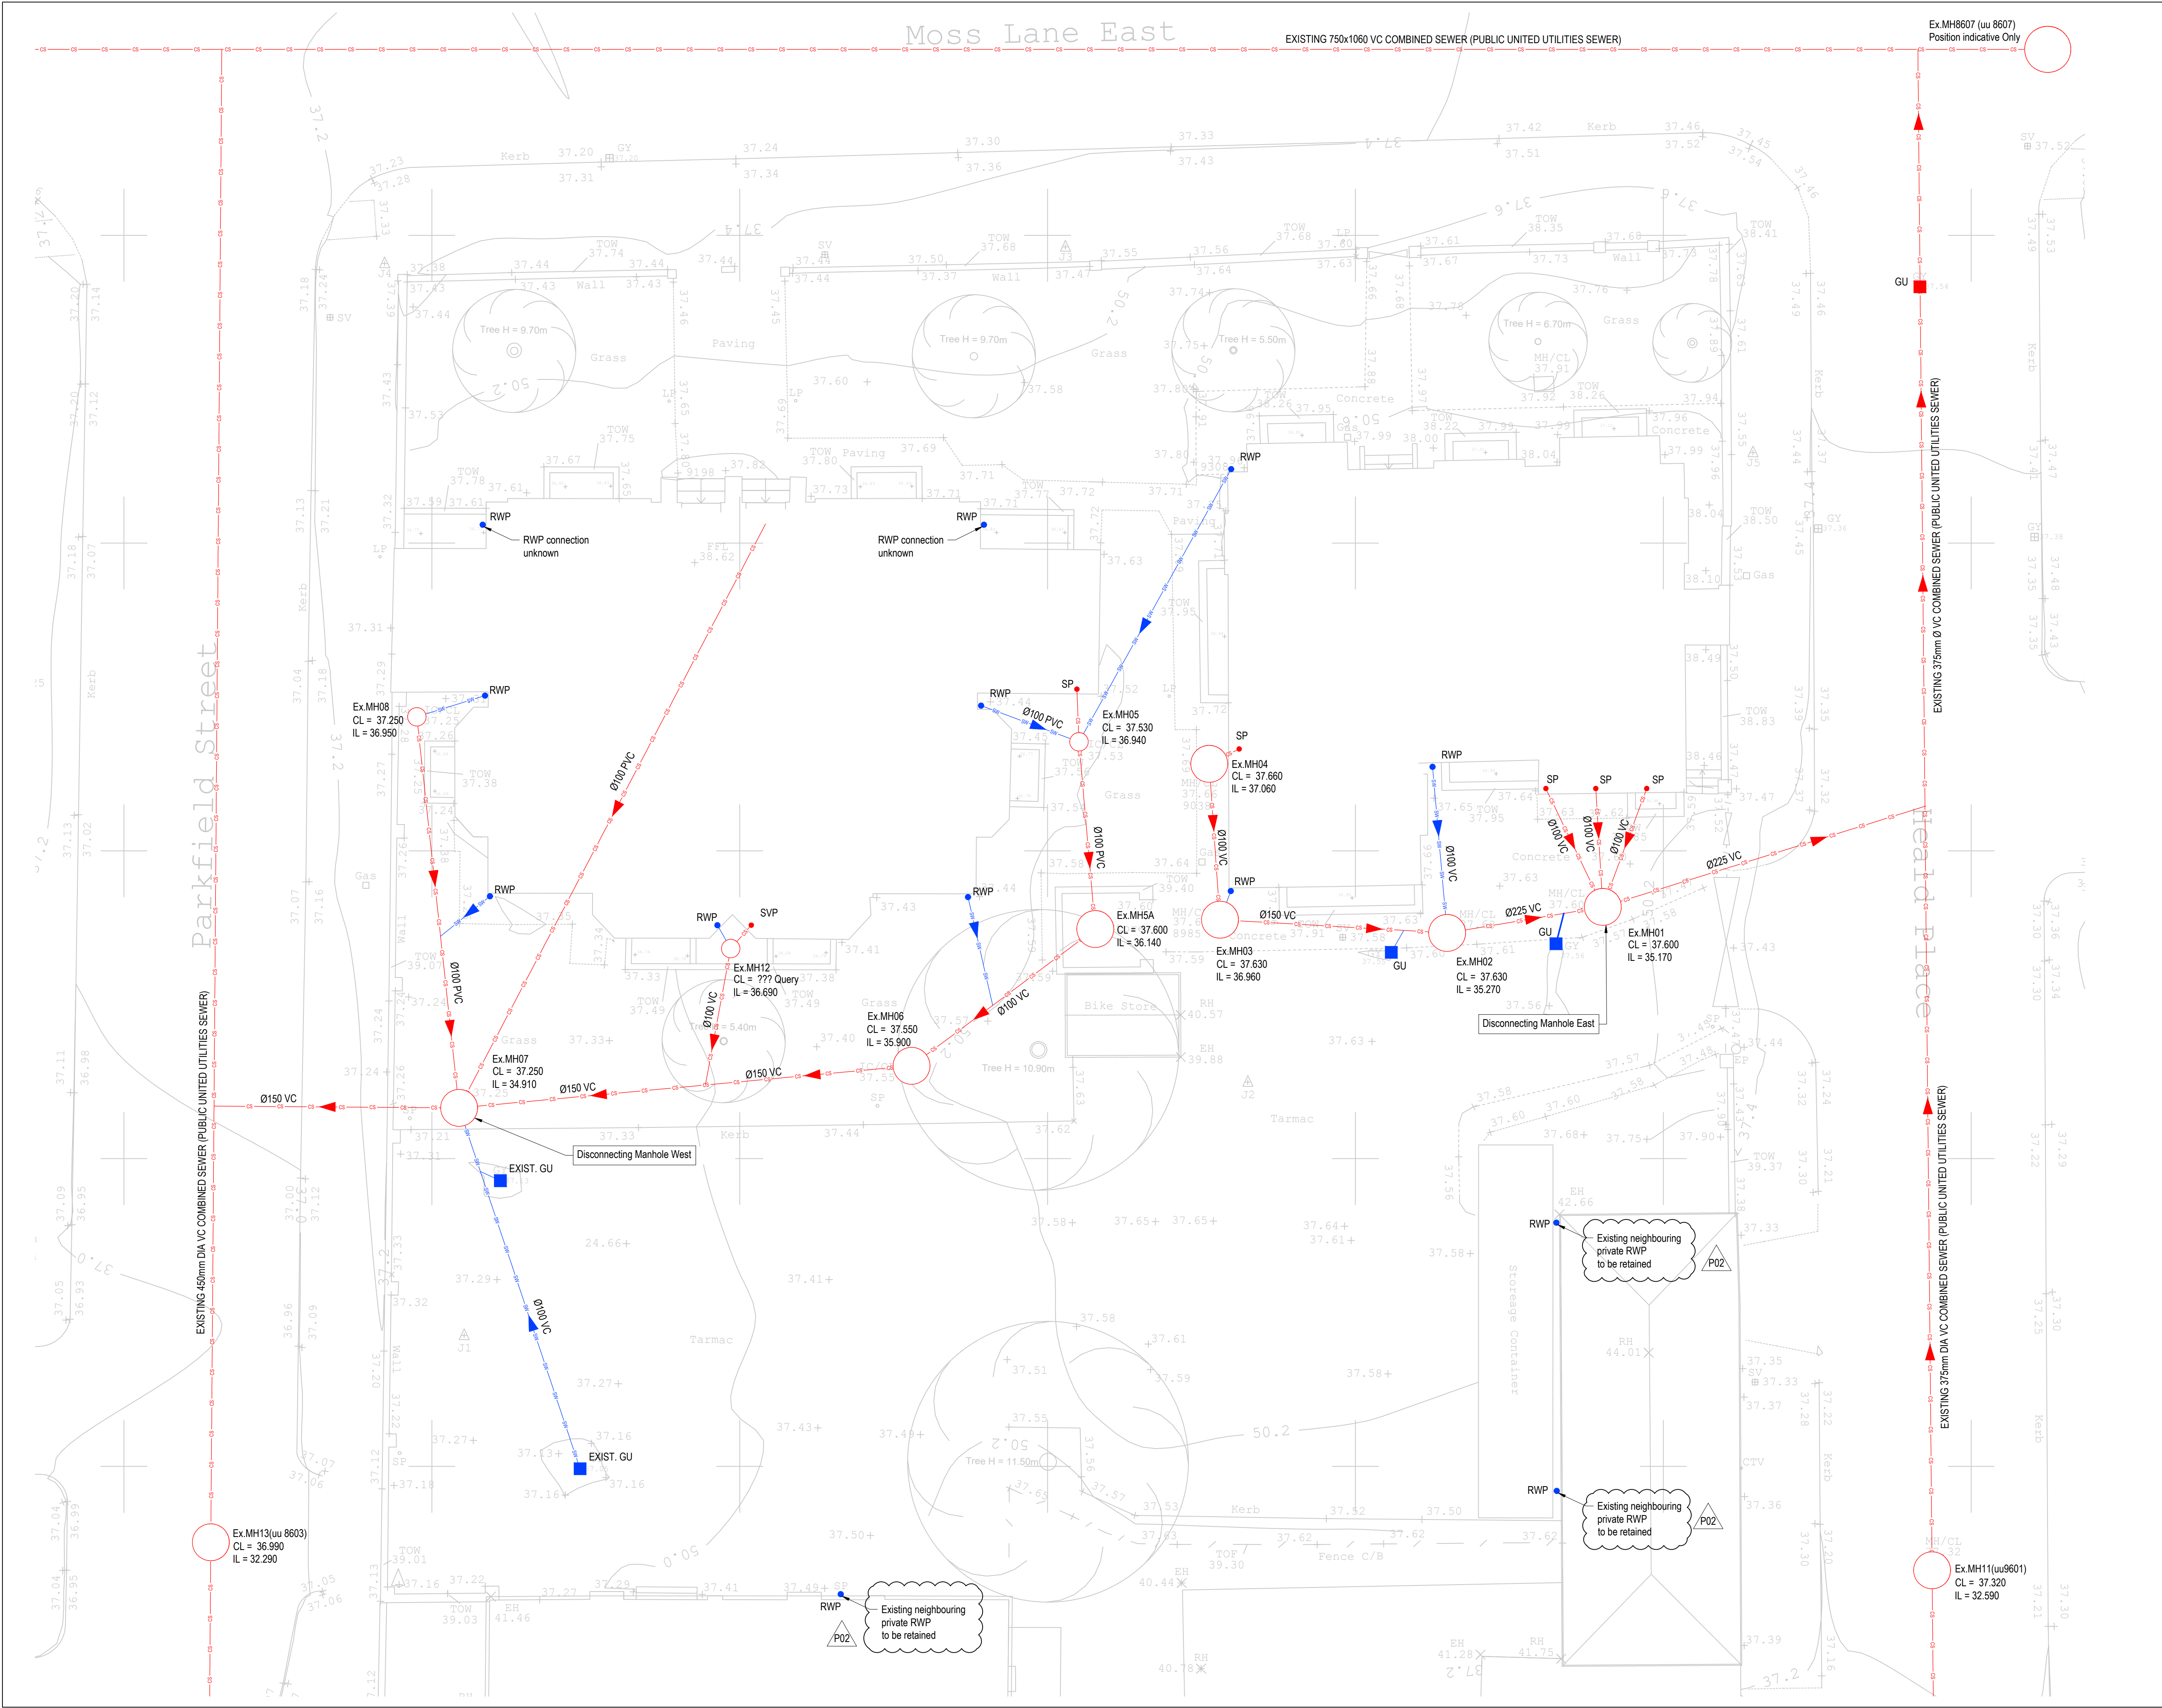

GENERAL NOTES

- DO NOT SCALE FROM THIS DRAWING - IF IN DOUBT CONTACT PROJECT ENGINEER.
- ALL DIMENSIONS ARE IN MILLIMETRES UNLESS STATED OTHERWISE.
- ALL LEVELS ARE IN METRES.
- THIS DRAWING IS TO BE READ IN CONJUNCTION WITH ALL RELEVANT ARCHITECTURAL, STRUCTURAL AND SERVICES DRAWINGS.
- THE CONTRACTOR IS TO VERIFY ALL DIMENSIONS ON SITE AND IS RESPONSIBLE FOR ACCURATE SETTING OUT.
- THE CONTRACTOR IS TO CONFIRM THE EXISTING BOUNDARY AND SITE STRUCTURES ETC. PRIOR TO COMMENCING THE WORKS AND IMMEDIATELY INFORM THE SUPERVISING OFFICER SHOULD THESE BE AT VARIANCE WITH THE ASSUMPTIONS SHOWN ON THE DRAWING.
- REFER TO DRG No. L047-WRD-22-ZZ-ZZ-D-S-220050 FOR SPECIFICATION NOTES.

ALL DIMENSIONS SHOWN ON THIS DRAWING ARE TO BE VERIFIED BY THE ARCHITECT PRIOR TO FABRICATION / MANUFACTURE / CONSTRUCTION
CONSTRUCTION (DESIGN AND MANAGEMENT) REGULATIONS 2015

THE DESIGNS ON THIS DRAWING ARE PREPARED WITH CONSIDERATION OF THE NEED TO IDENTIFY HAZARDS AND GIVE REGARD TO THEIR ELIMINATION OR MINIMISATION. REFERENCE MUST BE MADE TO HEALTH AND SAFETY INFORMATION PREPARED BY THE PRINCIPAL DESIGNER.

LEGEND

- Denotes existing combined sewer pipew.
- Denotes existing foul sewer pipew.
- Denotes existing surface water pipew.
- Ex.XX01 Denotes existing combined sewer manhole chamber. Location indicative.
- Ex.FW01 Denotes existing foul sewer manhole.
- Ex.XX02 / Ex.SW01 Denotes existing surface water manhole.
- Exist. GU Denotes existing gully
- RWP Denotes rain water pipe
- SP Denotes Soil Vent Pipe

NOTE

3rd Party Topographical Information provided by ACAD DESIGN & SURVEYS, dated 21 June 2022.

Existing drainage pipew and structure locations based on United Utilities Water Limited record drawings and CCTV Survey carried out by Drain Alert, on August 2022.

All Cover Levels and Invert Levels are indicative, and based upon 3rd Party information above.

P02	UPDATED RWP NOTE IN RESPONSE TO PLANNING	08/10/2024	WD	CA
C01	CONSTRUCTION ISSUE	12/08/2024	SC	CA
P01	ISSUE FOR STAGE 3	28/03/2024	WD	CA
ISSUE	DETAILS	DATE	BY	CHK

STATUS:

PLANNING

Will Rudd Davidson (Glasgow) Ltd
Consulting Civil & Structural Engineers
100 Brunswick St
Glasgow G1 1TF
T: 0141 248 4866
E: glasgow@ruddconsult.com
www.ruddconsult.com

CLIENT:
ALUMNO GROUP

PROJECT TITLE:
MOSS LANE EAST MANCHESTER

DRG TITLE:
EXISTING DRAINAGE LAYOUT

DRAWN BY:	WD	DATE DRAWN:	04/03/2024
CHECKED BY:	CA	DATE CHECKED:	24/03/2024
SCALES:	1:100m	SHEET SIZE:	A1

PROJECT	ORIG.	FUNCT.	SPACE.	FORM	DISC.	No.	REV
L047 - WRD -	52 - EX.ZZ -	D -	- C -	5000001			P02