


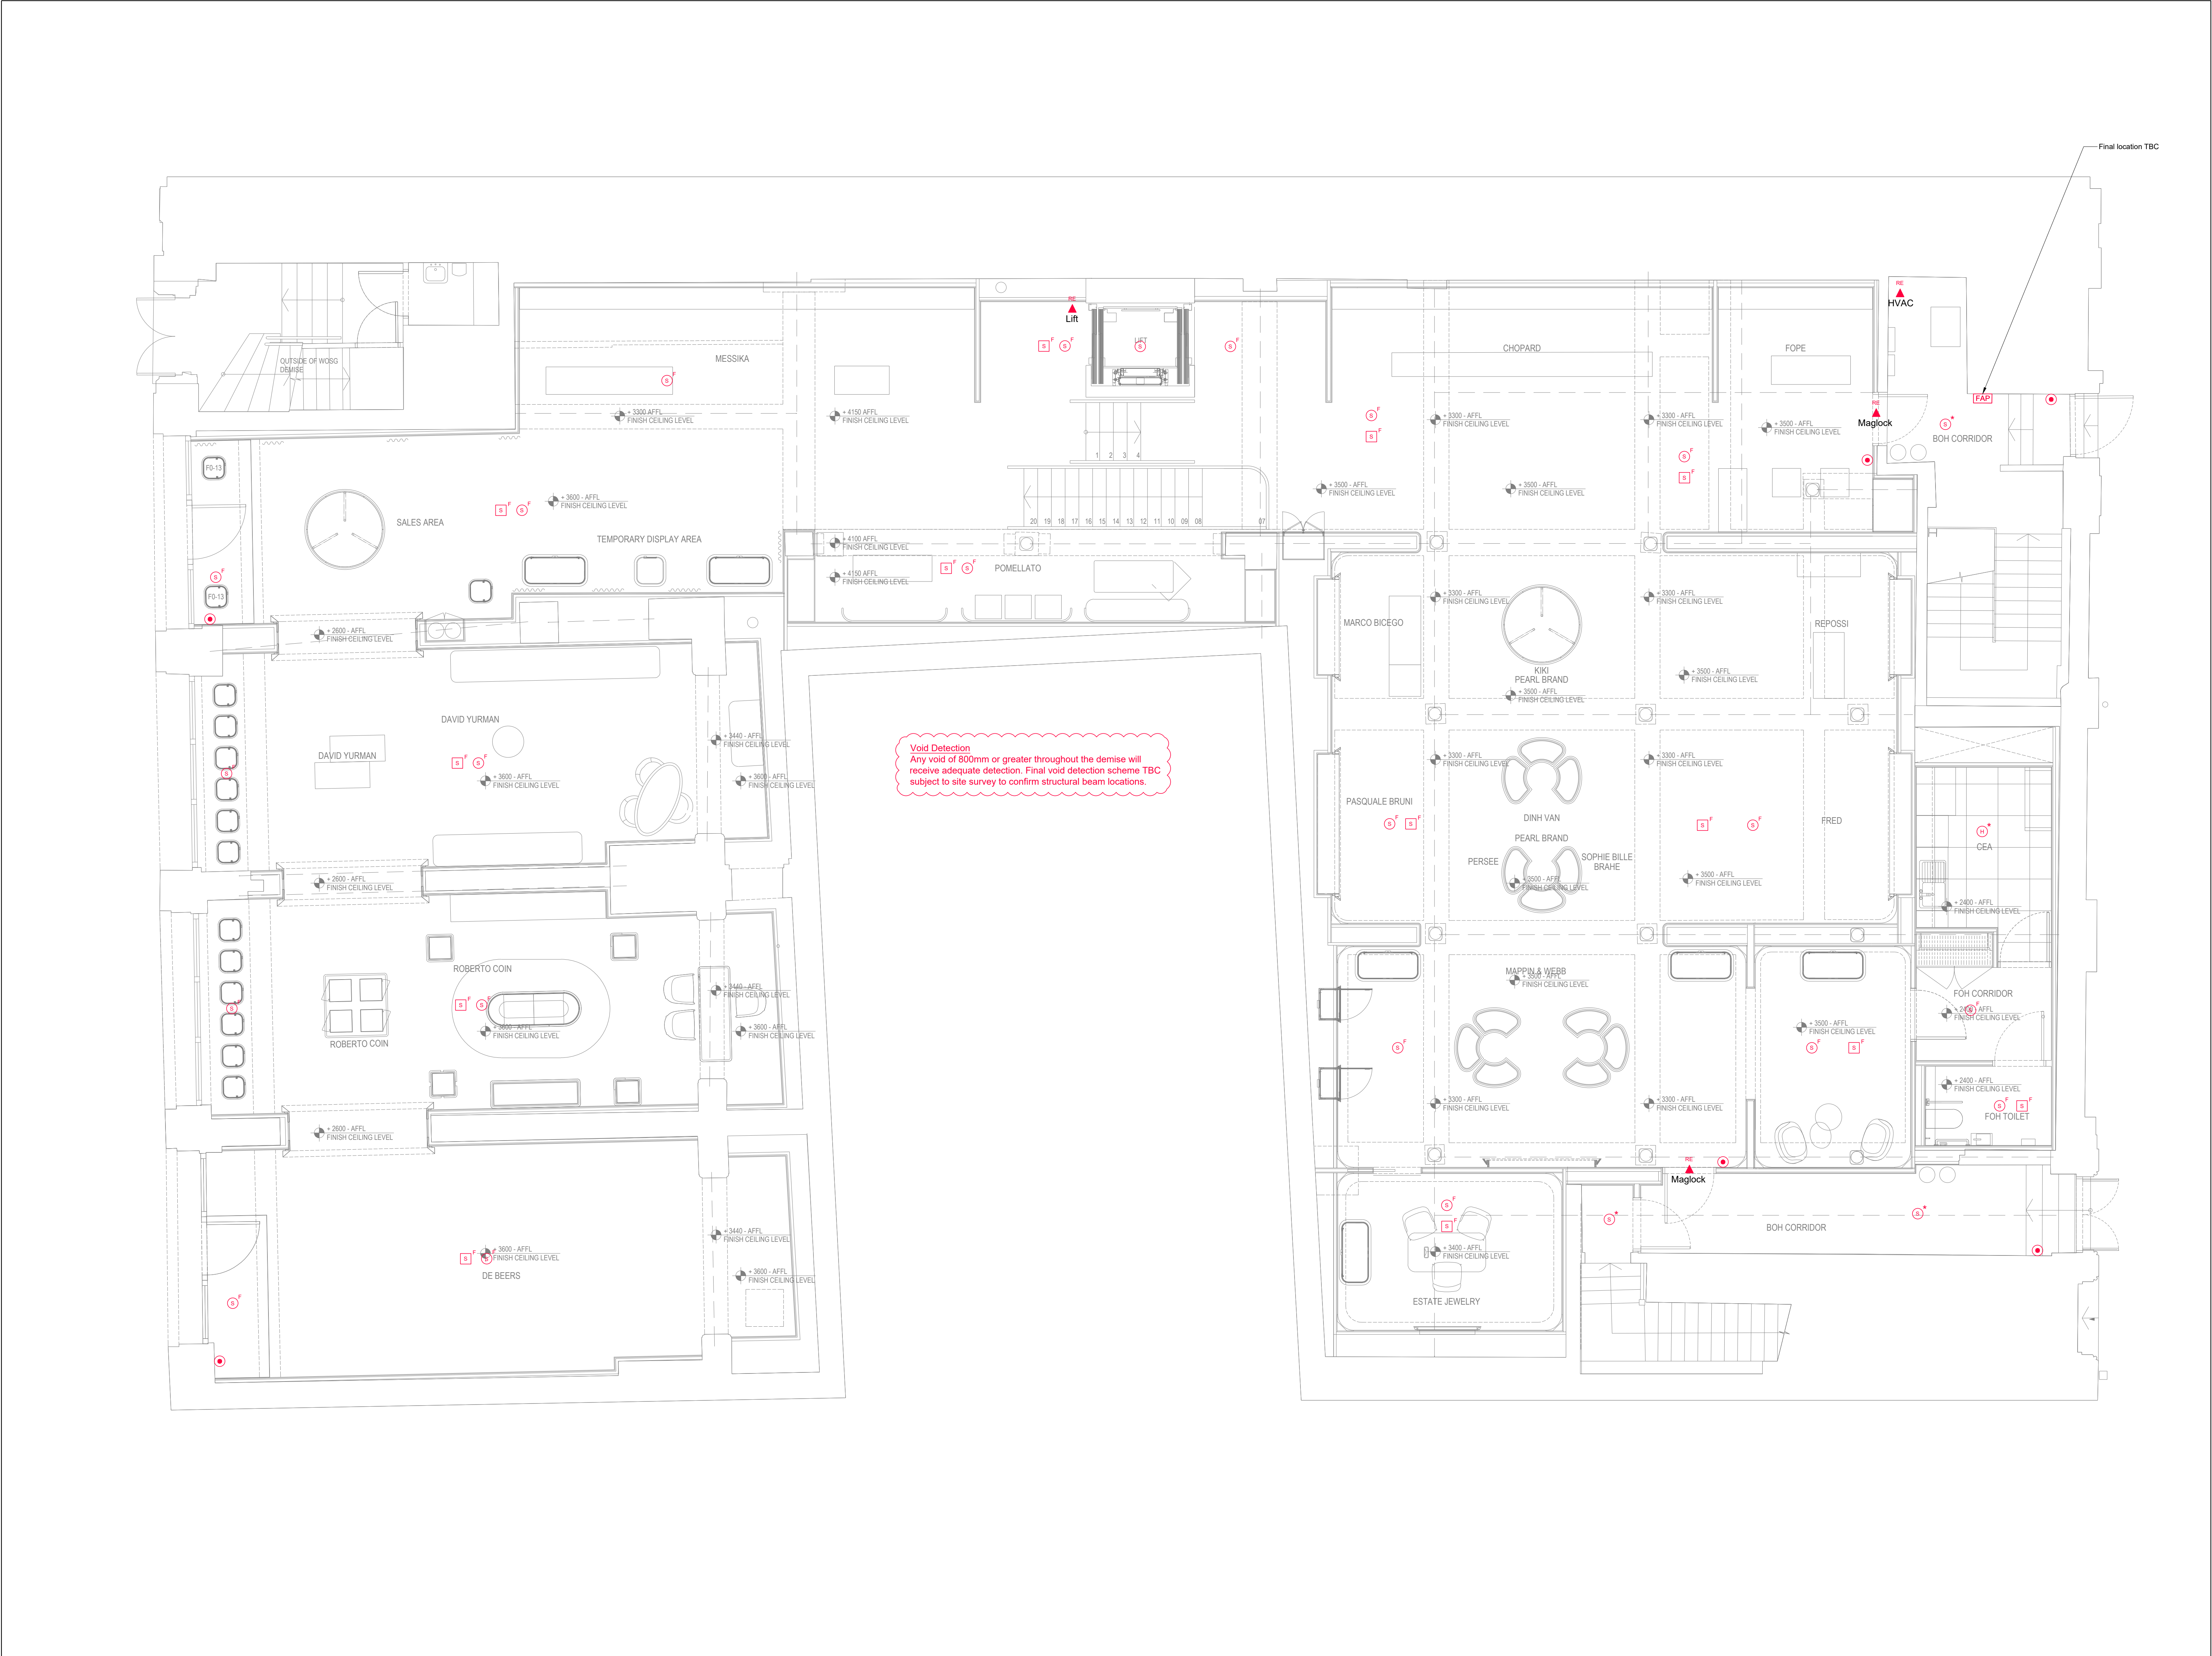

Fire Alarm

Fire Alarm Legend	
Symbol	Description
	Smoke Detector & Sounder Beacon Base
	Smoke Detector
	Smoke Detector In Ceiling Void
	Smoke Detector Recessed/Flush Mounted Apollo Soteria FL5100-600APO
	Sounder Recessed/Flush Mounted Fullen Askari Compact
	Heat Detector & Sounder Beacon Base
	Fire Condition Activated Relay
	Manual Call Point 1200mm AFFL to Underside
	Fire Alarm Panel Installed at 1200mm to Center of Panel

Fire Alarm - Interface Schedule

- HVAC
- Audio
- Maglock
- Lift
- Landlords Fire Alarm

Typical Fire Alarm Zone Layout

- Zone 1 - Front Of House (Ground)
- Zone 2 - Back Of House (Ground)
- Zone 3 - Front Of House (Basement)
- Zone 4 - Back Of House (Basement)
- Zone 5 - Lift

Fire Alarm interface to shutdown HVAC, audio system & deactivate door access controls in fire conditions. Please refer to the landlords hand book/fire alarm service provider for interface connections & all commissioning requirements.

AVALON TECHNOLOGY LTD
Proposed Fire Alarm System
08.07.24

THIS SYSTEM HAS BEEN DESIGNED TO
CATEGORISATION - L1

OAK COPYRIGHT STATEMENT

This drawing is the property of Oak Electrical Ltd. Copyright is reserved by them and is issued on the condition that it is not copied either wholly or in part without consent in writing from Oak Electrical Ltd.

General Notes:

- This drawing should be read in conjunction with all other relevant project drawings and specifications.
- The system is designed and installed in accordance with all relevant British Standards, Regulations, and Codes of practice and methods of working.
- Any conflict in design is to be highlighted and appropriate action / approval given prior to alterations being carried out.

A	05/11/24	FCH flush mounted devices noted	AC	BP
-	31/08/24	First Issue	AC	BP
Rev	Date	Description	By	CHK

Status
FOR APPROVAL

Oak Electrical
BUILDING SERVICES ENGINEERS

Warner Court, Blue Ridge Park, Glasshoughton
(M62 - J22) Castleford, West Yorkshire
Telephone (01977) 55 55 92 Fax (01977) 55 52 46
●CASTLEFORD ●BIRMINGHAM
www.oak-electrical.com info@oak-electrical.com

Client
Watches of Switzerland Group
2 Elland Road
Braunstone
Leicester, LE3 1TT

Project
Mappin & Webb
17-21 St Anns Square
Manchester
M2 7PW

Drawing Title
ELECTRICAL SERVICES
EQ4.2 - Fire Alarm Layout - Ground

Drawing No	Revision
C3016 - 24 - E - 04.2	A
Scale 1:50 @ A0	Date NOV 24
Engineer AC	Checked BP