


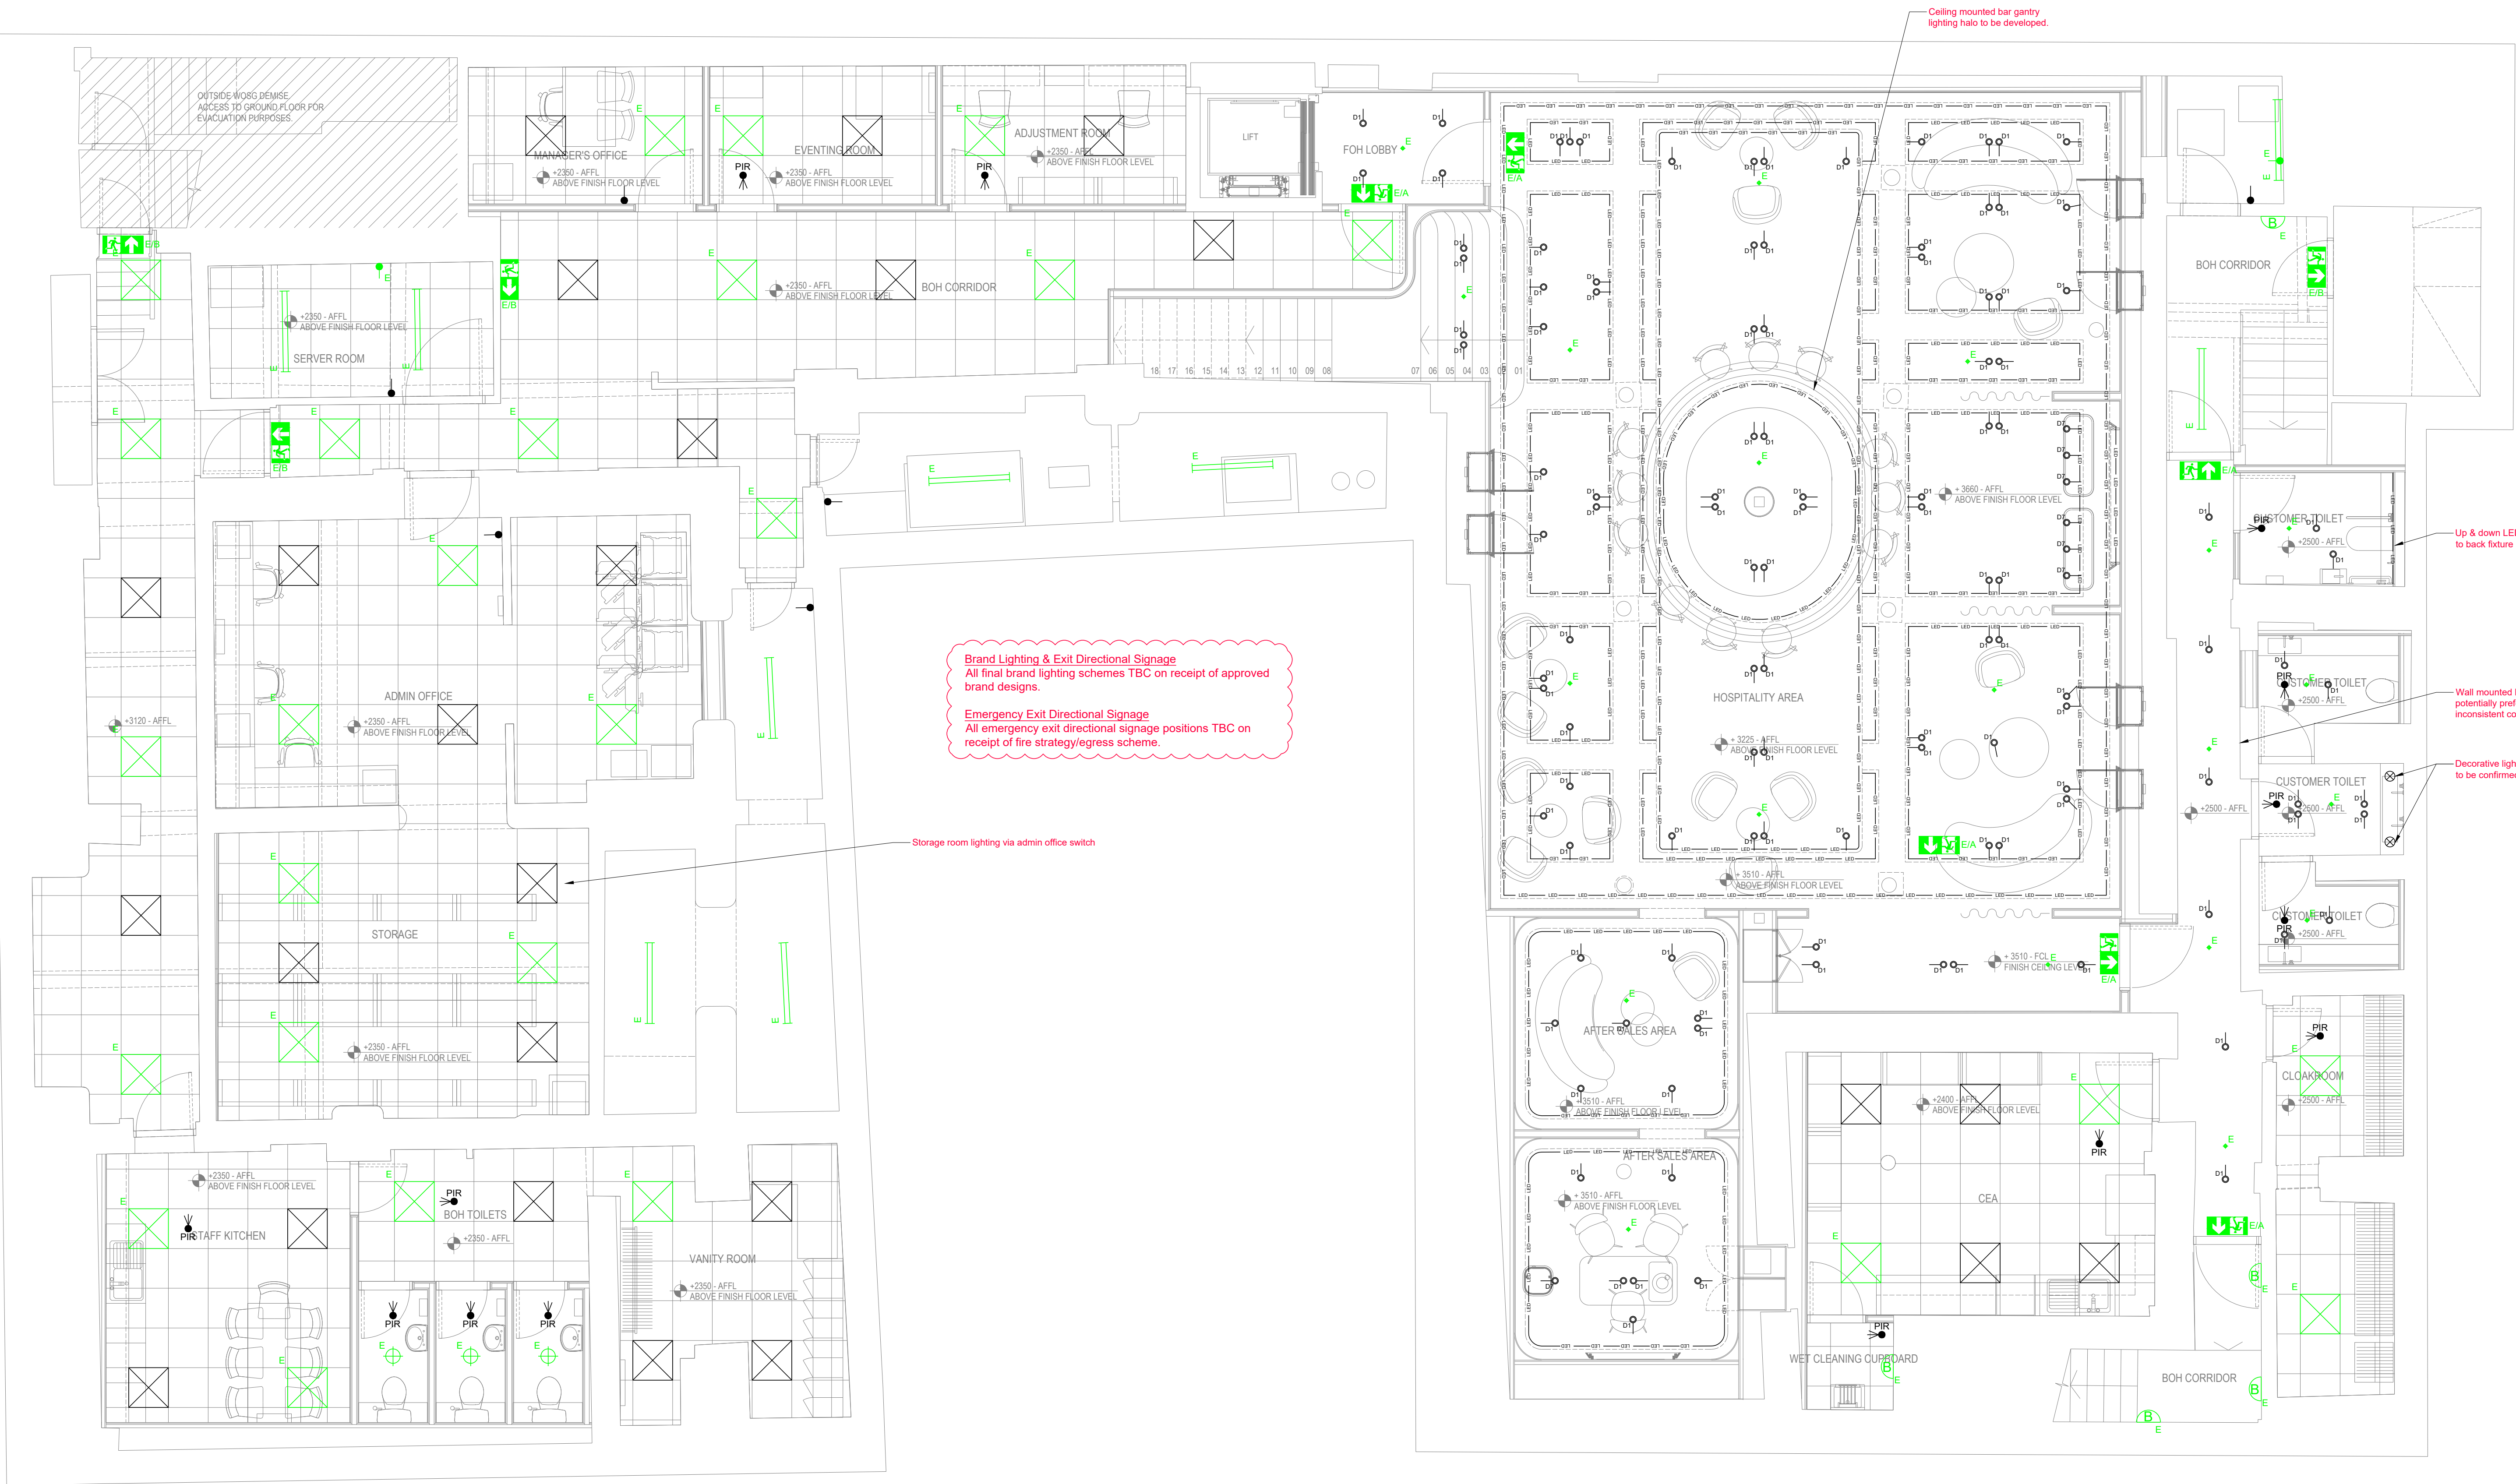

Retail Area Lighting

Retail Area Lighting Legend	
Symbol	Description
	EY-TA-WT/B1-STD14-30-90-30-1050 Adjustable Round Downlight 732m, 3000K LED Module 64mm Cut Out / 88mm Recess Depth Ø80mm Overall / 230V - 14W
	EY-TA-WT/B1-STD14-30-90-20-1050 Adjustable Round Downlight 732m, 3000K LED Module 64mm Cut Out / 88mm Recess Depth Ø80mm Overall / 230V - 14W
	EY-TA-WT/B1-STD14-40-90-20-1050 Adjustable Round Downlight 732m, 4000K LED Module 64mm Cut Out / 88mm Recess Depth Ø80mm Overall / 230V - 14W
	LED Strip Lighting
	ESP Ducori Non-maintained Recessed Downlight 138lm / IP20 EMD3WMDLK 230V - 3W
	Signbox FE LED Signblock Exit Blade

General & Emergency Lighting

General & Emergency Lighting Legend	
Symbol	Description
	JCC Lighting 600mm x 600mm LED Skylite Standard Driver / 3000lm / IP44 JC080104 230V - 30W
	JCC Lighting 600mm x 600mm LED Skylite Standard Driver / 3000lm / IP44 JC080104 + JCEM002 230V - 30W
	JCC Lighting ToughLED 4ft Single 4000K Frosted Diffuser 22W JC180002
	JCC Lighting Radial LED Slim Mains Bulkhead Standard Driver / 1500lm / IP44 JC24241 EM 230V - 18W
	JCC Lighting Recessed LED Satdisc Standard Driver / 1700lm / IP65 JC72503 + JCEM002 230V - 17W
	JCC Lighting Maintained Aluminium Exit Box IP20 / 3m JC50303
	PIR Detector
	1 Gang 1 Way Switch
	Emergency Key Switch



Example LED Backlit WC Mirrors

OAK COPYRIGHT STATEMENT

This drawing is the property of Oak Electrical Ltd. Copyright is reserved by them and is issued on the condition that it is not copied either wholly or in part without consent in writing from Oak Electrical Ltd.

General Notes:

- This drawing should be read in conjunction with all other relevant project drawings and specifications.
- The system is designed and installed in accordance with all relevant British Standards, Regulations, and Codes of practice and methods of working.
- Any conflict in design is to be highlighted and appropriate action / approval given prior to alterations being carried out.

-	31/08/24	First Issue	AC	BP
Rev	Date	Description	By	Chk

FOR APPROVAL

Oak Electrical
BUILDING SERVICES ENGINEERS
Werner Court, Blue Ridge Park, Glasshoughton
(M62 - J22) Castleford, West Yorkshire
Telephone (01977) 55 55 55 Fax (01977) 55 52 46
●CASTLEFORD ●BIRMINGHAM
www.oak-electrical.com info@oak-electrical.com

Client
Watches of Switzerland Group
2 Elland Road
Braunstone
Leicester, LE3 1TT
Project
Mappin & Webb
17-21 St Anns Square
Manchester
M2 7PW

Drawing Title
ELECTRICAL SERVICES
EP1.1 - General & Emergency Lighting Layout - Basement

Drawing No	Revision
C3016 - 24 - E - 01.1	-

Scale	Date	Engineer	Checked
1:50 @ A0	AUG 24	AC	BP