
 
 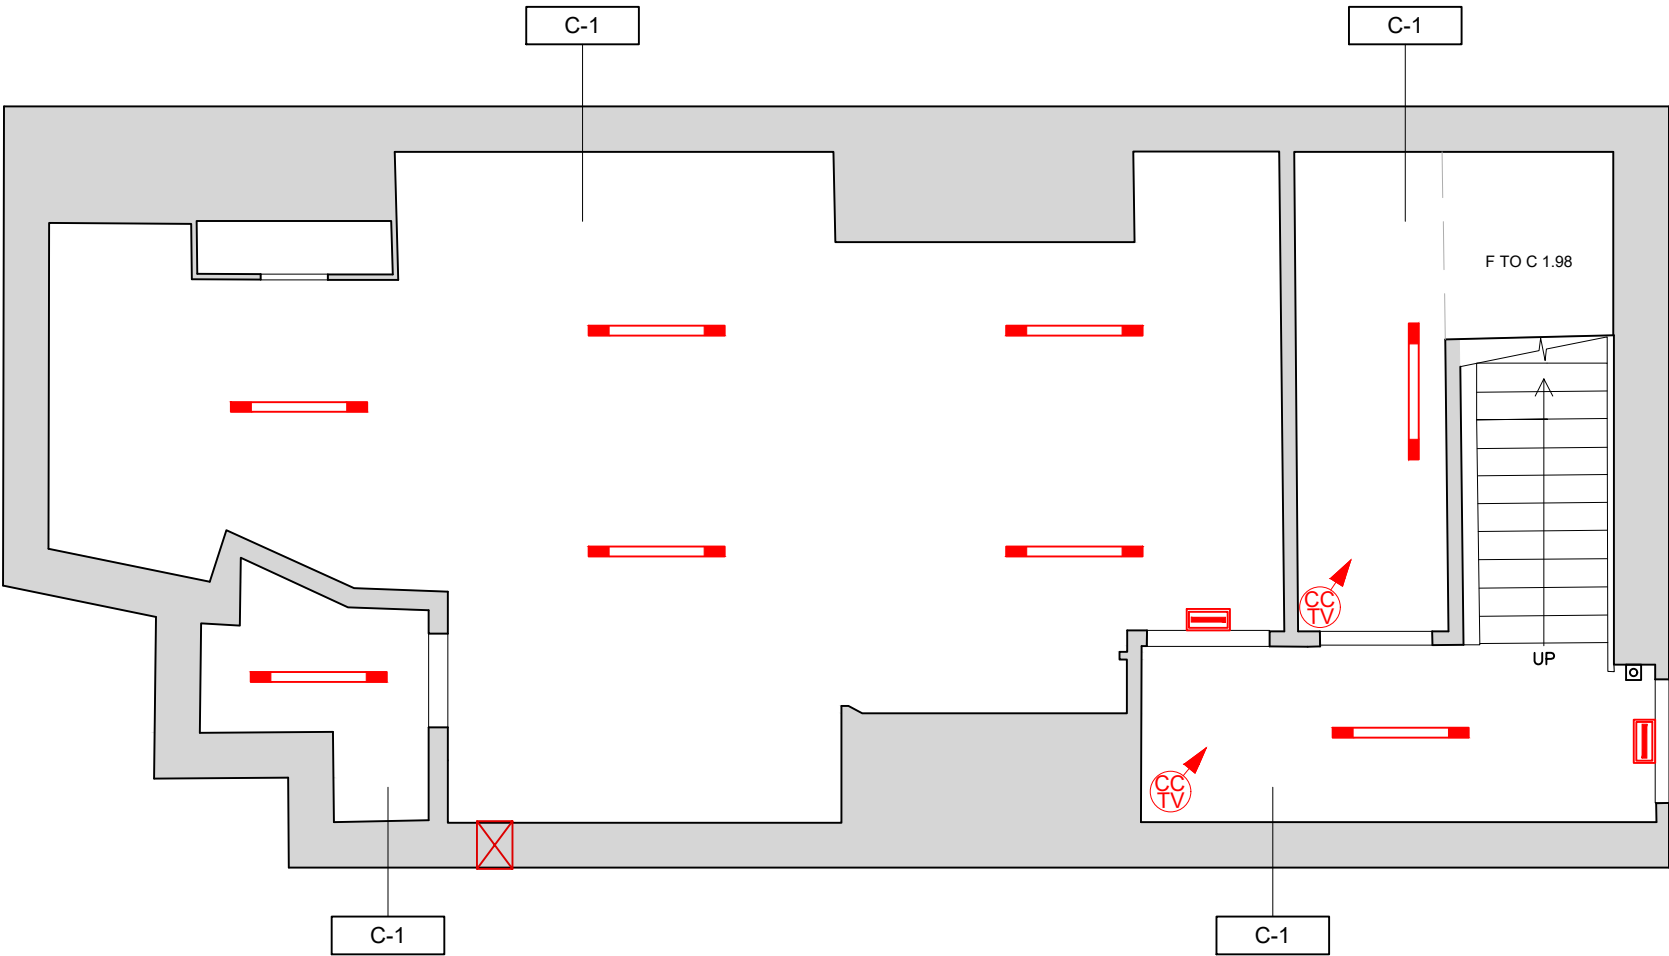


LIGHTING & SYMBOL LEGEND				NOTE: COORDINATE ALL MEP ITEMS WITH MEP ENGINEERS DRAWINGS AND DETAILS. REFER MEP DRAWINGS FOR PROPOSED MODIFICATION TO FIRE, EXIT AND EMERGENCY LIGHTING SYSTEMS. NOTE: LIGHTING FIXTURE SUPPORTS SHALL BE SUSPENDED FROM BUILDING STRUCTURE. CEILINGS SHALL NOT BE UTILISED AS MEANS OF SUPPORT FOR ANY LIGHT FIXTURES. NOTE: TENANT SHALL NOT DRILL, SCREW, WELD, OR SHOOT INTO LANDLORD'S STRUCTURE OR STRUCTURAL MEMBERS. ALL ATTACHMENTS WILL BE WITH BEAM CLAMPS, CLIPS, WIRE, OR BOLTS WITH WASHERS. DO NOT ATTACH ANY CONSTRUCTION DIRECTLY TO LANDLORD'S ROOF DECK. JOISTS, BEAMS, TRUSSES & GIRDERS MAY BE USED FOR LATERAL BRACING & SPANNING SUPPORT. DO NOT SUPPORT ANY CONSTRUCTION FROM LL'S CROSS-BRACING OR BRIDGING. NOTE: G.C. TO BE RESPONSIBLE FOR SAFE ACCESS AND SERVICE ACCESS TO ALL SUSPENDED MECHANICAL HVAC UNITS AND OTHER SUSPENDED EQUIPMENT IN COMPLIANCE WITH MANUFACTURER REQUIREMENTS AND LOCAL BUILDING CODE REGULATIONS.
	RECESSED SPOTLIGHT. EXACT SPEC TO BE CONFIRMED BY CLIENT		STORE WI-FI ACCESS POINT - CLIENT REQUIREMENTS TBC	
	EXISTING LIGHT TRACK TO BE RETAINED IN ITS CURRENT POSITION. G.C. TO INSPECT, CLEAN, AND ENSURE IT IS IN GOOD WORKING ORDER. ANY NECESSARY ADJUSTMENTS, CLEANING, OR MINOR REPAIRS REQUIRED FOR PROPER OPERATION ARE TO BE ADDRESSED BY THE G.C.		CCTV CAMERA - CLIENT REQUIREMENTS TBC	
	NEW HANGING PENDANT LIGHTS MOUNTED FROM RAFT CEILING SUPPLIED BY THE CLIENT AND INSTALLED BY G.C. BASE OF LIGHT FIXTURE @2100MM AFFL. SPEC - SKLUM OKAI Ø600MM OFF WHITE. CEILING TO BE REINFORCED BY G.C. ENSURING THE INSTALLATION COMPLIES WITH ALL SAFETY & BUILDING REGULATIONS. SPEC.: TBC BY CLIENT		NEW SMOKE DETECTOR, SOUNDER & STROBE. REFER TO MEP DRAWINGS FOR EXACT NUMBER AND LOCATION	
			150 DIA AIR SUPPLY GRILL (TO BE SPRAYED SAME COLOUR AS CEILING).	
			EXIT SIGNAGE. ARROW TO SUIT. WHITE.	
	RECESSED DOWNLIGHT LED. EXACT SPEC TBC BY CLIENT			
	EXISTING SURFACE MOUNTED STRIP LIGHTS TO BE RETAINED AND CLEANED	NOTE 1: ALL THE ABOVE ITEMS ARE TO BE SUPPLIED AND INSTALLED BY G.C. NOTE 2: REFER TO MANUFACTURER LIGHTING PROPOSAL FOR FURTHER INFORMATION		



LEGEND	
	OPEN CEILING TO EXPOSED STRUCTURE. ANY SPRAYED OUT ITEMS BY G.C. PER CLIENT REQUIREMENTS - TBC COLOUR TO BE CONFIRMED BY CLIENT
	NEW PLASTERBOARD CEILING TO UNDERSIDE OF MEZZANINE TO COMPRISE 15MM FIRELINE BOARD WITH A 3MM SKIMMED PLASTER FINISH TO GIVE A ONE HOUR FIRE RATING. COLOUR TO BE WHITE RAL 9003.
	18MM PLYWOOD LINED CEILING AS INDICATED, TO SUPPORT FEATURE PENDANTS AND LIGHT BOXES.
A.F.F.L. - ABOVE FINISHED FLOOR LEVEL	

ASTRID & MIYU



Design Coordinator
DYNAMIC DESIGN STUDIO
THE NEST, 19-20 YORK ROAD
DÚN LAOGHAIRE, CO. DUBLIN, IRELAND

Mechanical, Electrical, Plumbing

Revisions	
REV 0 - CONSTRUCTION PROGRESS ISSUE	09 DECEMBER 2024
REV 1 - CONSTRUCTION PROGRESS ISSUE	13 DECEMBER 2024

KEY PLAN

Client Specific Drawing Designation

A107

Project

18 Market Street,
Manchester

Drawing Title

REFLECTED CEILING PLAN
BASEMENT

Scale 1=50

Seal & Signature

Drawing Date DEC / 24

Project No. 24061

Drawn By

Checked By

Drawing No.

NAME
REG NO

A-107.1