


UNIT 261

UNIT 263

UNIT 265

UNIT 267

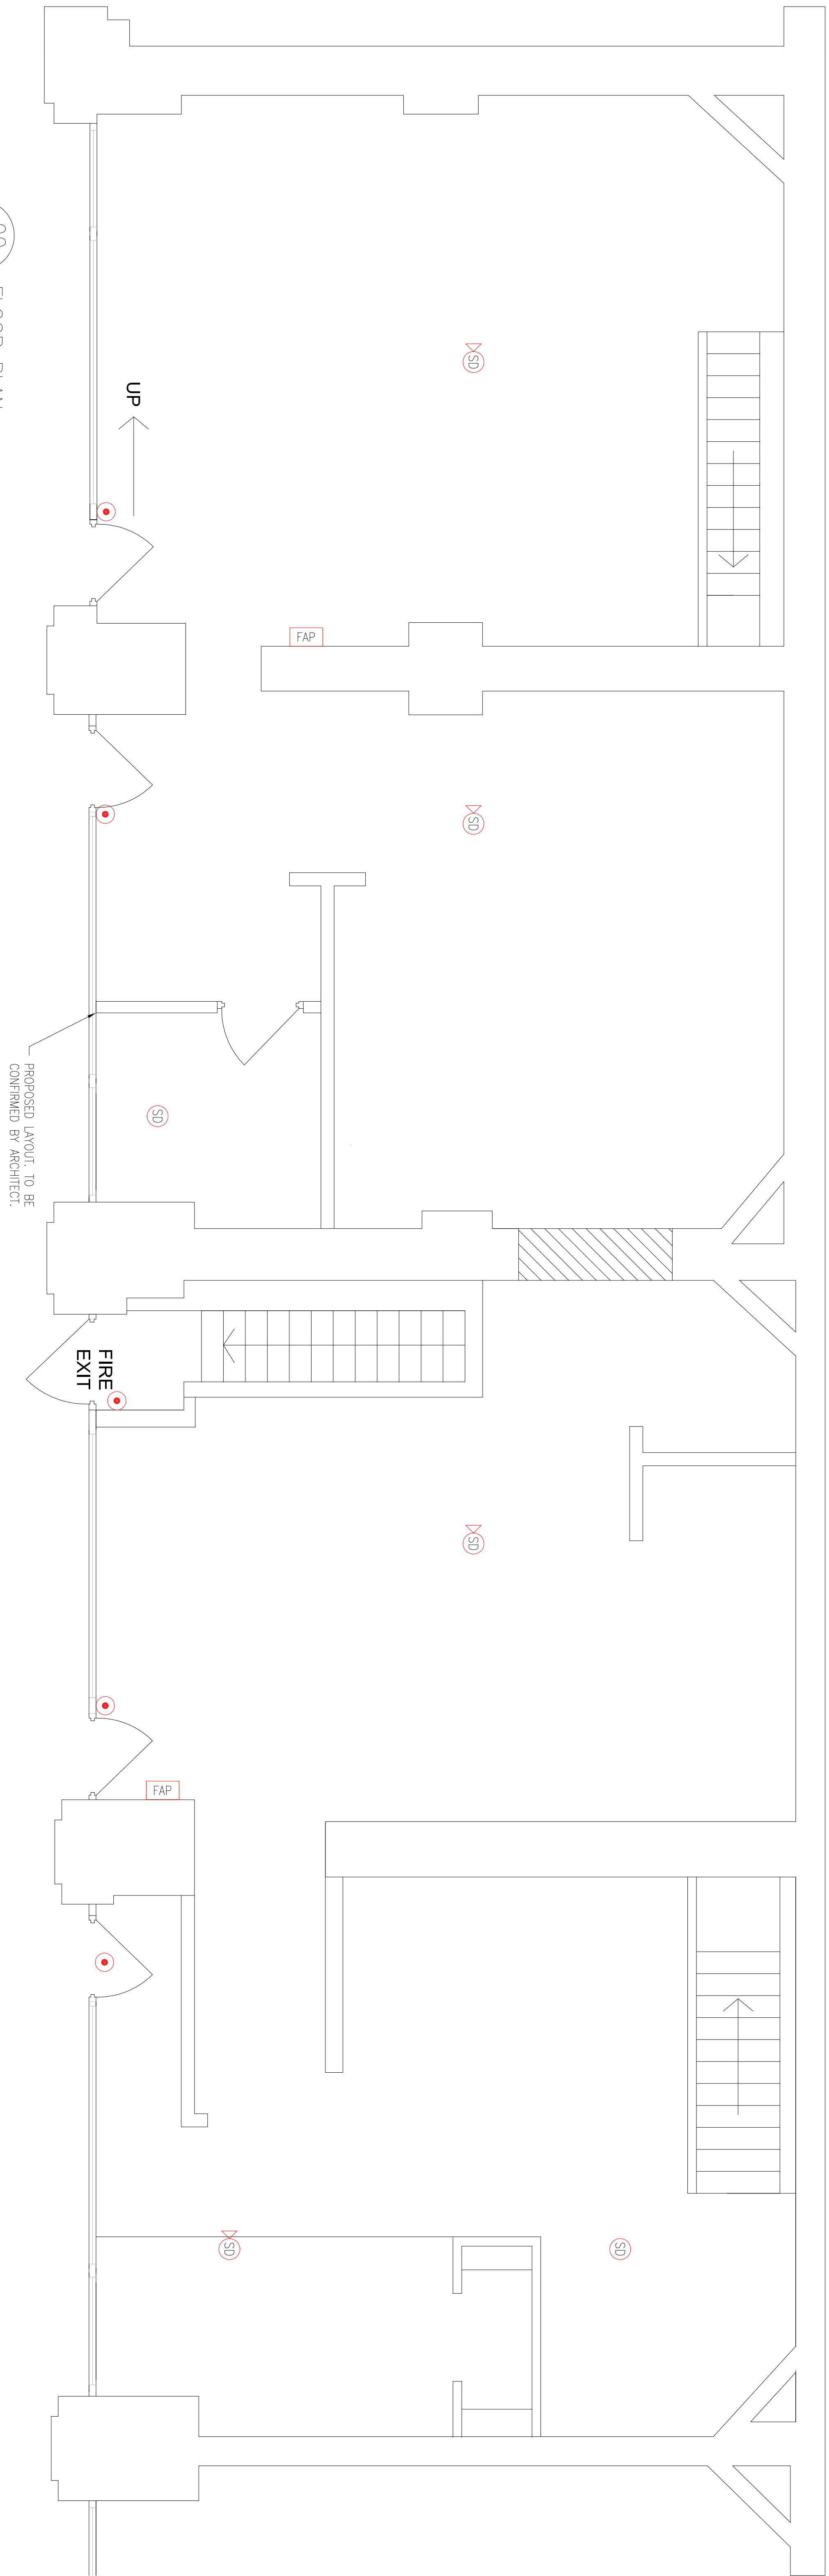


00 FLOOR PLAN
67-00-07 GROUND FLOOR – FIRE ALARM & SECURITY
1:50

UNIT 261

UNIT 263

UNIT 265

UNIT 267

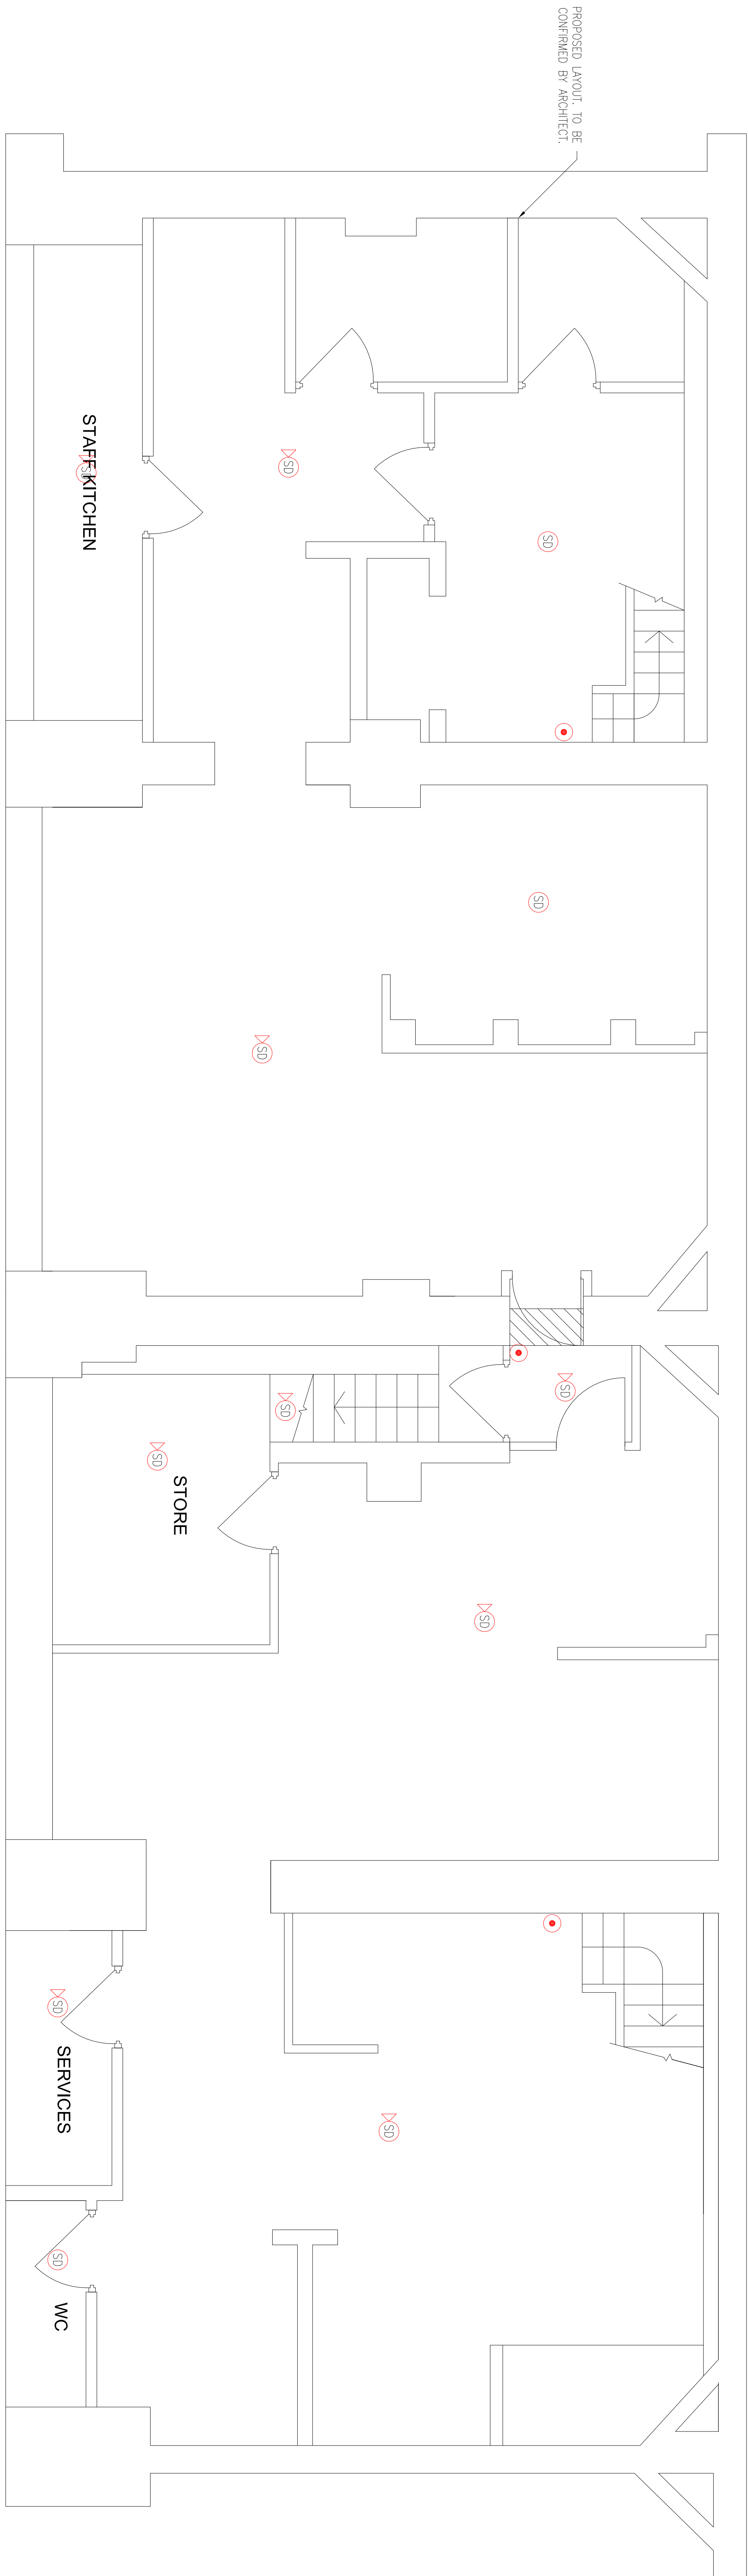

00 FLOOR PLAN
67-01-07 BASEMENT – FIRE ALARM & SECURITY
1:50

NOTES

1. DO NOT SCALE FROM THIS DRAWING
2. ALL WORKING TO BE ACCORD TO SITE FOR THE FABRICATION OF PARTS, ORDERING MATERIALS OR COMMENCING WORKS
3. THIS DRAWING IS TO BE READ IN CONJUNCTION WITH ALL OTHER CONSULTANT'S DRAWINGS, SPECIFICATIONS AND SCHEDULES
4. ANY PENETRATION THROUGH FLOOR, CEILING, STRUCTURAL ENGINEERS APPROVAL BEFORE COMMENCEMENT
5. ALL PLANT AND EQUIPMENT SHALL BE INSTALLED FULLY IN ACCORDANCE WITH MANUFACTURER'S RECOMMENDATIONS
6. FIRE STOPPING TO BE PROVIDED WHERE CABLES PASS THROUGH WALLS/FLOORS/CEILING/ROOFING & FIRE COMPARTMENT
7. THIS DRAWING SHALL BE READ IN COLOUR
8. ALL FINAL SETTING OUT OF ELECTRICAL ACCESSORIES BY ARCHITECTS

LEGEND	
SD	SMOKE DETECTOR
XSD	SMOKE DETECTOR W/ SOUNDER
.	MANUAL CALL POINT C/W LIFT UP COVER PLATE
FAP	FIRE ALARM PANEL
FAP	FIRE ALARM REPEATER PANEL
ABBREVIATIONS	
LL	– LOW LEVEL
HL	– HIGH LEVEL
FL	– FLOOR LEVEL
CV	– CEILING VOID
FB	– FROM BELOW
FT	– FROM TOP
DTB	– DROP TO BELOW
RIA	– RISE TO ABOVE

Revision	Description	Revised By
20.09.22	AS FITTED	C1 TOM SJ
13.05.22	COMMENT	P2 WP SJ
13.04.22	PRELIMINARY ISSUE	P1 WP SJ
Date	Description	Revised By

CONSOLUX
CONSOLUX M&E CONSULTING LTD.
MECHANICAL & ELECTRICAL CONSULTING ENGINEERS
London Office
35 Piccadilly
London W1J 0DW
Tel: +44 (0)207 734 3000
Fax: +44 (0)207 617 7365
Liverpool Office
The Cotton Exchange
Liverpool L3 9JR
Tel: +44 (0)151 708 9469
Fax: +44 (0)151 708 7196
moll@consolux.co.uk www.consolux.co.uk

Project:
261 – 267 DEANS GATE
MANCHESTER
M3 4EW

Drawing Title:
ELECTRICAL SERVICES
FIRE ALARM & SECURITY LAYOUT

Date:	Design By:	Drawn By:	Scale:
MAR 22	WP	WP	1:50

Issue Status:
AS FITTED

Drawing Number:
SP57-(67)-J00043-C1

Rev:
C1

11.04.2022

XREF Updated on: