

KEY TO WALLS:

- EXISTING WALLS
- NEW INTERNAL STUD WALL
- NEW INTERNAL STUD WALL, T&G LINED
- NEW EXPOSED BRICKWORK
- NEW BLOCKWORK

LIGHTING KEY:

10W LOW VOLTAGE OR LED RECESSED CUPBOARD DOWNLIGHT. Capsule light to fit within depth of bottom shelf of wall cupboard, allow provisional sum of £5 per fitting (supply).

TO BE UPDATED


- WALL MOUNTED DOWN LIGHTER
HI CUBE 32843 by National Lighting or similar approved
- WALL MOUNTED UP LIGHTER
HI CUBE 32843 by National Lighting or similar approved
- PENDANT FITTING
SHADE SUPPLIED BY CLIENT)
- RECESSED LED WALL GUIDE LUMINAIRE
DESIGN 32539 White LED by National Lighting or similar app.
- RECESSED LED STRIP
DESIGN 32539 White LED by National Lighting or similar app.

ELECTRICAL KEY:


- CAT 5 TELEPHONE/COMPUTER POINT
- SINGLE SOCKET UNDER WORK TOP
- SPUR SWITCH
- SINGLE SWITCHED SOCKET
- TWIN SWITCHED SOCKET
- SHAVR POINT
- TV AERIAL POINT
- SATELLITE TV POINT
- 5 AMP LIGHTING CIRCUIT SOCKET
- 2 WAY LIGHTING SWITCH
- LIGHTING SWITCH
- PULL CORD LIGHTING SWITCH
- CONSUMER UNIT
- MECHANICAL EXTRACT UNIT (IN LINE OR WALL MOUNTED)
- MECHANICAL EXTRACT FLAT DUCT GOING UP TO ROOF
- CEILING MOUNTED EXTRACT GRILLE

FIRE DETECTION KEY:

- MAINS OPERATED INTERLINKED HEAT DETECTOR WITH INTEGRAL SOUNDER
- MAINS OPERATED INTERLINKED SMOKE DETECTOR WITH INTEGRAL SOUNDER

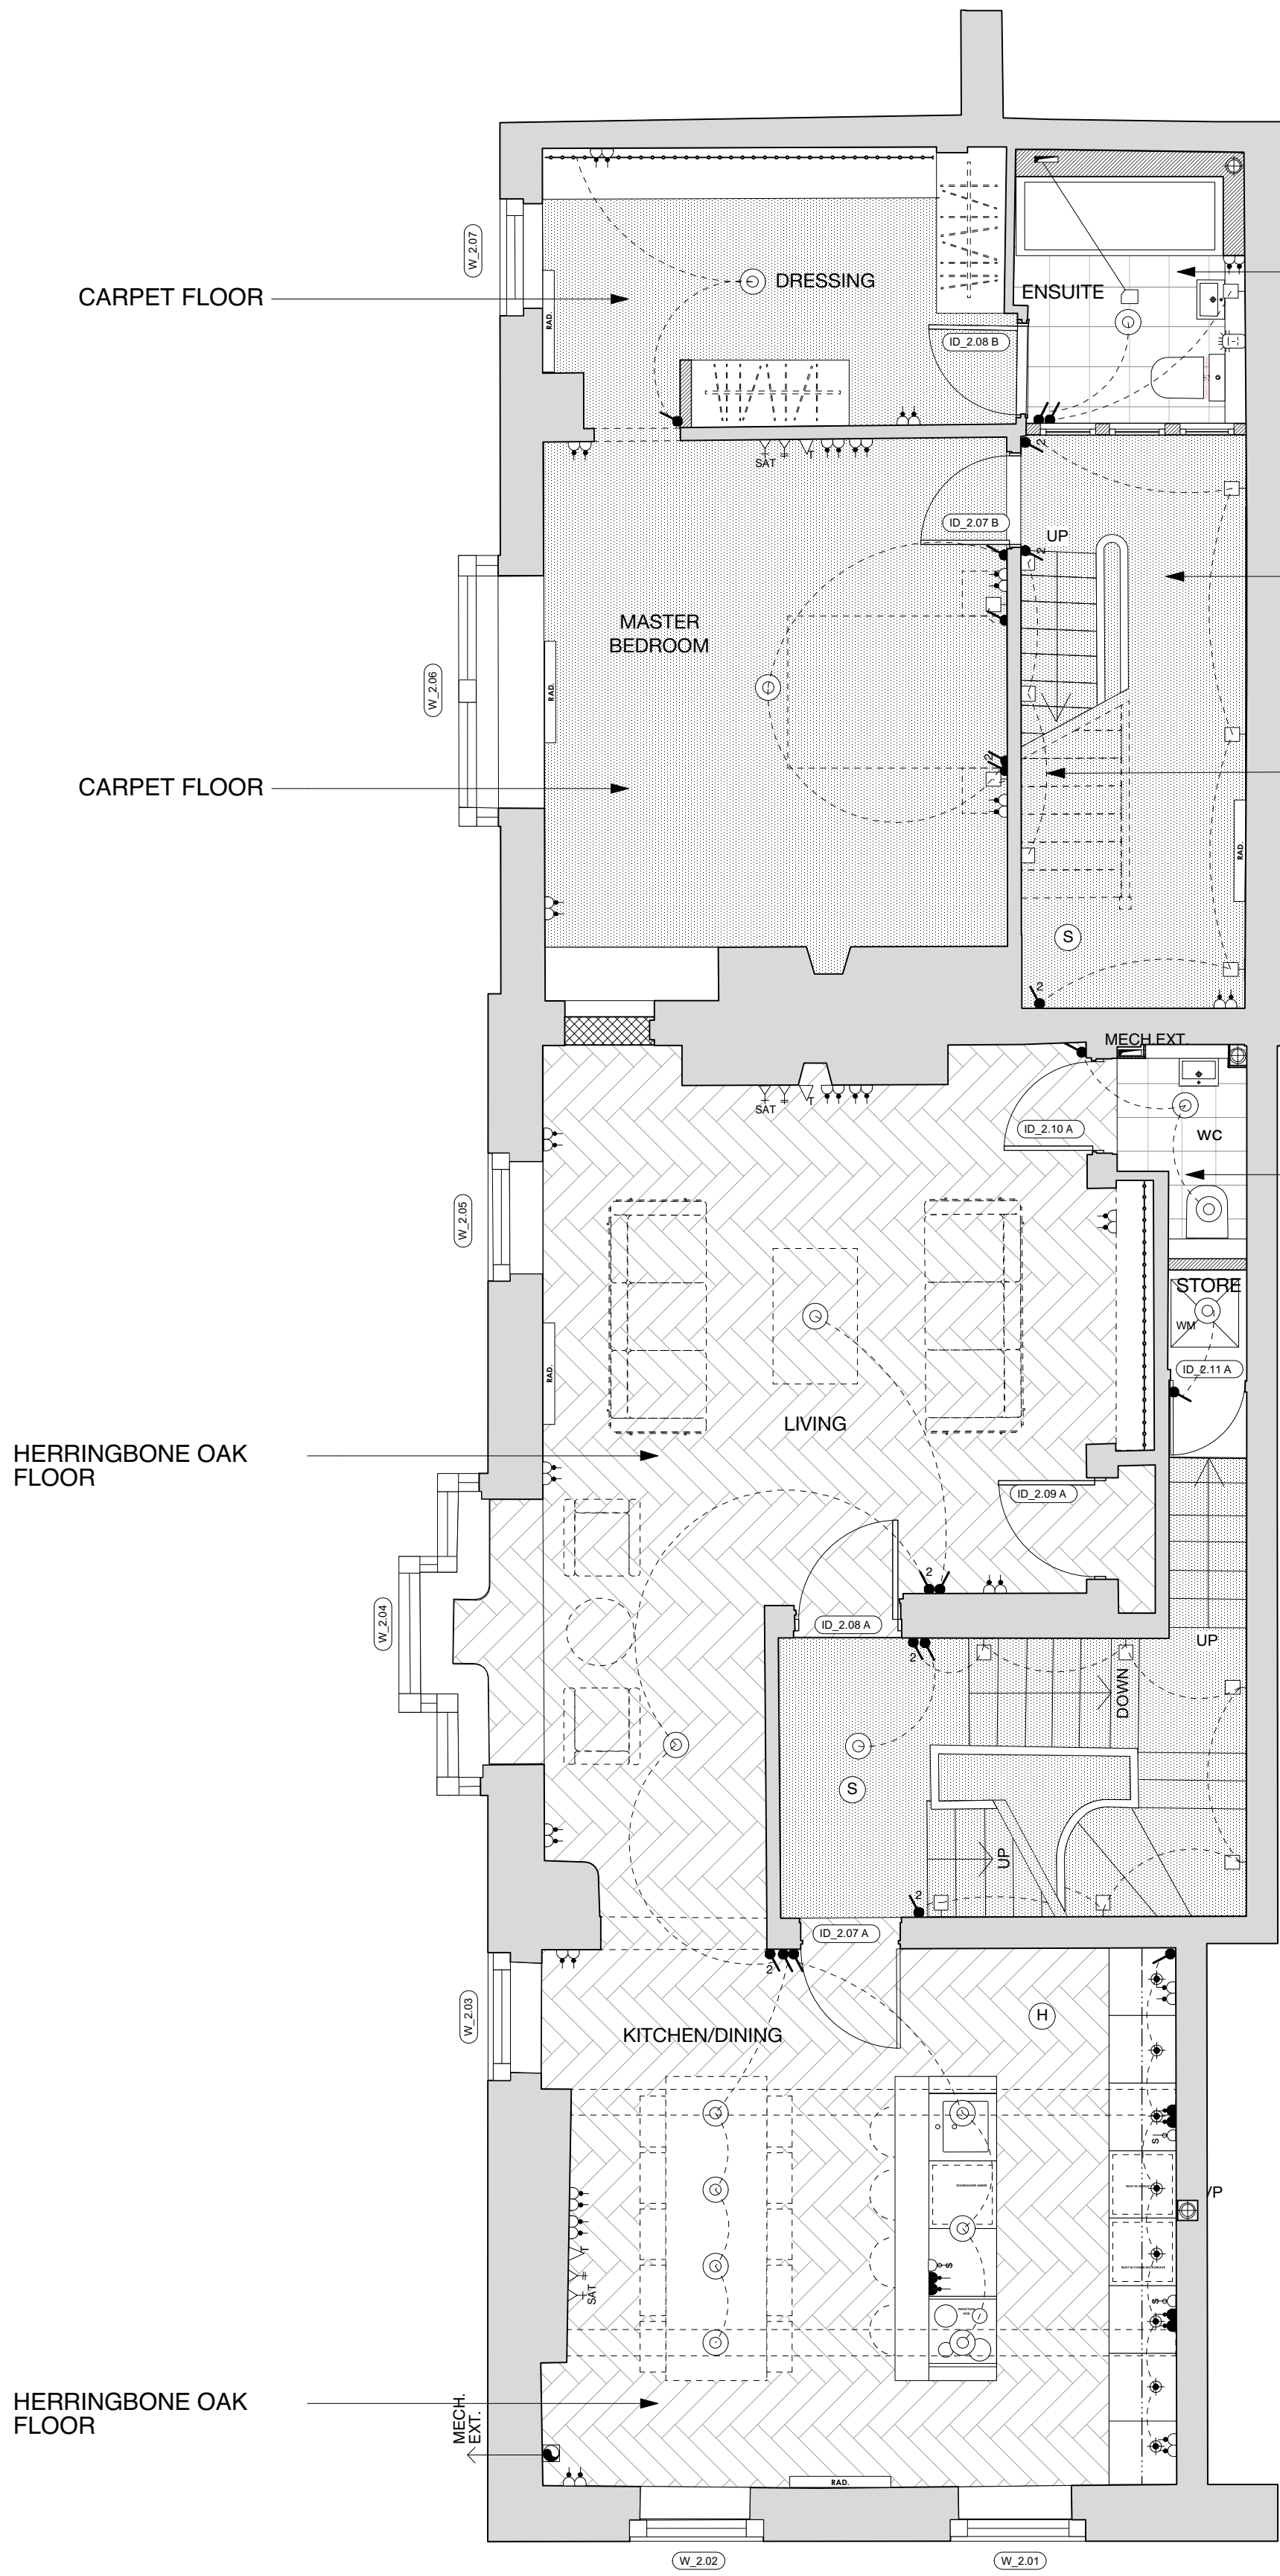

1ST FLOOR PLAN
1:50 @ A1

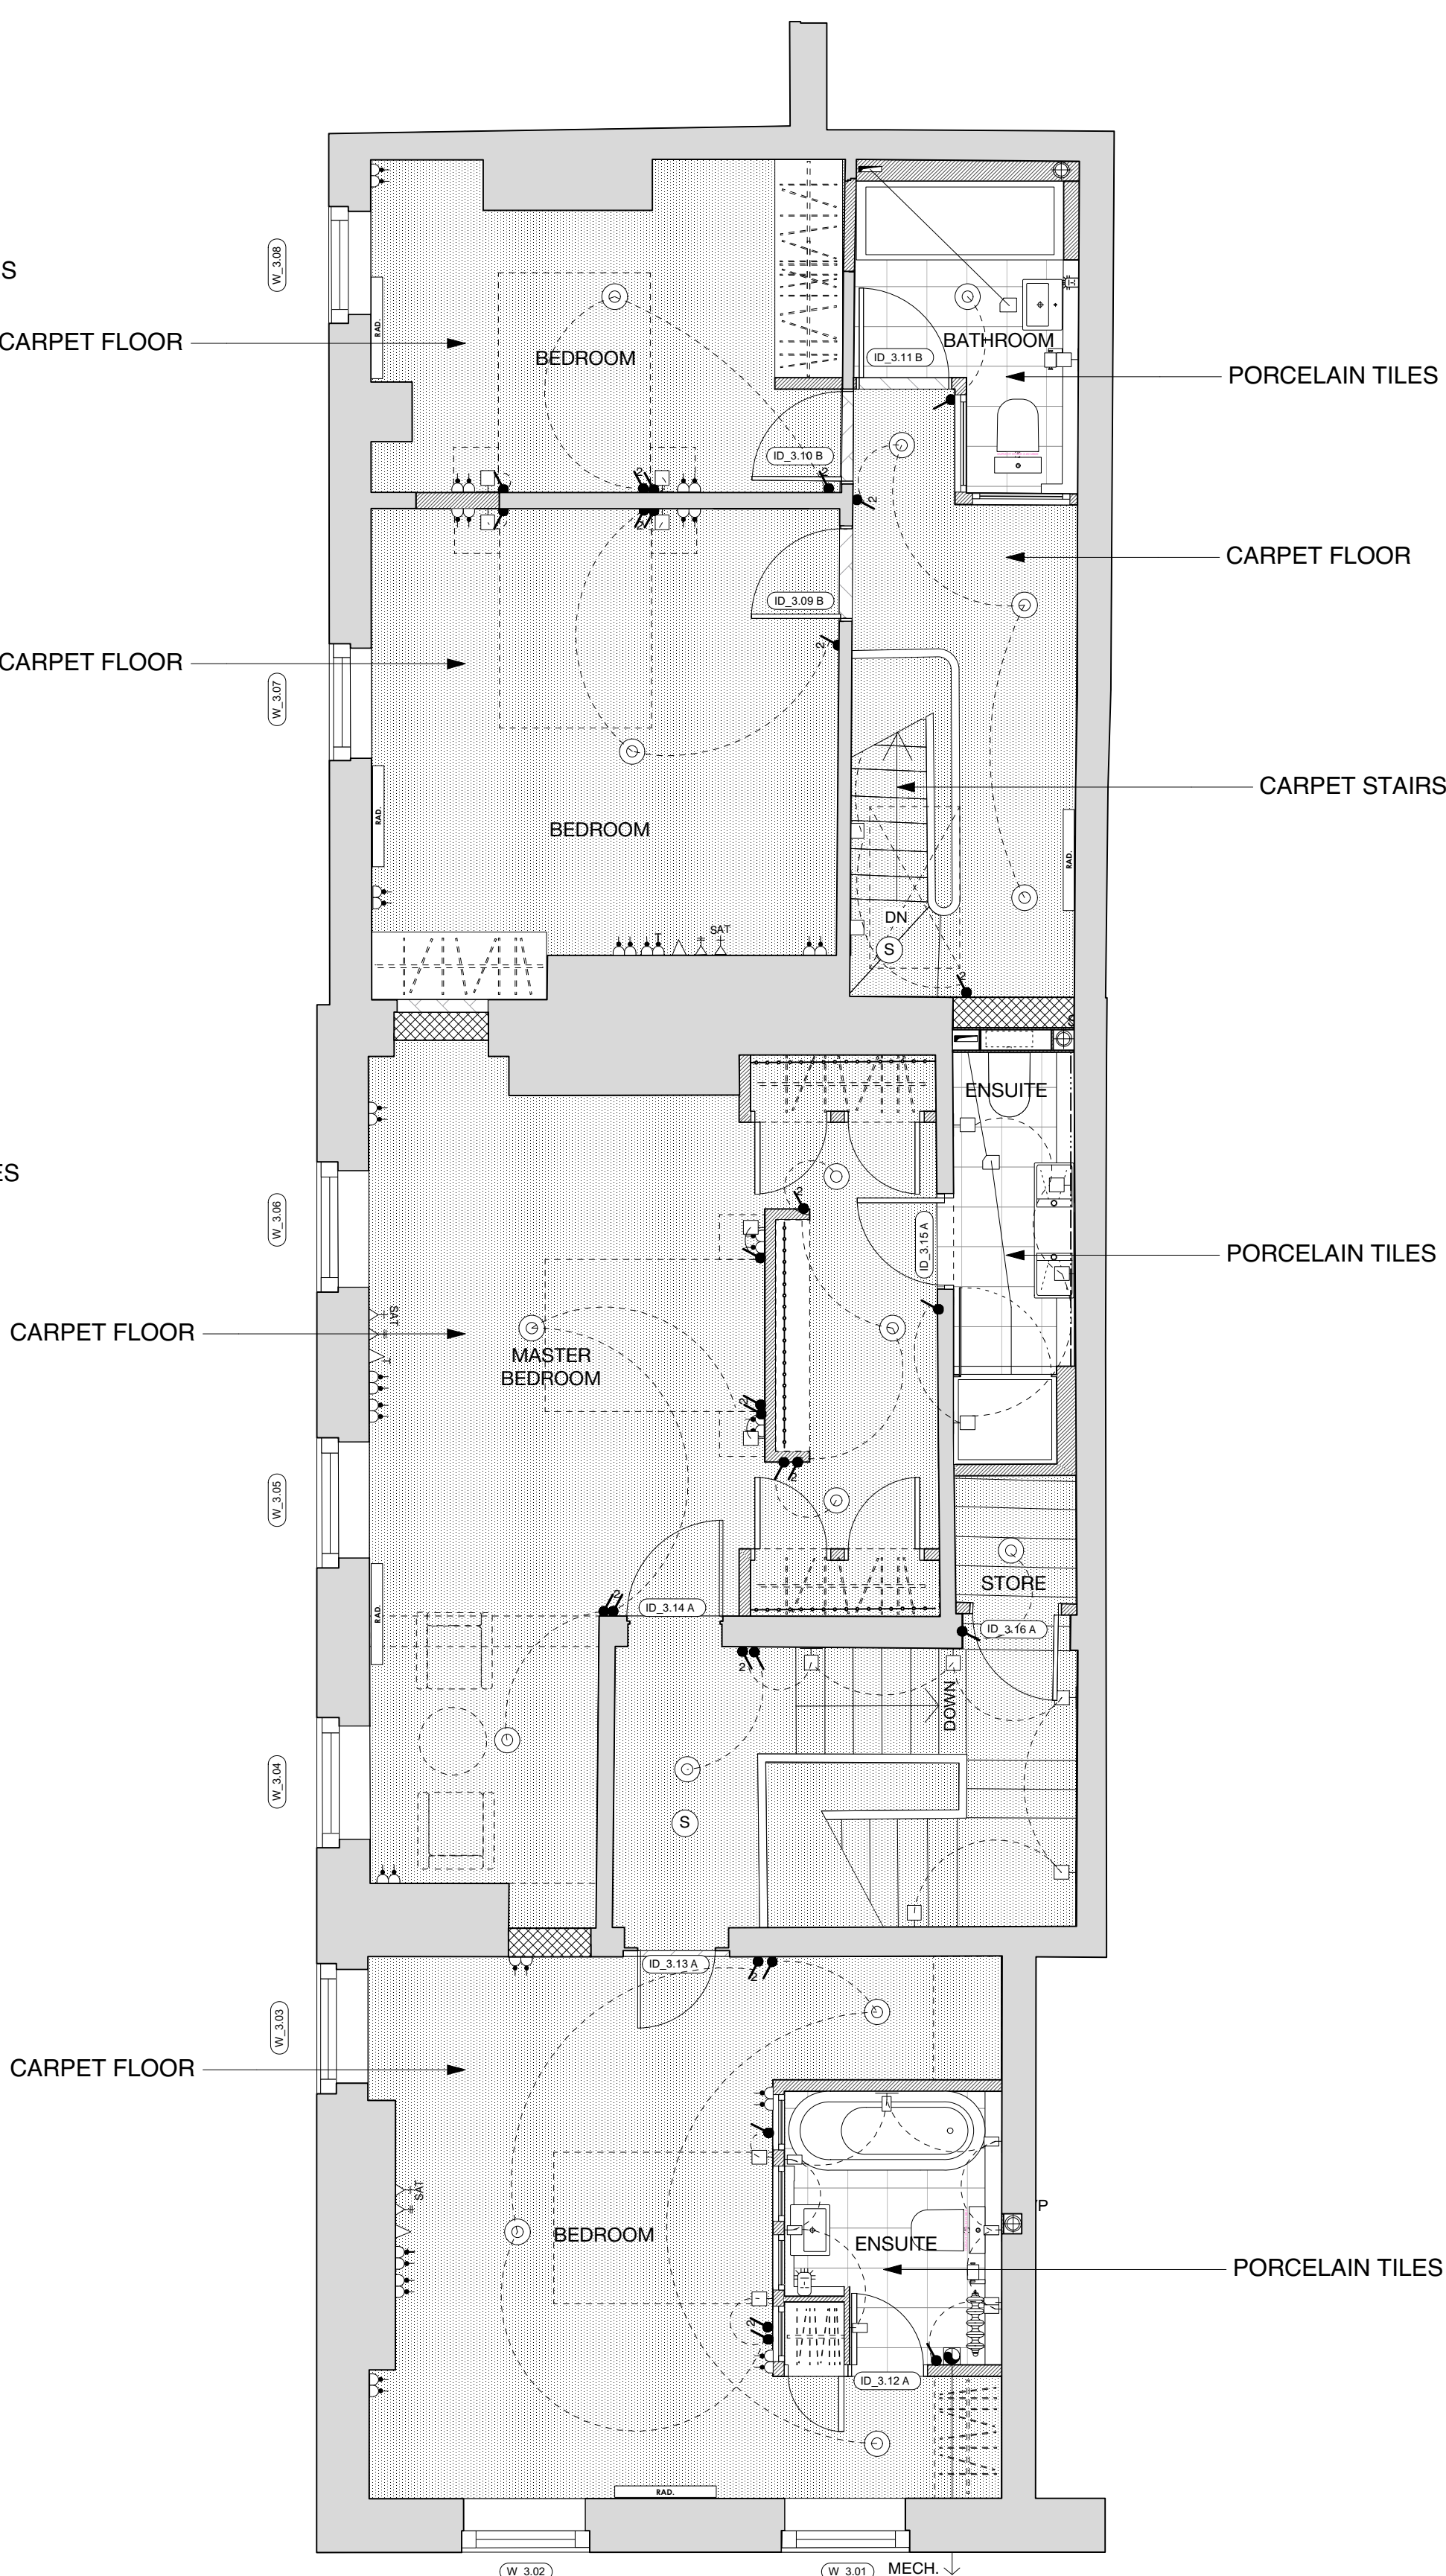

2ND FLOOR PLAN
1:50 @ A1

CONSTRUCTION

PROPOSED GA PLANS-1ST AND 2ND
1:50 @ A1
28 St John Street

IMPORTANT NOTES:

H	14.03.2024	Floor finishes mark up on drawings.
E	13.02.2024	Door swing to original doors we keep retained.
D	23.10.2023	2nd floor MB Ensuite amended.
C	29.08.2023	Additional wc and store added at 1st floor level. Electric box cupboard added in basement ensuite.
B	19.07.2023	Existing basement stair retained and minor amendments consequential to that. 2nd floor MB bathtub removed.
A	09/06/2023	MAE Updated
REVISION	DATE	DESCRIPTION

CLIENT: LEASING OPTIONS LTD	
PROJECT: PROPOSED RESIDENTIAL DEVELOPMENT	
ADDRESS: 28 ST JOHN STREET, MANCHESTER, M3 4DJ	
DRAWING TITLE: PROPOSED 1ST AND 2ND FLOORS	
SCALE: 1:50 @ A1	DATE: AUGUST 2023
DRAWING NO: A665_C_101F	

OLLIER SMURTHWAITE ARCHITECTS
40 King Street, Manchester, M2 6BA
T 0161 883 0838
F 0161 883 0839
E mail@olliersmurthwaite.com