

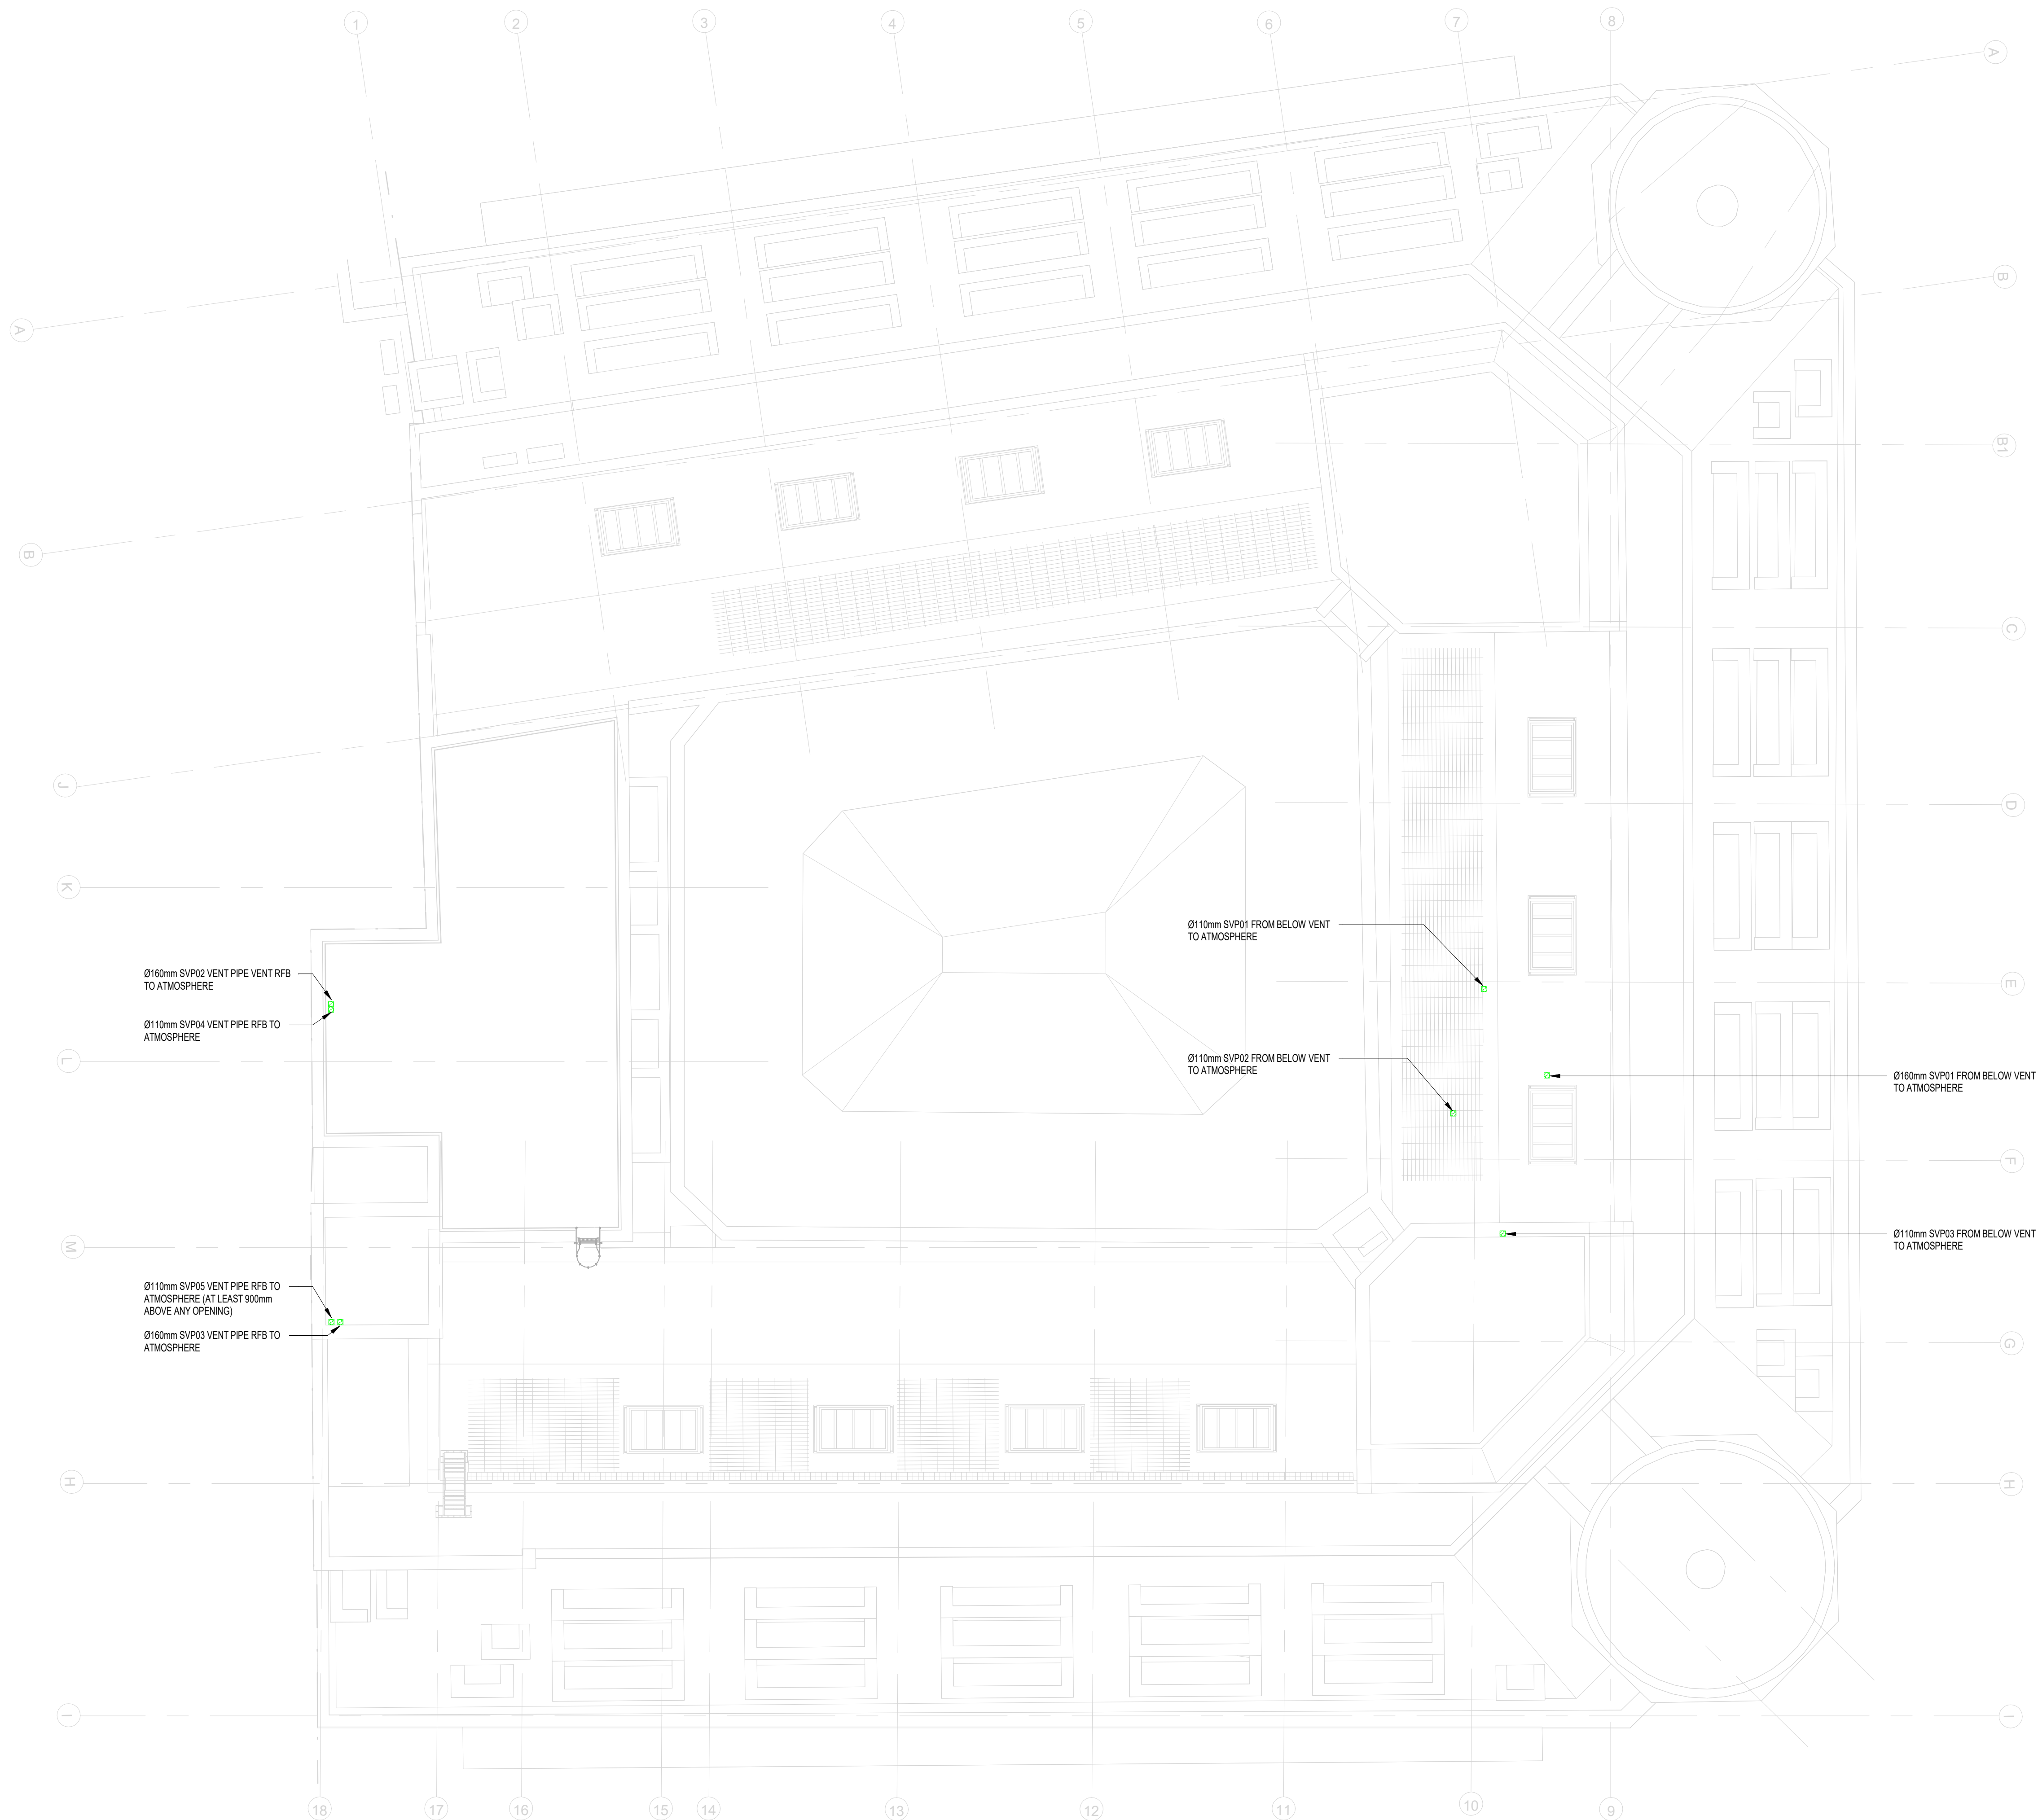
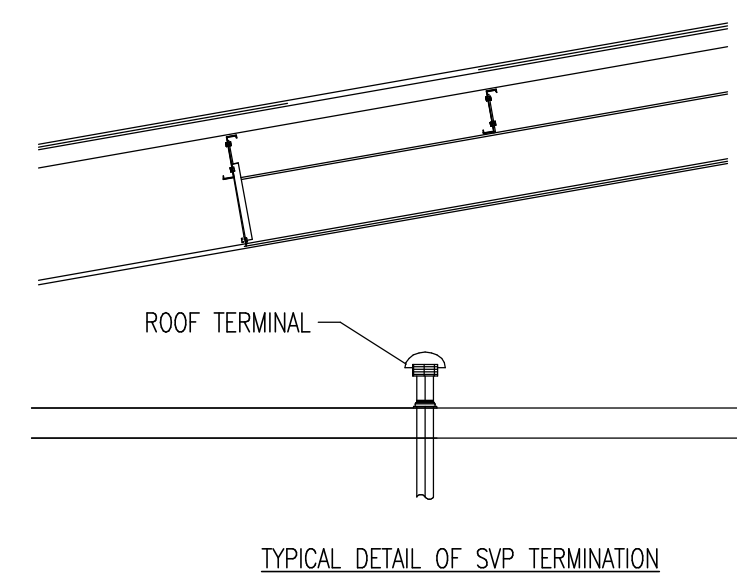
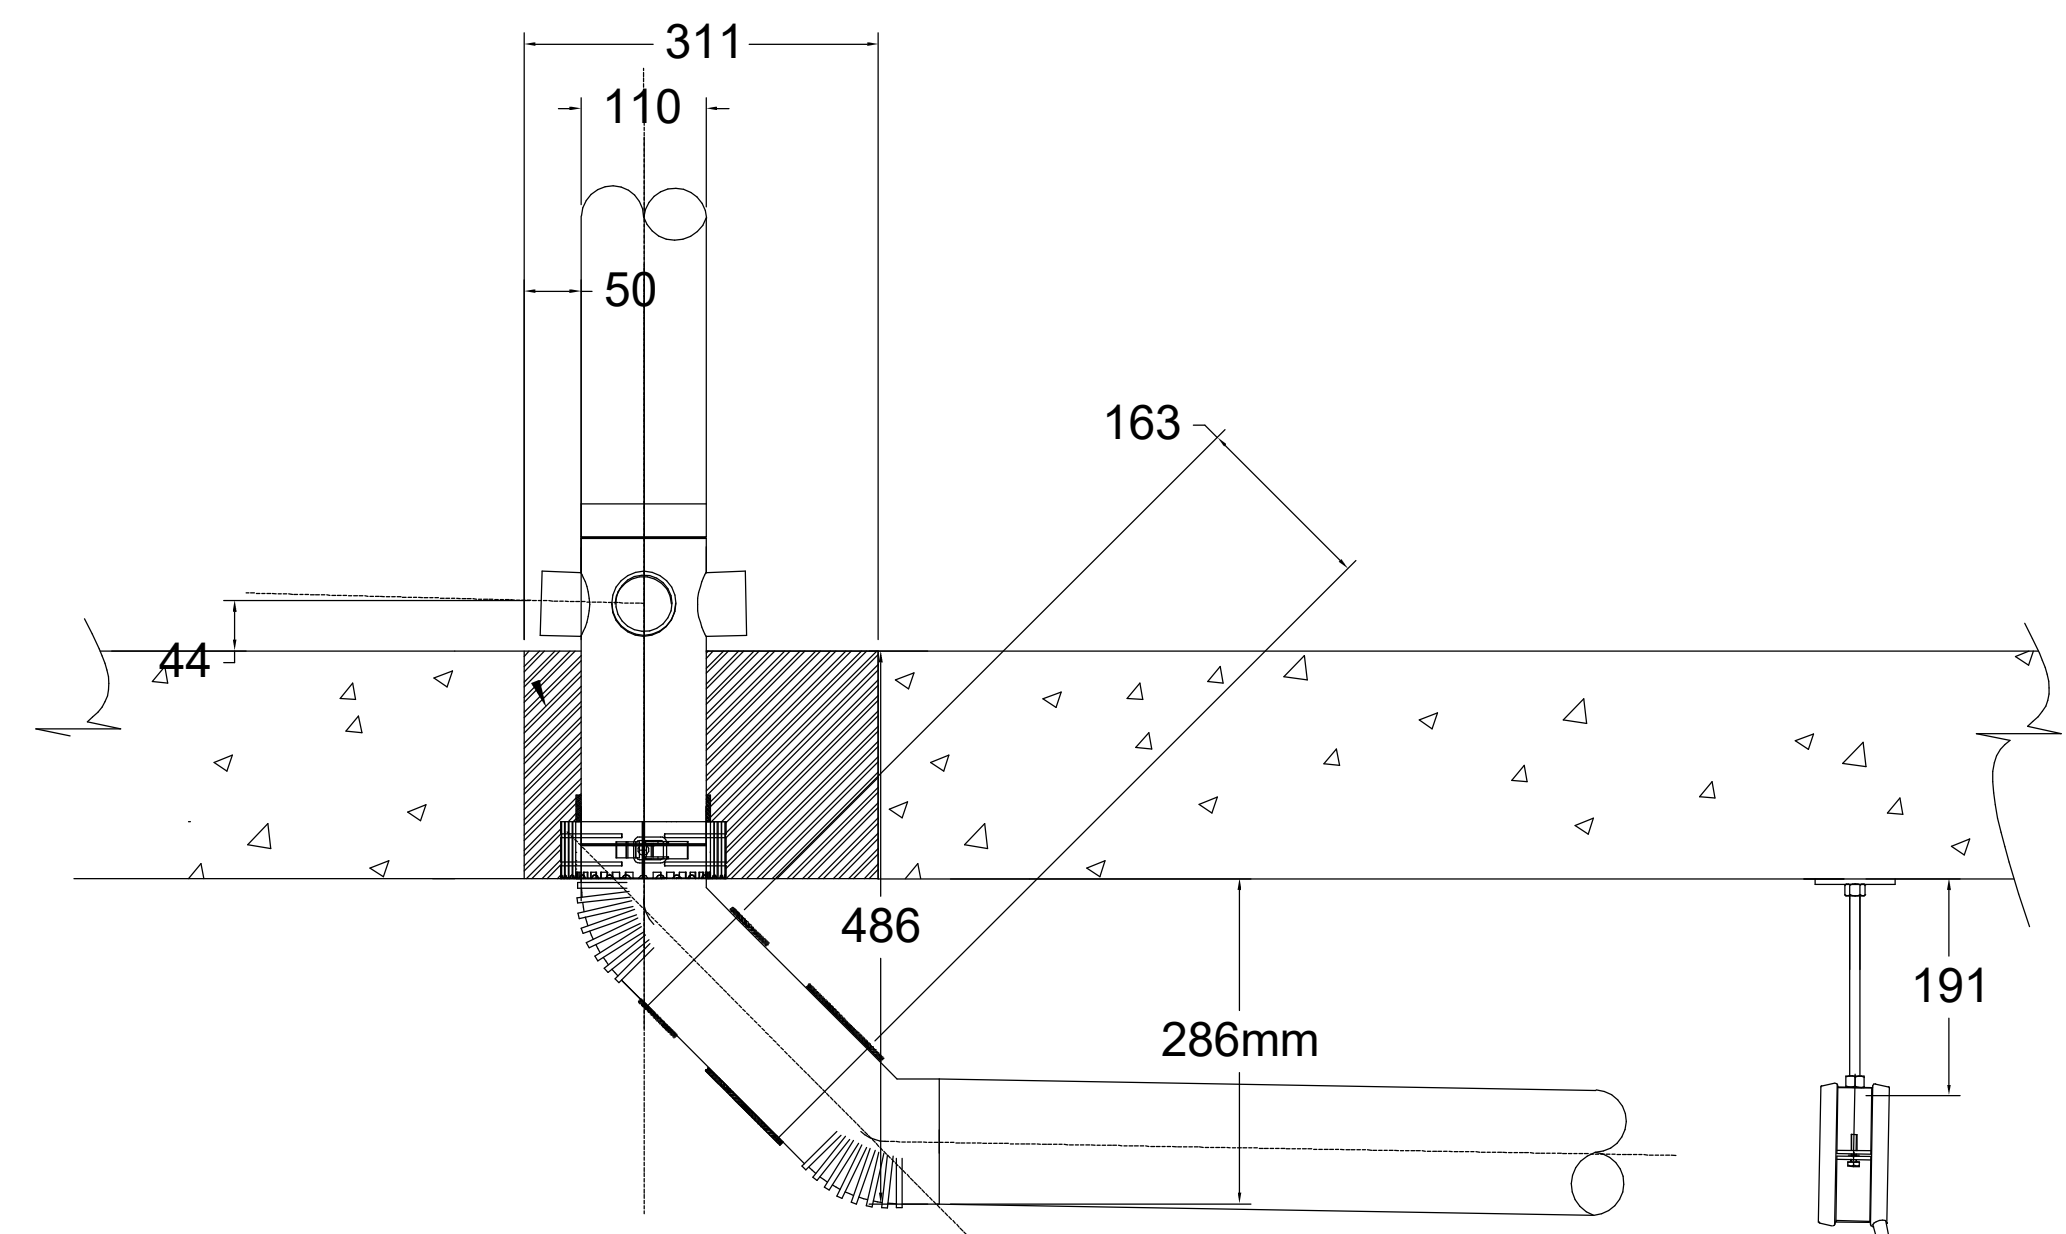
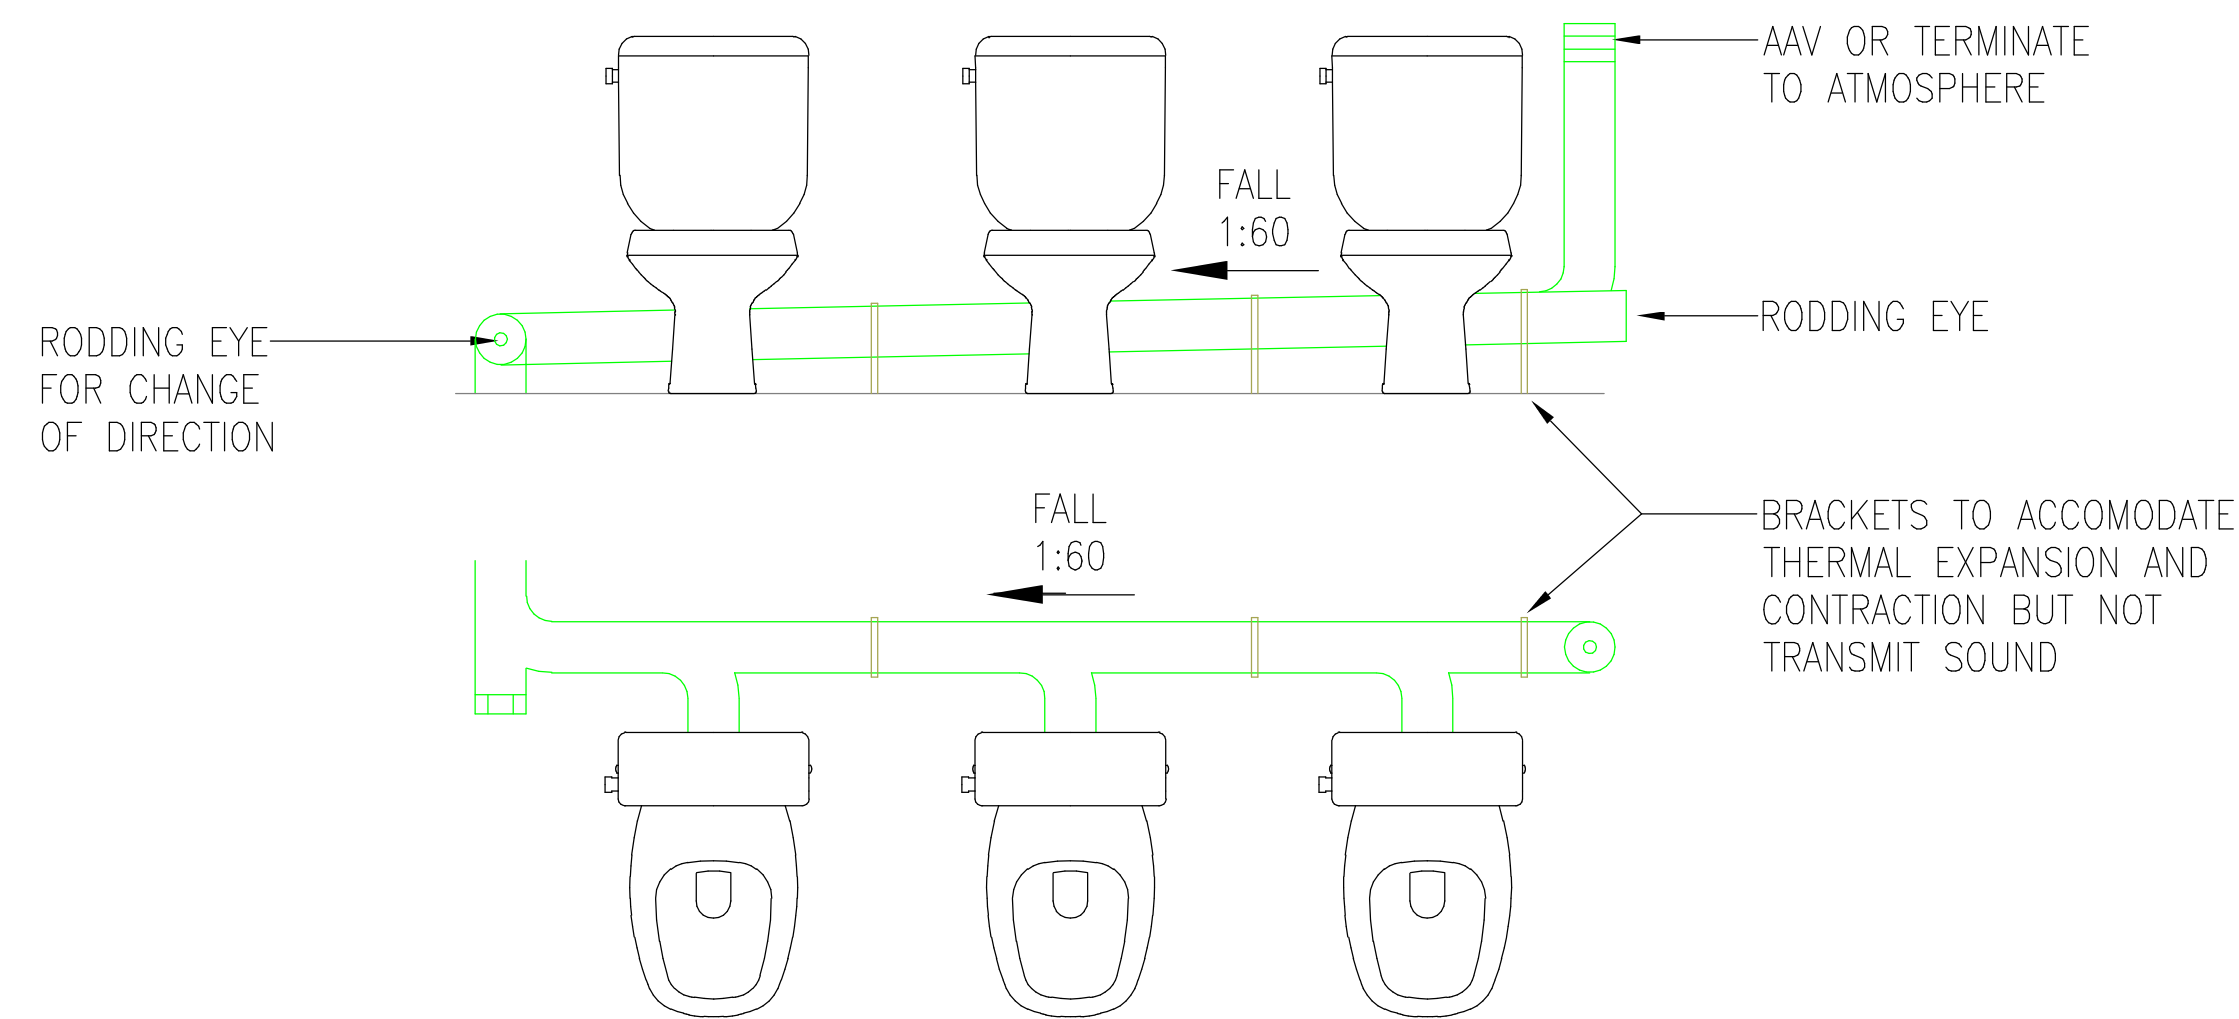
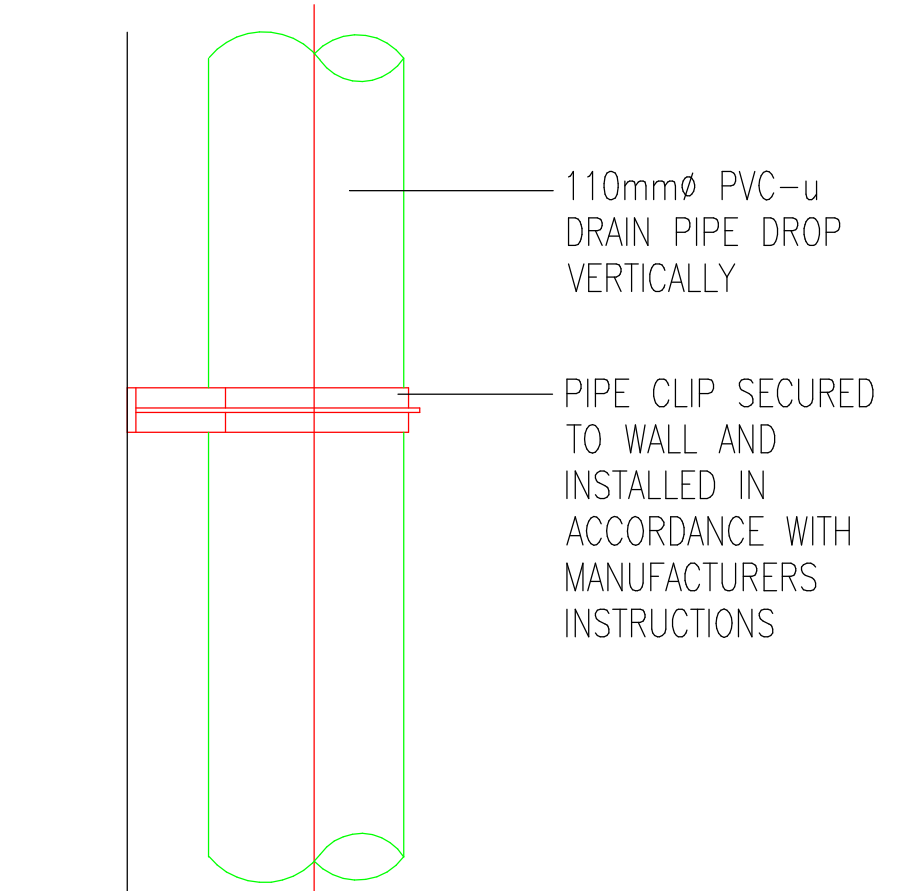
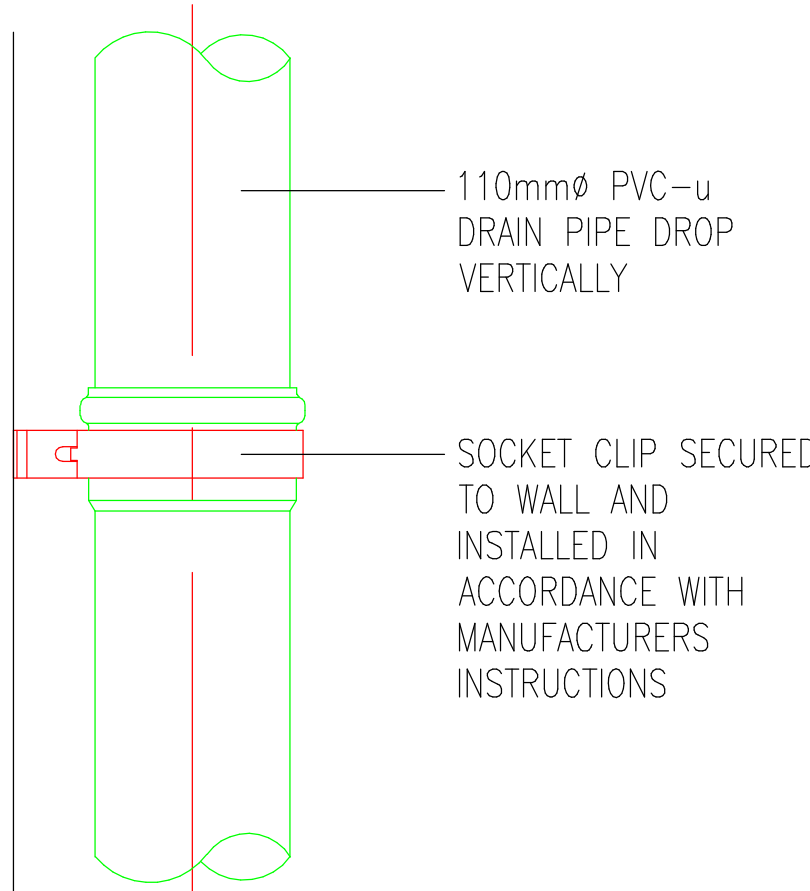


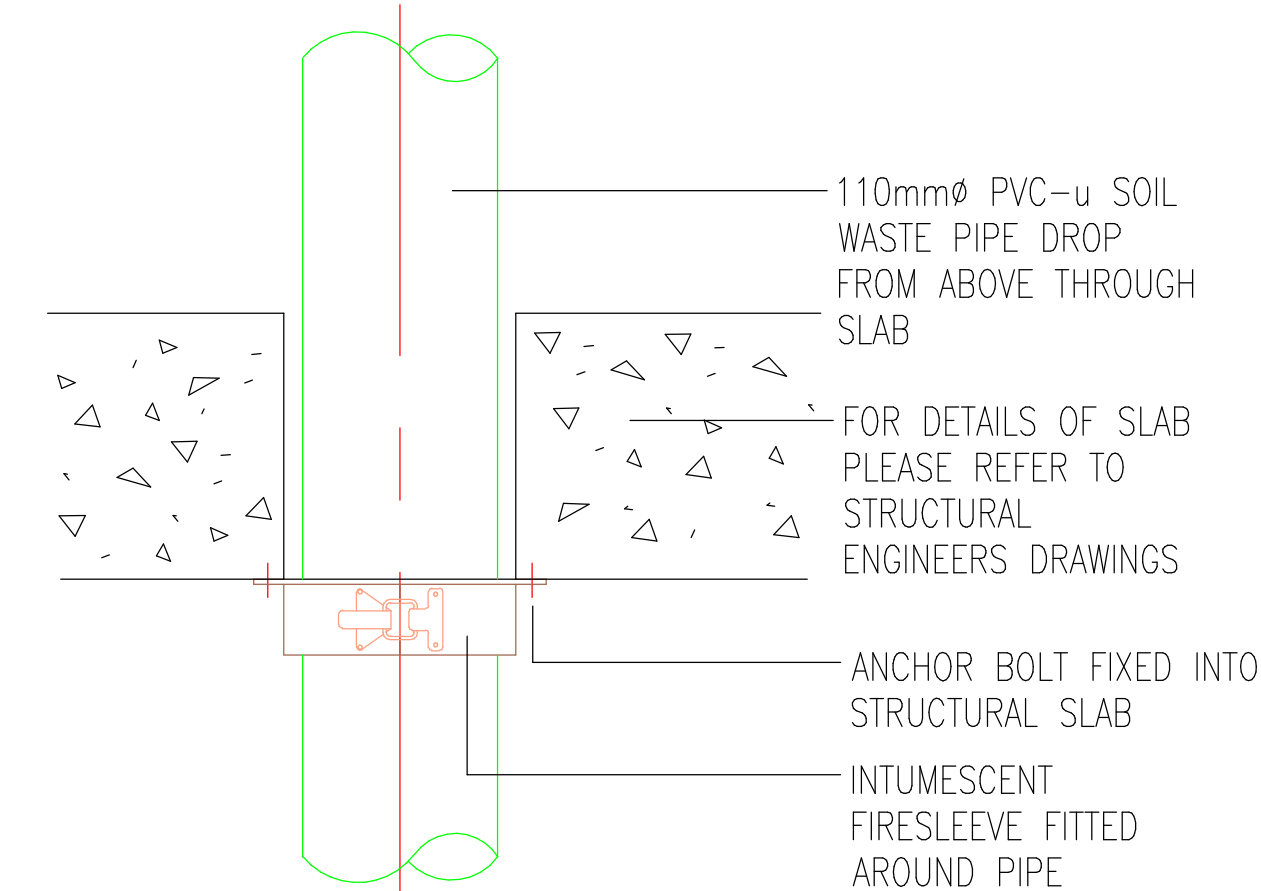

1 MECHANICAL SERVICES ABOVE GROUND DRAINAGE LAYOUT ROOF
1 : 100

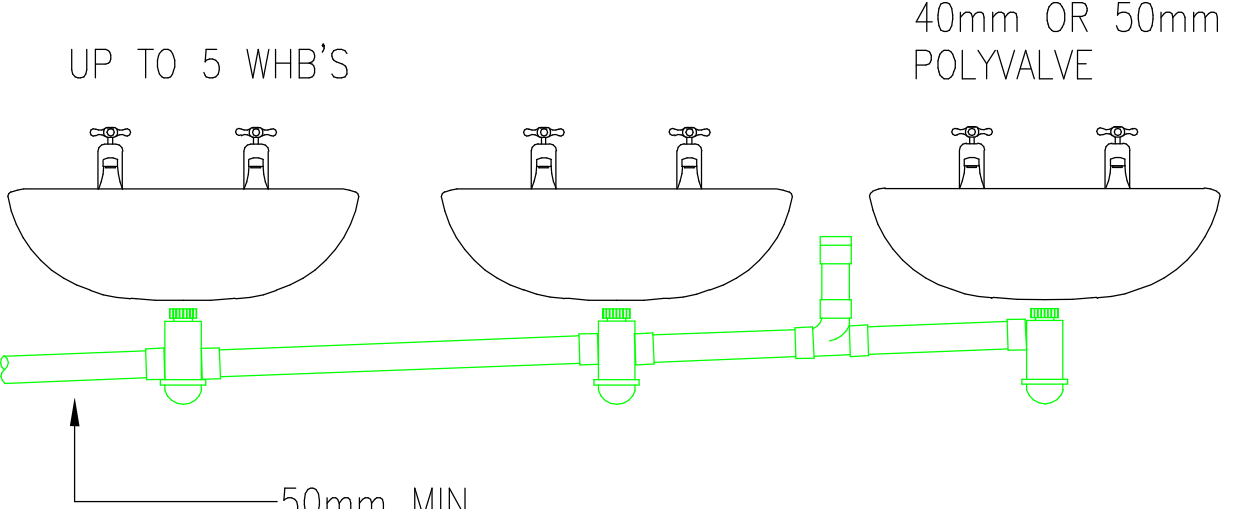

ARCHITECTURE IS BASED ON ANOMALY DESIGN ARCHITECTS
DRAWING NO. SLH-AND-PO-RF-OR-A-021RF(C01) LEVEL RF PLAN
12/03/2018 (01)

THIS DRAWING IS FOR INFORMATION ONLY DO NOT SCALE

CDM REGULATIONS

NUMBER	DATE ADDED	DATE INITIATED	DATE ASSESSMENT

LEGEND

RE (H) -

RODDING EYE

HIGH LEVEL PIPE

LOW LEVEL PIPE

BELOW GROUND PIPE

CONDENSATE PIPEWORK

SVP

SVP

SOIL VENT PIPE (PROPOSED)

SOIL VENT PIPE (EXISTING)

FLOOR GULLY

EXISTING FLOOR GULLY

DRAIN PUMP

ACCESS PANEL

DRAINAGE NOTES

1. DRAWING TO BE READ IN CONJUNCTION WITH SPECIFICATIONS.

2. REPORT ANY DISCREPANCIES TO THE DRAWING ORIGINATOR IMMEDIATELY.

3. ALL DIMS ARE IN MM UNLESS STATED OTHERWISE.

4. SANITATION PIPEWORK MUST COMPLY WITH BUILDING REGULATIONS PART H.

5. DRAINAGE SERVICES SHALL COMPLY WITH BS EN 12056 (SYSTEM H).

6. ALL HORIZONTAL WASTE PIPES TO HAVE 1:40 GRADIENT WHERE FEASIBLE.

7. PIPEWORK MUST BE SUPPORTED IN LINE WITH MANUFACTURERS RECOMMENDATIONS.

8. ALL PIPEWORK TO BE SOLVENT WELD. PUSH FIT TO FINAL APPLIANCE ONLY FOR EASY MAINTENANCE.

9. INSTALLATION TO ALLOW FOR EXPANSION WITH SLP JOINTS TO SUIT.

10. ACCESS/RODDING POINTS SHALL BE FITTED AT EACH FLOOR LEVEL, AT THE END OF HORIZONTAL BRANCHES, ALL CHANGES IN DIRECTION & EVERY 10M ON STRAIGHT SECTIONS.

11. W/C MANIFOLDS SHALL HAVE VENTED UPSTAND RODDING POINTS ABOVE LEVEL OF CISTERN.

12. ALL NEW VENT PIPE TERMINATIONS TO ATMOSPHERE SHALL BE AGREED WITH THE ARCHITECT.

13. ALL ROOF PENETRATIONS SHALL BE WEATHERED IN ACCORDANCE WITH THE ROOF SPECIALISTS REQUIREMENTS.

14. ALL BASINS/SINKS CONNECTING TO A RUN WHICH DOES NOT CONNECT TO A VENT PIPE MUST USE ANTI-SYPHON TRAPS.

15. PLASTIC PIPES PENETRATING A FIRE COMPARTMENT (REFER TO FIRE STRATEGY DRAWINGS), 100MM AND ABOVE SHALL BE FITTED WITH A SUITABLY INSTALLED FIRE COLLAR.

16. ALL BENDS TO BE LONG RADIUS SWEPT BENDS. IDEALLY USING 135° ENDS TO FORM A BEND. USE OF 90° ELBOWS ARE NOT ACCEPTABLE.

17. ALL DRAINAGE PIPEWORK PASSING THROUGH NOISE SENSITIVE SPACES SHALL BE ACoustICALLY LAGGED.

18. ALL EXPOSED DRAINAGE PIPES TO BE WHITE IN COLOUR.

19. HEP20 WATERLESS TRAPS SHALL BE INSTALLED ON CONDENSATE PIPE CONNECTIONS.

20. ALL FLOOR GULLIES SHALL BE PROVIDED AS PART OF THE UNDERGROUND DRAINAGE PACKAGE. LOCATIONS SHOWN FOR INFORMATION ONLY.

21. KITCHENETTE AREA - TERMINATION POINTS TO BE AGREED WITH CONTRACTOR.

FOR COMMENT & APPROVAL

Commercial Services Design Ltd

Unit 5
Woodside Court
Clayton Wood Rise
Leeds LS15 8HF
Tel: 0113 3223190
Web: www.csdesign.uk.com

CSD

Commercial Services Design Ltd

G&H GROUP OF COMPANIES

CLIENT

G&H BUILDING SERVICES

PROJECT

SUNLIGHT HOUSE
LITTLE QUAY STREET
MANCHESTER M3 3HP

TITLE

MECHANICAL SERVICES ABOVE GROUND
DRAINAGE LAYOUT ROOF

SCALE 1:100

DESIGNER

CSD 1298

DRAWN

MW

ENGINEER

DB

ISSUED

JUNE 24

ISSUED

AUGUST 24

APPROVED

DB

APPROVED

BW

1298-CSD-XX-RF-DR-M-5216

P03

Project Originator: Valued Local Type-Designer-Customer

This drawing is the property of Commercial Services Design Ltd. It is created by a member of the design team responsible for the design, development and production of the project. It is not to be used for any other purpose without the written consent of Commercial Services Design Ltd. The drawing is the property of Commercial Services Design Ltd.