


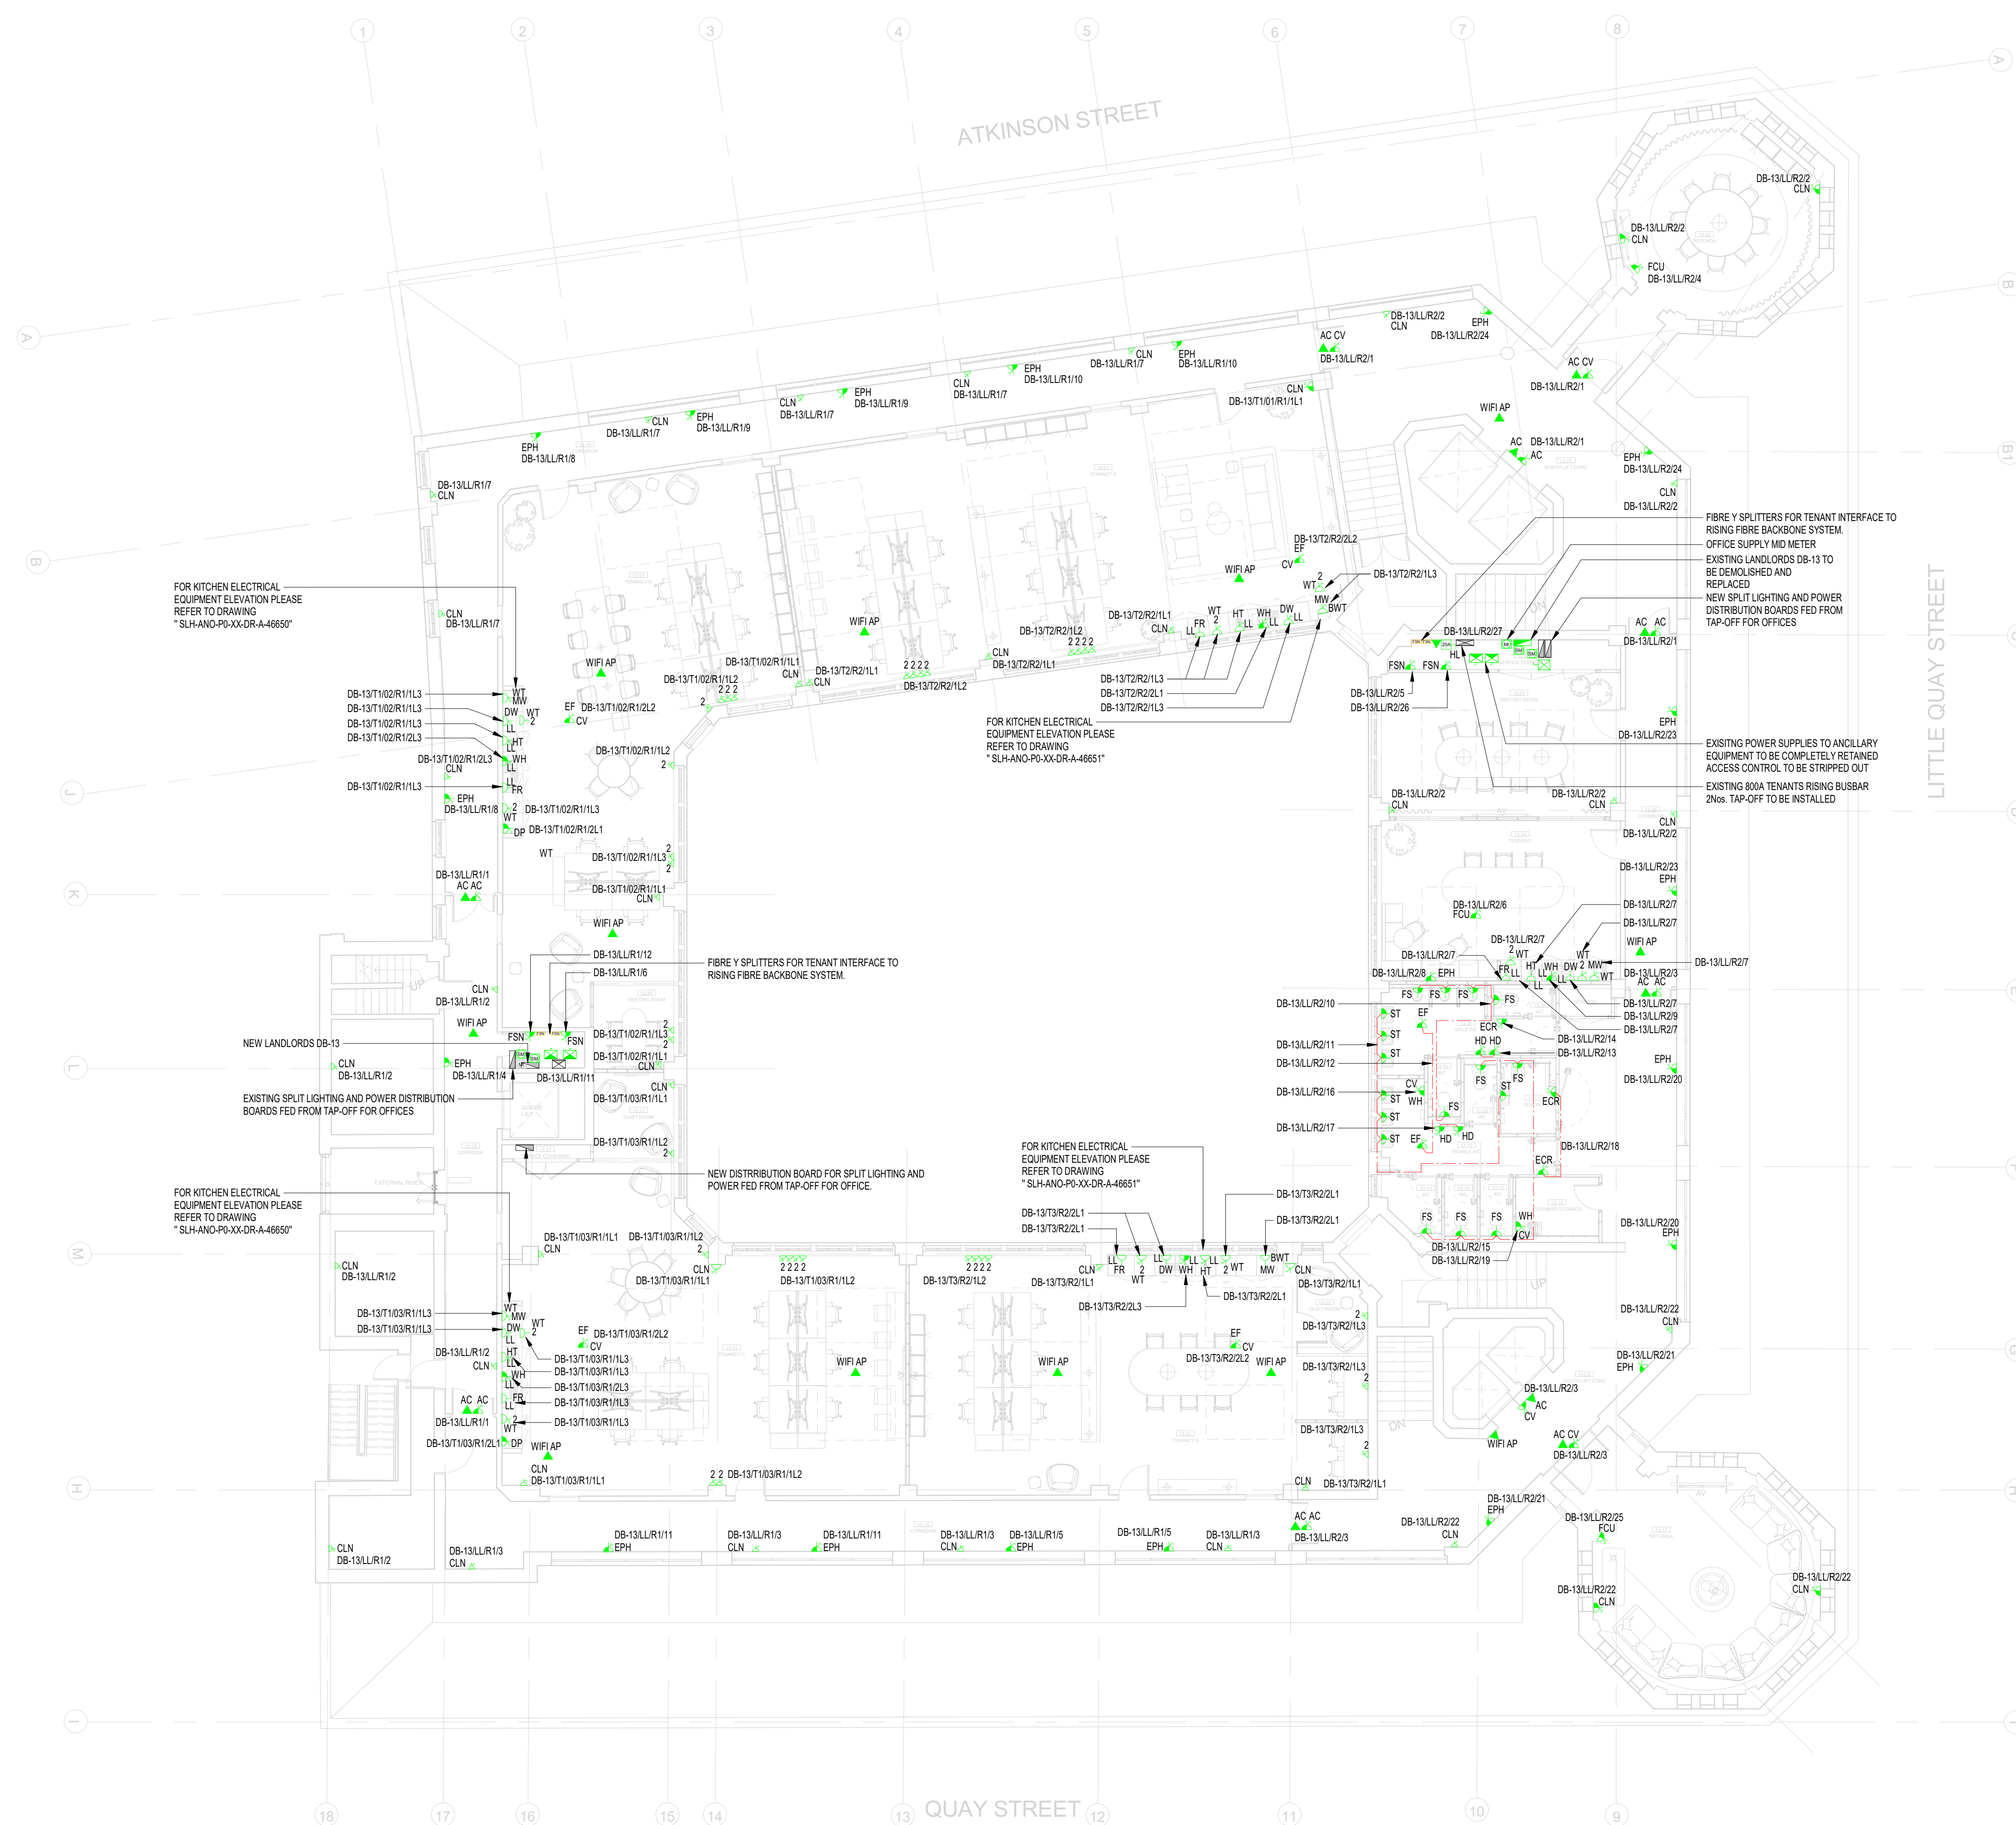

ABBREVIATIONS

HD	HAND DRYER
EF	EXTRACT FAN
CV	CEILING VOID
EPH	ELECTRIC PANEL HEATER
ST	SENSOR TRAP
CLN	CLEANERS SOCKET
FS	FLOW SWITCH
FCU	FAN COOL UNIT
AC	ACCESS CONTROL
ECR	ELECTRIC CONTROL RADIATOR
WH	WATER HEATER
DP	DRAIN PUMP
LL	MOUNTED AT LOW LEVEL
ML	MOUNTED AT MID LEVEL
HL	MOUNTED AT HIGH LEVEL
DAS	DISABLE ALARM SYSTEM
EAC	ELECTRIC AIR CURTAIN
HT	HOT WATER TAP
FSN	FIBRE SPLITTER NODE
BC	BRANCH CONTROLLER
FR	FRIDGE
MW	MICROWAVE
WT	WORK TOP (FOR KITCHENETTES)
BWT	BELOW WORK TOP (FOR KITCHENETTES)
DW	DISH WASHER

THIS DRAWING IS FOR INFORMATION ONLY DO NOT SCALE

CDM REGULATIONS

HAZARD	DATE ASSESSED	DATE INITIATED	DATE ASSESSMENT

LEGEND

- SPAN DISTRIBUTION BOARD
- TPAN DISTRIBUTION BOARD
- MAIN SWITCH BOARD/LY PANEL
- UNSWITCHED 13A SINGLE SOCKET OUTLET
- SWITCHED 13A SINGLE SOCKET OUTLET
- TWIN 13A SWITCHED SOCKET OUTLET - CLN DENOTES CLEANERS SOCKET
- UNSWITCHED FUSED CONNECTION UNIT
- SWITCHED FUSED CONNECTION UNIT
- SWITCHED FUSED CONNECTION UNIT w/ NEON INDICATOR
- RED DP 13A FUSED CONNECTION UNIT w/ NEON INDICATOR & BARREL LOCK
- COMMANDO SOCKET
- DOUBLE POLE ISOLATING SWITCH (20A)
- THREE POLE ISOLATING SWITCH
- 3 POLE ISOLATOR
- SPAN ISOLATOR
- TPAN ISOLATOR
- RJ45 DATA OUTLET POINT
- TELEPHONE OUTLET POINT
- COOKER CONNECTION UNIT
- AUDIOVISUAL PLATE
- DADO TRUNKING
- HDMI PORT
- DADO DROPPERS
- EMERGENCY STOP BUTTON
- 13A TWIN SWITCHED SOCKET & 2x 13A OUTLETS (2 COMPARTMENT FLOORBOX)
- DISABLED ALARM PULL CORD SWITCH w/ INTEGRAL REASSURANCE LAMP
- RESET PUSH BUTTON
- DISABLED ALARM INDICATOR LAMP w/ INTEGRAL SOUNDER
- 3 COMPARTMENT DADO DROPPER
- DISTRIBUTION UNIT BOX
- CLEANERS SOCKET FLOOR GORMET
- SOCKET & 2x DATA OUTLETS (4 COMPARTMENT FLOORBOX)
- UNSWITCHED FUSE SPUR FOR FIRE CURTAIN (IN COMPLIANCE WITH BS54)
- CLG-131 SUSPENDED PLASTERBOARD BULKHEAD FINISHED IN PPT-131, INCLUDE CLG-911 ACCESS PANELS
- 63A UNDERFLOOR BUS BAR POWER TRACK
- FSN FIBRE SPLITTER NODE
- SMART METER
- MID METER
- WIFI AP
- BOOSTER PUMP

REV	DATE	AMENDMENTS	BY	CHK
REV	DATE	AMENDMENTS	BY	CHK

FOR COMMENT & APPROVAL

Commercial Services Design Ltd
Unit 5
Woodside Court
Clayton Wood Rise
Leeds LS15 8HF
Tel: 0113 3223190
Web: www.csdesign.uk

G&H GROUP OF COMPANIES

CLIENT
G&H BUILDING SERVICES

PROJECT
SUNLIGHT HOUSE
LITTLE QUAY STREET
MANCHESTER M3 3HP

TITLE
ELECTRICAL SERVICES SMALL POWER AND DATA LAYOUT
LEVEL 13

SCALE @ 1:100

DESIGNER
CSD 1298

ENGINEER
DB

ISSUED
AUGUST 24

APPROVED
BW

1298-CSD-XX-13-DR-E-6214

P01

ARCHITECTURE IS BASED ON ANIMALY DESIGN
ARCHITECTS DRAWING NO. SLH-AND-PO-13-DR-A-6651
(001) LEVEL 13 PLAN
RECEIVED: 03.08.2024