


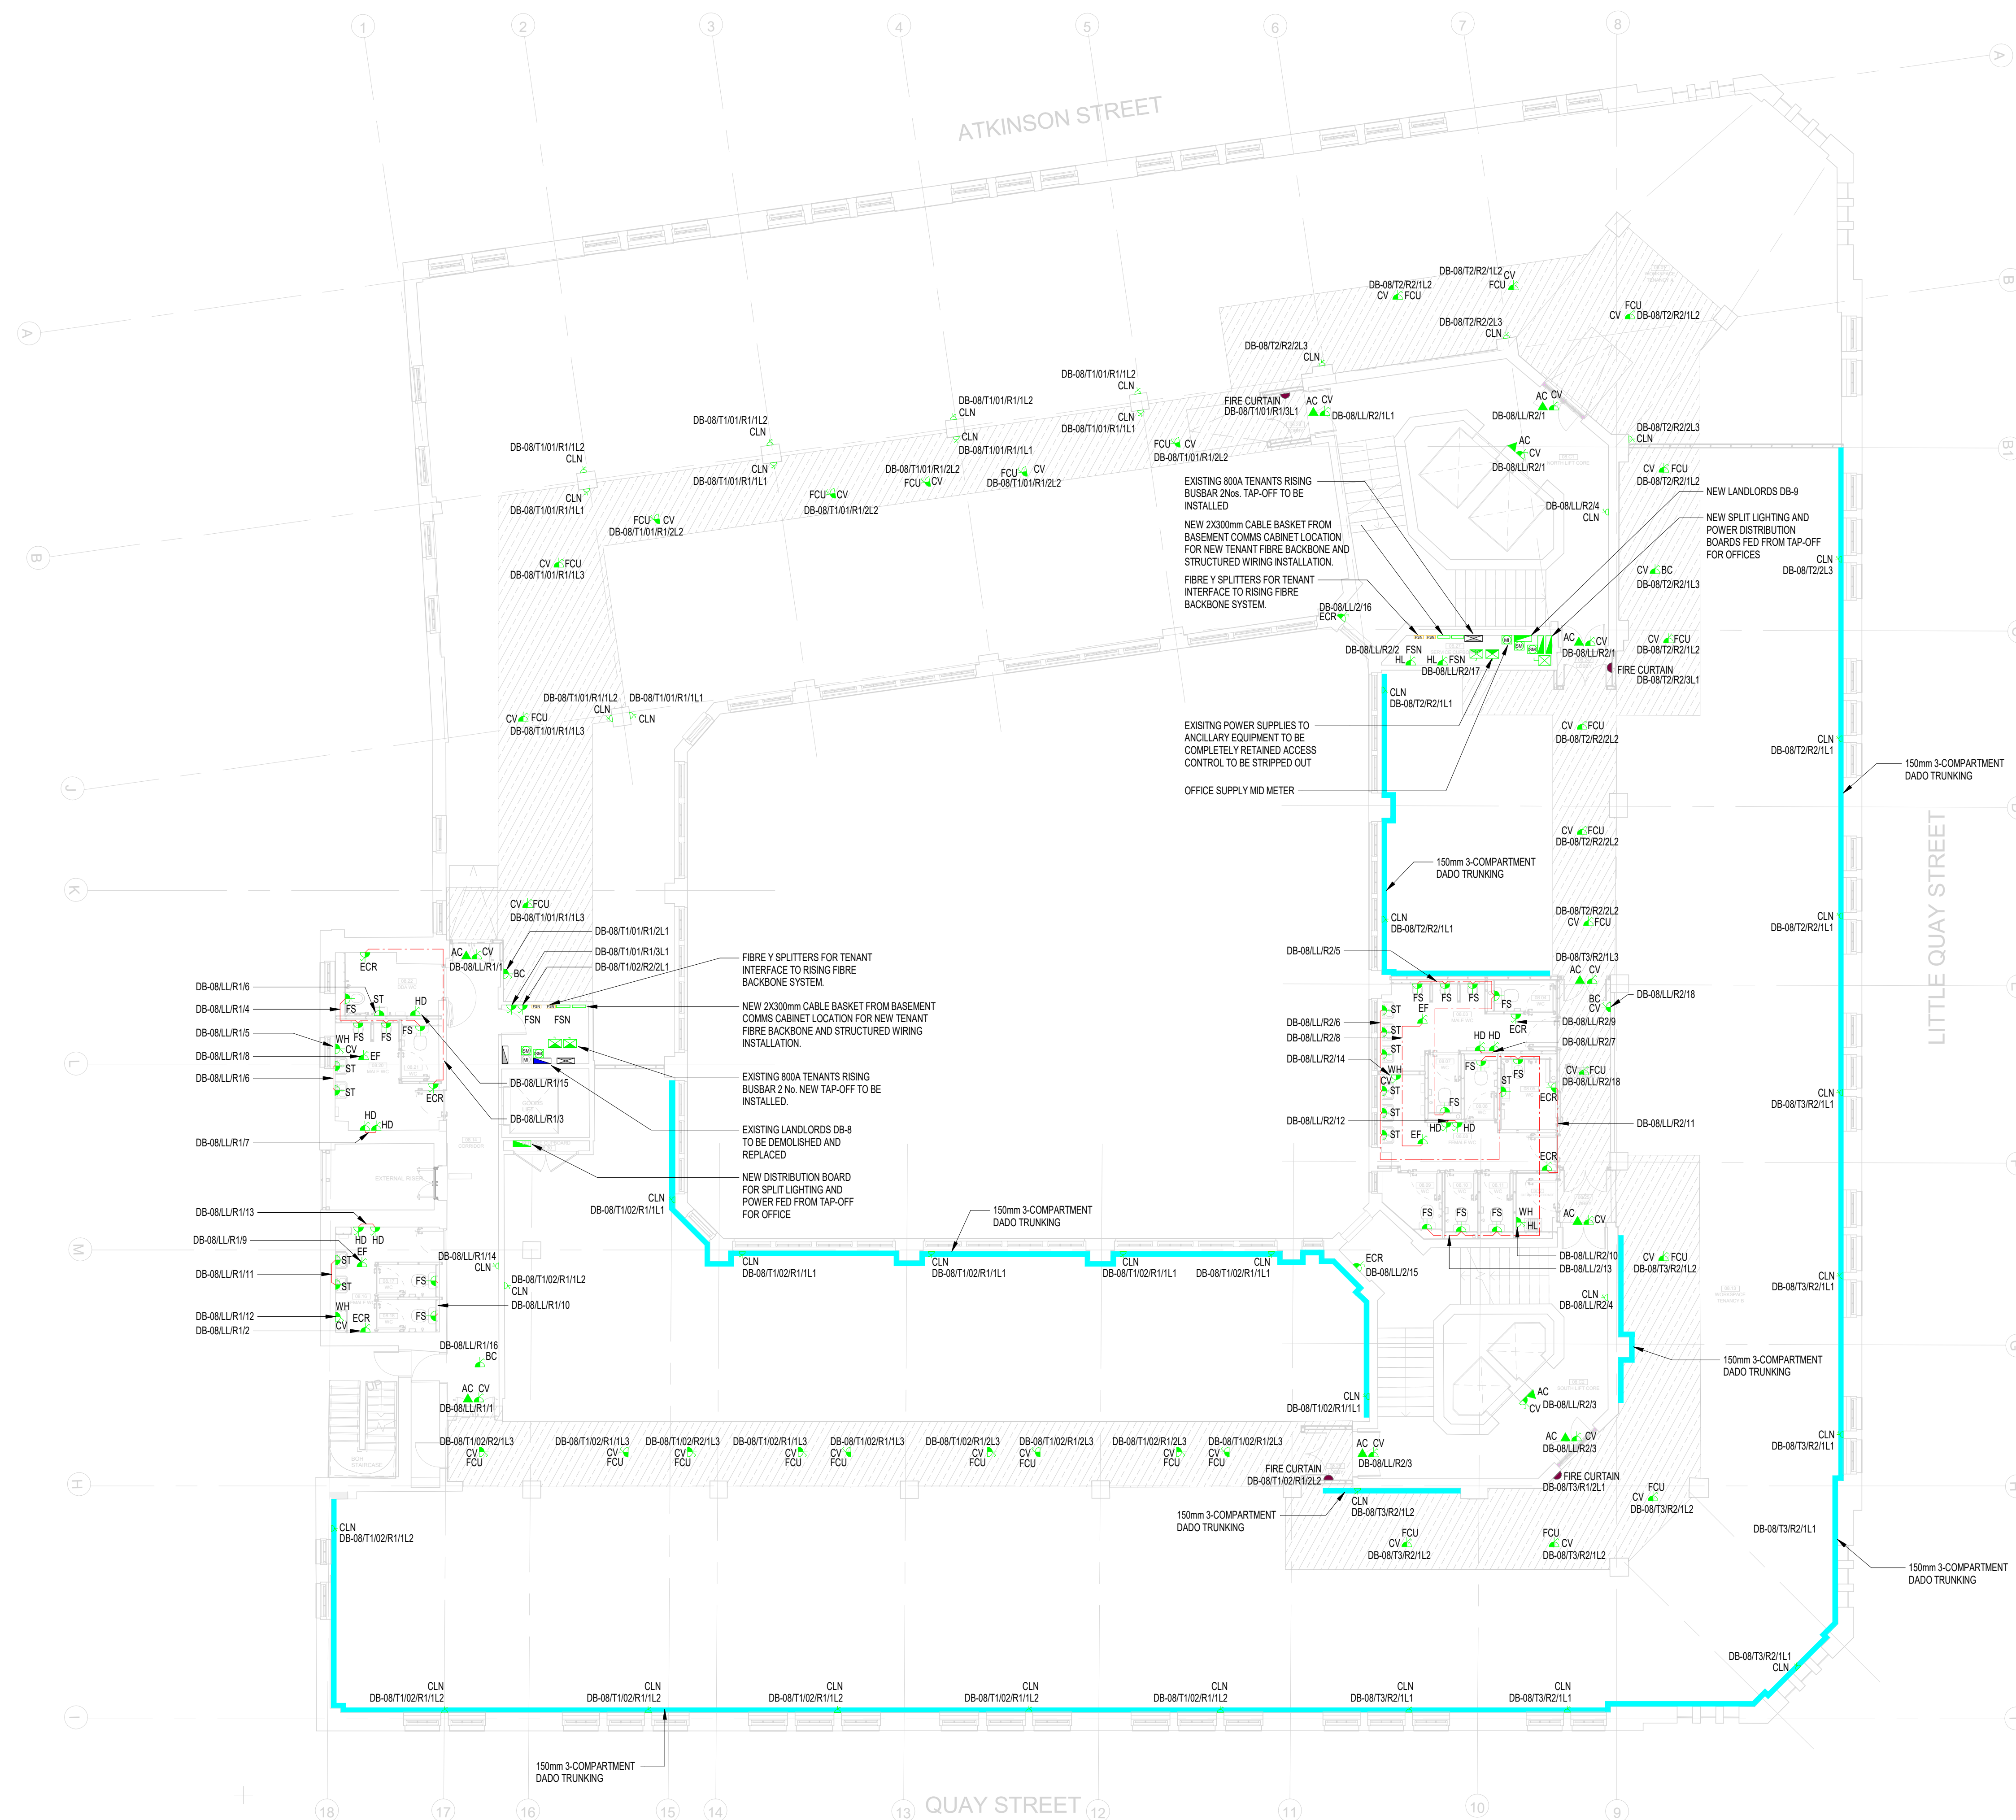

ABBREVIATIONS:

HD	HAND DRYER
EF	EXTRACT FAN
CV	CEILING VOID
EPH	ELECTRIC PANEL HEATER
ST	SENSOR TRAP
CLN	CLEANERS SOCKET
FS	FLOW SWITCH
FCU	FAN COIL UNIT
AC	ACCESS CONTROL
ECR	ELECTRIC CONTROL RADIATOR
WH	WATER HEATER
DP	DRAIN PUMP
LL	MOUNTED AT LOW LEVEL
HL	MOUNTED AT HIGH LEVEL
DAS	DISABLE ALARM SYSTEM
EAC	ELECTRIC AIR CURTAIN
FSN	FIBRE SPLITTER NODE

THIS DRAWING IS FOR INFORMATION ONLY DO NOT SCALE

CDM REGULATIONS

HAZARD	DATE ASSESSED	DATE INITIATED	DATE ASSESSED

LEGEND

- SPIN DISTRIBUTION BOARD
- TPAN DISTRIBUTION BOARD
- MAIN SWITCH BOARD/VP PANEL
- UNSWITCHED 13A SINGLE SOCKET OUTLET
- UNSWITCHED 13A TWIN SOCKET OUTLET
- SWITCHED 13A SINGLE SOCKET OUTLET
- SWITCHED 13A TWIN SOCKET OUTLET - CLN DENOTES CLEANERS SOCKET
- UNSWITCHED FUSED CONNECTION UNIT
- SWITCHED FUSED CONNECTION UNIT
- SWITCHED FUSED CONNECTION UNIT w/ NEON INDICATOR
- RED DP 13A FUSED CONNECTION UNIT w/ NEON INDICATOR & BARREL LOCK
- COMMANDO SOCKET
- DOUBLE POLE ISOLATING SWITCH (20A)
- THREE POLE ISOLATING SWITCH
- 3 POLE ISOLATOR
- SPIN ISOLATOR
- TPAN ISOLATOR
- RJ45 DATA OUTLET POINT
- TELEPHONE OUTLET POINT
- COOKER CONNECTION UNIT
- AUDIOVISUAL PLATE
- DADO TRUNKING
- HDMI PORT
- DADO DROPPERS
- EMERGENCY STOP BUTTON
- 1 No. TWIN SWITCHED SOCKET & 2 No. DATA OUTLETS (2-COMPARTMENT FLOORBOX)
- DISABLED ALARM PULL CORD SWITCH w/ INTEGRAL REASSURANCE LAMP
- RESET PUSH BUTTON
- DISABLED ALARM INDICATOR LAMP w/ INTEGRAL SOUNDER
- DISTRIBUTION UNIT BOX
- CLEANERS SOCKET FLOOR GORMET
- SOCKET & 2 No. DATA OUTLETS (4-COMPARTMENT FLOORBOX)
- UNSWITCHED FUSE SPUR FOR FIRE CURTAIN (IN COMPLIANCE WITH BS28)
- CLG-131 SUSPENDED PLASTERBOARD BULKHEAD FINISHED IN PINT-101, INCLUDE CLG-811 ACCESS PANELS
- UNDERFLOOR BUS BAR POWER TRACK

REV 14.08.24 ISSUED FOR COMMENT & APPROVAL

REV DATE AMENDMENTS BY CRO

FOR COMMENT & APPROVAL

Commercial Services Design Ltd
Unit 5
Woodside Court
Clayton Wood Rise
Little Hulton
Leeds LS18 5HF
Tel: 0113 3223190
Web: www.csdesign.uk.com

G&H
GROUP OF COMPANIES

CLIENT
G&H BUILDING SERVICES

PROJECT
**SUNLIGHT HOUSE
LITTLE QUAY STREET
MANCHESTER M3 3HP**

TITLE
**ELECTRICAL SERVICES SMALL POWER AND DATA LAYOUT
LEVEL 08**

SCALE: 1:100
DRAWN: MW
CHECKED: DB
DATE: JUNE 24
ISSUED: AUGUST 24
APPROVED: BW

1298-CSD-XX-08-DR-E-6209 P01

ARCHITECTURE IS BASED ON ANIMALLY DESIGN
ARCHITECTS DRAWING NO. S-L-H-00-PO-08-DR-A-00-08
(001) LEVEL 08 PLAN
REVISED 01.08.2024