


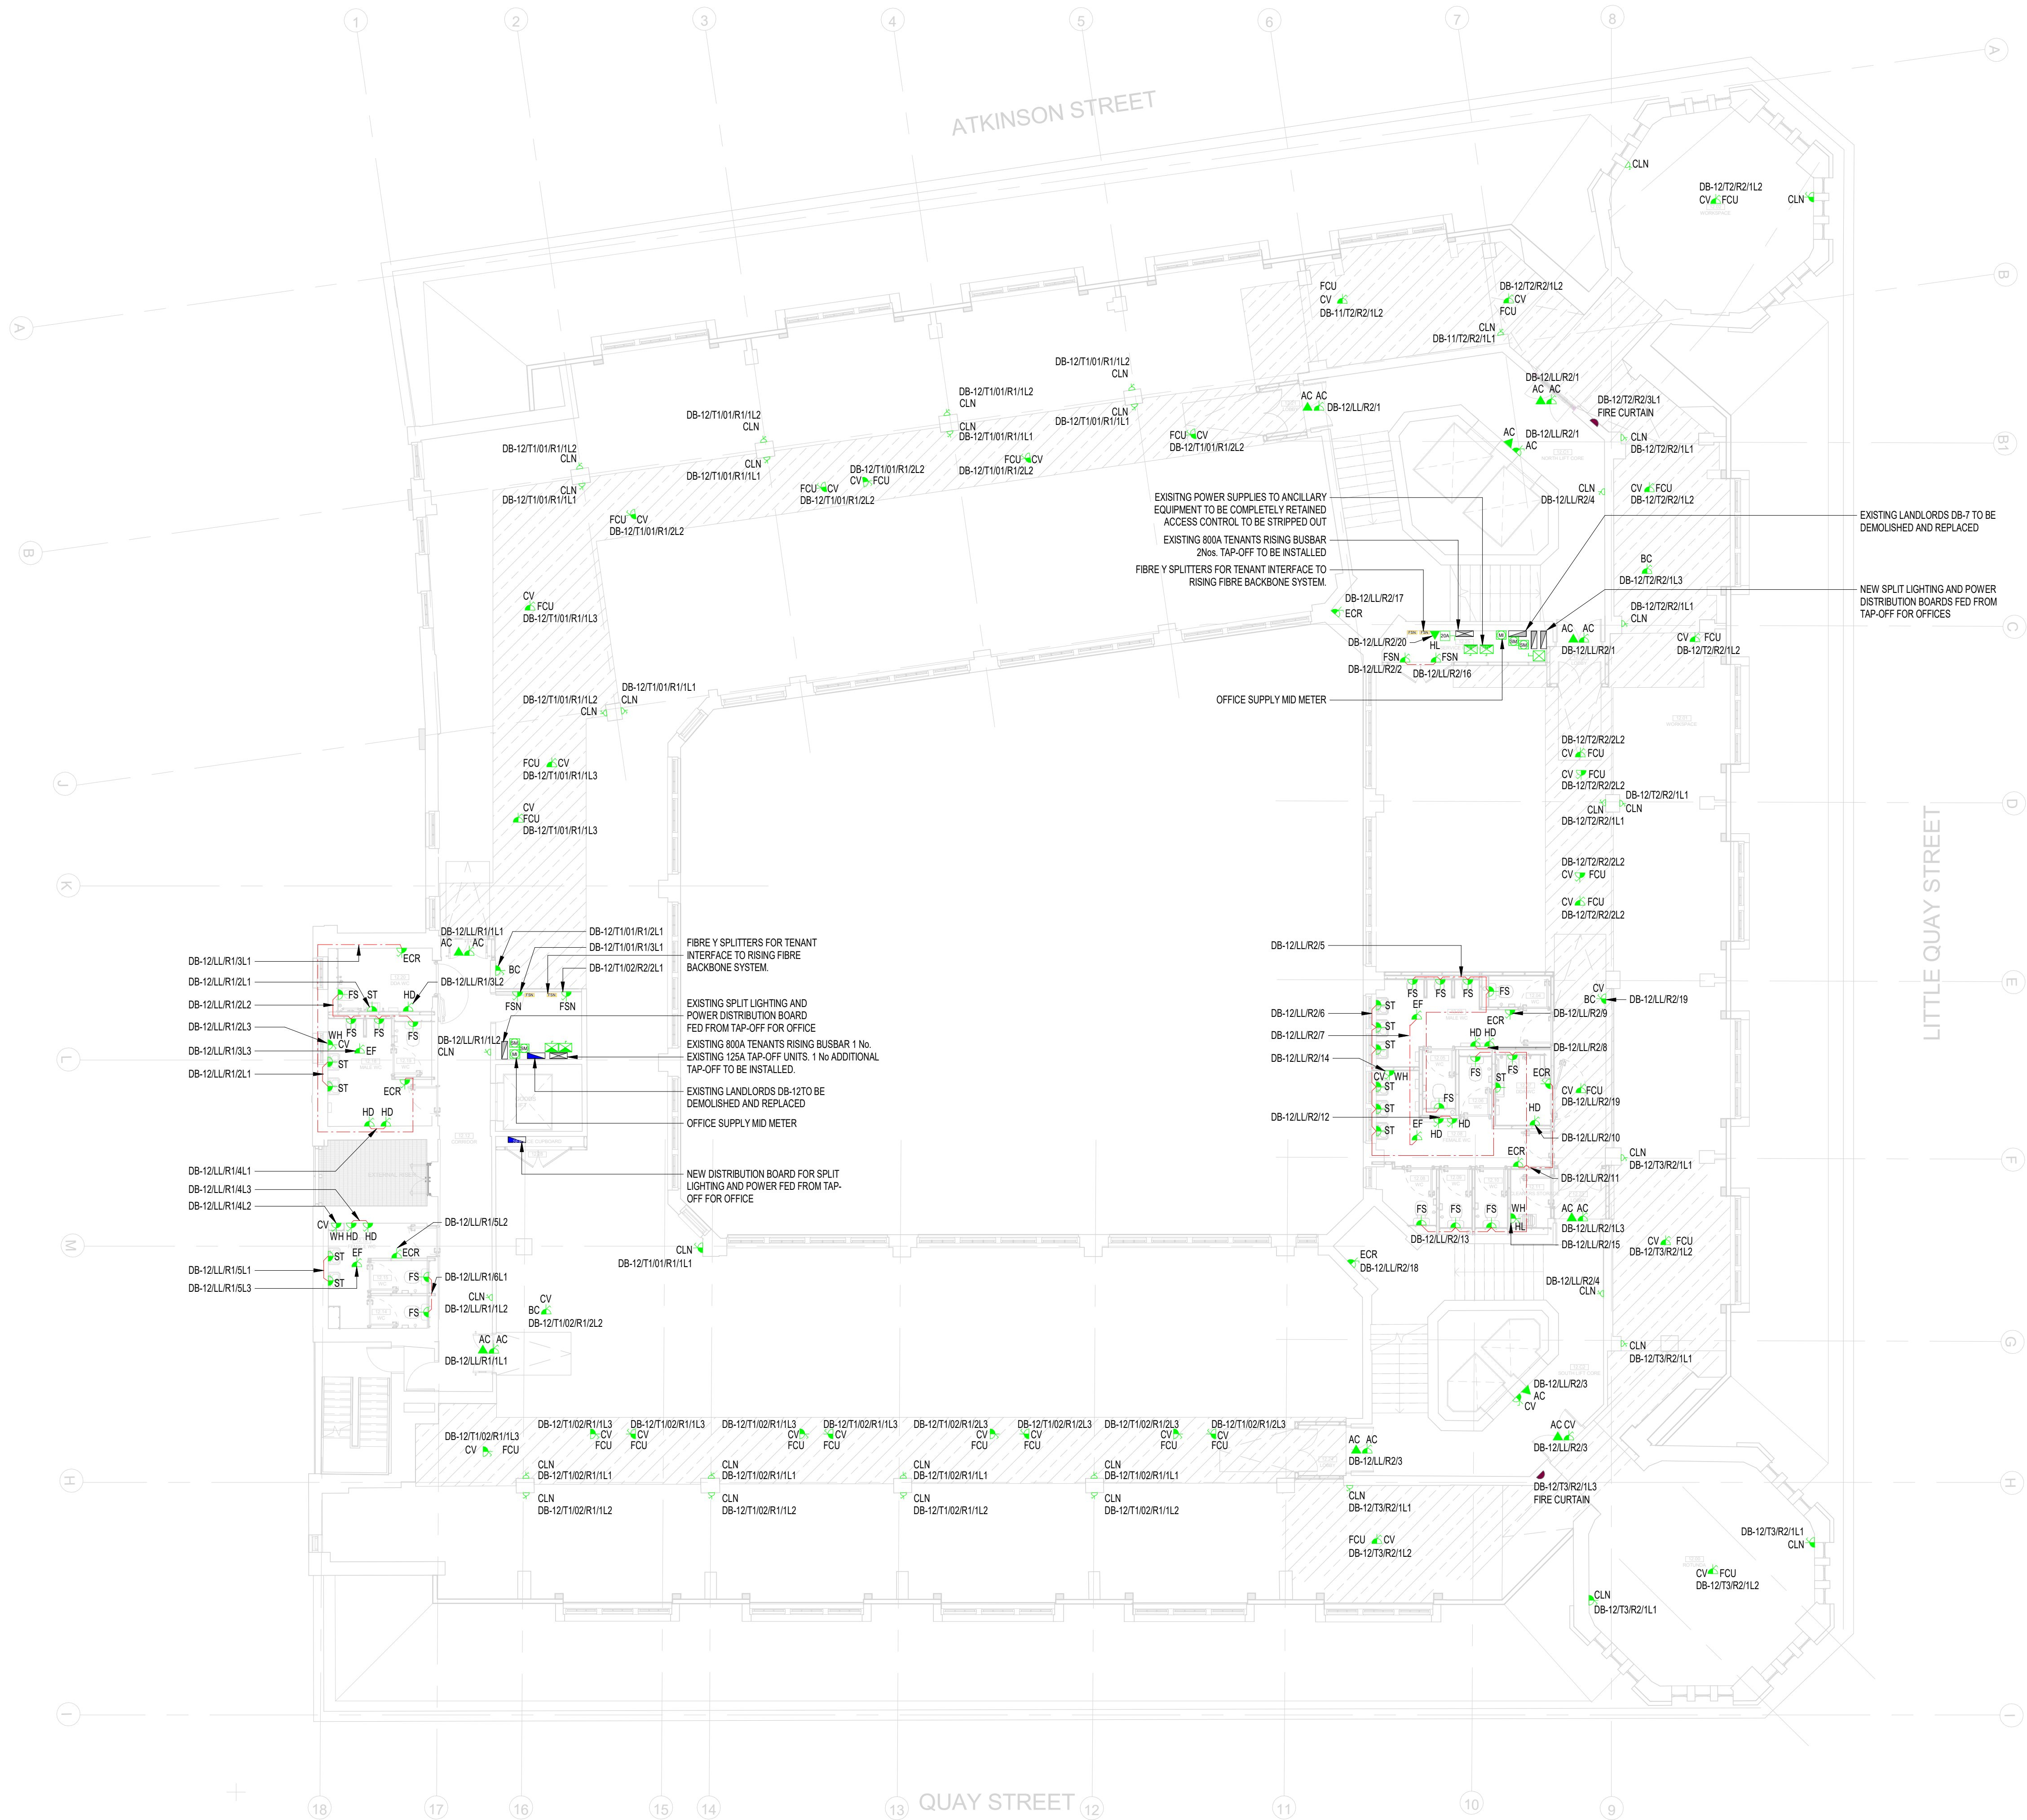

ABBREVIATIONS

HD	HAND DRYER
EF	EXTRACT FAN
CV	CEILING VOID
EPH	ELECTRIC PANEL HEATER
ST	SENSOR TRAP
CLN	CLEANERS SOCKET
FS	FLOW SWITCH
FCU	FAN COIL UNIT
AC	ACCESS CONTROL
ECR	ELECTRIC CONTROL RADIATOR
WH	WATER HEATER
DP	DRAIN PUMP
LL	MOUNTED AT LOW LEVEL
ML	MOUNTED AT MID LEVEL
HL	MOUNTED AT HIGH LEVEL
DAS	DISABLE ALARM SYSTEM
EAC	ELECTRIC AIR CURTAIN
HT	HOT WATER TAP
FSN	FIBRE SPLITTER NODE
BC	BRANCH CONTROLLER
FR	FRIDGE
MW	MICROWAVE
WT	WORK TOP (FOR KITCHENETTES)
BWT	BELOW WORK TOP (FOR KITCHENETTES)
DW	DISH WASHER

THIS DRAWING IS FOR INFORMATION ONLY DO NOT SCALE

CDM REGULATIONS

NUMBER	DATE ISSUED	DATE INITIATED	DATE ASSESSMENT

LEGEND

- SPAN DISTRIBUTION BOARD
- TPAN DISTRIBUTION BOARD
- MAIN SWITCH BOARD/LY PANEL
- UNSWITCHED 13A SINGLE SOCKET OUTLET
- SWITCHED 13A SINGLE SOCKET OUTLET
- TWIN 13A SWITCHED SOCKET OUTLET - CLN DENOTES CLEANERS SOCKET
- UNSWITCHED FUSED CONNECTION UNIT
- SWITCHED FUSED CONNECTION UNIT
- SWITCHED FUSED CONNECTION UNIT w/ NEON INDICATOR
- RED DP 13A FUSED CONNECTION UNIT w/ NEON INDICATOR & BAREL LOCK
- COMMAND SOCKET
- DOUBLE POLE ISOLATING SWITCH (20A)
- THREE POLE ISOLATING SWITCH
- 3 POLE ISOLATOR
- TPAN ISOLATOR
- RJ45 DATA OUTLET POINT
- TELEPHONE OUTLET POINT
- COOKER CONNECTION UNIT
- AUDIOVISUAL PLATE
- DADO TRUNKING
- HDM PORT
- DADO DROPPERS
- EMERGENCY STOP BUTTON
- 1 No. TWIN SWITCHED SOCKET & 2 No. DATA OUTLETS (2 COMPARTMENT FLOORBOX)
- DISABLED ALARM PULL CORD SWITCH w/ INTEGRAL REASSURANCE LAMP
- RESET PUSH BUTTON
- DISABLED ALARM INDICATOR LAMP w/ INTEGRAL SOUNDER
- 3 COMPARTMENT DADO DROPPER
- DISTRIBUTION UNIT BOX
- CLEANERS SOCKET FLOOR GORMET
- SOCKET & 2m DATA OUTLETS (4 COMPARTMENT FLOORBOX)
- UNSWITCHED FUSE SPUR FOR FIRE CURTAIN (IN COMPLIANCE WITH BS284)
- CLG-131 SUSPENDED PLASTERBOARD BULKHEAD FINISHED IN PINT-101, INCLUDE CLG-911 ACCESS PANELS
- 6A UNDERFLOOR BUS BAR POWER TRACK
- FIBRE SPLITTER NODE
- SMART METER
- MID METER
- WIFI AP
- BOOSTER PUMP
- INVERTER

REV	DATE	AMENDMENTS	BY	CHKD

FOR COMMENT & APPROVAL

Commercial Services Design Ltd
Unit 5
Woodside Court
Clayton Wood Rise
LE11 5HF
Tel: 0113 3223190
Web: www.csdesign.co.uk

G&H
GROUP OF COMPANIES

CLIENT
G&H BUILDING SERVICES

PROJECT
**SUNLIGHT HOUSE
LITTLE QUAY STREET
MANCHESTER M3 3HP**

TITLE
**ELECTRICAL SERVICES SMALL POWER AND DATA LAYOUT
LEVEL 12**

SCALE @ 1:100	DESIGN	CSD 1298
DRAWN	ENGINEER	DB
DATE	ISSUED	AUGUST 24
REVISION	APPROVED	BW

1298-CSD-XX-12-DR-E-6213 P01

ARCHITECTURE IS BASED ON ANIMALLY DESIGN
ARCHITECTS DRAWING NO. S-H-AND-PO-12-DR-AUG12
(001) LEVEL 12 PLAN
REVISED 01.08.2024