


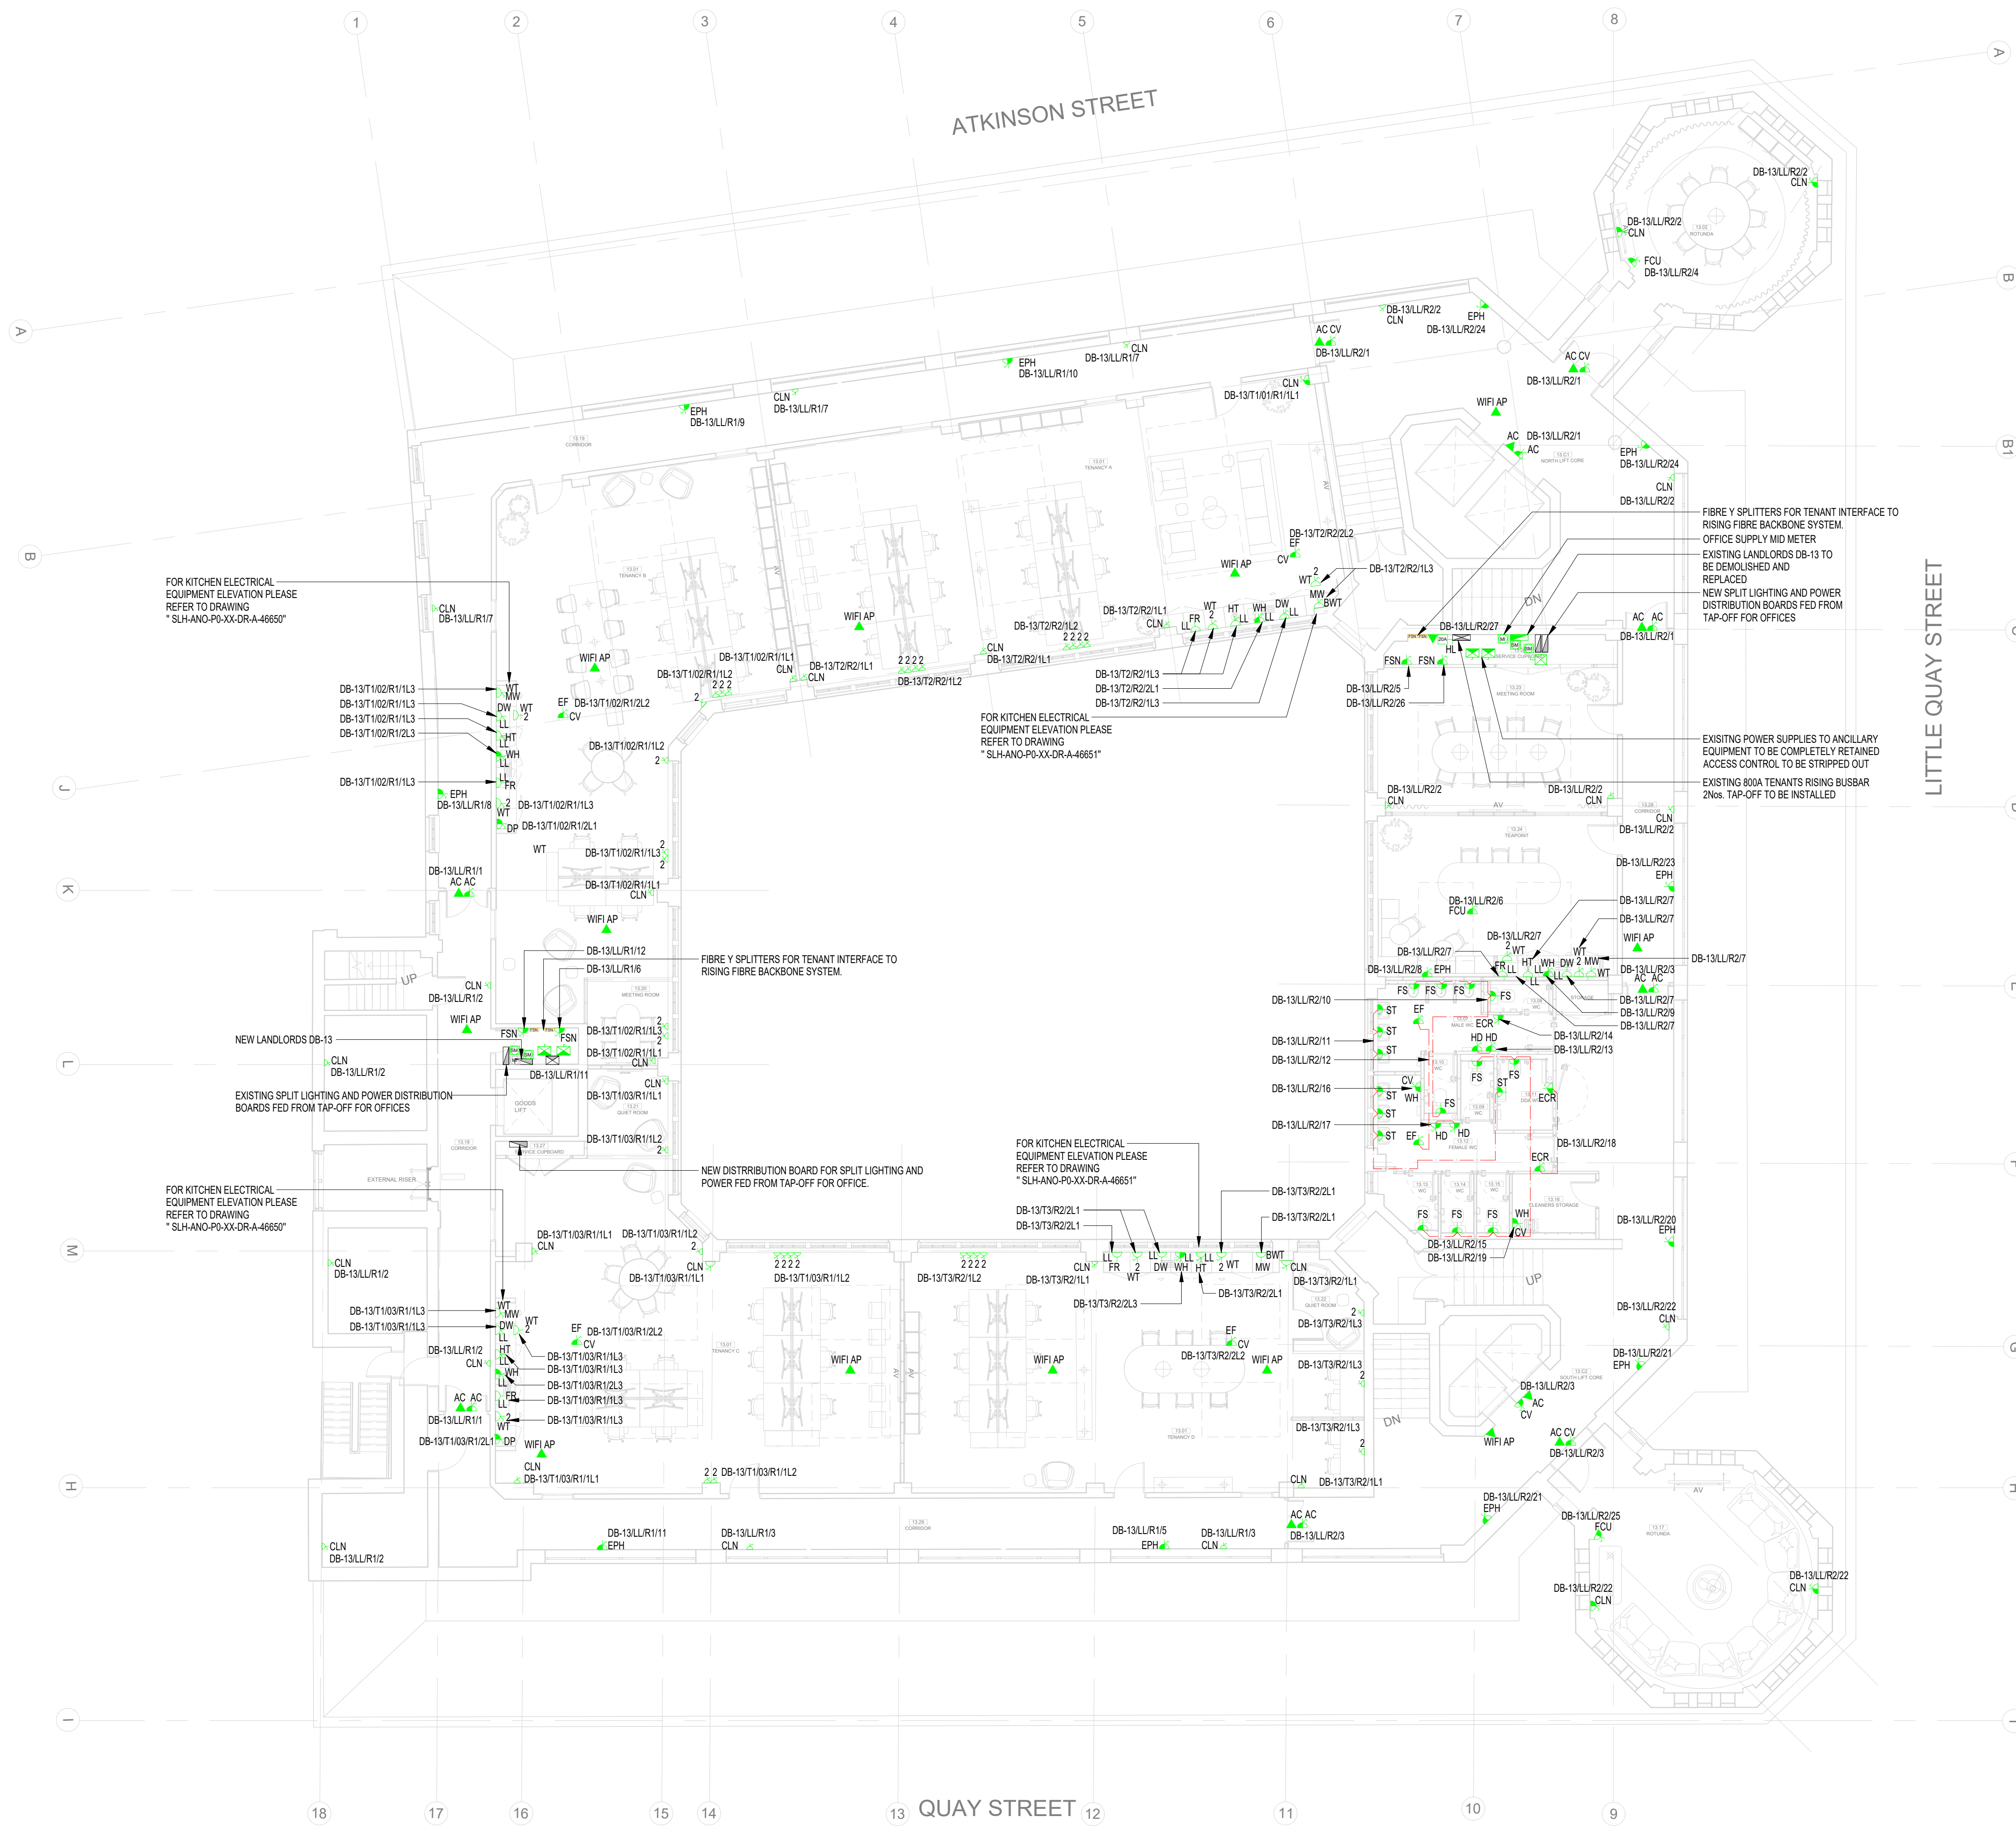

ABBREVIATIONS			
HD	HAND DRYER		
EF	EXTRACT FAN		
CV	CEILING VOID		
EPH	ELECTRIC PANEL HEATER		
ST	SENSOR TRAP		
CLN	CLEANERS SOCKET		
FS	FLOW SWITCH		
FCU	FAN COIL UNIT		
AC	ACCESS CONTROL		
ECR	ELECTRIC CONTROL RADIATOR		
WH	WATER HEATER		
DP	DRAIN PUMP		
LL	MOUNTED AT LOW LEVEL		
ML	MOUNTED AT MID LEVEL		
HL	MOUNTED AT HIGH LEVEL		
DAS	DISABLE ALARM SYSTEM		
EAC	ELECTRIC AIR CURTAIN		
HT	HOT WATER TAP		
FSN	FIBRE SPLITTER NODE		
BC	BRANCH CONTROLLER		
FR	FRIDGE		
MW	MICROWAVE		
WT	WORK TOP (FOR KITCHENETTES)		
BWT	BELOW WORK TOP (FOR KITCHENETTES)		
DW	DSH WASHER		

THIS DRAWING IS FOR INFORMATION ONLY DO NOT SCALE

COM REGULATIONS

REVISIONS	DATE	DATE	DATE

LEGEND:

- SPAN DISTRIBUTION BOARD
- SPAN SWITCH BOARD/LY PANEL
- UNSWITCHED 13A SINGLE SOCKET OUTLET
- UNSWITCHED 13A TWIN SOCKET OUTLET
- SWITCHED 13A SINGLE SOCKET OUTLET
- SWITCHED 13A TWIN SOCKET OUTLET
- TWIN 13A SWITCHED SOCKET OUTLET
- UNSWITCHED FUSED CONNECTION UNIT
- SWITCHED FUSED CONNECTION UNIT
- SWITCHED FUSED CONNECTION UNIT w/ NEON INDICATOR
- RED DP 13A FUSED CONNECTION UNIT w/ NEON INDICATOR & BARREL LOCK
- COMMANDO SOCKET
- DOUBLE POLE ISOLATING SWITCH (20A)
- THREE POLE ISOLATING SWITCH
- 3 POLE ISOLATOR
- SPAN ISOLATOR
- TWIN ISOLATOR
- RHS DATA OUTLET POINT
- TELEPHONE OUTLET POINT
- COOKER CONNECTION UNIT
- AUDIOVISUAL PLATE
- DADO TRUNKING
- HDMI PORT
- DADO DROPPERS
- EMERGENCY STOP BUTTON
- 1 No. TWIN SWITCHED SOCKET & 2 No. DATA OUTLETS (2 COMPARTMENT FLOORBOX)
- DISABLED ALARM PULL CORO SWITCH w/ INTEGRAL REASSURANCE LAMP
- RESET PUSH BUTTON
- DISABLED ALARM INDICATOR LAMP w/ INTEGRAL SOUNDER
- 3 COMPARTMENT DADO DROPPER
- DISTRIBUTION UNIT BOX
- CLEANERS SOCKET FLOOR CORMET
- SOCKET & 2No. DATA OUTLETS (4 COMPARTMENT FLOORBOX)
- UNSWITCHED FUSE SPUR FOR FIRE CURTAIN (IN COMPLIANCE WITH BS24)
- CLG-131 SUSPENDED PLASTERBOARD BLANK/HEAD FINISHED IN PINT 151, INCLUDE CLG-811 ACCESS PANELS
- 63A UNDERFLOOR BUS BAR POWER TRACK
- FIBRE SPLITTER NODE
- SMART METER
- MID METER
- WIFI AP
- BOOSTER PUMP

PREP	27.06.24	ISOMETRICS REMOVED	DB	BT
REV	21.06.24	ISSUED FOR COMMENT & APPROVAL	DB	BT
REV	DATE	AMENDMENTS	BY	CHK

FOR COMMENT & APPROVAL

Commercial Services Design Ltd
Unit 5
Woodside Court
Claydon Wood Rise
Leeds
LS16 6BP
Tel: 0113 3233190
Web: www.csdesign.co.uk

G&H
GROUP OF COMPANIES

G&H BUILDING SERVICES

SUNLIGHT HOUSE
LITTLE QUAY STREET
MANCHESTER M3 3HP

ELECTRICAL SERVICES SMALL POWER AND DATA LAYOUT
LEVEL 13

SCALE	AS SHOWN	CSO REF	CSO 1296
DATE	JUNE 24	ENGINEER	DB
DATE	JUNE 24	ENGINEER	AUGUST 24
DATE	DB	APPROVED	BT

1298-CSD-XX-13-DR-E-6214 P02

ARCHITECTURE IS BASED ON ANOMALY DESIGN
ARCHITECTS DRAWING NO. SLH-AND-PO-13-DR-A-05113
(C01) LEVEL 13 PLAN
RECEIVED 03.06.2024