


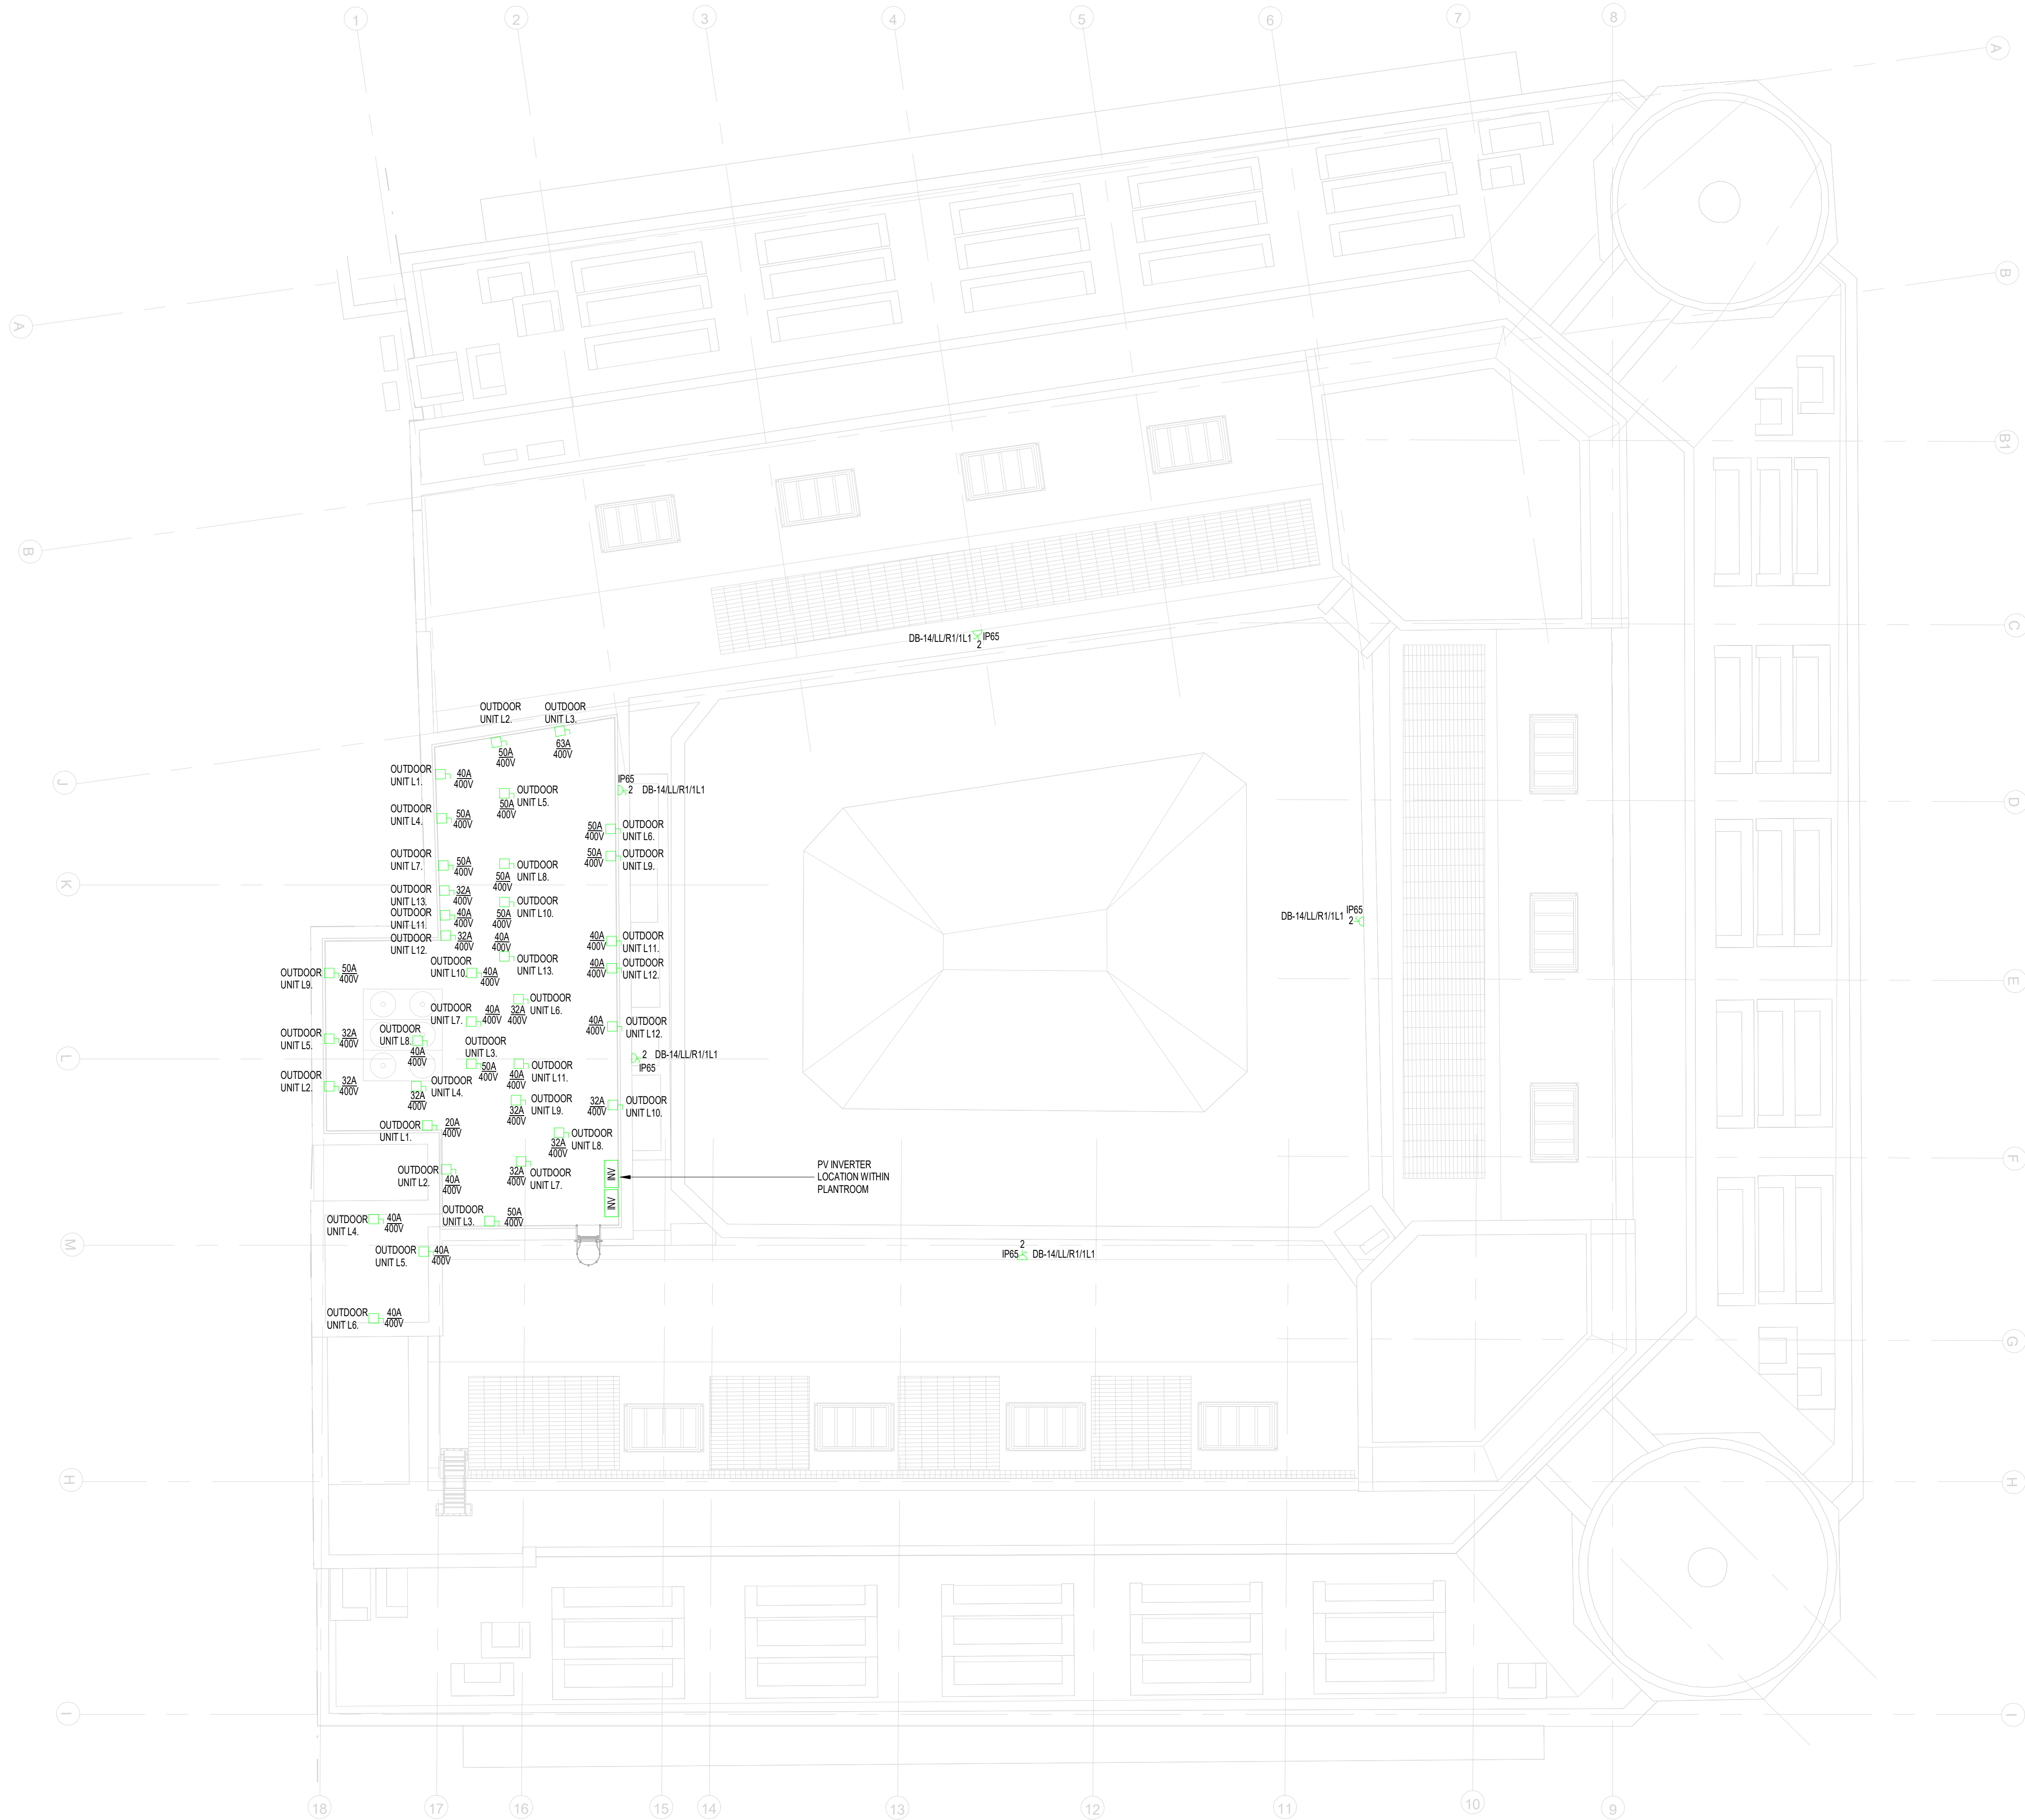

ABBREVIATIONS	
HD	HAND DRYER
EF	EXTRACT FAN
CV	CEILING VOID
EPH	ELECTRIC PANEL HEATER
ST	SENSOR TRAP
CLN	CLEANERS SOCKET
FS	FLOW SWITCH
FCU	FAN COIL UNIT
AC	ACCESS CONTROL
ECR	ELECTRIC CONTROL RADIATOR
WH	WATER HEATER
DP	DRAIN PUMP
LL	MOUNTED AT LOW LEVEL
ML	MOUNTED AT MD LEVEL
HL	MOUNTED AT HIGH LEVEL
DAS	DISABLE ALARM SYSTEM
EAC	ELECTRIC AIR CURTAIN
HT	HOT WATER TAP
FSN	FIBRE SPLITTER NODE
BC	BRANCH CONTROLLER
FR	FRIDGE
MW	MICROWAVE
WT	WORK TOP (FOR KITCHENETTES)
BWT	BELOW WORK TOP (FOR KITCHENETTES)
DW	DISH WASHER

THIS DRAWING IS FOR INFORMATION ONLY DO NOT SCALE

CDM REGULATIONS

NOTES	DATE ADDED	DATE INITIATED	DATE ASSESSMENT

LEGEND

SPIN DISTRIBUTION BOARD

TPAN DISTRIBUTION BOARD

MAIN SWITCH BOARD/LV PANEL

UNSWITCHED 13A SINGLE SOCKET OUTLET

UNSWITCHED 13A TWIN SOCKET OUTLET

SWITCHED 13A SINGLE SOCKET OUTLET

SWITCHED 13A TWIN SOCKET OUTLET - CLN DENOTES CLEANERS SOCKET

UNSWITCHED FUSED CONNECTION UNIT

SWITCHED FUSED CONNECTION UNIT

SWITCHED FUSED CONNECTION UNIT w/ NEON INDICATOR

RED DP 13A FUSED CONNECTION UNIT w/ NEON INDICATOR & BARREL LOCK

COMMANDO SOCKET

DOUBLE POLE ISOLATING SWITCH (20A)

THREE POLE ISOLATING SWITCH

3 POLE ISOLATOR

SPIN ISOLATOR

TPAN ISOLATOR

RJ45 DATA OUTLET POINT

TELEPHONE OUTLET POINT

COOKER CONNECTION UNIT

AUDIOVISUAL PLATE

DADO TRUNKING

HDMI

HDMI PORT

DADO DROPPERS

EMERGENCY STOP BUTTON

1 No. TWIN SWITCHED SOCKET & 2 No. DATA OUTLETS (2 COMPARTMENT FLOORBOX)

DISABLED ALARM PULL CORD SWITCH w/ INTEGRAL REASSURANCE LAMP

RESET PUSH BUTTON

DISABLED ALARM INDICATOR LAMP w/ INTEGRAL SOUNDER

3 COMPARTMENT DADO DROPPER

DISTRIBUTION UNIT BOX

CLEANERS SOCKET FLOOR GORMET

SOCKET & 2No. DATA OUTLETS (4 COMPARTMENT FLOORBOX)

UNSWITCHED FUSE SPUR FOR FIRE CURTAIN (IN COMPLIANCE WITH BS24)

CLG-131 SUSPENDED PLASTERBOARD BULKHEAD FINISHED IN PFC-101, INCLUDE CLG-911 ACCESS PANELS

63A UNDERFLOOR BUS BAR POWER TRACK

FSN

FIBRE SPLITTER NODE

SM

SMART METER

MM

MID METER

WIFI AP

BOOSTER PUMP

INVERTER

REV	DATE	AMENDMENTS	BY	CHKD
001	20.08.24	ISSUED FOR COMMENT & APPROVAL	SB	SH

FOR COMMENT & APPROVAL

Commercial Services Design Ltd

Unit 5
Woodside Court
Claydon Wood Rise
L31 15 8HF
Tel: 0113 3223190
Web: www.csdesign.uk.com

CLIENT

G&H BUILDING SERVICES

PROJECT

SUNLIGHT HOUSE
LITTLE QUAY STREET
MANCHESTER M3 3HP

TITLE

ELECTRICAL SERVICES SMALL POWER AND DATA LAYOUT ROOF

SCALE: 1:100	CD REF: CSD 1298
DRAWN: MW	ENGINEER: DB
STARTED: AUGUST 24	ISSUED: AUGUST 24
DESIGNED: DB	APPROVED: BW
1298-CSD-XX-RF-DR-E-6216	P01

PROJECT ORIGINATOR: V&A/ARL/Local Type: Electrical Drawing Number

THIS DRAWING IS THE PROPERTY OF COMMERCIAL SERVICES DESIGN LTD. IT IS LOANED TO YOU BY THE CLIENT AND IS NOT TO BE REPRODUCED OR USED IN ANY MANNER WITHOUT THE WRITTEN PERMISSION OF COMMERCIAL SERVICES DESIGN LTD. THE DRAWING IS TO BE USED FOR THE PROJECT AND NO OTHER PROJECTS.