




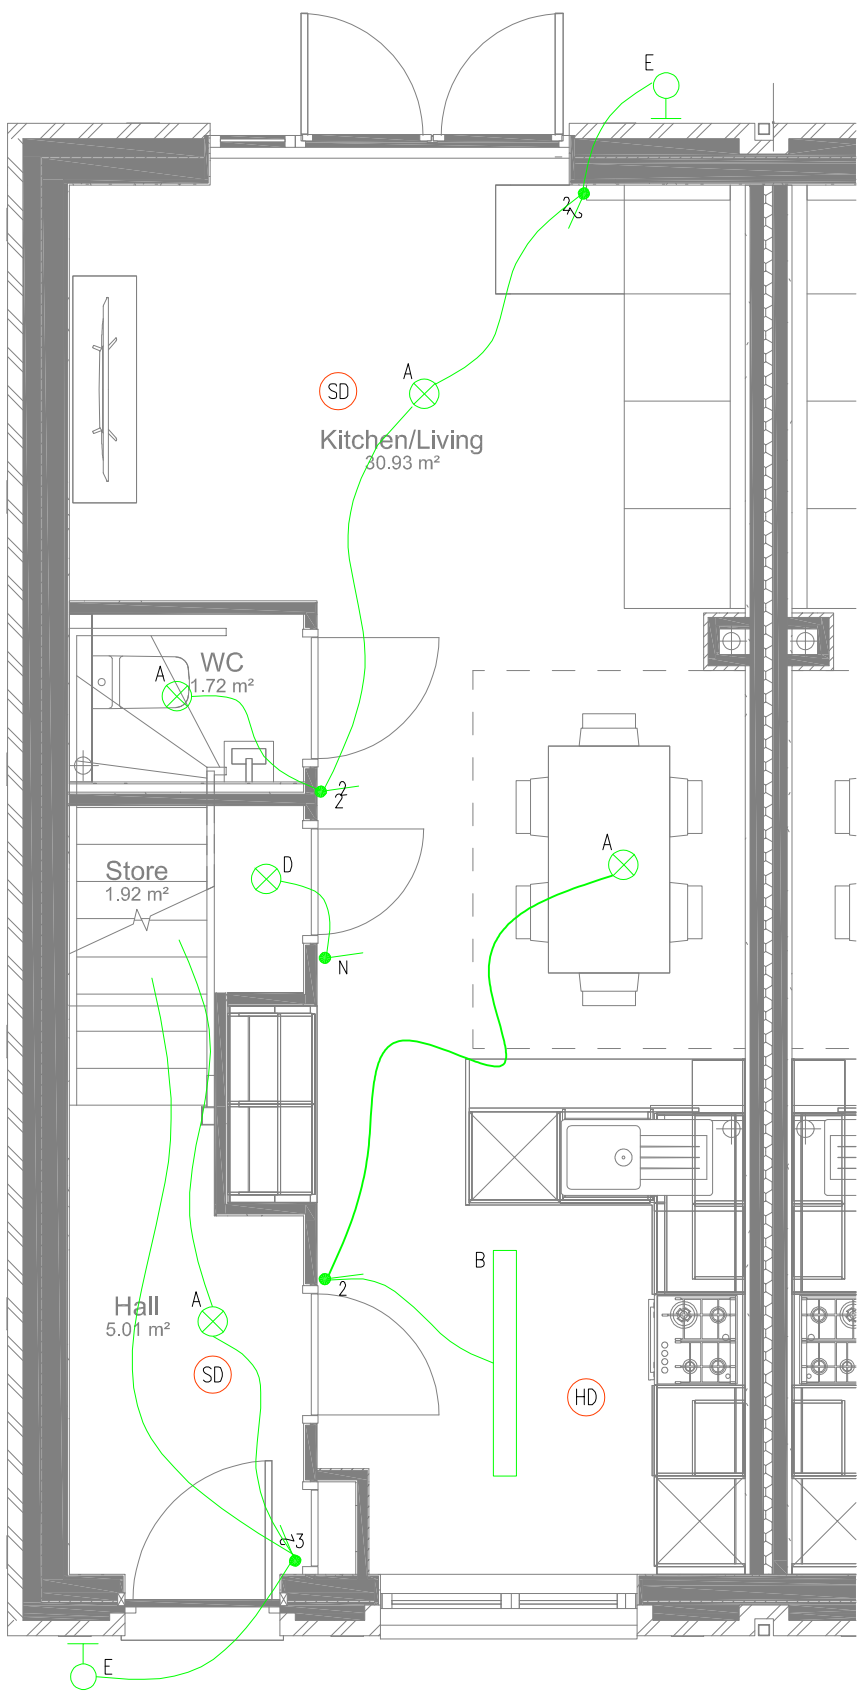


NOTE:
REF 'A' LIGHT FITTING AND
LIGHTSWITCH TO BE INSTALLED
IN LOFT SPACE

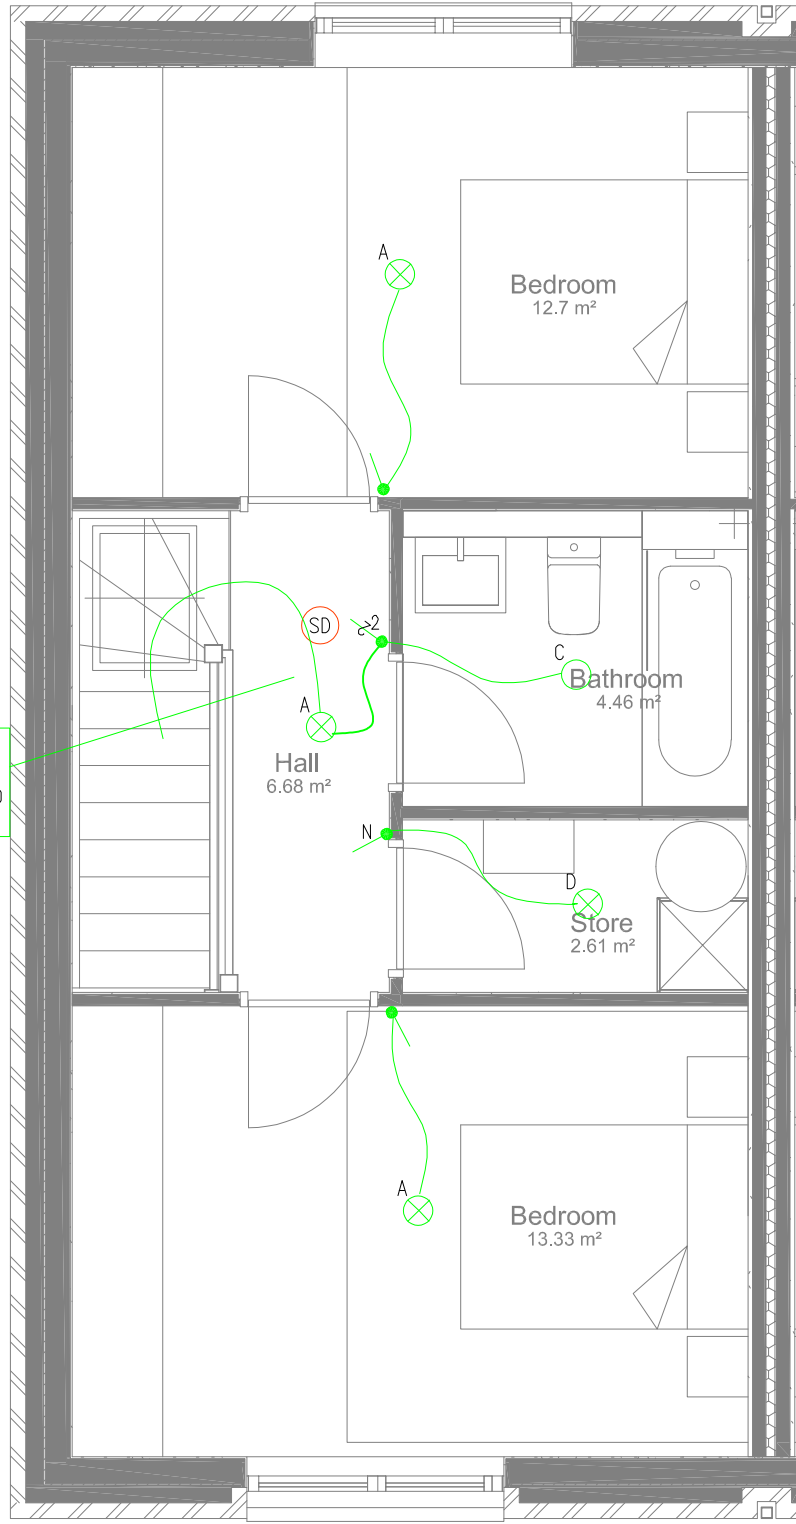

NOTE:
SINGLE GANG OUTLET IN ROOF
SPACE FOR TV AMPLIFICATION

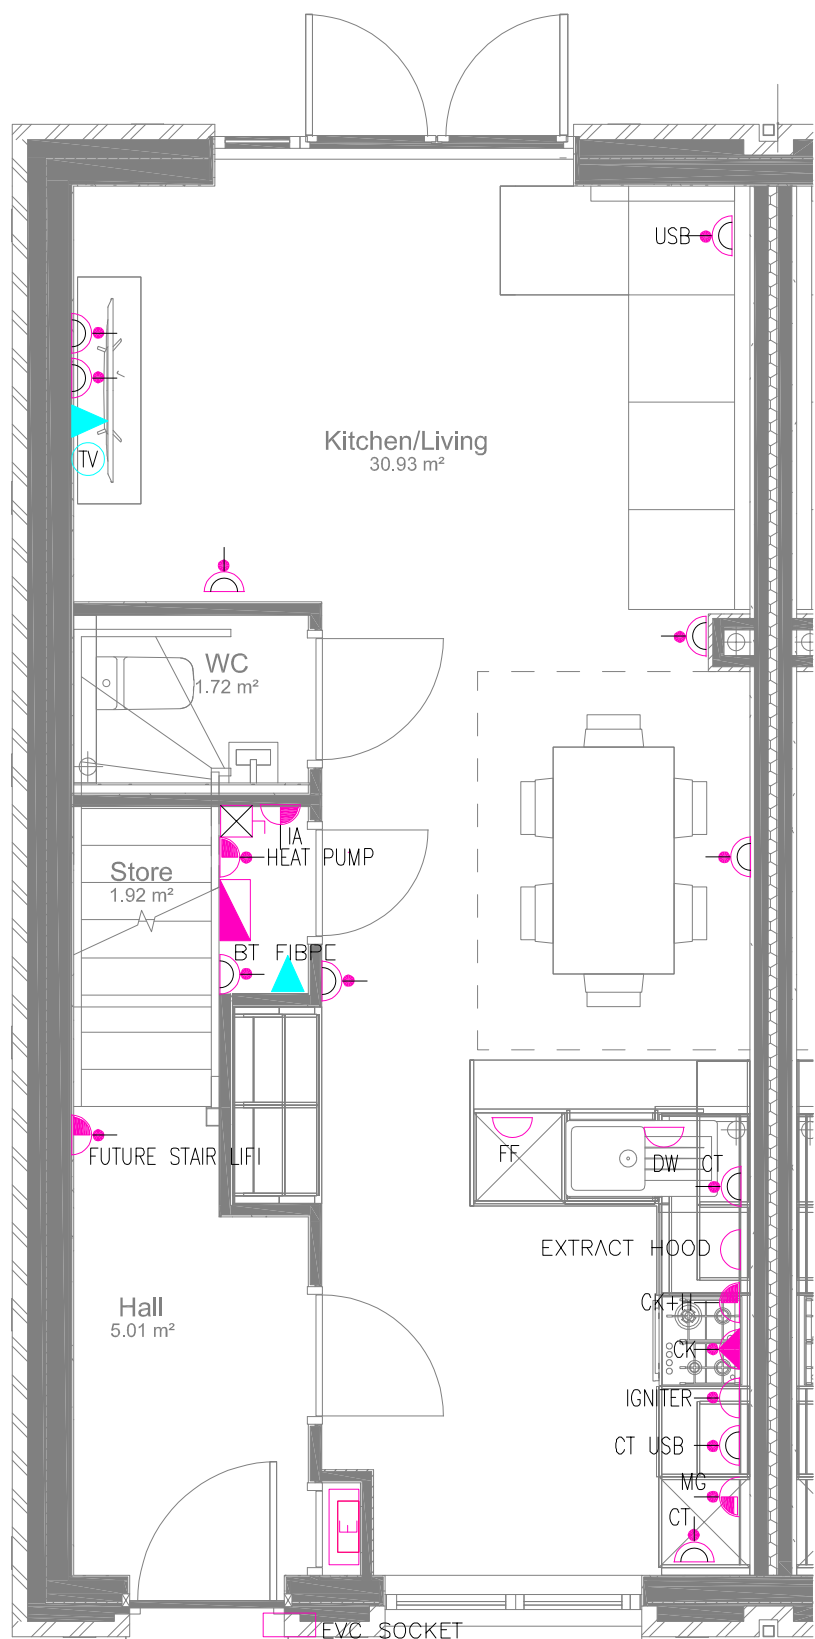


NOTE:
SINGLE GANG OUTLET IN ROOF
SPACE FOR TV AMPLIFICATION

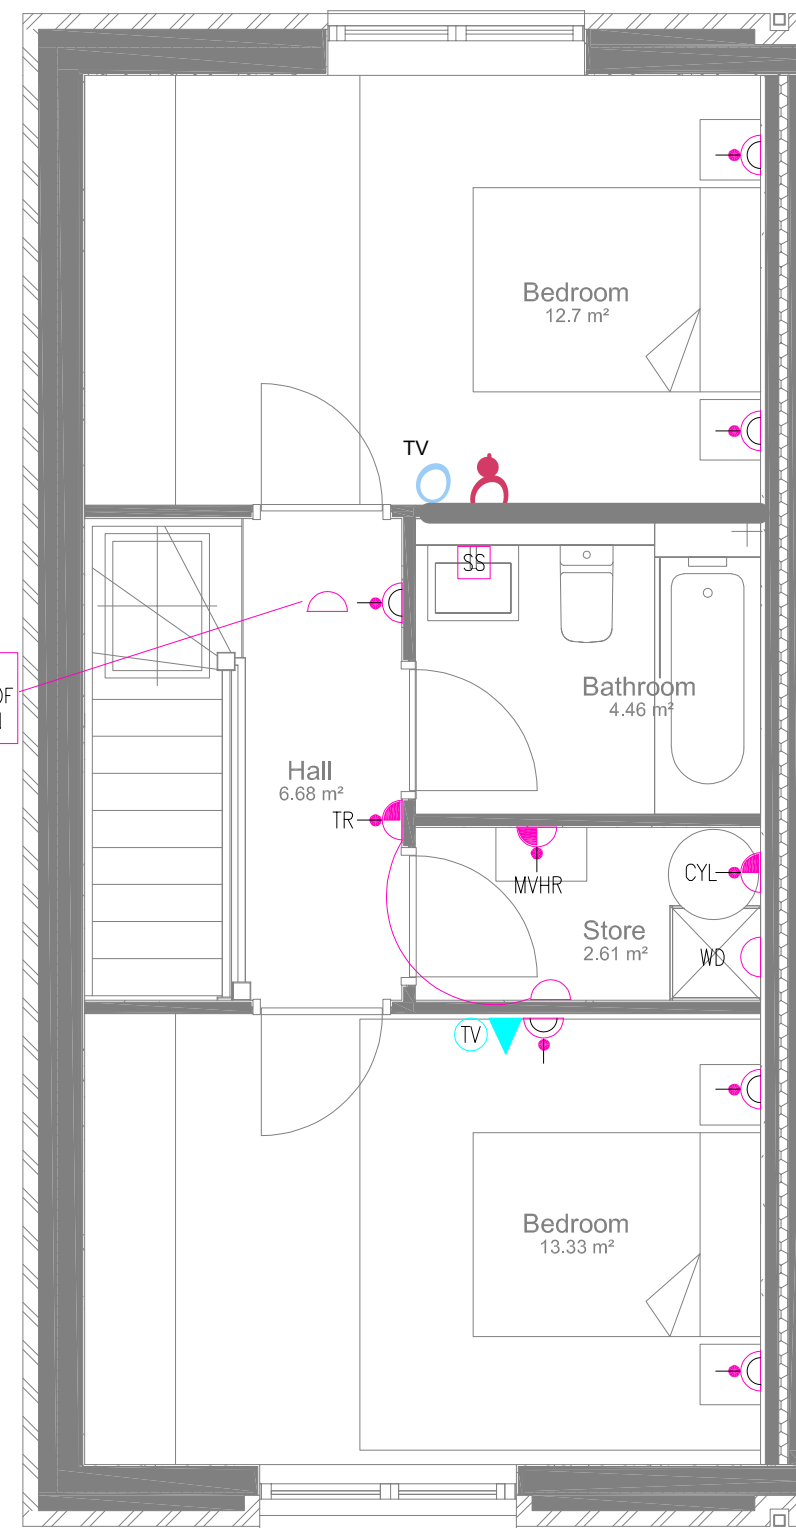

NOTE:
SINGLE GANG OUTLET IN ROOF
SPACE FOR TV AMPLIFICATION

- LIGHTING LEGEND:**
- A: PENDANT LUMINAIRE
 - B: LIGHTING BAR C/W 4 NO LED SPOTS
 - C: IP65 WHITE CIRCULAR LED BULKHEAD FITTING
 - D: BATTEN LIGHT FITTING
 - E: IP65 EXTERNAL LOW ENERGY LIGHT
 - ✓: SINGLE GANG LIGHTSWITCH
 - 2: 2 WAY LIGHTSWITCH
 - 2: 2 GANG LIGHTSWITCH
 - N: LIGHTSWITCH C/W NEON INDICATOR SWITCH
- (REFER TO LUMINAIRE SCHEDULE FOR FITTING TYPES)
- FIRE ALARM LEGEND:**
- SD: SMOKE DETECTOR/SOUNDER, MAINS POWERED WITH BATTERY BACKUP
 - HD: HEAT DETECTOR/SOUNDER, MAINS POWERED WITH BATTERY BACKUP

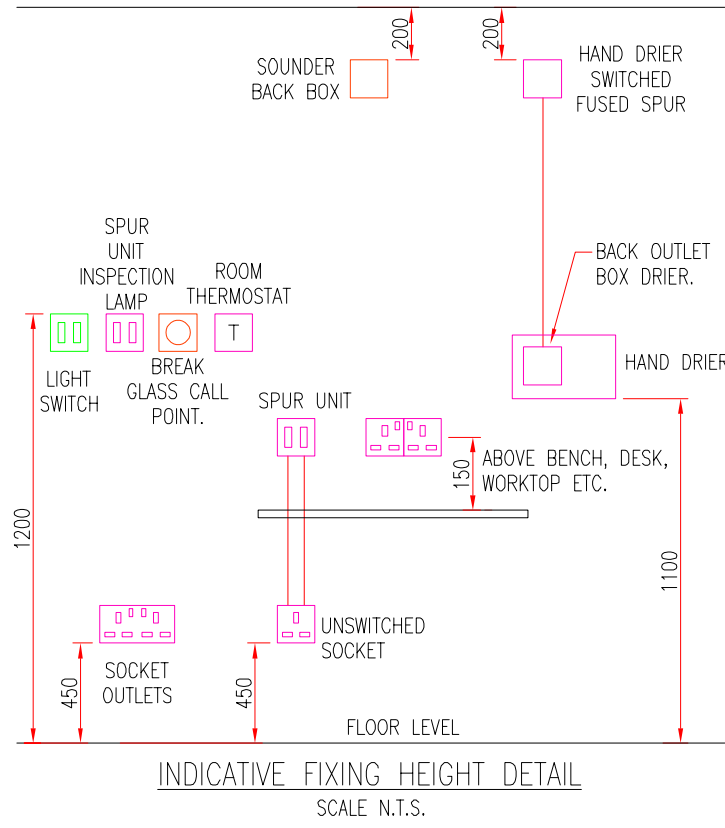

- SMALL POWER LEGEND:**
- UNSWITCHED SINGLE SOCKET OUTLET
 - SWITCHED SINGLE SOCKET OUTLET
 - SWITCHED DOUBLE SOCKET OUTLET
 - USB-DOUBLE SOCKET C/W DUAL USB OUTLETS
 - CT: SWITCHED DOUBLE SOCKET OUTLET MOUNTED 150mm ABOVE KITCHEN COUNTER
 - SWITCHED FUSED CONNECTION UNIT
 - EF-EXTRACT FAN
 - MWHR-MWHR UNIT
 - CYL-CYLINDER
 - MG-MULTIGANG GRID SWITCH FOR ISOLATION OF KITCHEN APPLIANCES
 - CK+H: LOW LEVEL UN-SWITCHED CONNECTION POINT FOR OVEN AND FLEX OUTLET PLATE FOR HOB
 - CK: 45A COOKER CONTROL UNIT C/W LED MOUNTED 150mm ABOVE KITCHEN COUNTER FOR ISOLATION OF OVEN AND HOB
 - DUAL RCD RESIDENTIAL CONSUMER UNIT
 - TV: TV AERIAL POINT
 - SAT: SATELITE TV POINT
 - BT: TELEPHONE OUTLET
 - CAT 6: CAT 6 DATA OUTLET
 - SS: SHOWER SOCKET OUTLET
 - INCOMING ELECTRIC SUPPLY AND METER
 - IA: UNSWITCHED FUSED CONNECTION UNIT FOR FUTURE INSTALLATION OF INTRUDER ALARM
 - ELECTRIC PANEL HEATER
 - HEATING PROGRAMMER
 - HH: HEATING HUB
 - EVC: ELECTRIC VEHICLE CHARGING UNIT
 - DB: DOORBELL
 - DOORBELL CHIME
 - TOWEL RAIL AND FLEX OUTLET
 - 32A SP&N ISOLATOR FOR HEAT PUMP

Rev - A - 28.02.23 Updated to latest layout.



92-94 Buttermarket Street, Warrington,
Cheshire, WA1 2NZ

Tel: 01925 414884
Email: cal@dwhargreaves.co.uk

Project.

DOWNLEY DRIVE
ANCOATES
MANCHESTER

Work's.

ELECTRICAL SERVICES
PROPOSED 2 BED, 4 PERSON TERRACE
AFFORDABLE RENT

Date: FEB 2023 Scale: 1:50 @ A1

Drn By. DMH Checked By. CP

Rev - A Drawing No. E01

STATUS - APPROVAL